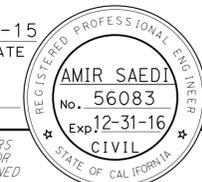


Dist	COUNTY	ROUTE	POST MILES TOTAL PROJECT	SHEET No.	TOTAL SHEETS
05	SB	101	2.2/3.3	402	786
			12-4-15	DATE	
REGISTERED CIVIL ENGINEER					
12-7-15			PLANS APPROVAL DATE		
					
<small>THE STATE OF CALIFORNIA OR ITS OFFICERS OR AGENTS SHALL NOT BE RESPONSIBLE FOR THE ACCURACY OR COMPLETENESS OF SCANNED COPIES OF THIS PLAN SHEET.</small>					

GENERAL NOTES

SPECIFICATIONS

DESIGN: AASHTO STANDARD SPECIFICATIONS FOR STRUCTURAL SUPPORTS FOR HIGHWAY SIGNS, LUMINAIRES, AND TRAFFIC SIGNALS DATED 2010.

LOADING

WIND LOADINGS: 100 MPH




 
UNIT STRESSES

STRUCTURAL STEEL:
 FY= 48,000 PSI TAPERED STEEL POLE
 FY= 36,000 PSI UNLESS OTHERWISE NOTED.

NOTES:

1. ANCHORAGE MUST BE ACCOMPLISHED WITH ASTM A307 ALL ANCHOR BOLTS WITH TWO HEX NUTS AND FLAT WASHERS FOR EACH. TOP 8' OF THREADED RODS SHALL BE GALVANIZED.
2. THE EXPOSED LENGTH OF THE ANCHOR BOLT BETWEEN THE TOP OF THE FOUNDATION AND THE BOTTOM OF THE LEVELING NUT SHOULD NOT EXCEED ONE BOLT Dia.
3. DURING POLE ERECTION, THE POLE MUST BE RAKED AS NECESSARY WITH THE USE OF LEVELING NUTS TO PROVIDE A PLUMB POLE AXIS. AFTER PLUMBING, PLACE A PAD OF NON-SHRINK GROUT UNDER BASE PLATE AND ALL AROUND THREADED RODS. THE PAD MUST HAVE VERTICAL SIDES AT PERIPHERY OF BASE PLATE.
4. OUTSIDE Dia, WALL THICKNESS, AND CORRESPONDING SECTION PROPERTIES OF THE BASE AND MAST ARE MINIMUM, UNLESS OTHERWISE SPECIFIED, ALTERNATIVE SECTIONS REQUIRE APPROVAL BY THE ENGINEER.
5. THE SPACE BETWEEN THE BASE PLATE AND TOP OF FOUNDATION SHALL BE PACKED WITH NON-SHRINK GROUT WITH VERTICAL SIDES.
6. POLE MUST BE POWDER COATED WITH PPG #PCTQ40104 (GEMINI GREEN).
7. DECORATIVE LAMP MUST NOT WEIGH MORE THAN 50 LBS
8. LAMP ATTACHMENT AND BASE COVER TO BE APPROVED BY THE ENGINEER.
9. EXPOSED HARDWARE FINISH PAINTED BY CONTRACTOR AFTER INSTALLATION. TOUCH-UP PAINT PROVIDED BY FINISHER.

NOTE:
 THE CONTRACTOR MUST VERIFY ALL CONTROLLING FIELD DIMENSIONS BEFORE ORDERING OR FABRICATING ANY MATERIAL.

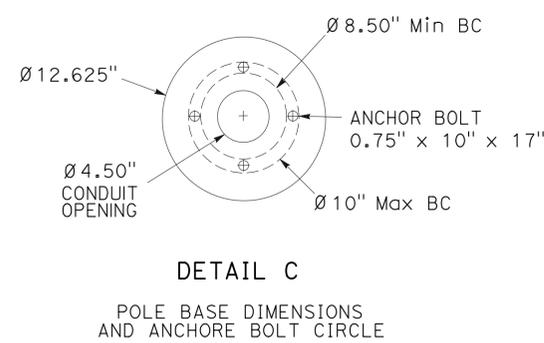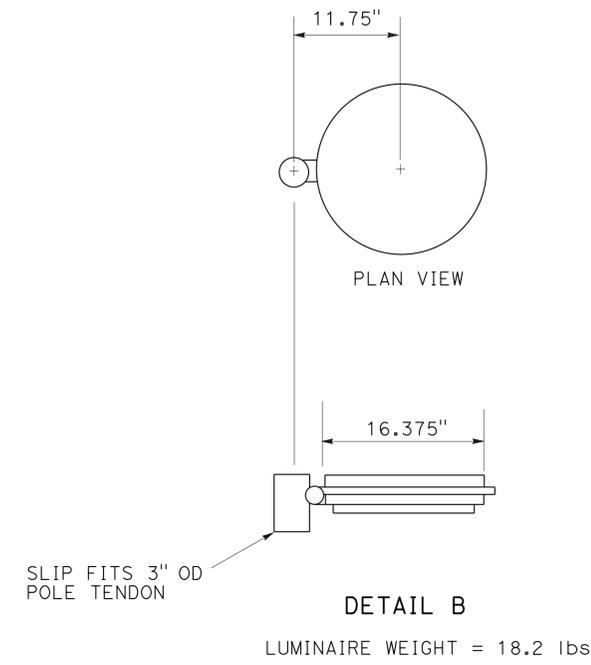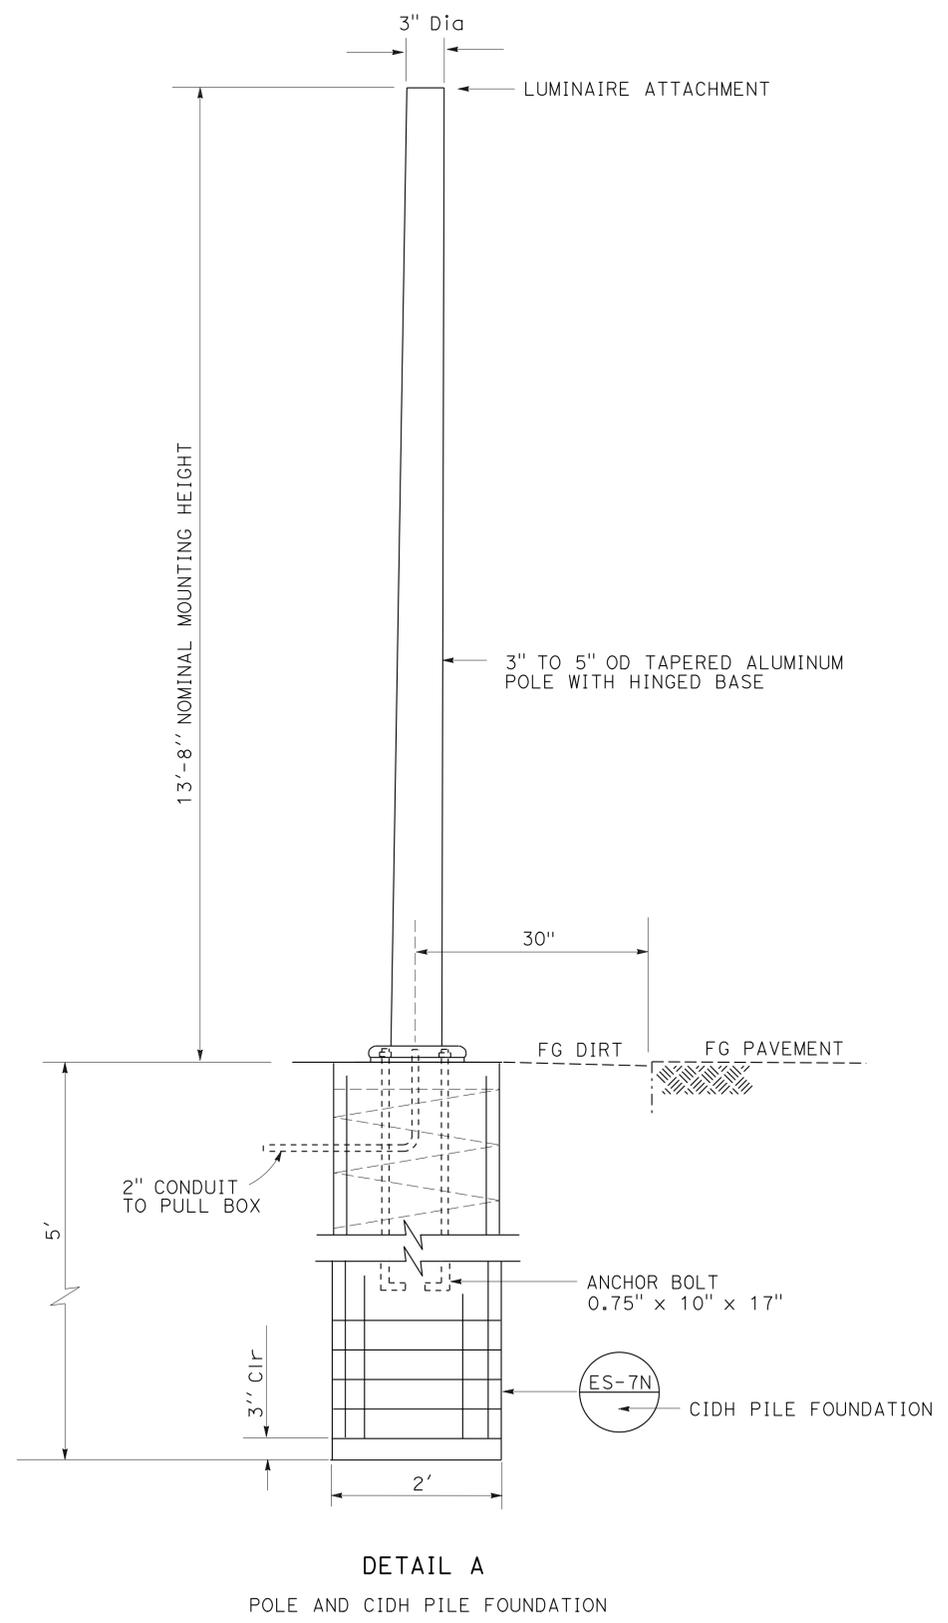

STATE OF CALIFORNIA - DEPARTMENT OF TRANSPORTATION
Caltrans
 DESIGN
 FUNCTIONAL SUPERVISOR: JAMES R. PERANO
 CALCULATED/DESIGNED BY: AMIR SAEDI
 CHECKED BY: XAVIER ALFARO
 REVISED BY: AMIR SAEDI
 DATE REVISED: XAVIER ALFARO

Dist	COUNTY	ROUTE	POST MILES TOTAL PROJECT	SHEET No.	TOTAL SHEETS
05	SB	101	2.2/3.3	403	786

Xavier Alfaro 11-25-15
 REGISTERED ELECTRICAL ENGINEER
 No. E17488
 Exp. 6-30-17
 ELECTRICAL
 STATE OF CALIFORNIA

12-7-15
 PLANS APPROVAL DATE

THE STATE OF CALIFORNIA OR ITS OFFICERS OR AGENTS SHALL NOT BE RESPONSIBLE FOR THE ACCURACY OR COMPLETENESS OF SCANNED COPIES OF THIS PLAN SHEET.

NOTE:
 THE QUANTITIES ON THIS SHEET ARE NOT A SEPARATE PAY ITEM, FOR INFORMATION ONLY.
 FOR COMPLETE ELECTRICAL WORK, SEE ELECTRICAL PLAN SHEETS.

LIGHTING

SHEET No.	SERVICE EQUIPMENT ENCLOSURE TYPE III-BF	SCE APPROVED PB	No. 5 PB	No. 5 (T) PB	TYPE 30 ELECTROLIER AND FOUNDATION	TYPE 30 ^{INS} ELECTROLIER AND FOUNDATION	TYPE 21S ELECTROLIER	ISL	2"C TYPE 3	3"C TYPE 3	2"C TYPE 1	EA				LF			
												No. 10 CONDUCTORS	No. 8 CONDUCTORS	No. 2 CONDUCTORS	No. 8 (G) CONDUCTORS	No. 10 CONDUCTORS	No. 8 CONDUCTORS	No. 2 CONDUCTORS	No. 8 (G) CONDUCTORS
E-4	1	1	3	0	1	0	1	1	350	150	200	1,100	0	500	600				
E-5	0	0	4	2	3	0	0	0	1,100	150	0	0	2,200	0	1,100				
E-6	0	0	5	0	0	3	0	0	700	150	0	0	1,800	0	900				

TRAFFIC OPERATION SYSTEMS

SHEET No.	2"C TYPE 3	2"C TYPE 1	No. 10 CONDUCTORS	No. 8 CONDUCTORS	No. 8 (G) CONDUCTORS	COAX CABLE	SIC	CAT5E	CCTV POWER CORD	EA		LF	
										No. 10 CONDUCTORS	No. 8 CONDUCTORS	No. 10 CONDUCTORS	No. 8 CONDUCTORS
E-8	350	700	1,100	1,000	300	100	100	300	100				
E-9	100	200	0	0	0	0	0	30	0				

TRAFFIC OPERATION SYSTEMS

SHEET No.	VSN	VSN TYPE 30 POLE AND FOUNDATION	344 CCTV CABINET	PoE	CCTV CAMERA ASSEMBLY	24 Volt POWER SUPPLY	120 VOLT QUAD OUTLET	802.11 WCB	0.5 A CIRCUIT BREAKER	No. 5 PB	No. 6 PB	EA	
												No. 5 PB	No. 6 PB
E-8	2	1	1	1	1	1	1	1	1	7	1		
E-9	2	0	0	0	0	0	0	1	0	0	0		
E-10	0	1	0	0	0	1	1	0	1	0	0		

SIGNAL AND LIGHTING (LOCATION 1)

SHEET No.	2"C, TYPE 3	3"C, TYPE 3	No. 8 CONDUCTORS	12CSC	3CSC	DLC	EVUC	APS CABLE	No. 8 CONDUCTOR (G)	SIC	BBS AND CONTROLLER CABINET FOUNDATION	EA	
												No. 5 PB	No. 6 PB
E-11	800	500	800	800	400	5,600	400	40	1,200	600	1		1

SIGNAL AND LIGHTING (LOCATION 1)

SHEET No.	TYPE 19-3 Sig STANDARD WITH EQUIPMENT AND FOUNDATION	TYPE 1-A Sig STANDARD WITH EQUIPMENT AND FOUNDATION	TYPE 17-3 Sig STANDARD WITH EQUIPMENT AND FOUNDATION	TYPE 16-3 STANDARD WITH EQUIPMENT AND FOUNDATION	No. 5 PB	No. 6 PB	No. 6 (E) PB	TYPE A LOOP DETECTOR	TYPE C LOOP DETECTOR	TYPE D LOOP DETECTOR	EA	
											No. 5 PB	No. 6 PB
E-11	1	3	1	1	11	4	1	9	4	4		2

**ELECTRICAL QUANTITIES
E-30**

STATE OF CALIFORNIA - DEPARTMENT OF TRANSPORTATION
Caltrans ELECTRICAL DESIGN
 XAVIER ALFARO
 KARIM ABDOLLAHIAN
 CALCULATED/DESIGNED BY
 CHECKED BY
 FUNCTIONAL SUPERVISOR
 ALI BAKHDOUD

LAST REVISION DATE PLOTTED => 15-DEC-2015 11-25-15 TIME PLOTTED => 15:30

STATE OF CALIFORNIA - DEPARTMENT OF TRANSPORTATION
Caltrans ELECTRICAL DESIGN
 FUNCTIONAL SUPERVISOR
 ALT BAKHDOUD
 CALCULATED/DESIGNED BY
 XAVIER ALFARO
 KARIM ABDOLLAHIAN
 REVISOR BY
 XIA
 DATE REVISOR
 11-25-15

NOTE:
 THE QUANTITIES ON THIS SHEET ARE NOT A SEPARATE PAY ITEM, FOR INFORMATION ONLY.
 FOR COMPLETE ELECTRICAL WORK, SEE ELECTRICAL PLAN SHEETS.

Dist	COUNTY	ROUTE	POST MILES TOTAL PROJECT	SHEET No.	TOTAL SHEETS
05	SB	101	2.2/3.3	405	786

Xavier Alfaro 11-25-15
 REGISTERED ELECTRICAL ENGINEER
 No. E17488
 Exp. 6-30-17
 12-7-15
 PLANS APPROVAL DATE
THE STATE OF CALIFORNIA OR ITS OFFICERS OR AGENTS SHALL NOT BE RESPONSIBLE FOR THE ACCURACY OR COMPLETENESS OF SCANNED COPIES OF THIS PLAN SHEET.



SIGNAL AND LIGHTING (CITY STREET)

SHEET No.	2" C, TYPE 3	3" C, TYPE 3	No. 8 CONDUCTORS	No. 10 CONDUCTORS	12CSC	3CSC	DLC	EVUC	APS CABLE	No. 8 CONDUCTOR (G)
	E-19	1,000	700	600	1,200	1,200	300	1,200	300	200

SIGNAL AND LIGHTING (CITY STREET)

SHEET No.	TYPE 19-4 Sig STANDARD WITH EQUIPMENT AND FOUNDATION	TYPE 1-A Sig STANDARD WITH EQUIPMENT AND FOUNDATION	TYPE 17-3 Sig STANDARD WITH EQUIPMENT AND FOUNDATION	TYPE 18-3 Sig STANDARD WITH EQUIPMENT AND FOUNDATION	BBS AND CONTROLLER CABINET FOUNDATION	165 W LED LUMINAIRE	No. 5 PB	No. 6 PB	No. 6 (E) PB	TYPE A LOOP DETECTOR	TDC	VIVDS	TYPE III-BF SERVICE EQUIPMENT ENCLOSURE
	E-19	1	2	1	1	1	3	9	2	1	2	1	3

LIGHTING (CITY STREET)

SHEET No.	No. 8 CONDUCTORS	No. 10 CONDUCTORS	3" C TYPE 3	2" C TYPE 3	2" C TYPE 1	TYPE III-BF SERVICE EQUIPMENT ENCLOSURE	TYPE 9A PULL BOX	BRIDGE SOFFIT	No. 5 PB	No. 3 PB	DECORATIVE BRIDGE MOUNT ELECTROLIER	DECORATIVE GROUND LEVEL ELECTROLIER AND FOUNDATION	BICYCLE PATH ELECTROLIER AND FOUNDATION
	E-21	3,000	0	1,400	1,400	200	0	2	4	15	0	0	0
E-22	400	2,000	2,500	2,500	400	1	0	0	12	6	6	0	1
E-23	0	2,500	1,600	1,200	400	1	0	0	6	6	6	6	0

**ELECTRICAL QUANTITIES
E-32**



	M
Maint	MAINTENANCE
Max	MAXIMUM
MB	METAL BEAM
MBB	METAL BEAM BARRIER
MBGR	METAL BEAM GUARD RAILING
Med	MEDIAN
MGS	MIDWEST GUARDRAIL SYSTEM
MH	MANHOLE
Min	MINIMUM
Misc	MISCELLANEOUS
Misc I & S	MISCELLANEOUS IRON AND STEEL
Mkr	MARKER
Mod	MODIFIED, MODIFY
Mon	MONUMENT
MP	METAL PLATE
MPGR	METAL PLATE GUARD RAILING
MR	MOVEMENT RATING
MSE	MECHANICALLY STABILIZED EMBANKMENT
Mt	MOUNTAIN, MOUNT
MtI	MATERIAL
MVP	MAINTENANCE VEHICLE PULLOUT
	N
N	NORTH
NB	NORTHBOUND
No.	NUMBER (MUST HAVE PERIOD)
Nos.	NUMBERS (MUST HAVE PERIOD)
NPS	NOMINAL PIPE SIZE
NS	NEAR SIDE
NSP	NEW STANDARD PLAN
NTS	NOT TO SCALE
	O
Obir	OBLITERATE
OC	OVERCROSSING
OD	OUTSIDE DIAMETER
OF	OUTSIDE FACE
OG	ORIGINAL GROUND
OGAC	OPEN GRADED ASPHALT CONCRETE
OGFC	OPEN GRADED FRICTION COURSE
OH	OVERHEAD
OHWM	ORDINARY HIGH WATER MARK
O-O	OUT TO OUT
Opp	OPPOSITE
OSD	OVERSIDE DRAIN
	P
p	PAGE
PAP	PERFORATED ALUMINUM PIPE
PB	PULL BOX
PC	POINT OF CURVATURE, PRECAST
PCC	POINT OF COMPOUND CURVE, PORTLAND CEMENT CONCRETE
PCMS	PORTABLE CHANGEABLE MESSAGE SIGN
PCP	PERFORATED CONCRETE PIPE, PRESTRESSED CONCRETE PIPE
PCVC	POINT OF COMPOUND VERTICAL CURVE
PEC	PERMIT TO ENTER AND CONSTRUCT
Ped	PEDESTRIAN
Ped OC	PEDESTRIAN OVERCROSSING
Ped UC	PEDESTRIAN UNDERCROSSING
Perm MtI	PERMEABLE MATERIAL

	P continued
PG	PROFILE GRADE
PI	POINT OF INTERSECTION
PJP	PARTIAL JOINT PENETRATION
Pkwy	PARKWAY
PL, PL	PLATE
P/L	PROPERTY LINE
PM	POST MILE, TIME FROM NOON TO MIDNIGHT
PN	PAVING NOTCH
POC	POINT OF HORIZONTAL CURVE
POT	POINT OF TANGENT
POVC	POINT OF VERTICAL CURVE
PP	PIPE PILE, PLASTIC PIPE, POWER POLE
PPL	PREFORMED PERMEABLE LINER
PPP	PERFORATED PLASTIC PIPE
PRC	POINT OF REVERSE CURVE
PRF	PAVEMENT REINFORCING FABRIC
PRVC	POINT OF REVERSE VERTICAL CURVE
PS&E	PLANS, SPECIFICATIONS AND ESTIMATES
PS, P/S	PRESTRESSED
PSP	PERFORATED STEEL PIPE
PT	POINT OF TANGENCY
PVC	POLYVINYL CHLORIDE
Pvmt	PAVEMENT
	Q
Qty	QUANTITY
	R
R	RADIUS
R & D	REMOVE AND DISPOSE
R & S	REMOVE AND SALVAGE
R/C	RATE OF CHANGE
RCA	REINFORCED CONCRETE ARCH
RCB	REINFORCED CONCRETE BOX
RCP	REINFORCED CONCRETE PIPE
RCPA	REINFORCED CONCRETE PIPE ARCH
Rd	ROAD
Reinf	REINFORCED, REINFORCEMENT, REINFORCING
Rel	RELOCATE
Repl	REPLACEMENT
Ret	RETAINING
Rev	REVISED, REVISION
Rdwy	ROADWAY
RHMA	RUBBERIZED HOT MIX ASPHALT
Riv	RIVER
RM	ROAD-MIXED
RP	RADIUS POINT, REFERENCE POINT
RR	RAILROAD
RSP	ROCK SLOPE PROTECTION, REVISED STANDARD PLAN
Rt	RIGHT
Rte	ROUTE
RW	REDWOOD, RETAINING WALL
R/W	RIGHT OF WAY
Rwy	RAILWAY

	S
S	SOUTH, SUPPLEMENT
SAE	STRUCTURE APPROACH EMBANKMENT
Salv	SALVAGE
SAPP	STRUCTURAL ALUMINUM PLATE PIPE
SB	SOUTHBOUND
SC	SAND CUSHION
SCSP	SLOTTED CORRUGATED STEEL PIPE
SD	STORM DRAIN
Sec	SECOND, SECTION
Sep	SEPARATION
SG	SUBGRADE
Shld	SHOULDER
Sht	SHEET
Sim	SIMILAR
SL	STATION LINE
SM	SELECTED MATERIAL
Spec	SPECIAL, SPECIFICATIONS
SPP	SLOTTED PLASTIC PIPE
SS	SLOPE STAKE
SSBM	STRAP AND SADDLE BRACKET METHOD
SSD	STRUCTURAL SECTION DRAIN
SSPA	STRUCTURAL STEEL PLATE ARCH
SSPP	STRUCTURAL STEEL PLATE PIPE
SSPPA	STRUCTURAL STEEL PLATE PIPE ARCH
SSRP	STEEL SPIRAL RIB PIPE
St	STREET
Sta	STATION
STBB	SINGLE THRIE BEAM BARRIER
Std	STANDARD
Str	STRUCTURE
Surf	SURFACING
SW	SIDEWALK, SOUND WALL
Swr	SEWER
Sym	SYMMETRICAL
S4S	SURFACE 4 SIDES
	T
T	SEMI-TANGENT
Tan	TANGENT
TBB	THRIE BEAM BARRIER
Tbr	TIMBER
TC	TOP OF CURB
TCB	TRAFFIC CONTROL BOX
TCE	TEMPORARY CONSTRUCTION EASEMENT
TeI	TELEPHONE
Temp	TEMPORARY
TG	TOP OF GRADE
Tot	TOTAL
TP	TELEPHONE POLE
TPB	TREATED PERMEABLE BASE
TPM	TREATED PERMEABLE MATERIAL
Trans	TRANSITION

	T continued
TS	TRANSVERSE, TRAFFIC SIGNAL, TUBULAR STEEL
Typ	TYPICAL
	U
UC	UNDERCROSSING
UD	UNDERDRAIN
UG	UNDERGROUND
UON	UNLESS OTHERWISE NOTED
UP	UNDERPASS
	V
V	VALVE, DESIGN SPEED
Var	VARIABLE, VARIES
VC	VERTICAL CURVE
VCP	VITRIFIED CLAY PIPE
Vert	VERTICAL
Via	VIADUCT
Vol	VOLUME
	W
W	WEST, WIDTH
WB	WESTBOUND
WH	WEEP HOLE
WM	WIRE MESH
WS	WATER SURFACE
WSP	WELDED STEEL PIPE
Wt	WEIGHT
WV	WATER VALVE
WW	WINGWALL
WWL	WINGWALL LAYOUT LINE
	X
X Sec	CROSS SECTION
Xing	CROSSING
	Y
Yr	YEAR
Yrs	YEARS

Dist	COUNTY	ROUTE	POST MILES TOTAL PROJECT	SHEET No.	TOTAL SHEETS
05	SB	101	2.2/3.3	406	786

Grace M. Tsushima
REGISTERED CIVIL ENGINEER



July 19, 2013
PLANS APPROVAL DATE

THE STATE OF CALIFORNIA OR ITS OFFICERS OR AGENTS SHALL NOT BE RESPONSIBLE FOR THE ACCURACY OR COMPLETENESS OF SCANNED COPIES OF THIS PLAN SHEET.

TO ACCOMPANY PLANS DATED 12-7-15

UNIT OF MEASUREMENT SYMBOLS:

Some of the symbols used in the project plan quantity tables and in the Bid Item List are:

SYMBOL USED	DEFINITIONS
ACRE	ACRE
CF	CUBIC FOOT
CY	CUBIC YARD
EA	EACH
GAL	GALLON
LB	POUND
LF	LINEAR FOOT
SQFT	SQUARE FOOT
SQYD	SQUARE YARD
STA	100 FEET
TAB	TABLET
TON	2,000 POUNDS

Some of the symbols used in the plans other than in the project plan quantity tables are:

SYMBOL USED	DEFINITIONS
ksi	KIPS PER SQUARE INCH
ksf	KIPS PER SQUARE FOOT
psi	POUNDS PER SQUARE INCH
psf	POUNDS PER SQUARE FOOT
lb/ft ³ , pcf	POUNDS PER CUBIC FOOT
tsf	TONS PER SQUARE FOOT
mph, MPH *	MILES PER HOUR
ø	NOMINAL DIAMETER
oz	OUNCE
lb	POUND
kíp	1,000 POUNDS
cal	CALORIE
ft	FOOT OR FEET
gal	GALLON

* For use on a sign panel only

STATE OF CALIFORNIA
DEPARTMENT OF TRANSPORTATION

**ABBREVIATIONS
(SHEET 2 OF 2)**

NO SCALE

RSP A10B DATED JULY 19, 2013 SUPERSEDES STANDARD PLAN A10B
DATED MAY 20, 2011 - PAGE 2 OF THE STANDARD PLANS BOOK DATED 2010.

2010 REVISED STANDARD PLAN RSP A10B

Dist	COUNTY	ROUTE	POST MILES TOTAL PROJECT	SHEET No.	TOTAL SHEETS
05	SB	101	2.2/3.3	407	786


 CERTIFIED ENGINEERING GEOLOGIST
 October 30, 2015
 PLANS APPROVAL DATE
THE STATE OF CALIFORNIA OR ITS OFFICERS OR AGENTS SHALL NOT BE RESPONSIBLE FOR THE ACCURACY OR COMPLETENESS OF SCANNED COPIES OF THIS PLAN SHEET.

REGISTERED GEOLOGIST
 CHRIS A. RISDEN
 No. 2541
 Exp. 9-30-17
 STATE OF CALIFORNIA

CEMENTATION	
DESCRIPTION	CRITERIA
WEAK	CRUMBLES OR BREAKS WITH HANDLING OR LITTLE FINGER PRESSURE.
MODERATE	CRUMBLES OR BREAKS WITH CONSIDERABLE FINGER PRESSURE.
STRONG	WILL NOT CRUMBLE OR BREAK WITH FINGER PRESSURE.

ABBREVIATION:





GWS = Ground Water Surface

TO ACCOMPANY PLANS DATED 12-7-15

BOREHOLE IDENTIFICATION		
SYMBOL	HOLE TYPE	DESCRIPTION
	A	AUGER BORING (HOLLOW OR SOLID STEM BUCKET)
	R	ROTARY DRILLED BORING (CONVENTIONAL)
	RW	ROTARY DRILLED WITH SELF-CASING WIRE-LINE
	RC	ROTARY CORE WITH CONTINUOUSLY-SAMPLED, SELF-CASING WIRE-LINE
	P	ROTARY PERCUSSION BORING (AIR)
	R	ROTARY DRILLED DIAMOND CORE
	RC	ROTARY DRILLED DIAMOND CORE, CONTINUOUSLY SAMPLED
	HD	HAND DRIVEN (1-INCH SOIL TUBE)
	HA	HAND AUGER
	D	DYNAMIC CONE PENETRATION BORING
	CPT	CONE PENETRATION TEST (ASTM D 5778)
	O	OTHER (NOTE ON LOTB)

Note: Size in inches.

CONSISTENCY OF COHESIVE SOILS				
DESCRIPTION	SHEAR STRENGTH (tsf)	POCKET PENETROMETER MEASUREMENT, PP, (tsf)	TORVANE MEASUREMENT, TV, (tsf)	VANE SHEAR MEASUREMENT, VS, (tsf)
VERY SOFT	LESS THAN 0.12	LESS THAN 0.25	LESS THAN 0.12	LESS THAN 0.12
SOFT	0.12 - 0.25	0.25 - 0.5	0.12 - 0.25	0.12 - 0.25
MEDIUM STIFF	0.25 - 0.5	0.5 - 1	0.25 - 0.5	0.25 - 0.5
STIFF	0.5 - 1	1 - 2	0.5 - 1	0.5 - 1
VERY STIFF	1 - 2	2 - 4	1 - 2	1 - 2
HARD	GREATER THAN 2	GREATER THAN 4	GREATER THAN 2	GREATER THAN 2

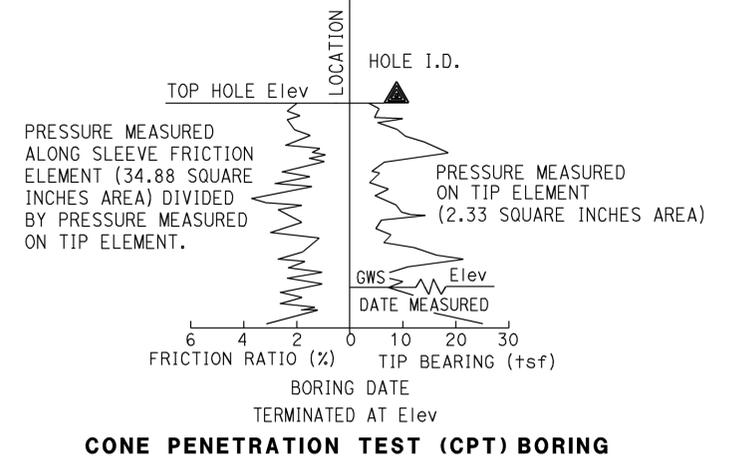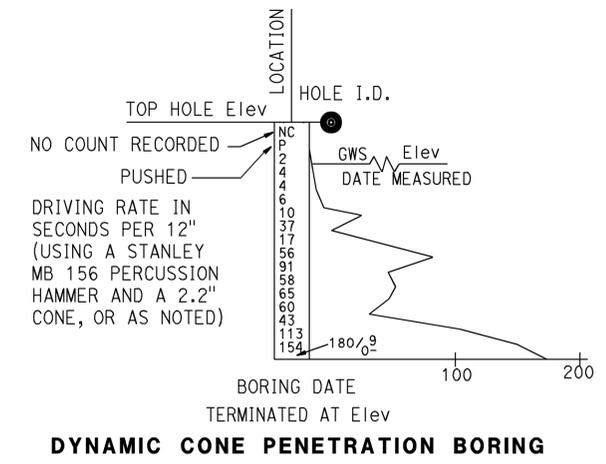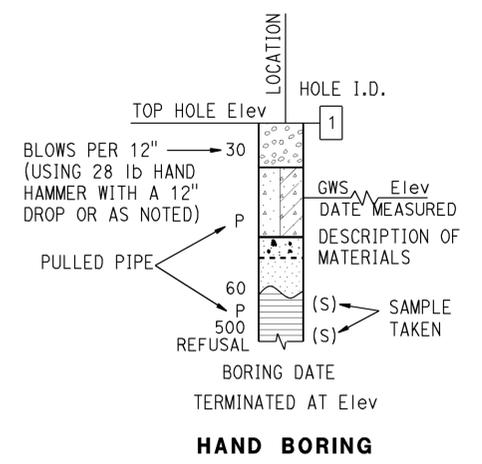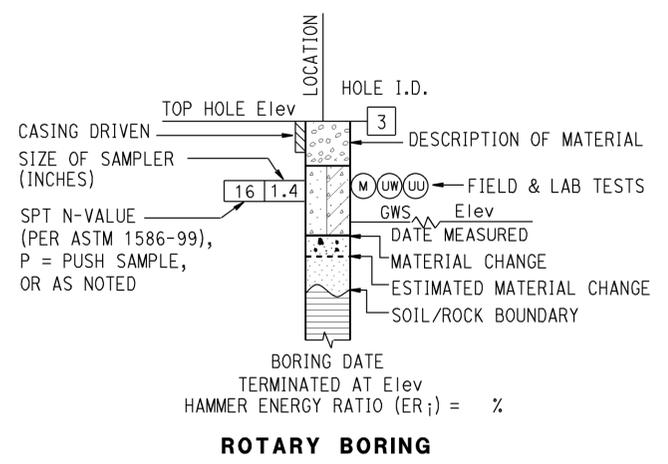

STATE OF CALIFORNIA
 DEPARTMENT OF TRANSPORTATION
LEGEND - SOIL (SHEET 1 OF 2)
 NO SCALE

RSP A10F DATED OCTOBER 30, 2015 SUPERSEDES STANDARD PLAN A10F DATED MAY 20, 2011 - PAGE 6 OF THE STANDARD PLANS BOOK DATED 2010.

2010 REVISED STANDARD PLAN RSP A10F

Dist	COUNTY	ROUTE	POST MILES TOTAL PROJECT	SHEET No.	TOTAL SHEETS
05	SB	101	2.2/3.3	408	786

Chris A. Risden
 CERTIFIED ENGINEERING GEOLOGIST
 October 30, 2015
 PLANS APPROVAL DATE

REGISTERED GEOLOGIST
 CHRIS A. RISDEN
 No. 2541
 Exp. 9-30-17
 STATE OF CALIFORNIA

THE STATE OF CALIFORNIA OR ITS OFFICERS OR AGENTS SHALL NOT BE RESPONSIBLE FOR THE ACCURACY OR COMPLETENESS OF SCANNED COPIES OF THIS PLAN SHEET.

TO ACCOMPANY PLANS DATED 12-7-15

GROUP SYMBOLS AND NAMES					
GRAPHIC/SYMBOL	GROUP NAMES	GRAPHIC/SYMBOL	GROUP NAMES	GRAPHIC/SYMBOL	GROUP NAMES
	GW WELL-GRADED GRAVEL WELL-GRADED GRAVEL WITH SAND		CL LEAN CLAY LEAN CLAY WITH SAND LEAN CLAY WITH GRAVEL SANDY LEAN CLAY SANDY LEAN CLAY WITH GRAVEL GRAVELLY LEAN CLAY GRAVELLY LEAN CLAY WITH SAND		GP POORLY-GRADED GRAVEL POORLY-GRADED GRAVEL WITH SAND
	GW-GM WELL-GRADED GRAVEL WITH SILT WELL-GRADED GRAVEL WITH SILT AND SAND		CL-ML SILTY CLAY SILTY CLAY WITH SAND SILTY CLAY WITH GRAVEL SANDY SILTY CLAY SANDY SILTY CLAY WITH GRAVEL GRAVELLY SILTY CLAY GRAVELLY SILTY CLAY WITH SAND		GP-GM POORLY-GRADED GRAVEL WITH SILT POORLY-GRADED GRAVEL WITH SILT AND SAND
	GW-GC WELL-GRADED GRAVEL WITH CLAY (OR SILTY CLAY) WELL-GRADED GRAVEL WITH CLAY AND SAND (OR SILTY CLAY AND SAND)		ML SILT SILT WITH SAND SILT WITH GRAVEL SANDY SILT SANDY SILT WITH GRAVEL GRAVELLY SILT GRAVELLY SILT WITH SAND		GP-GC POORLY-GRADED GRAVEL WITH CLAY (OR SILTY CLAY) POORLY-GRADED GRAVEL WITH CLAY AND SAND (OR SILTY CLAY AND SAND)
	GM SILTY GRAVEL SILTY GRAVEL WITH SAND		OL ORGANIC LEAN CLAY ORGANIC LEAN CLAY WITH SAND ORGANIC LEAN CLAY WITH GRAVEL SANDY ORGANIC LEAN CLAY SANDY ORGANIC LEAN CLAY WITH GRAVEL GRAVELLY ORGANIC LEAN CLAY GRAVELLY ORGANIC LEAN CLAY WITH SAND		GC CLAYEY GRAVEL CLAYEY GRAVEL WITH SAND
	GC-GM SILTY, CLAYEY GRAVEL SILTY, CLAYEY GRAVEL WITH SAND		OL ORGANIC SILT ORGANIC SILT WITH SAND ORGANIC SILT WITH GRAVEL SANDY ORGANIC SILT SANDY ORGANIC SILT WITH GRAVEL GRAVELLY ORGANIC SILT GRAVELLY ORGANIC SILT WITH SAND		SW WELL-GRADED SAND WELL-GRADED SAND WITH GRAVEL
	SP POORLY-GRADED SAND POORLY-GRADED SAND WITH GRAVEL		CH FAT CLAY FAT CLAY WITH SAND FAT CLAY WITH GRAVEL SANDY FAT CLAY SANDY FAT CLAY WITH GRAVEL GRAVELLY FAT CLAY GRAVELLY FAT CLAY WITH SAND		SW-SM WELL-GRADED SAND WITH SILT WELL-GRADED SAND WITH SILT AND GRAVEL
	SW-SC WELL-GRADED SAND WITH CLAY (OR SILTY CLAY) WELL-GRADED SAND WITH CLAY AND GRAVEL (OR SILTY CLAY AND GRAVEL)		MH ELASTIC SILT ELASTIC SILT WITH SAND ELASTIC SILT WITH GRAVEL SANDY ELASTIC SILT SANDY ELASTIC SILT WITH GRAVEL GRAVELLY ELASTIC SILT GRAVELLY ELASTIC SILT WITH SAND		SP-SM POORLY-GRADED SAND WITH SILT POORLY-GRADED SAND WITH SILT AND GRAVEL
	SP-SC POORLY-GRADED SAND WITH CLAY (OR SILTY CLAY) POORLY-GRADED SAND WITH CLAY AND GRAVEL (OR SILTY CLAY AND GRAVEL)		OH ORGANIC FAT CLAY ORGANIC FAT CLAY WITH SAND ORGANIC FAT CLAY WITH GRAVEL SANDY ORGANIC FAT CLAY SANDY ORGANIC FAT CLAY WITH GRAVEL GRAVELLY ORGANIC FAT CLAY GRAVELLY ORGANIC FAT CLAY WITH SAND		SM SILTY SAND SILTY SAND WITH GRAVEL
	SC CLAYEY SAND CLAYEY SAND WITH GRAVEL		OH ORGANIC ELASTIC SILT ORGANIC ELASTIC SILT WITH SAND ORGANIC ELASTIC SILT WITH GRAVEL SANDY ORGANIC ELASTIC SILT SANDY ORGANIC ELASTIC SILT WITH GRAVEL GRAVELLY ORGANIC ELASTIC SILT GRAVELLY ORGANIC ELASTIC SILT WITH SAND		SC-SM SILTY, CLAYEY SAND SILTY, CLAYEY SAND WITH GRAVEL
	PT PEAT		OL/OH ORGANIC SOIL ORGANIC SOIL WITH SAND ORGANIC SOIL WITH GRAVEL SANDY ORGANIC SOIL SANDY ORGANIC SOIL WITH GRAVEL GRAVELLY ORGANIC SOIL GRAVELLY ORGANIC SOIL WITH SAND		COBBLES COBBLES AND BOULDERS BOULDERS

FIELD AND LABORATORY TESTING	
(C)	CONSOLIDATION (ASTM D2435)
(CL)	COLLAPSE POTENTIAL (ASTM D4546)
(CP)	COMPACTION CURVE (CTM 216)
(CR)	CORROSIVITY TESTING (CTM 643, CTM 422, CTM 417)
(CU)	CONSOLIDATED UNDRAINED TRIAXIAL (ASTM D4767)
(DS)	DIRECT SHEAR (ASTM D3080)
(EI)	EXPANSION INDEX (ASTM D4829)
(M)	MOISTURE CONTENT (ASTM D2216)
(OC)	ORGANIC CONTENT-% (ASTM D2974)
(P)	PERMEABILITY (CTM 220)
(PA)	PARTICLE SIZE ANALYSIS (ASTM D422)
(PI)	PLASTICITY INDEX (AASHTO T 90) LIQUID LIMIT (AASHTO T 89)
(PL)	POINT LOAD INDEX (ASTM D5731)
(PM)	PRESSURE METER
(R)	R-VALUE (CTM 301)
(SE)	SAND EQUIVALENT (CTM 217)
(SG)	SPECIFIC GRAVITY (AASHTO T 100)
(SL)	SHRINKAGE LIMIT (ASTM D4943)
(SW)	SWELL POTENTIAL (ASTM D4546)
(UC)	UNCONFINED COMPRESSION-SOIL (ASTM D2166) UNCONFINED COMPRESSION-ROCK (ASTM D7012 - METHOD C)
(UU)	UNCONSOLIDATED UNDRAINED TRIAXIAL (ASTM D2850)
(UW)	UNIT WEIGHT (ASTM D7263 - METHOD B)

APPARENT DENSITY OF COHESIONLESS SOILS	
DESCRIPTION	SPT N ₆₀ (BLOWS / 12 INCHES)
VERY LOOSE	0 - 5
LOOSE	5 - 10
MEDIUM DENSE	10 - 30
DENSE	30 - 50
VERY DENSE	GREATER THAN 50

MOISTURE	
DESCRIPTION	CRITERIA
DRY	NO DISCERNABLE MOISTURE
MOIST	MOISTURE PRESENT, BUT NO FREE WATER
WET	VISIBLE FREE WATER

PERCENT OR PROPORTION OF SOILS	
DESCRIPTION	CRITERIA
TRACE	PARTICLES ARE PRESENT BUT ESTIMATED TO BE LESS THAN 5%
FEW	5% - 10%
LITTLE	15% - 25%
SOME	30% - 45%
MOSTLY	50% - 100%

PARTICLE SIZE		
DESCRIPTION	SIZE	
BOULDER	GREATER THAN 12"	
COBBLE	3" - 12"	
GRAVEL	COARSE	3/4" - 3"
	FINE	1/5" - 3/4"
SAND	COARSE	1/16" - 1/5"
	MEDIUM	1/64" - 1/16"
	FINE	1/300" - 1/64"
SILT AND CLAY	LESS THAN 1/300"	

STATE OF CALIFORNIA
 DEPARTMENT OF TRANSPORTATION
LEGEND - SOIL
(SHEET 2 OF 2)
 NO SCALE

RSP A10G DATED OCTOBER 30, 2015 SUPERSEDES STANDARD PLAN A10G DATED MAY 20, 2011 - PAGE 7 OF THE STANDARD PLANS BOOK DATED 2010.

REVISED STANDARD PLAN RSP A10G

2010 REVISED STANDARD PLAN RSP A10G


Dist	COUNTY	ROUTE	POST MILES TOTAL PROJECT	SHEET No.	TOTAL SHEETS
05	SB	101	2.2/3.3	409	786

REGISTERED CIVIL ENGINEER
 Roberta L. McLaughlin
 No. C40375
 Exp. 3-31-15
 CIVIL
 STATE OF CALIFORNIA


July 19, 2013
 PLANS APPROVAL DATE

THE STATE OF CALIFORNIA OR ITS OFFICERS OR AGENTS SHALL NOT BE RESPONSIBLE FOR THE ACCURACY OR COMPLETENESS OF SCANNED COPIES OF THIS PLAN SHEET.


EXIT RAMP NEUTRAL AREA (GORE) TREATMENT

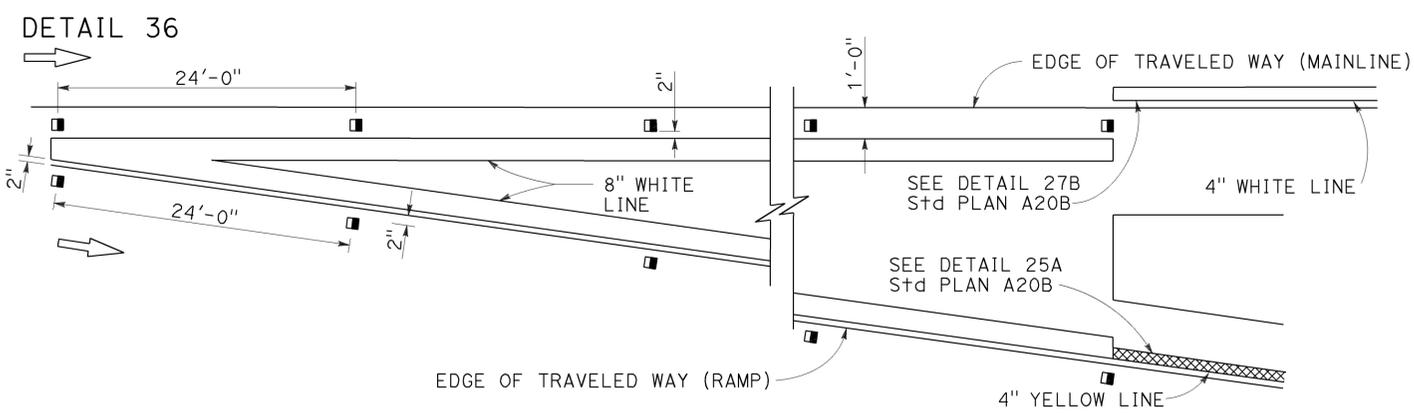

ENTRANCE RAMP NEUTRAL AREA (MERGE) TREATMENT

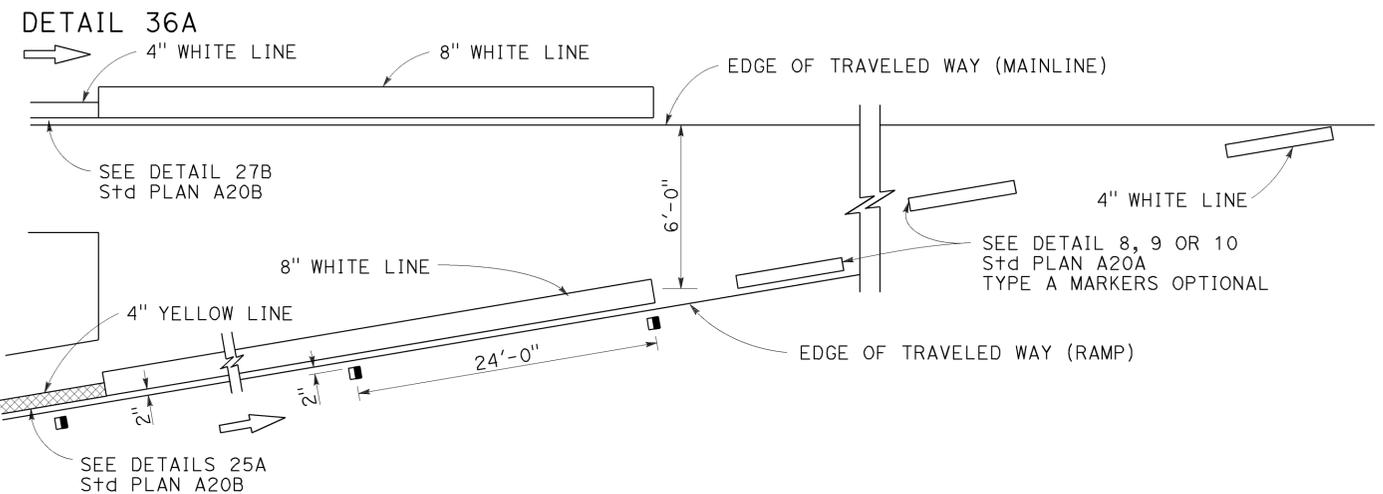


ENTRANCE RAMP NEUTRAL AREA (ACCELERATION LANE) TREATMENT

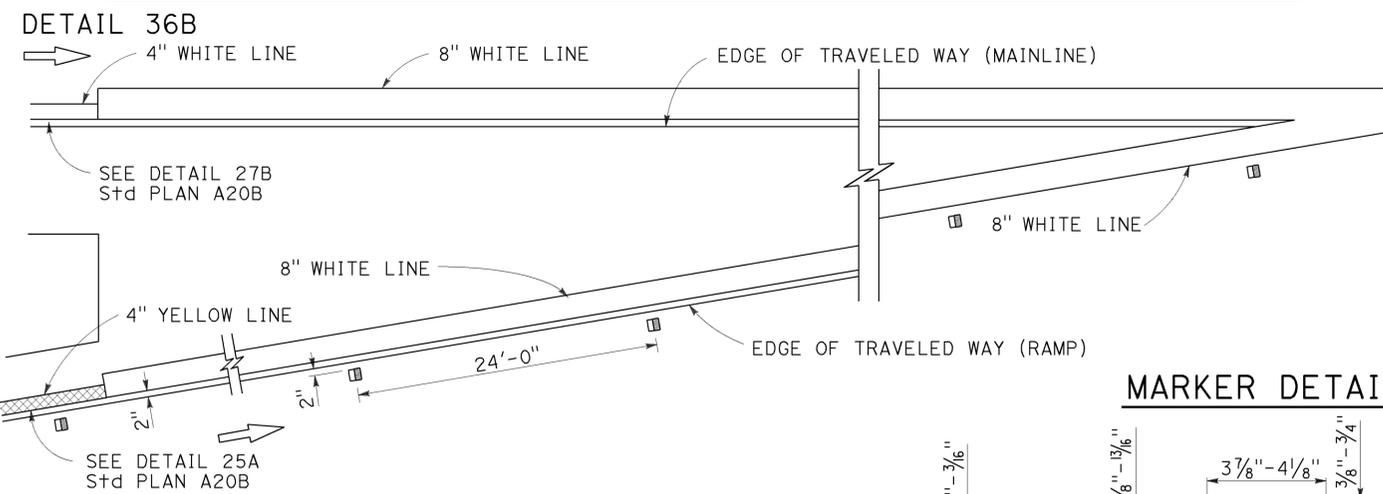



MARKER DETAILS

LEGEND:

- MARKERS
- TYPE A WHITE NON-REFLECTIVE
 - ◻ TYPE C RED-CLEAR RETROREFLECTIVE
 - TYPE G ONE-WAY CLEAR RETROREFLECTIVE


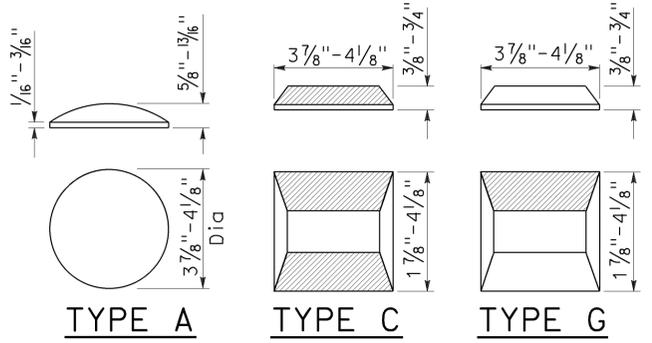


LANE DROP AT EXIT RAMP

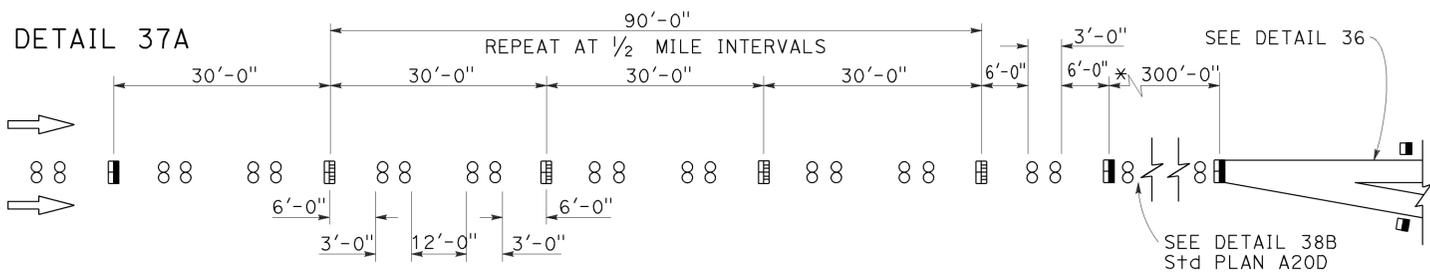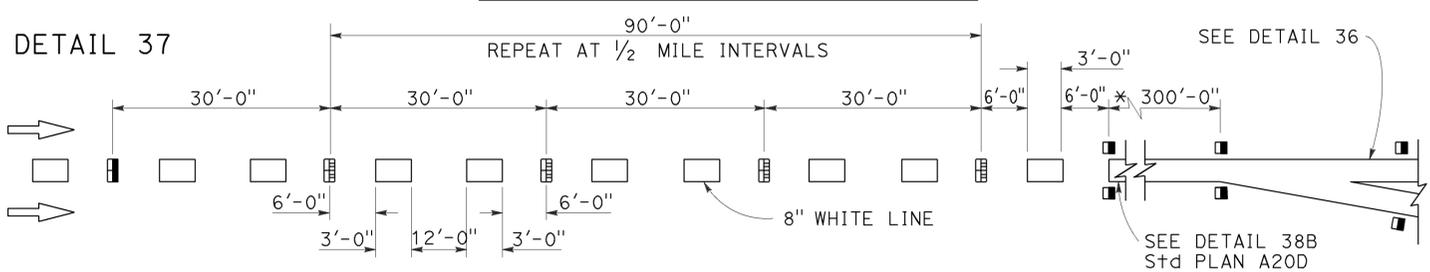

* The solid channelizing line shown may be omitted on short auxiliary lanes where weaving length is critical.

LANE DROP AT INTERSECTIONS

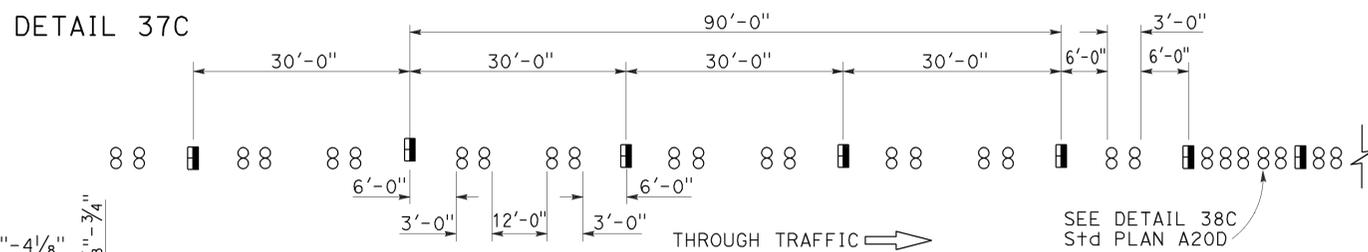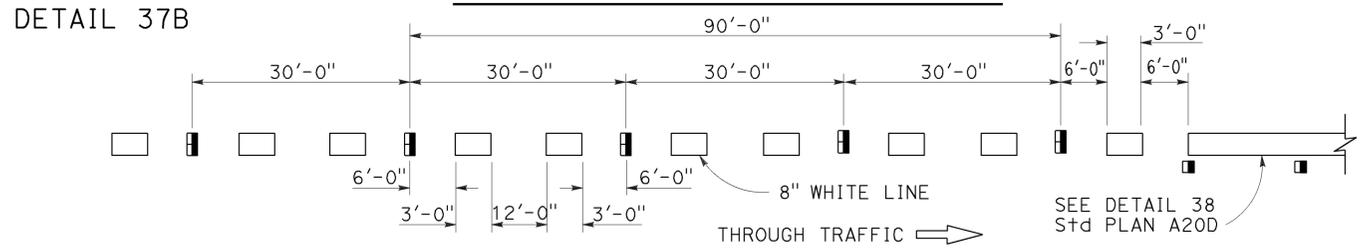

STATE OF CALIFORNIA
 DEPARTMENT OF TRANSPORTATION

PAVEMENT MARKERS AND TRAFFIC LINE TYPICAL DETAILS

NO SCALE

RSP A20C DATED JULY 19, 2013 SUPERSEDES STANDARD PLAN A20C DATED MAY 20, 2011 - PAGE 11 OF THE STANDARD PLANS BOOK DATED 2010.

REVISED STANDARD PLAN RSP A20C


2010 REVISED STANDARD PLAN RSP A20C

Dist	COUNTY	ROUTE	POST MILES TOTAL PROJECT	SHEET No.	TOTAL SHEETS
05	SB	101	2.2/3.3	410	786


Roberta L. McLaughlin
 REGISTERED CIVIL ENGINEER
 April 20, 2012
 PLANS APPROVAL DATE
 THE STATE OF CALIFORNIA OR ITS OFFICERS OR AGENTS SHALL NOT BE RESPONSIBLE FOR THE ACCURACY OR COMPLETENESS OF SCANNED COPIES OF THIS PLAN SHEET.

REGISTERED PROFESSIONAL ENGINEER
 Roberta L. McLaughlin
 No. C40375
 Exp. 3-31-13
 CIVIL
 STATE OF CALIFORNIA


TO ACCOMPANY PLANS DATED 12-7-15

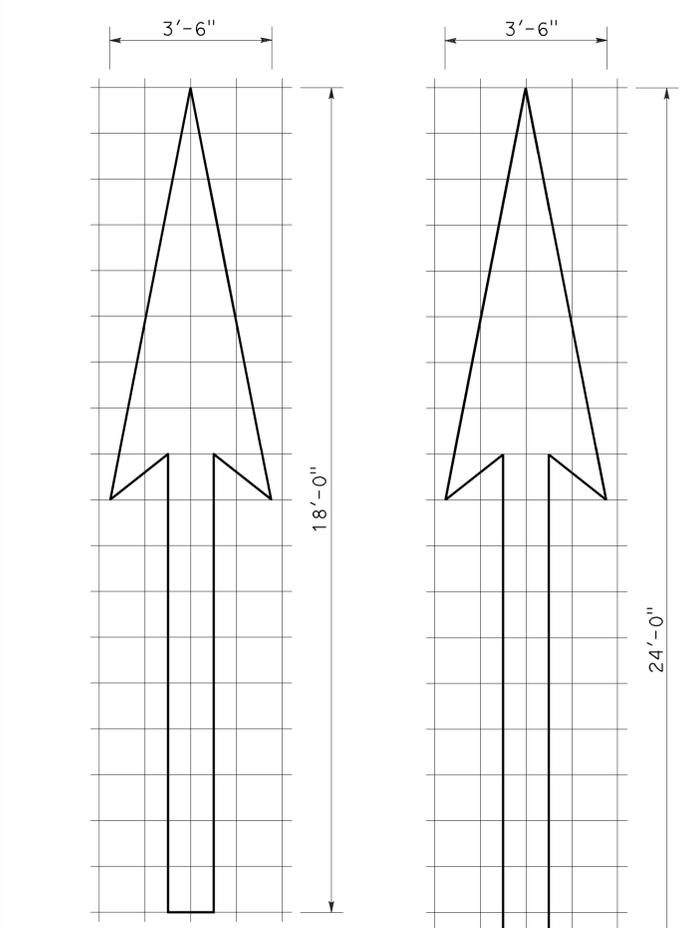


A=25 ft²
TYPE I 18'-0" ARROW

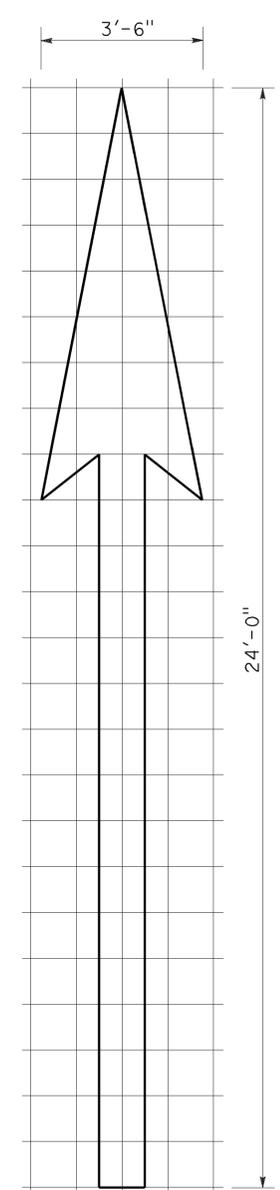


A=31 ft²
TYPE I 24'-0" ARROW

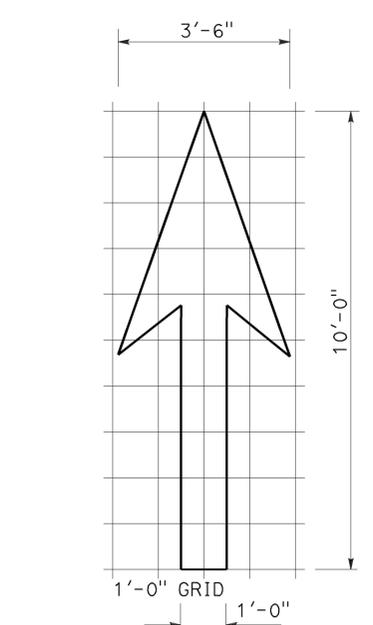


A=14 ft²
TYPE I 10'-0" ARROW

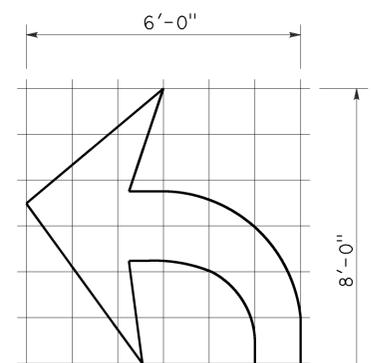


A=15 ft²
TYPE IV (L) ARROW
 (For Type IV (R) arrow, use mirror image)

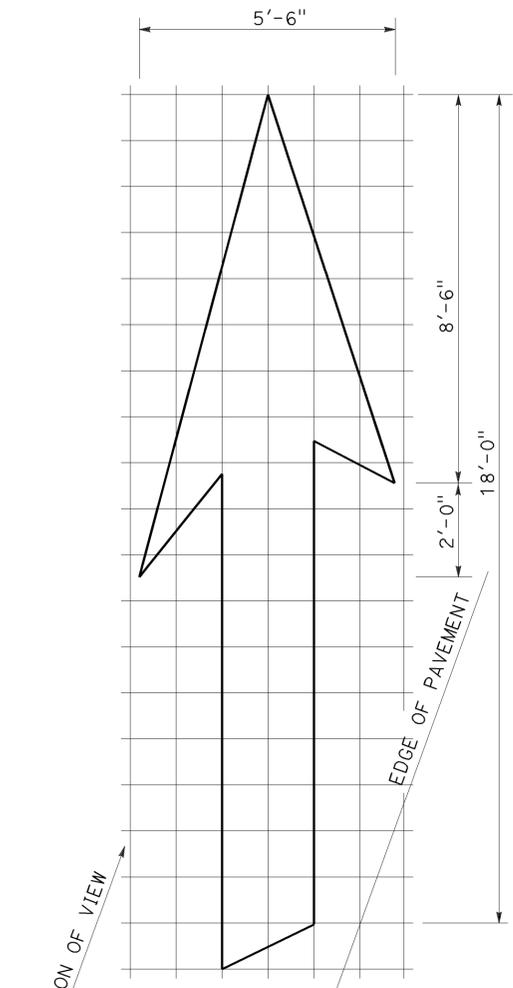


A=42 ft²
TYPE VI ARROW
 Right lane drop arrow
 (For left lane, use mirror image)

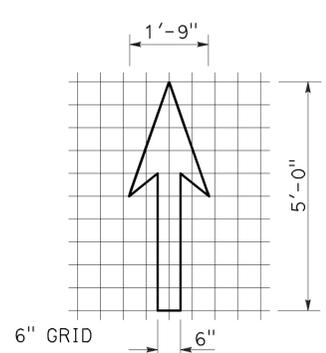


A=3.5 ft²
BIKE LANE ARROW

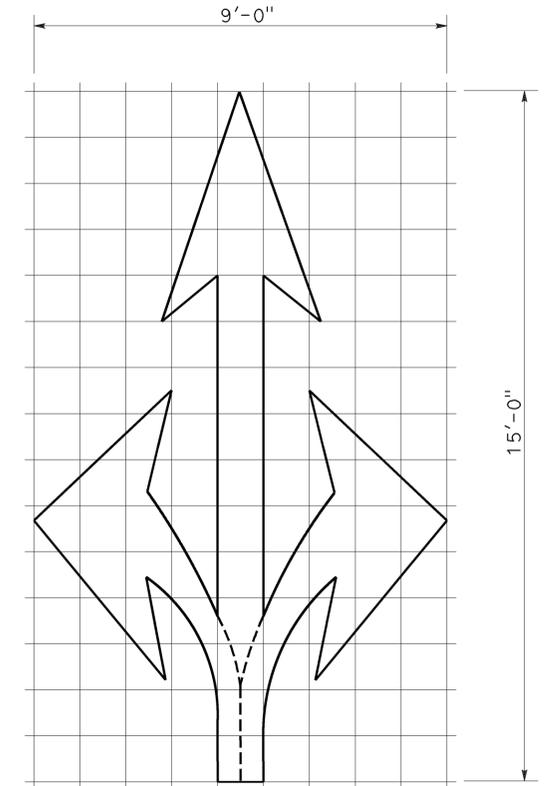

A=36 ft²
TYPE VIII ARROW

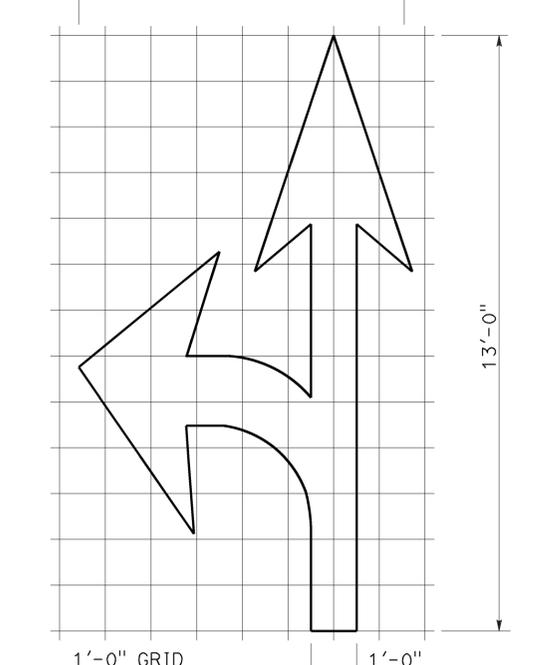

A=27 ft²
TYPE VII (L) ARROW
 (For Type VII (R) arrow, use mirror image)

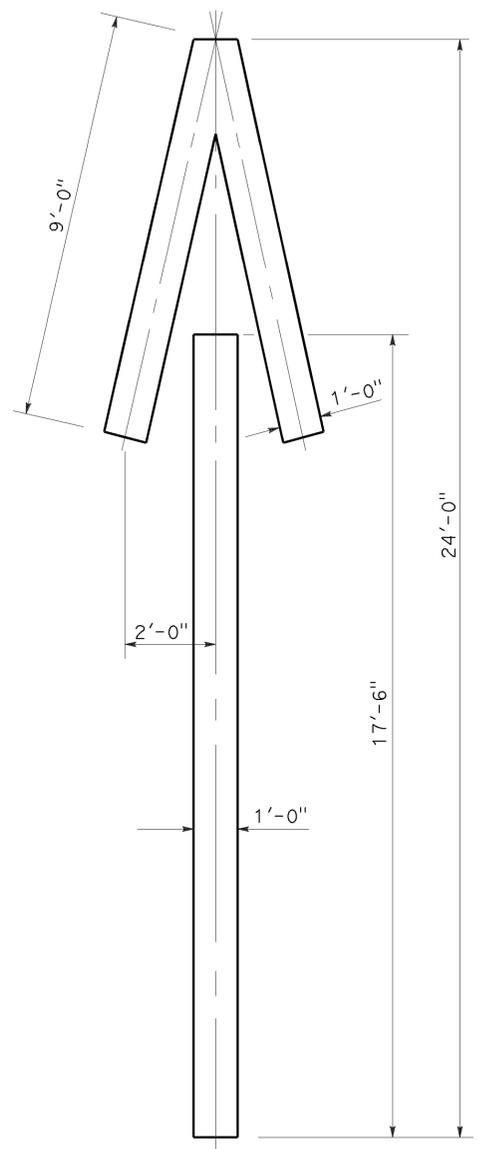

A=33 ft²
TYPE V ARROW

NOTE:
 Minor variations in dimensions may be accepted by the Engineer.

STATE OF CALIFORNIA
 DEPARTMENT OF TRANSPORTATION
**PAVEMENT MARKINGS
 ARROWS**
 NO SCALE


RSP A24A DATED APRIL 20, 2012 SUPERSEDES STANDARD PLAN A24A DATED MAY 20, 2011 - PAGE 13 OF THE STANDARD PLANS BOOK DATED 2010.

2010 REVISED STANDARD PLAN RSP A24A


Dist	COUNTY	ROUTE	POST MILES TOTAL PROJECT	SHEET No.	TOTAL SHEETS
05	SB	101	2.2/3.3	412	786

Roberta L. McLaughlin
 REGISTERED CIVIL ENGINEER
 July 20, 2012
 PLANS APPROVAL DATE
THE STATE OF CALIFORNIA OR ITS OFFICERS OR AGENTS SHALL NOT BE RESPONSIBLE FOR THE ACCURACY OR COMPLETENESS OF SCANNED COPIES OF THIS PLAN SHEET.


TO ACCOMPANY PLANS DATED 12-7-15

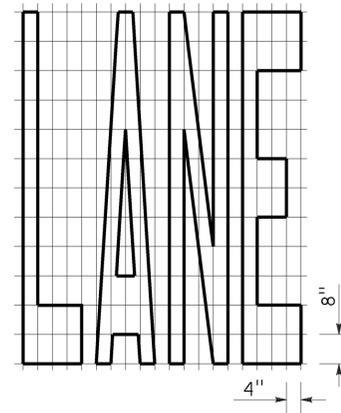


A=24 ft²

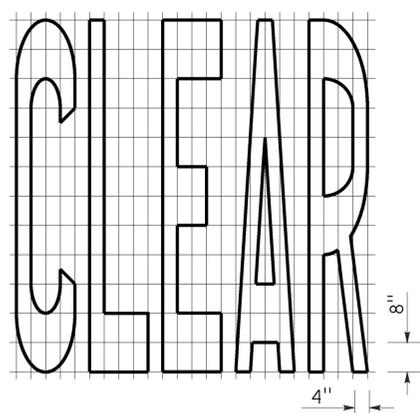


A=27 ft²

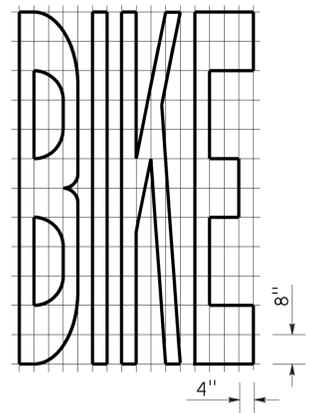


A=21 ft²

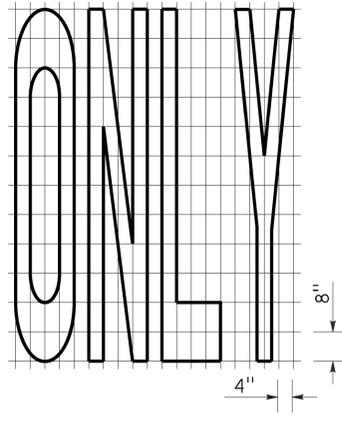


A=22 ft²

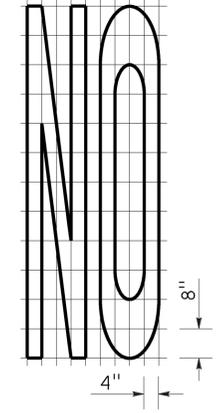


A=14 ft²

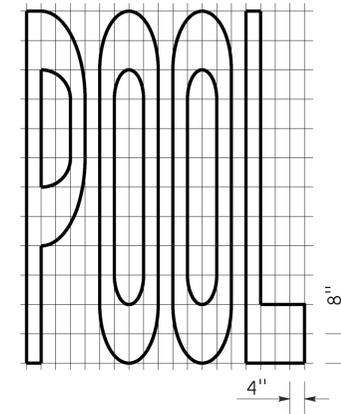


A=23 ft²

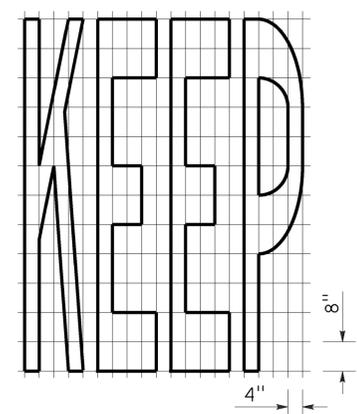


A=24 ft²

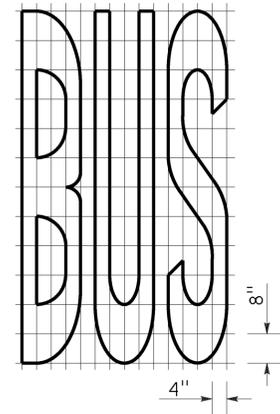

A=20 ft²

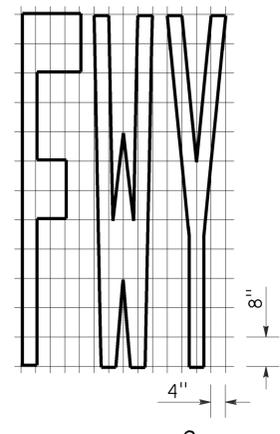


A=16 ft²

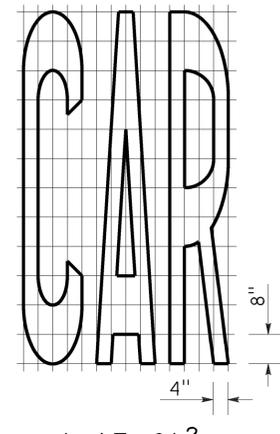


A=17 ft²

WORD MARKINGS			
ITEM	ft ²	ITEM	ft ²
LANE	24	NO	14
POOL	23	BIKE	21
CAR	17	BUS	20
CLEAR	27	ONLY	22
KEEP	24	FWY	16

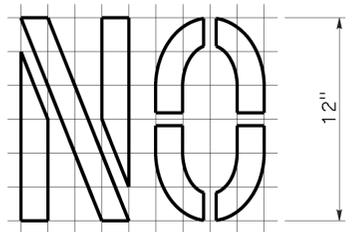


A=2 ft²

See Notes 6 and 7

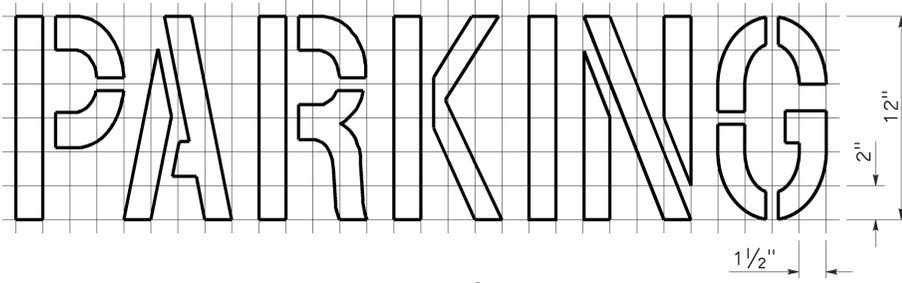

A=2 ft²

See Notes 6 and 7

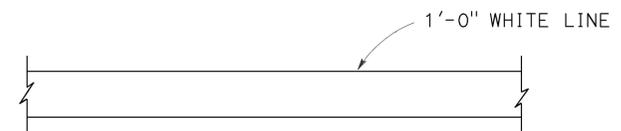

LIMIT LINE (STOP LINE)



YIELD LINE

NOTES:

1. If a message consists of more than one word, it should read "UP", i.e., the first word should be nearest the driver.
2. The space between words should be at least four times the height of the characters for low speed roads, but not more than ten times the height of the characters. The space may be reduced appropriately where there is limited space because of local conditions.
3. Minor variations in dimensions may be accepted by the Engineer.
4. Portions of a letter, number or symbol may be separated by connecting segments not to exceed 2" in width.
5. The words "NO PARKING" pavement marking is to be used for parking facilities. For typical locations of markings, see Standard Plans A90A and A90B.
6. The words "NO PARKING", shall be painted in white letters no less than 1'-0" high on a contrasting background and located so that it is visible to traffic enforcement officials.

STATE OF CALIFORNIA
 DEPARTMENT OF TRANSPORTATION
**PAVEMENT MARKINGS
 WORDS, LIMIT AND YIELD LINES**
 NO SCALE

RSP A24E DATED JULY 20, 2012 SUPERSEDES STANDARD PLAN A24E
 DATED MAY 20, 2011 - PAGE 17 OF THE STANDARD PLANS BOOK DATED 2010.


2010 REVISED STANDARD PLAN RSP A24E

Dist	COUNTY	ROUTE	POST MILES TOTAL PROJECT	SHEET No.	TOTAL SHEETS
05	SB	101	2.2/3.3	413	786





Roberta L. McLaughlin
 REGISTERED CIVIL ENGINEER
 July 20, 2012
 PLANS APPROVAL DATE

THE STATE OF CALIFORNIA OR ITS OFFICERS OR AGENTS SHALL NOT BE RESPONSIBLE FOR THE ACCURACY OR COMPLETENESS OF SCANNED COPIES OF THIS PLAN SHEET.

TO ACCOMPANY PLANS DATED 12-7-15

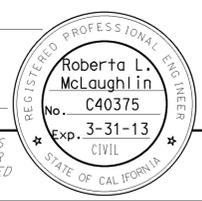


2010 REVISED STANDARD PLAN RSP A24F

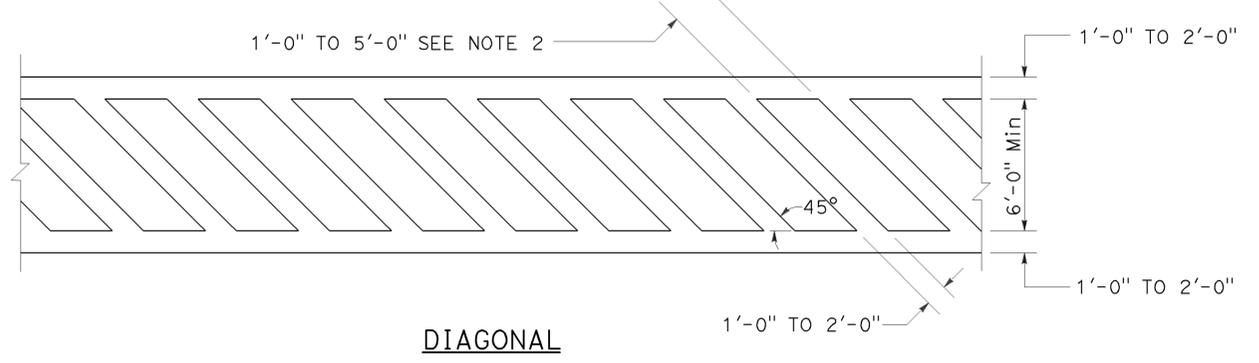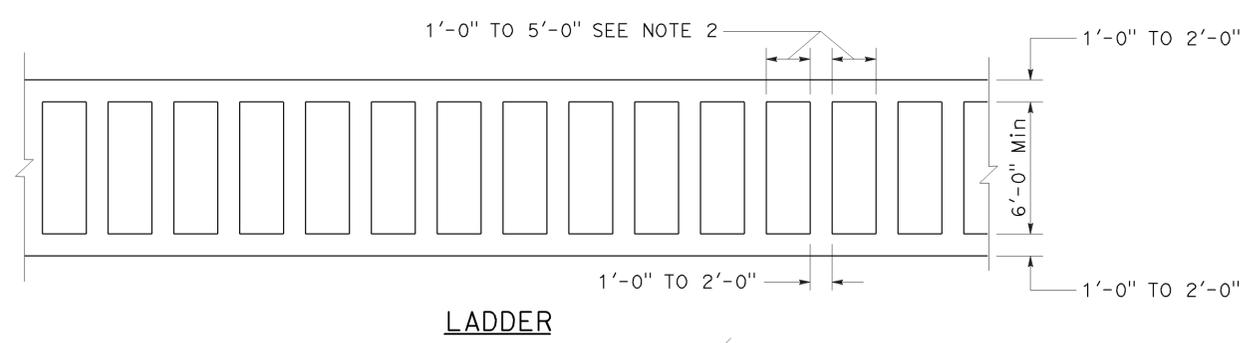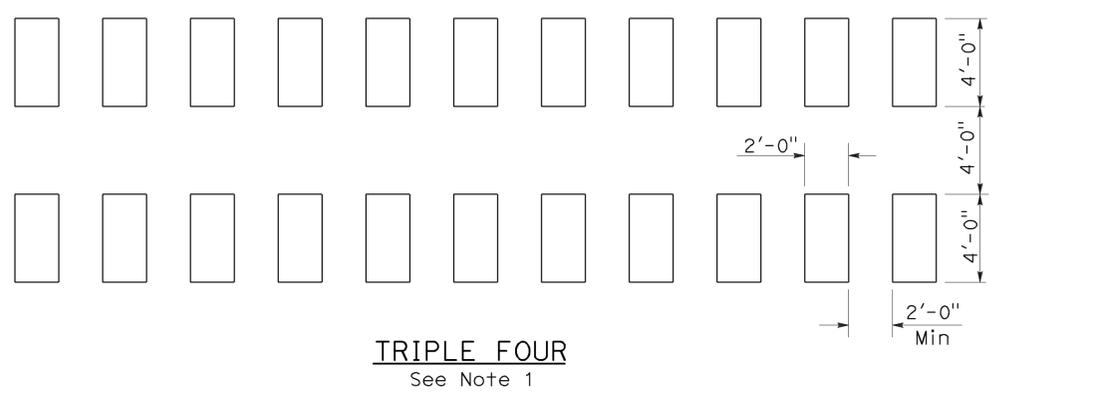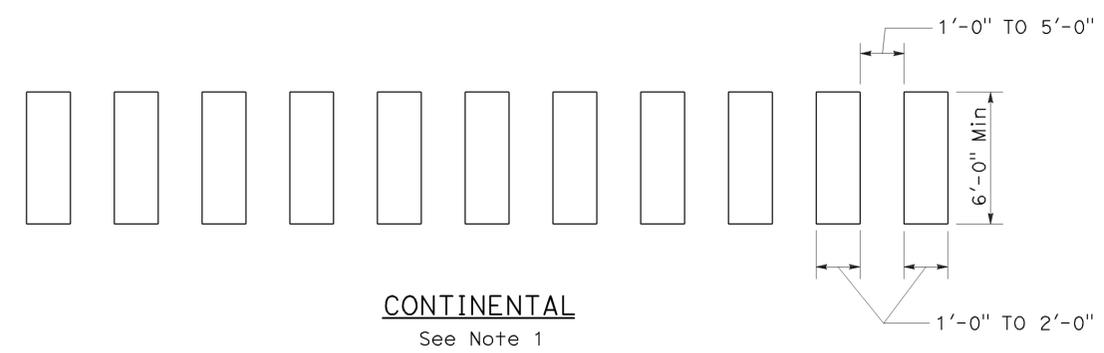

HIGHER VISIBILITY CROSSWALKS

NOTES:

1. Spaces between markings should be placed in wheel tracks of each lane.
2. Spacings not to exceed 2.5 times width of longitudinal line.
3. All crosswalk markings must be white except for those near schools must be yellow.

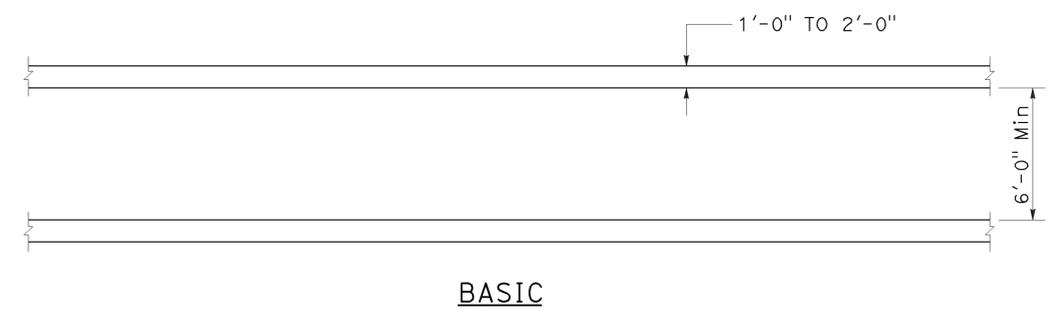

BASIC

STATE OF CALIFORNIA
DEPARTMENT OF TRANSPORTATION
**PAVEMENT MARKINGS
CROSSWALKS**
NO SCALE


RSP A24F DATED JULY 20, 2012 SUPPLEMENTS THE STANDARD PLANS BOOK DATED 2010.

Dist	COUNTY	ROUTE	POST MILES TOTAL PROJECT	SHEET No.	TOTAL SHEETS
05	SB	101	2.2/3.3	414	786


REGISTERED CIVIL ENGINEER
 October 30, 2015
 PLANS APPROVAL DATE
 THE STATE OF CALIFORNIA OR ITS OFFICERS OR AGENTS SHALL NOT BE RESPONSIBLE FOR THE ACCURACY OR COMPLETENESS OF SCANNED COPIES OF THIS PLAN SHEET.

REGISTERED PROFESSIONAL ENGINEER
 Carl M. Duan
 No. C59976
 Exp. 6-30-16
 CIVIL
 STATE OF CALIFORNIA


TO ACCOMPANY PLANS DATED 12-7-15

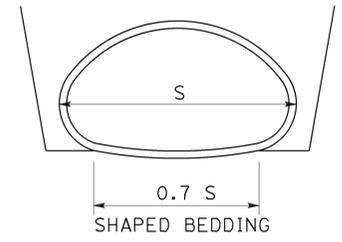


SHAPED BEDDING
S = Larger than 84"

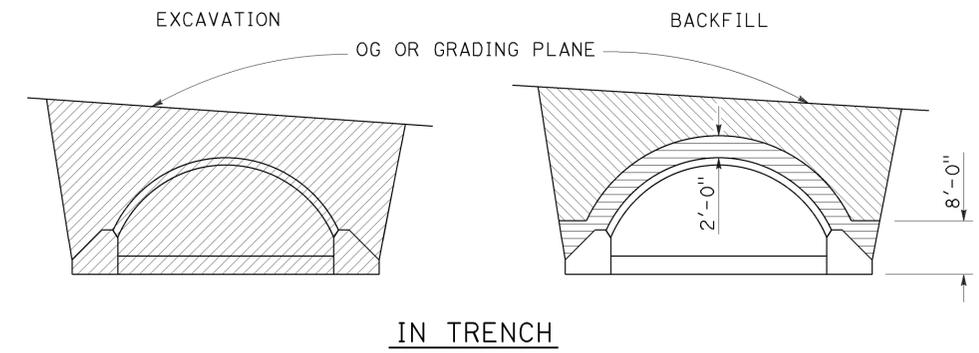

IN TRENCH

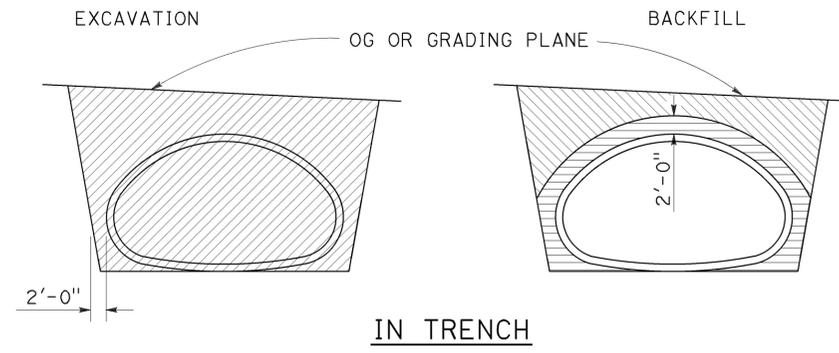


IN TRENCH

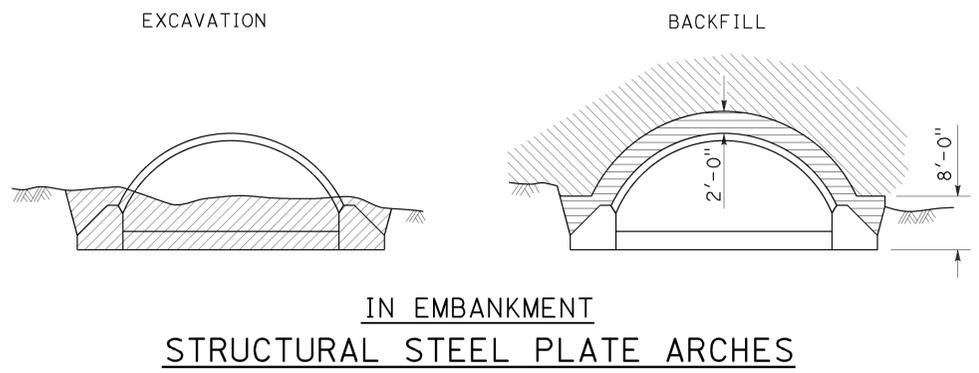

IN EMBANKMENT

STRUCTURAL STEEL PLATE ARCHES

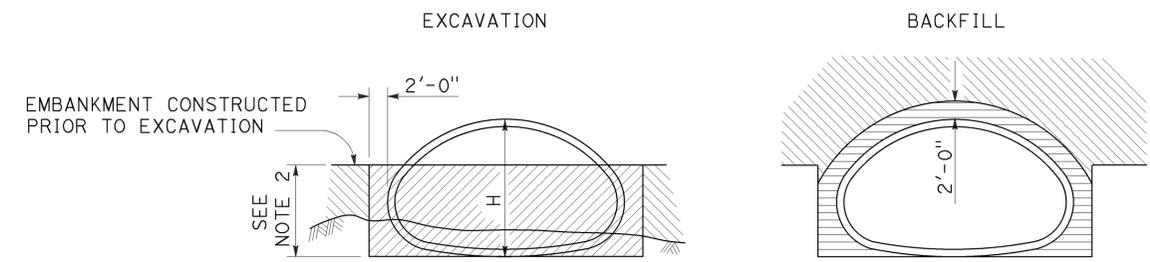


IN EMBANKMENT


STRUCTURAL STEEL PLATE PIPE ARCHES AND VEHICULAR UNDERCROSSING

NOTES:


1. PIPES: 30" minimum for diameters up to and including 42" then 2/3 diameter but no more than 60" required. CORRUGATED METAL PIPE ARCHES: 30" maximum.
2. 2/3 H up to 60" maximum.
3. Slope or shore excavation sides as necessary.
4. Backfill shall be placed full width of excavation except as noted.
5. Diagrams do not apply to overside drains.
6. Dimensions shown are minimum.
7. Construction strutting of structural steel plate pipe, arches and vehicular undercrossing to be used when shown on the project plans. When shown, see Standard Plan D88A for strutting requirements.
8. Excavation below pipe and 80% relative compaction requirements for plastic pipes only.
9. D is the inside diameter (ID) of the pipe.

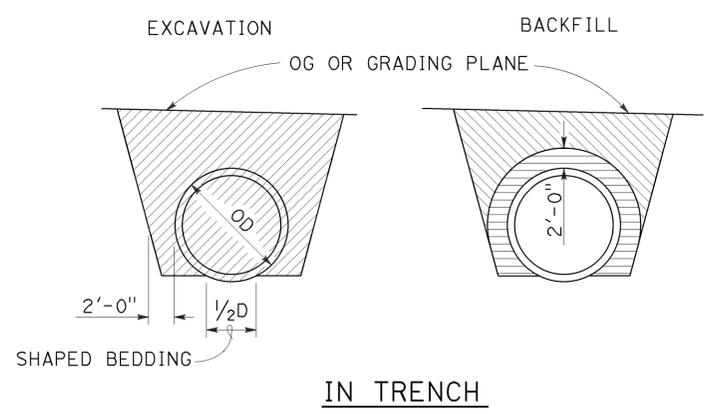

IN TRENCH

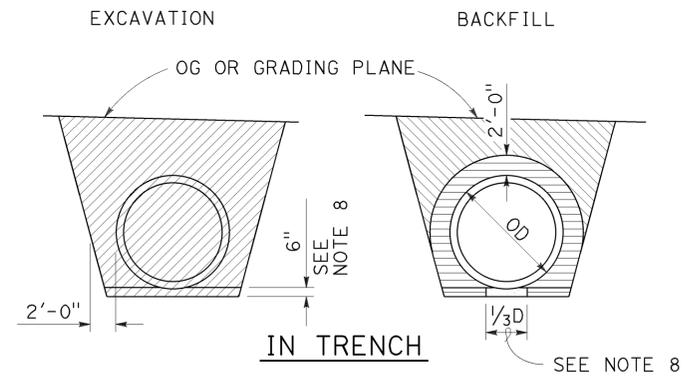


IN TRENCH

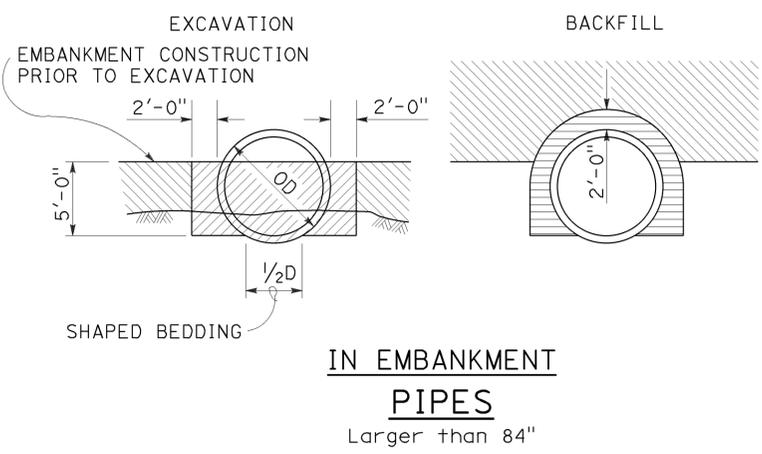

IN EMBANKMENT

PIPES
Larger than 84"

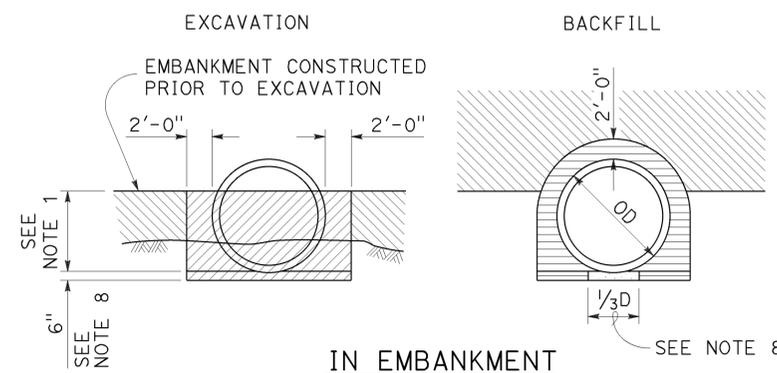

IN EMBANKMENT

METAL AND PLASTIC PIPES AND CORRUGATED METAL PIPE ARCHES

84" or Smaller

LEGEND

	STRUCTURE EXCAVATION (CULVERT)		ROADWAY EMBANKMENT
	STRUCTURE BACKFILL (CULVERT) 95% RELATIVE COMPACTION		STRUCTURE BACKFILL (CULVERT) 80% RELATIVE COMPACTION

STATE OF CALIFORNIA
DEPARTMENT OF TRANSPORTATION

EXCAVATION AND BACKFILL
METAL AND PLASTIC CULVERTS

NO SCALE

RSP A62F DATED OCTOBER 30, 2015 SUPERSEDES STANDARD PLAN A62F DATED MAY 20, 2011 - PAGE 26 OF THE STANDARD PLANS BOOK DATED 2010.

REVISED STANDARD PLAN RSP A62F

2010 REVISED STANDARD PLAN RSP A62F


Dist	COUNTY	ROUTE	POST MILES TOTAL PROJECT	SHEET No.	TOTAL SHEETS
05	SB	101	2.2/3.3	415	786

Randell D. Hiatt
REGISTERED CIVIL ENGINEER


October 30, 2015
PLANS APPROVAL DATE

THE STATE OF CALIFORNIA OR ITS OFFICERS OR AGENTS SHALL NOT BE RESPONSIBLE FOR THE ACCURACY OR COMPLETENESS OF SCANNED COPIES OF THIS PLAN SHEET.


TO ACCOMPANY PLANS DATED 12-7-15

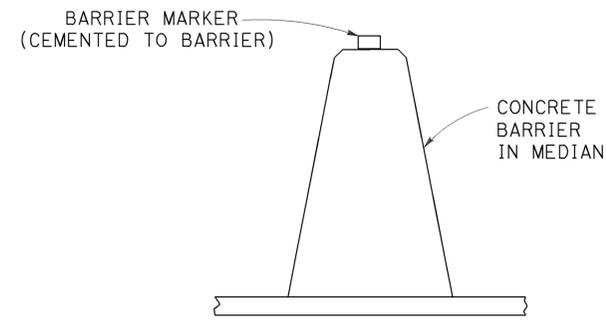

CONCRETE BARRIER TYPE 60 DELINEATION
See Note 5

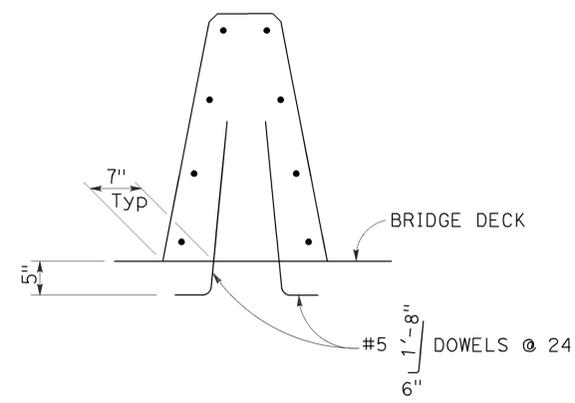


CONCRETE BARRIER TYPE 60A
Details similar to Type 60 except as noted.

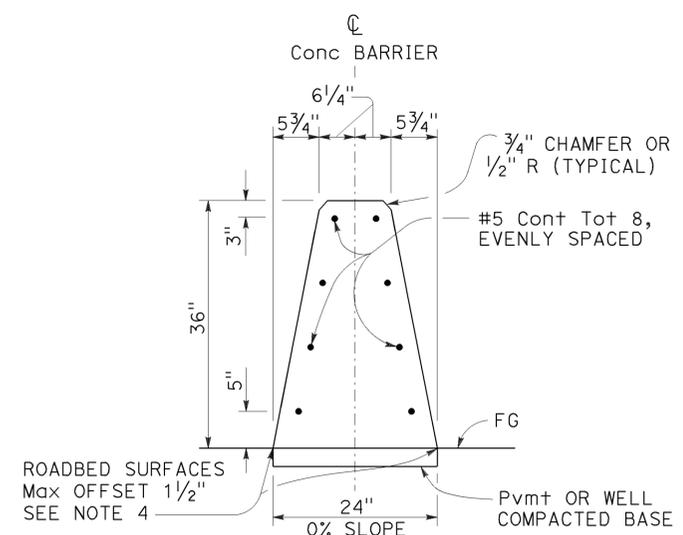


CONCRETE BARRIER TYPE 60

NOTES:

- See Standard Plan A76B for details of Concrete Barrier Type 60 end anchors, connection to structures and transitions to Concrete Barrier Type 50 and Concrete Barrier Type 60S.
- See Revised Standard Plan RSP A76C for Concrete Barrier Type 60 transitions at bridge column and sign pedestals.
- Where glare screen is required on Concrete Barrier Type 60, use Concrete Barrier Type 60G.
- Where roadbed offset is greater than 1 1/2", see Concrete Barrier Type 60C.
- See Project Plans for barrier delineation locations.
- Reinforcing stirrup not required for roadbed offsets less than 1'-0".
- For roadbed surfaces offset greater than 1 1/2" and less than or equal to 3", no reinforcement required. For roadbed surfaces offset greater than 3" and less than or equal to 8", use two #4 Reinf at 3" above the lower roadbed surface. For roadbed surfaces offset greater than 8" and less than or equal to 12", use two #4 Reinf at 3" above the lower roadbed surface and two #4 Reinf at 8" above the lower roadbed surface. For roadbed surfaces offset greater than 12" and less than or equal to 36", use two #4 Reinf at 3" above the lower roadbed surface and two #4 Reinf at every 8" increment vertical spacing above the first two #4 Reinf.

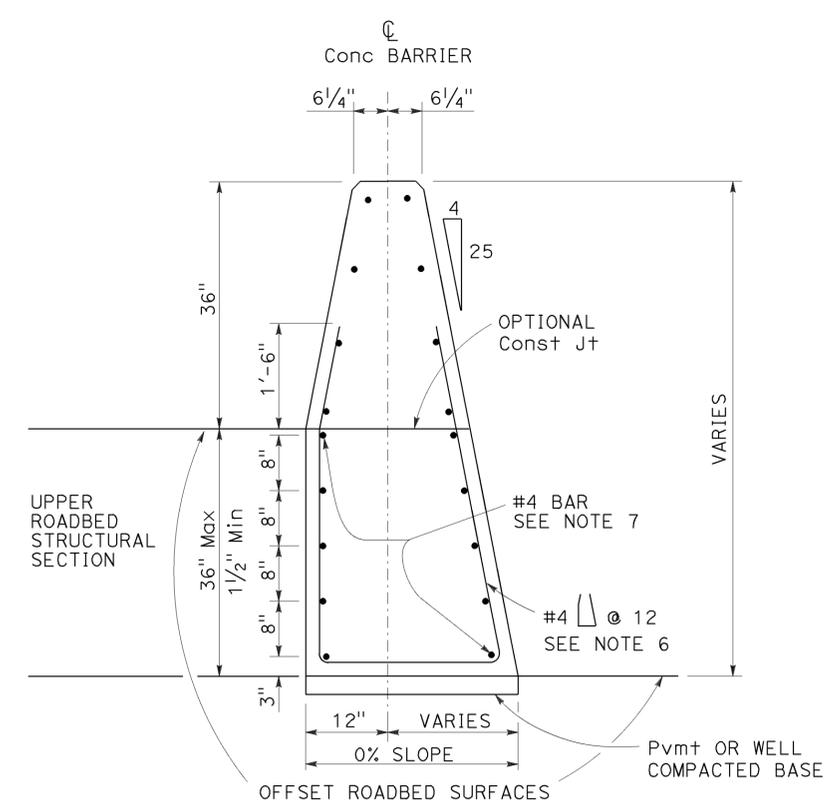

CONCRETE BARRIER TYPE 60C
Details similar to Type 60 except as noted.
Use concrete barrier end anchor when necessary.
36" roadbed surfaces offset shown.

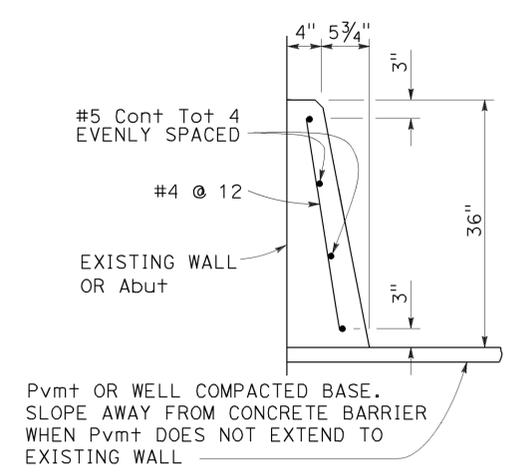

CONCRETE BARRIER TYPE 60D

STATE OF CALIFORNIA
DEPARTMENT OF TRANSPORTATION
CONCRETE BARRIER TYPE 60
NO SCALE

RSP A76A DATED OCTOBER 30, 2015 SUPERSEDES STANDARD PLAN A76A DATED MAY 20, 2011 - PAGE 34 OF THE STANDARD PLANS BOOK DATED 2010.

2010 REVISED STANDARD PLAN RSP A76A


Dist	COUNTY	ROUTE	POST MILES TOTAL PROJECT	SHEET No.	TOTAL SHEETS
05	SB	101	2.2/3.3	416	786

Randell D. Hiatt
REGISTERED CIVIL ENGINEER

July 19, 2013
PLANS APPROVAL DATE


THE STATE OF CALIFORNIA OR ITS OFFICERS OR AGENTS SHALL NOT BE RESPONSIBLE FOR THE ACCURACY OR COMPLETENESS OF SCANNED COPIES OF THIS PLAN SHEET.

TO ACCOMPANY PLANS DATED 12-7-15

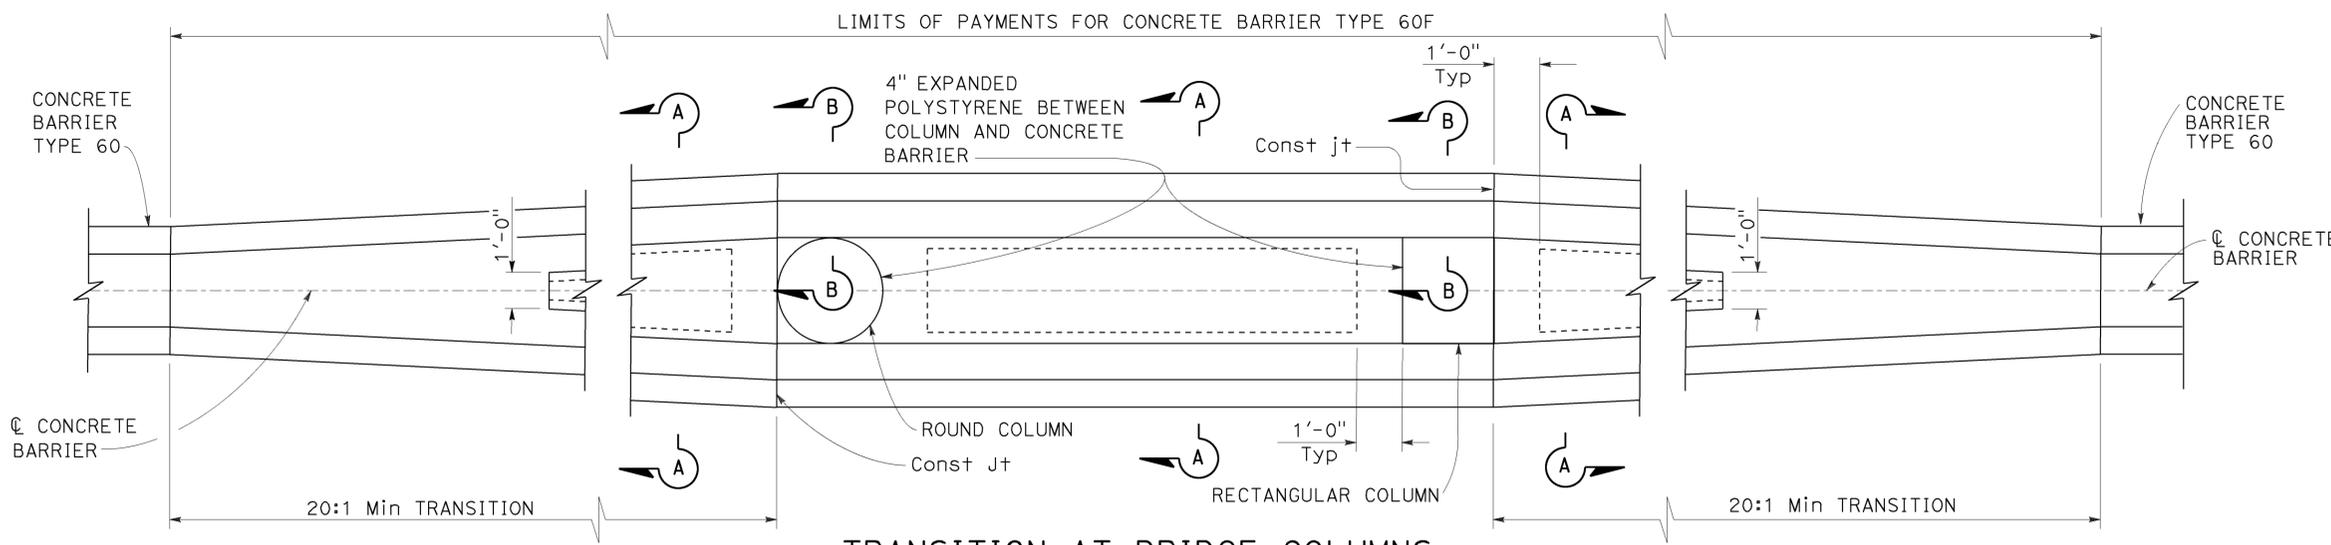


TRANSITION AT BRIDGE COLUMNS


Concrete Barrier Type 60F
See Note 7

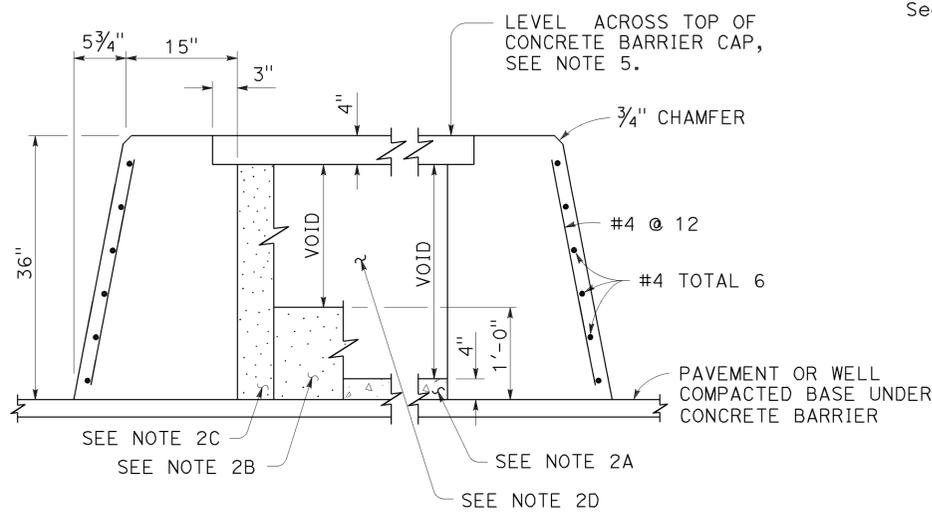

SECTION A-A

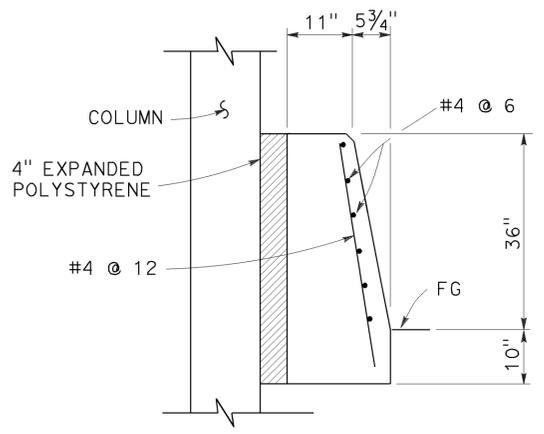


SECTION B-B

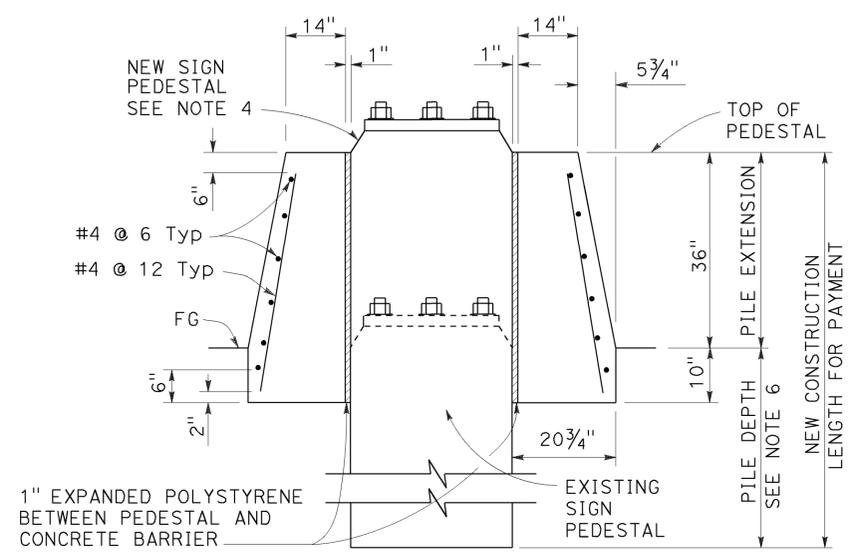

SECTION C-C

NOTES:

- See Standard Plan A76A for Concrete Barrier Type 60.
- Contractor options for fill between concrete barrier walls:
 - Place 4" PCC at base between concrete barrier walls.
 - Place 1'-0" of granular material at base between walls.
 - Place granular material from base to bottom of 4" cap.
 - Monolithic concrete with foam blockouts is not permitted.
- Reinforcing steel shall extend continuous through construction joints.
- See "Overhead Sign" plans for sign pedestal elevations on new construction.
- Adjust height of concrete barrier wall on low side of offset or superelevated roadways to provide level grade across top of concrete barrier cap.
- See Overhead Signs Standard Plan Pile Foundation Tables.
- All locations with limited shoulder width available for barrier, see Standard Plan A76F for use of Concrete Barrier Type 60GE.

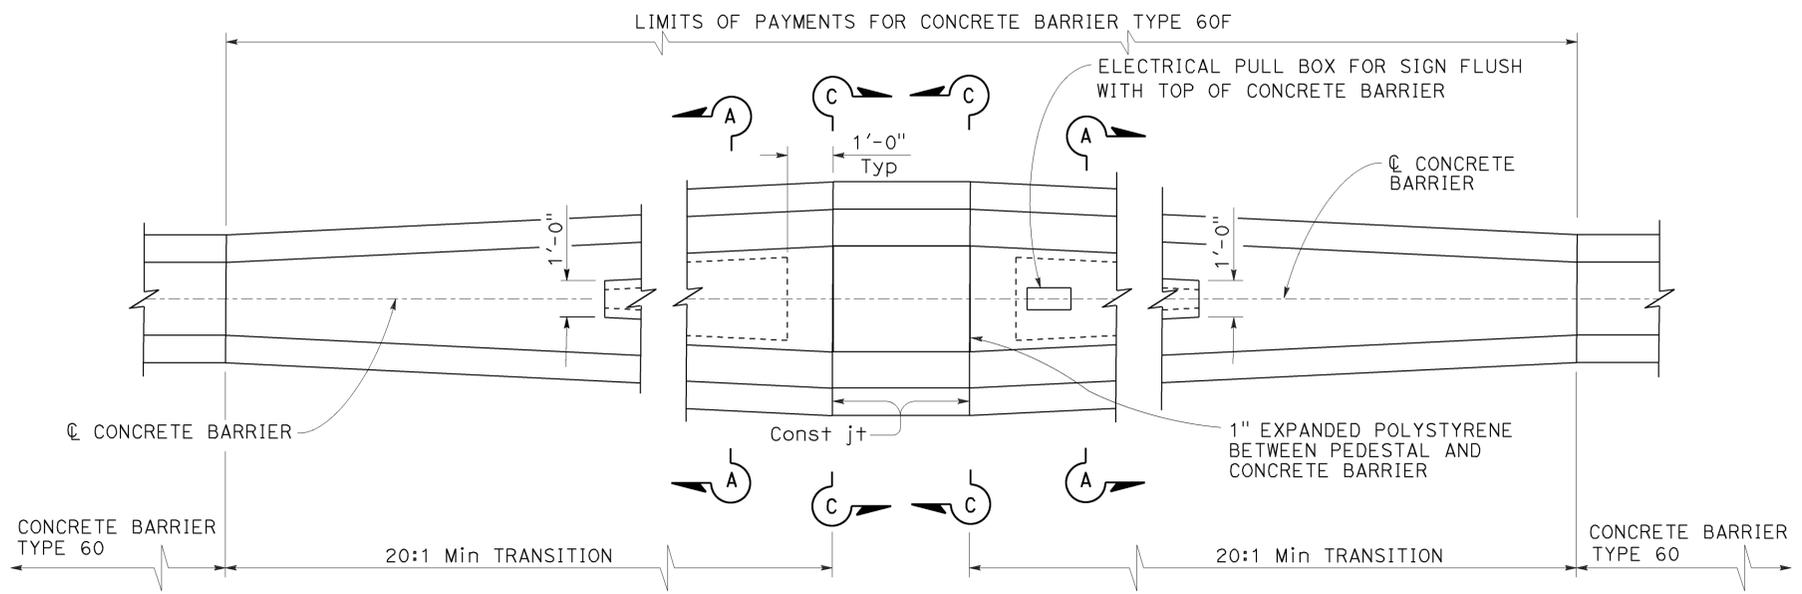

TRANSITION AT SIGN PEDESTAL

Concrete Barrier Type 60F
See Note 7

STATE OF CALIFORNIA
DEPARTMENT OF TRANSPORTATION
CONCRETE BARRIER TYPE 60F
NO SCALE

RSP A76C DATED JULY 19, 2013 SUPERSEDES STANDARD PLAN A76C
DATED MAY 20, 2011 - PAGE 36 OF THE STANDARD PLANS BOOK DATED 2010.

REVISED STANDARD PLAN RSP A76C

2010 REVISED STANDARD PLAN RSP A76C

Dist	COUNTY	ROUTE	POST MILES TOTAL PROJECT	SHEET No.	TOTAL SHEETS
05	SB	101	2.2/3.3	417	786




Randell D. Hiatt
REGISTERED CIVIL ENGINEER

July 19, 2013
PLANS APPROVAL DATE


THE STATE OF CALIFORNIA OR ITS OFFICERS OR AGENTS SHALL NOT BE RESPONSIBLE FOR THE ACCURACY OR COMPLETENESS OF SCANNED COPIES OF THIS PLAN SHEET.

TO ACCOMPANY PLANS DATED 12-7-15


REGISTERED PROFESSIONAL ENGINEER
No. C50200
Exp. 6-30-15
CIVIL
STATE OF CALIFORNIA

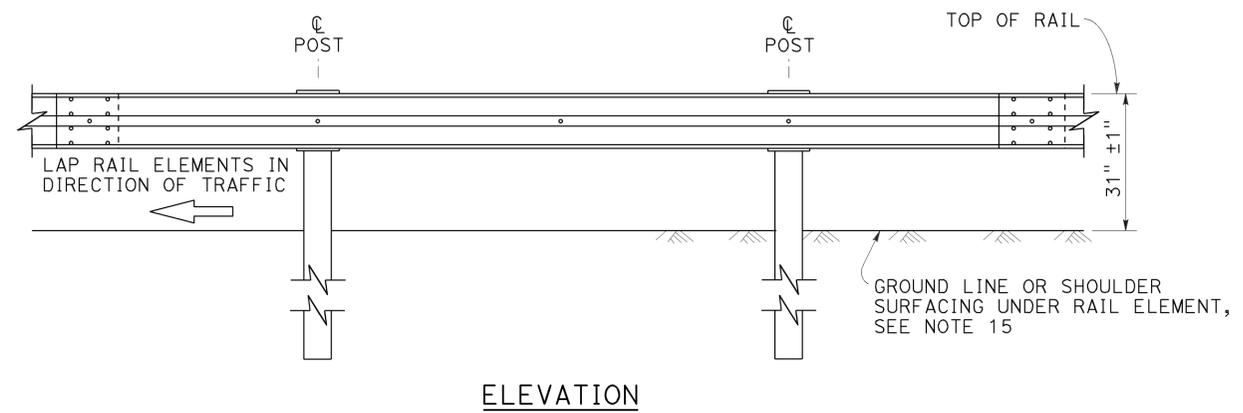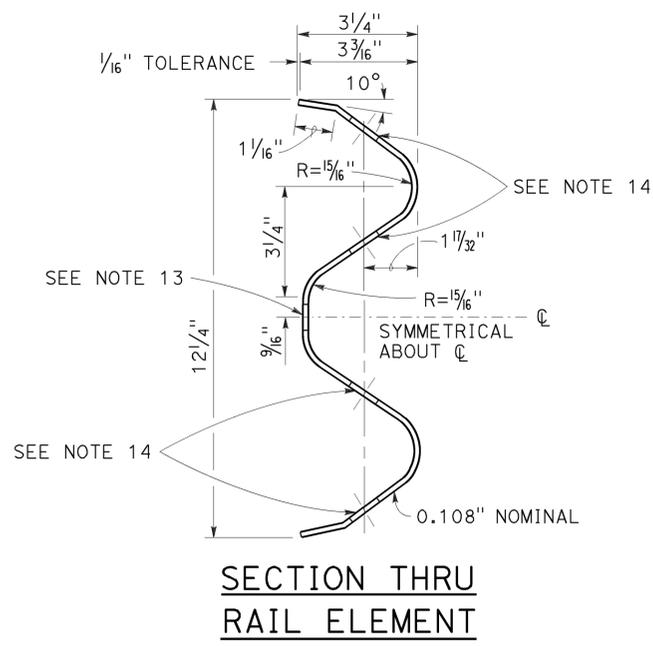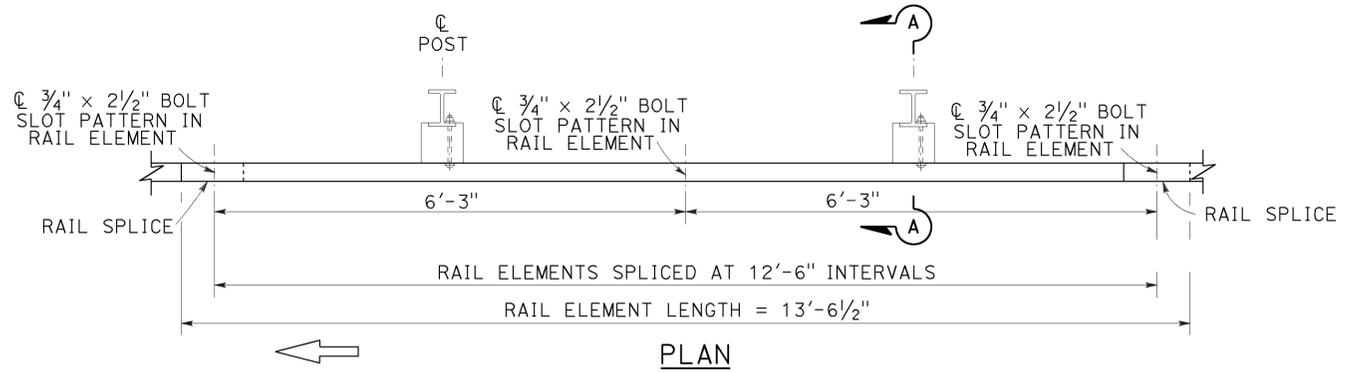

MIDWEST GUARDRAIL SYSTEM WITH STEEL POSTS AND NOTCHED WOOD OR NOTCHED RECYCLED PLASTIC BLOCKS

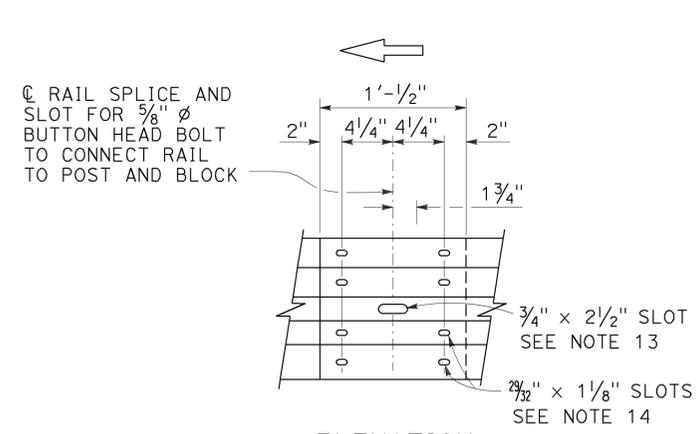

- Connect the overlapped end of the rail elements with 5/8" ϕ x 1 3/8" button head oval shoulder splice bolts inserted into the 7/32" x 1 1/8" slots and bolted together with 5/8" ϕ recessed hex nuts. Recess of hex nut points toward rail element. A total of 8 bolts and nuts are to be used at each rail splice connection.
- The ends of the rail elements are to be overlapped in the direction of traffic (see details).
- Where end cap is to be attached to the end of a rail element, a total of 4 of the above described splice bolts and nuts are to be used.

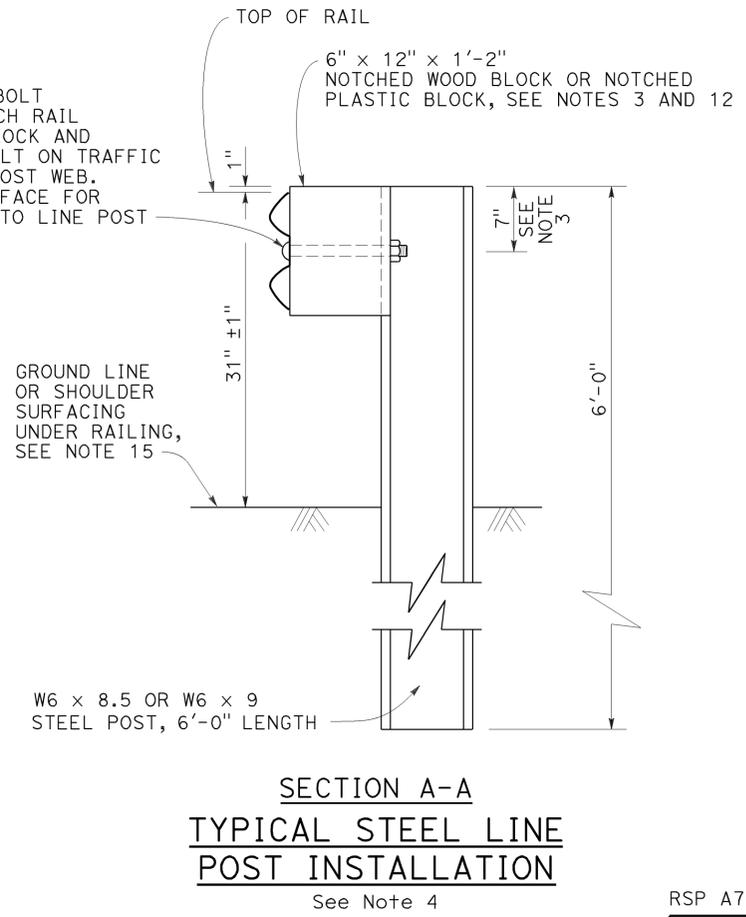

NOTES:

- For details of wood post installations, see Revised Standard Plan RSP A77L1.
- For details of standard hardware used to construct MGS, see Revised Standard Plan RSP A77M1.
- For details of steel posts and notched wood blocks used to construct MGS, see Revised Standard Plan RSP A77N2.
- For additional installation details, see Revised Standard Plan RSP A77N3.
- MGS post spacing to be 6'-3" center to center, except as otherwise noted.
- For MGS typical layouts, see the A77P, A77Q and A77R Series of Standard Plans.
- If railing is connected to terminal system end treatment, use 31" height terminal system end treatment.
- For MGS end anchor details, see Revised Standard Plans RSP A77S1 and RSP A77T2.
- For details of MGS transition to bridge railing, see Revised Standard Plan RSP A77U4.
- For additional details of MGS connection to bridge railings, see Revised Standard Plans RSP A77U1, RSP A77U2 and RSP A77V1.
- For dike positioning and MGS delineation details, see Revised Standard Plan RSP A77N4.
- Notched face of block faces steel post.
- Slotted hole for bolted connection of rail element to block and post. See "Section Thru Rail Element".
- Slotted holes for splice bolts to overlap ends of rail element. See "Section Thru Rail Element".
- Install posts in soil.

STATE OF CALIFORNIA
DEPARTMENT OF TRANSPORTATION

**MIDWEST GUARDRAIL SYSTEM
STANDARD RAILING SECTION
(STEEL POST WITH NOTCHED
WOOD OR NOTCHED
RECYCLED PLASTIC BLOCK)**

NO SCALE

RSP A77L2 DATED JULY 19, 2013 SUPPLEMENTS THE STANDARD PLANS BOOK DATED 2010.

REVISED STANDARD PLAN RSP A77L2


2010 REVISED STANDARD PLAN RSP A77L2

Dist	COUNTY	ROUTE	POST MILES TOTAL PROJECT	SHEET No.	TOTAL SHEETS
05	SB	101	2.2/3.3	418	786


Randell D. Hiatt
REGISTERED CIVIL ENGINEER

July 19, 2013
PLANS APPROVAL DATE

THE STATE OF CALIFORNIA OR ITS OFFICERS OR AGENTS SHALL NOT BE RESPONSIBLE FOR THE ACCURACY OR COMPLETENESS OF SCANNED COPIES OF THIS PLAN SHEET.

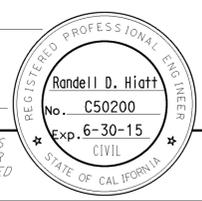


TO ACCOMPANY PLANS DATED 12-7-15

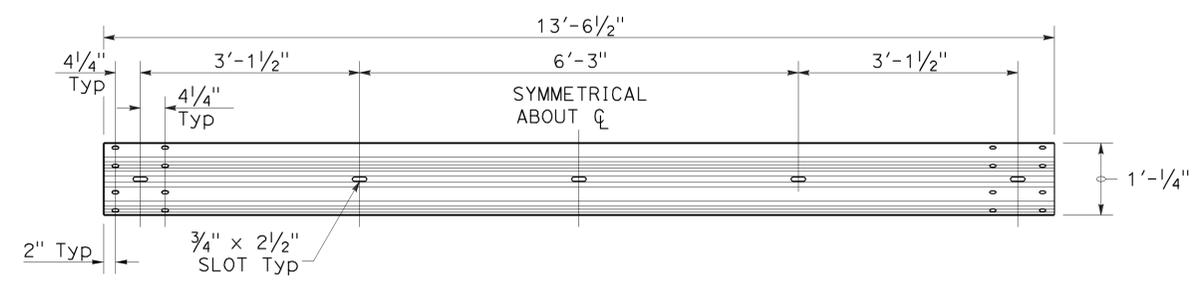


TYPICAL RAIL ELEMENT

NOTE:

1. Slotted holes for splice bolts to overlap ends of rail element.

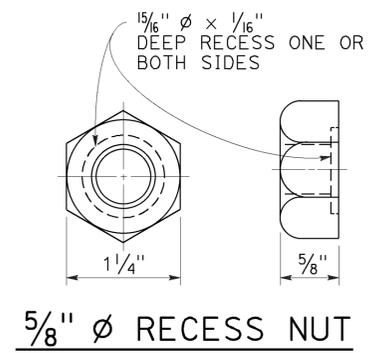

5/8" Ø RECESS NUT

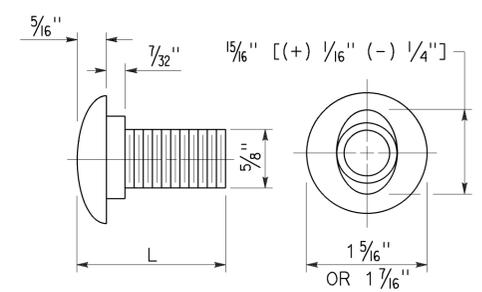


5/8" Ø BUTTON HEAD BOLT


BUTTON HEAD BOLT

L	THREAD LENGTH
1 3/8"	FULL THREAD LENGTH
2"	FULL THREAD LENGTH
10"	4" Min THREAD LENGTH
18"	4" Min THREAD LENGTH
20"	4" Min THREAD LENGTH
22"	4" Min THREAD LENGTH
26"	4" Min THREAD LENGTH
36"	4" Min THREAD LENGTH
** 2 3/4"	2" Min THREAD LENGTH
** 19"	4" Min THREAD LENGTH

** For nested rail applications.

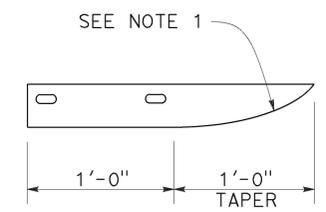

PLAN

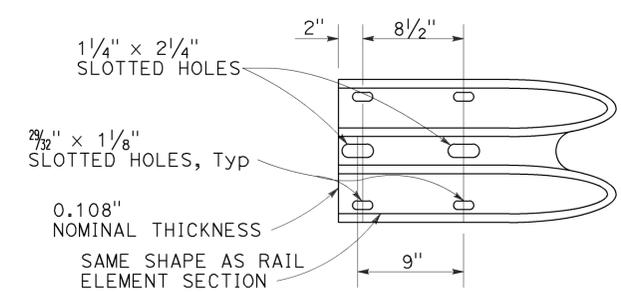

**ELEVATION
END CAP
(TYPE A)**

STATE OF CALIFORNIA
DEPARTMENT OF TRANSPORTATION

**MIDWEST GUARDRAIL SYSTEM
STANDARD HARDWARE**

NO SCALE

RSP A77M1 DATED JULY 19, 2013 SUPPLEMENTS THE STANDARD PLANS BOOK DATED 2010.

REVISED STANDARD PLAN RSP A77M1

2010 REVISED STANDARD PLAN RSP A77M1

DIST	COUNTY	ROUTE	POST MILES TOTAL PROJECT	SHEET No.	TOTAL SHEETS
05	SB	101	2.2/3.3	419	786

Randell D. Hiatt
REGISTERED CIVIL ENGINEER

November 15, 2013
PLANS APPROVAL DATE

THE STATE OF CALIFORNIA OR ITS OFFICERS OR AGENTS SHALL NOT BE RESPONSIBLE FOR THE ACCURACY OR COMPLETENESS OF SCANNED COPIES OF THIS PLAN SHEET.


REGISTERED PROFESSIONAL ENGINEER
No. C50200
Exp. 6-30-15
CIVIL
STATE OF CALIFORNIA

TO ACCOMPANY PLANS DATED 12-7-15


NOTES:

1. All holes in steel post shall be $\frac{13}{16}$ " Dia maximum.
2. Dimensions shown for wood block are nominal.
3. Notched face of block faces steel post.
4. 6'-0" length posts to be used for typical roadway installation. See Revised Standard Plan RSP A77N3.
5. See Revised Standard Plan RSP A77L3 for use of 6" x 8" and 8" x 8" notched wood blocks.
6. This post and 8" x 12" block combination to be used for line post sections of MGS on narrow roadways and where strengthened line post sections of MGS are warranted to shield fixed objects.


2010 REVISED STANDARD PLAN RSP A77N2

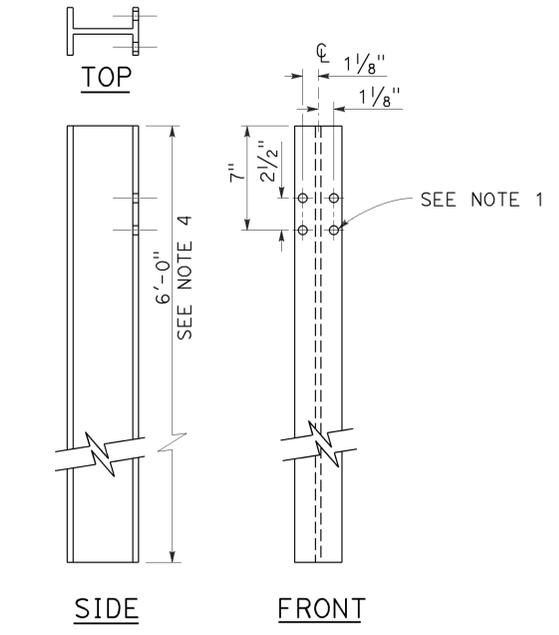


**W6 x 9 OR W6 x 8.5
STEEL POST**
See Note 4

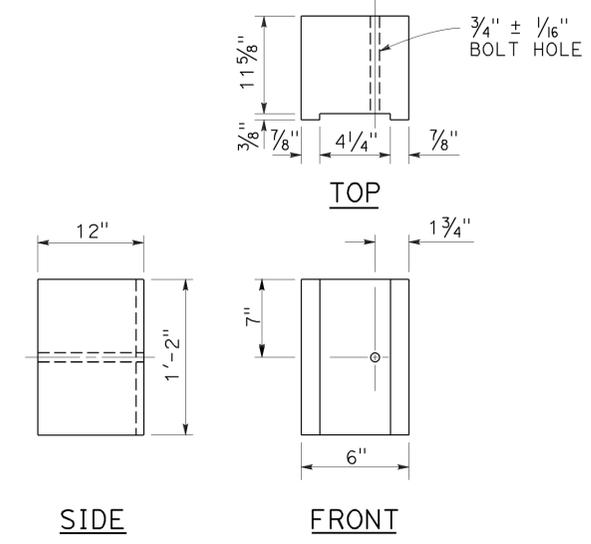


**6" x 12"
NOTCHED WOOD BLOCK**
See Notes 2 and 3

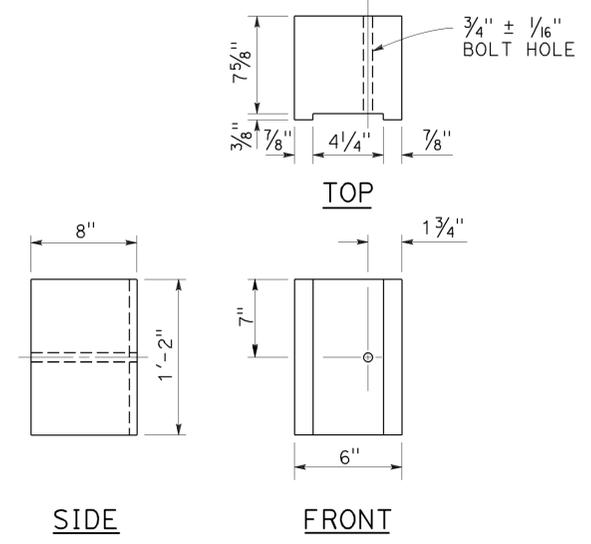


**6" x 8"
NOTCHED WOOD BLOCK**
Only for use with metal beam guard railing. See Note 5

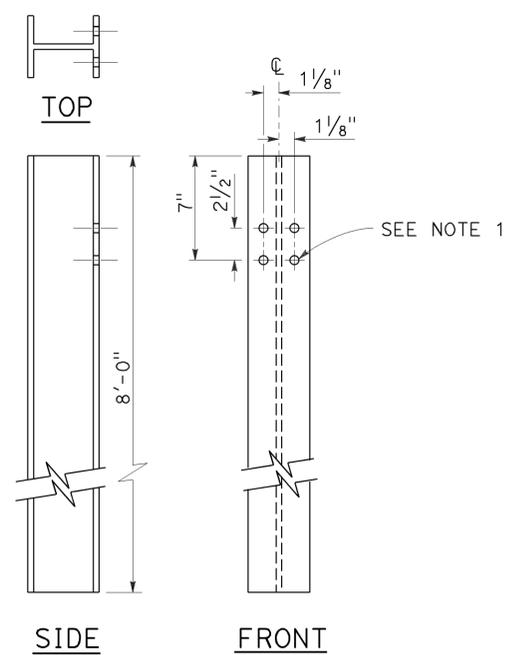

**W6 x 15
STEEL POST**
See Note 6

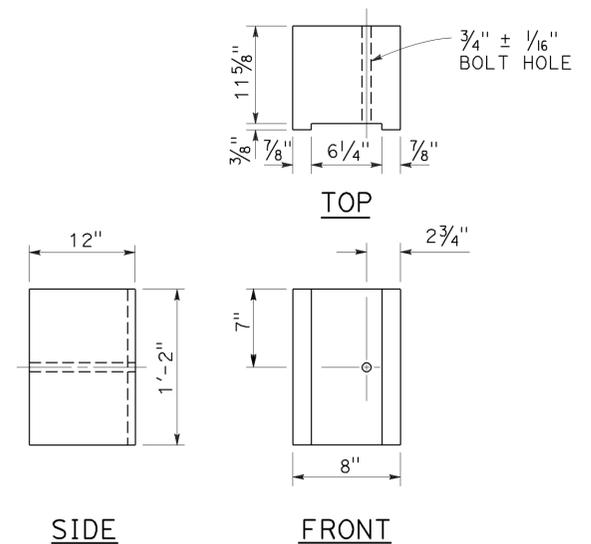

**8" x 12"
NOTCHED WOOD BLOCK**
See Notes 2 and 3

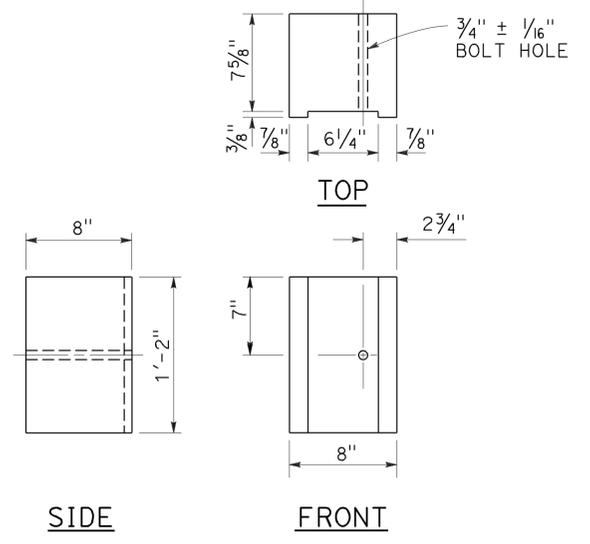

**8" x 8"
NOTCHED WOOD BLOCK**
Only for use with metal beam guard railing. See Note 5

STATE OF CALIFORNIA
DEPARTMENT OF TRANSPORTATION

**MIDWEST GUARDRAIL SYSTEM
STEEL POST AND
NOTCHED WOOD BLOCK DETAILS**

NO SCALE

RSP A77N2 DATED NOVEMBER 15, 2013 SUPERSEDES RSP A77N2
DATED JULY 19, 2013 THAT SUPPLEMENTS THE STANDARD PLANS BOOK DATED 2010.

REVISED STANDARD PLAN RSP A77N2

Dist	COUNTY	ROUTE	POST MILES TOTAL PROJECT	SHEET No.	TOTAL SHEETS
05	SB	101	2.2/3.3	420	786


Randell D. Hiatt
REGISTERED CIVIL ENGINEER

November 15, 2013
PLANS APPROVAL DATE


THE STATE OF CALIFORNIA OR ITS OFFICERS OR AGENTS SHALL NOT BE RESPONSIBLE FOR THE ACCURACY OR COMPLETENESS OF SCANNED COPIES OF THIS PLAN SHEET.

REGISTERED PROFESSIONAL ENGINEER
Randell D. Hiatt
No. C50200
Exp. 6-30-15
CIVIL
STATE OF CALIFORNIA


TO ACCOMPANY PLANS DATED 12-7-15

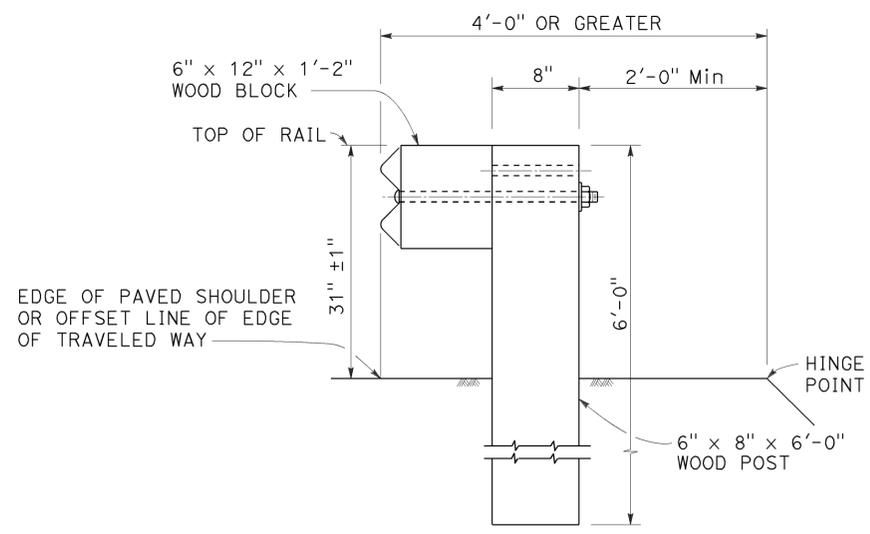


DETAIL A
TYPICAL ROADWAY
INSTALLATION
See Note 1

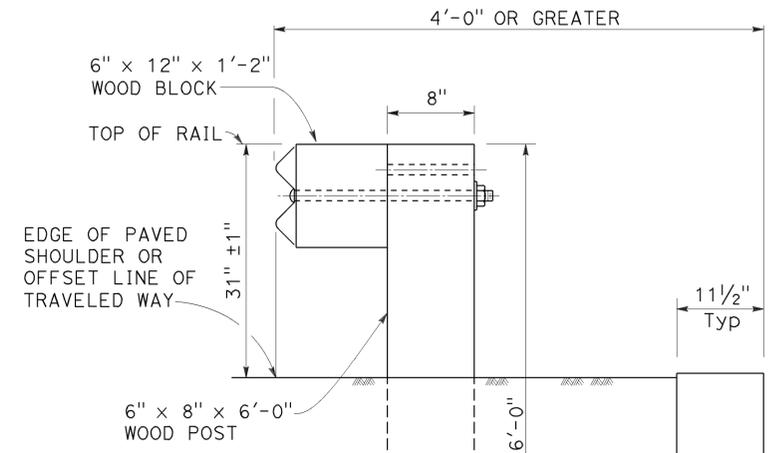

DETAIL C

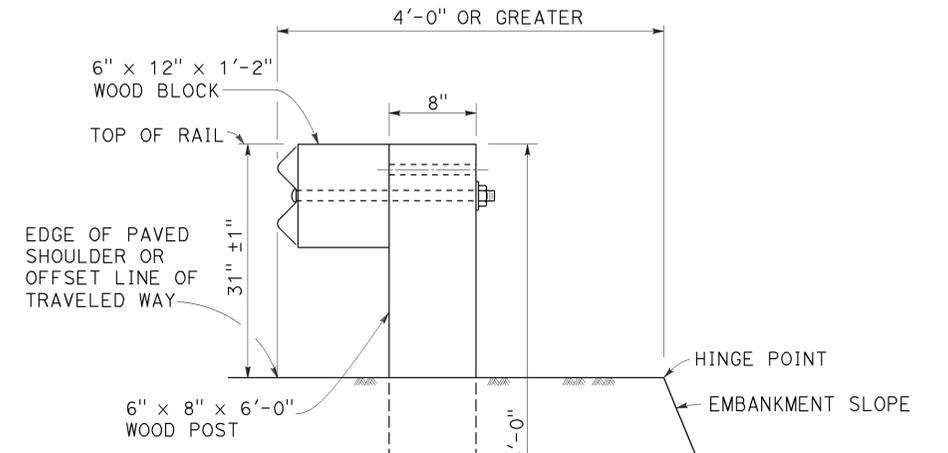

DETAIL D

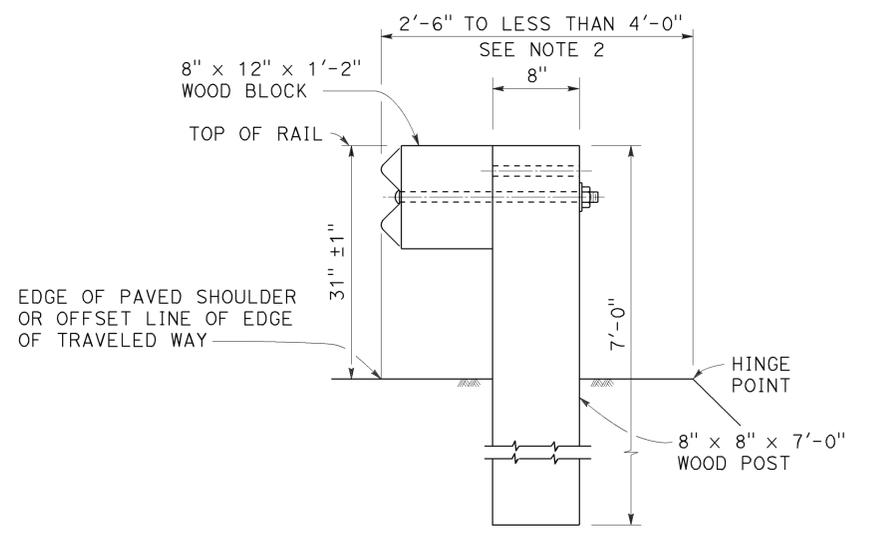

DETAIL B
NARROW ROADWAY
INSTALLATION
See Note 1

POST EMBEDMENT

INSTALLATION AT EARTH RETAINING WALLS

NOTES:

1. These installation details also applicable to steel line post installations. For Detail A, C, and D, where steel line post installations are constructed, W6 x 8.5 or W6 x 9 steel post, 6'-0" in length, with 6" x 12" x 1'-2" notched wood blocks or notched recycled plastic blocks are to be used in place of the size of wood post and wood block shown. For Detail B, where steel line post installations are constructed, W6 x 15 steel post, 8'-0" in length, with 8" x 12" x 1'-2" notched wood blocks or notched recycled plastic blocks are to be used in place of the size of wood post and wood block shown. For additional installation details, see Revised Standard Plan RSP A77L1 and RSP A77L2.
2. Where the distance between the face of the rail and the hinge point is less than 2'-6", see the Project Plans for special details.
3. For dike positioning with MGS installations, see Revised Standard Plan RSP A77N4.

STATE OF CALIFORNIA
DEPARTMENT OF TRANSPORTATION

MIDWEST GUARDRAIL SYSTEM
TYPICAL LINE POST
EMBEDMENT AND
HINGE POINT OFFSET DETAILS

NO SCALE

RSP A77N3 DATED NOVEMBER 15, 2013 SUPERSEDES RSP A77N3
DATED JULY 19, 2013 THAT SUPPLEMENTS THE STANDARD PLANS BOOK DATED 2010.

REVISED STANDARD PLAN RSP A77N3

2010 REVISED STANDARD PLAN RSP A77N3

Dist	COUNTY	ROUTE	POST MILES TOTAL PROJECT	SHEET No.	TOTAL SHEETS
05	SB	101	2.2/3.3	421	786

Randell D. Hiatt
REGISTERED CIVIL ENGINEER

July 19, 2013
PLANS APPROVAL DATE


THE STATE OF CALIFORNIA OR ITS OFFICERS OR AGENTS SHALL NOT BE RESPONSIBLE FOR THE ACCURACY OR COMPLETENESS OF SCANNED COPIES OF THIS PLAN SHEET.

REGISTERED PROFESSIONAL ENGINEER
No. C50200
Exp. 6-30-15
CIVIL
STATE OF CALIFORNIA


TO ACCOMPANY PLANS DATED 12-7-15

NOTES:

1. When necessary to place dike more than 7" in front of face of MGS, only Type C dike may be used. For dike details, see Revised Standard Plan RSP A87B.
2. For standard railing post embedment, see Revised Standard Plan RSP A77N3.
3. MGS delineation to be used where shown on the Project Plans.
4. When dike or curb is placed under MGS, the maximum height of the dike or curb shall be 6". Mountable dike should not be used. For dike and curb details, see Revised Standard Plans RSP A87A and RSP A87B.
5. For details of typical distance between the face of rail and hinge point, see Revised Standard Plan RSP A77N3.
6. For steel line posts, use 1/4" - 20 self-tapping screws in 0.22" diameter holes or 1/4" bolts in 3/32" diameter holes.

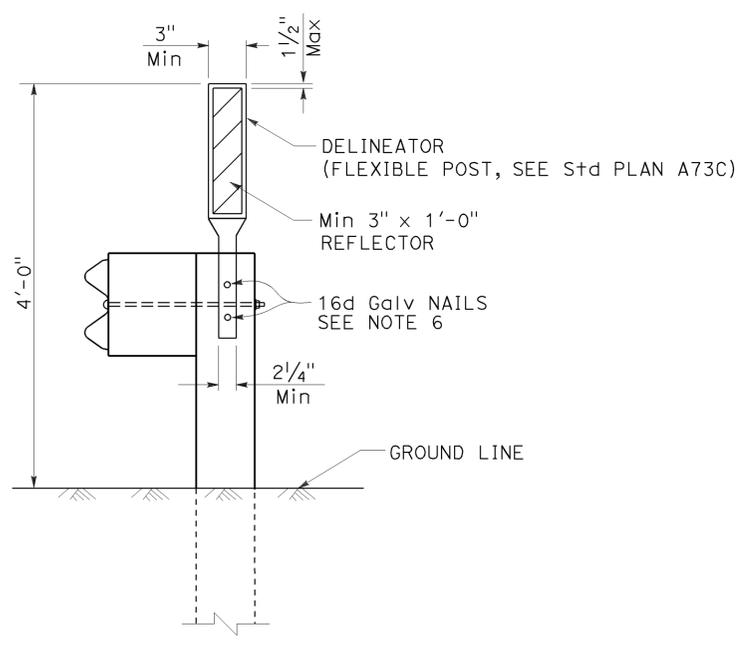

MGS DELINEATION
See Note 3

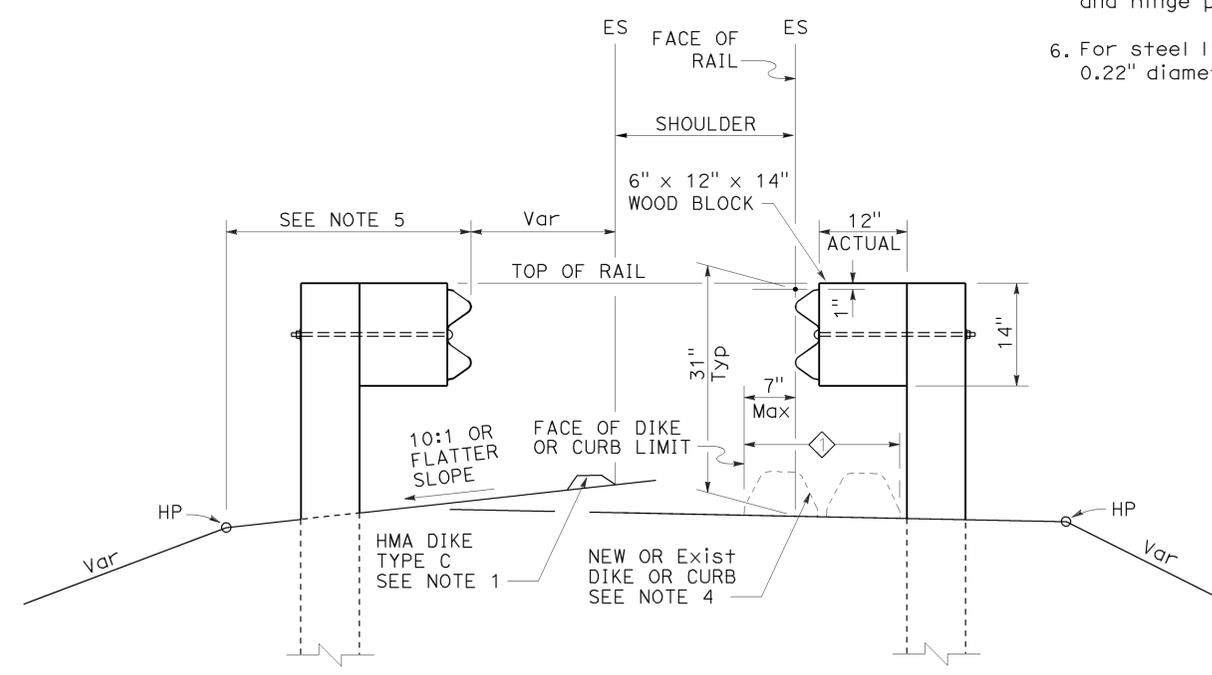

DIKE POSITIONING
See Note 1

◇ PERMISSIBLE DIKE OR CURB PLACEMENT AREA

STATE OF CALIFORNIA
DEPARTMENT OF TRANSPORTATION

**MIDWEST GUARDRAIL SYSTEM
TYPICAL RAILING DELINEATION
AND DIKE POSITIONING DETAILS**
NO SCALE


RSP A77N4 DATED JULY 19, 2013 SUPPLEMENTS THE STANDARD PLANS BOOK DATED 2010.

REVISED STANDARD PLAN RSP A77N4


2010 REVISED STANDARD PLAN RSP A77N4

Dist	COUNTY	ROUTE	POST MILES TOTAL PROJECT	SHEET No.	TOTAL SHEETS
05	SB	101	2.2/3.3	423	786

RANDALL D. HIATT
 REGISTERED CIVIL ENGINEER
 July 19, 2013
 PLANS APPROVAL DATE
THE STATE OF CALIFORNIA OR ITS OFFICERS OR AGENTS SHALL NOT BE RESPONSIBLE FOR THE ACCURACY OR COMPLETENESS OF SCANNED COPIES OF THIS PLAN SHEET.

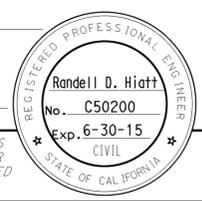


TO ACCOMPANY PLANS DATED 12-7-15

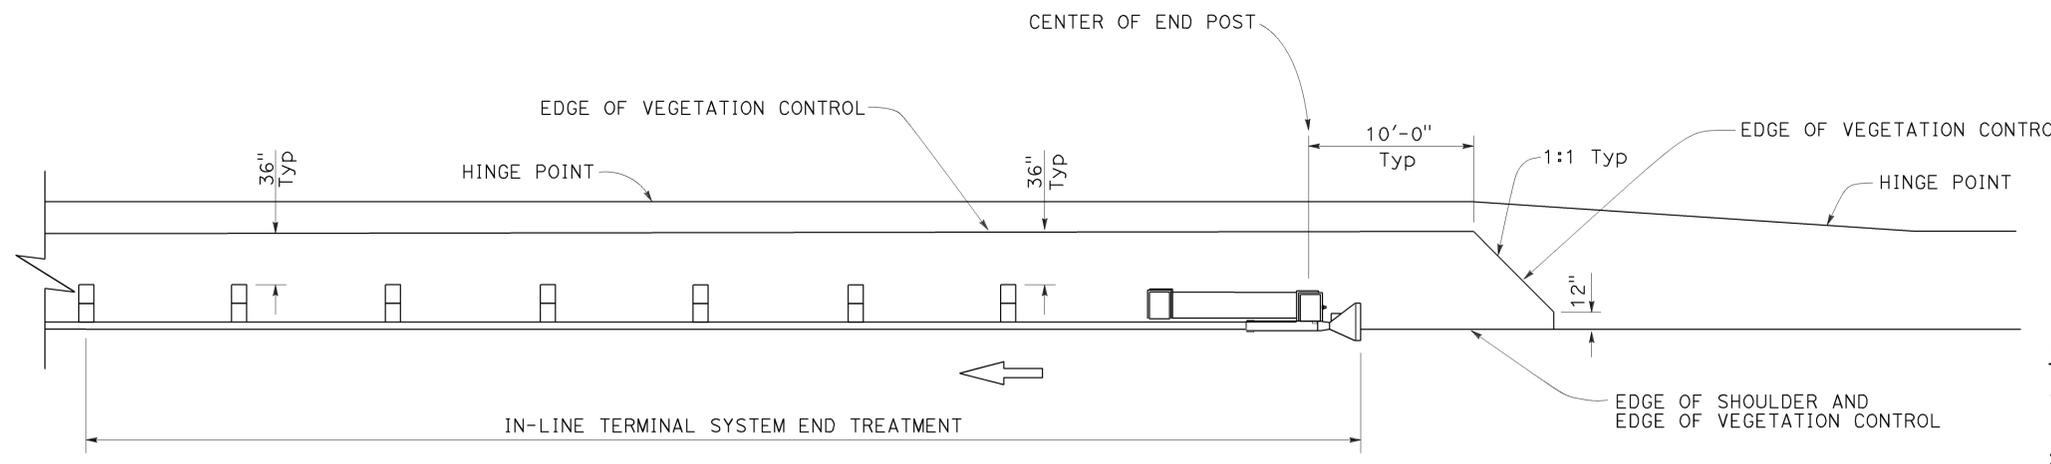


PLAN

NOTES:

1. See Revised Standard Plan RSP A77N5 for additional vegetation control details.
2. Where the distance between back of post and hinge point is less than 42", construct vegetation control to 6" from hinge point while maintaining the 8" block-out at back of post. If the 8" block-out at back of post can not be maintained, construct vegetation control flush with the back edge of post.
3. Where dike is constructed under railing, construct vegetation control to back edge of dike. Where paved shoulder is constructed within 36" in front of the post, construct vegetation control to the edge of paved shoulder.

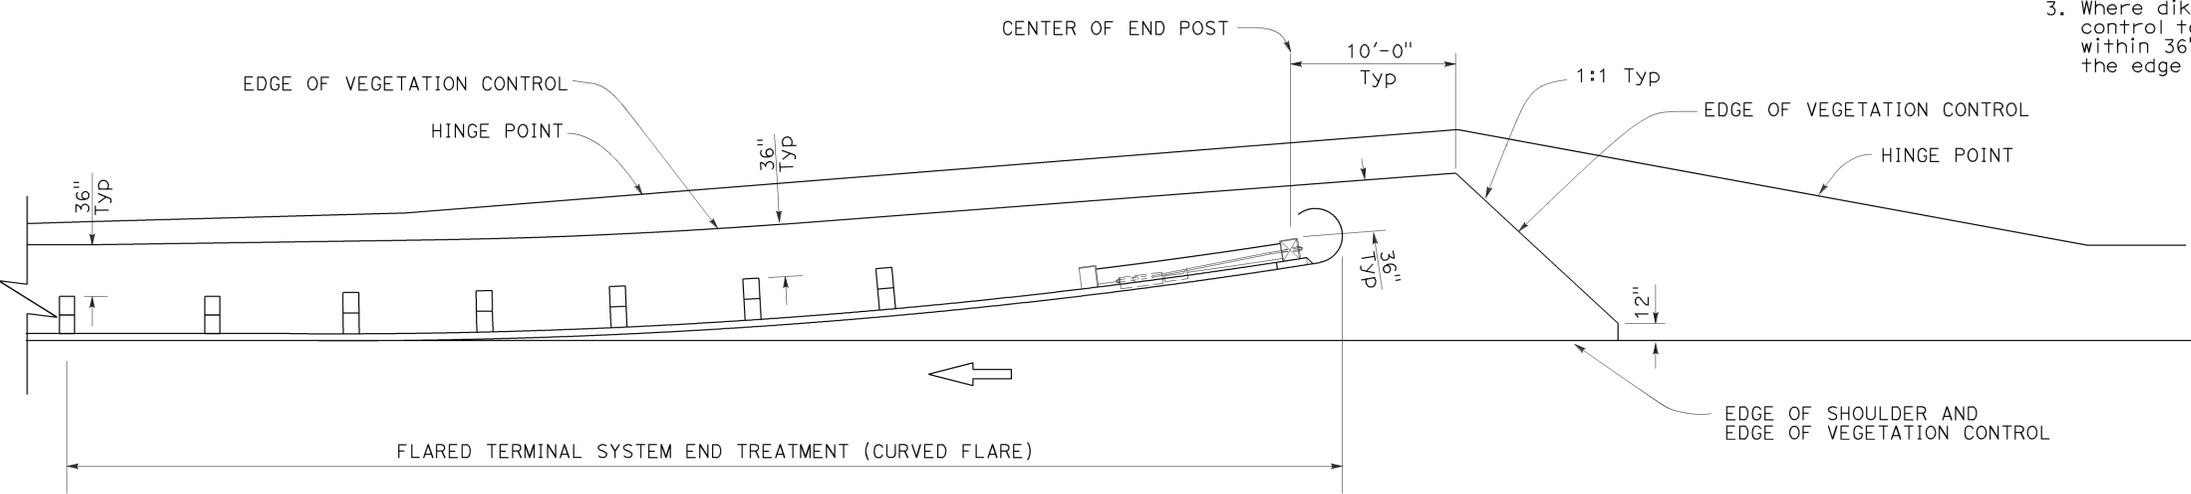

PLAN

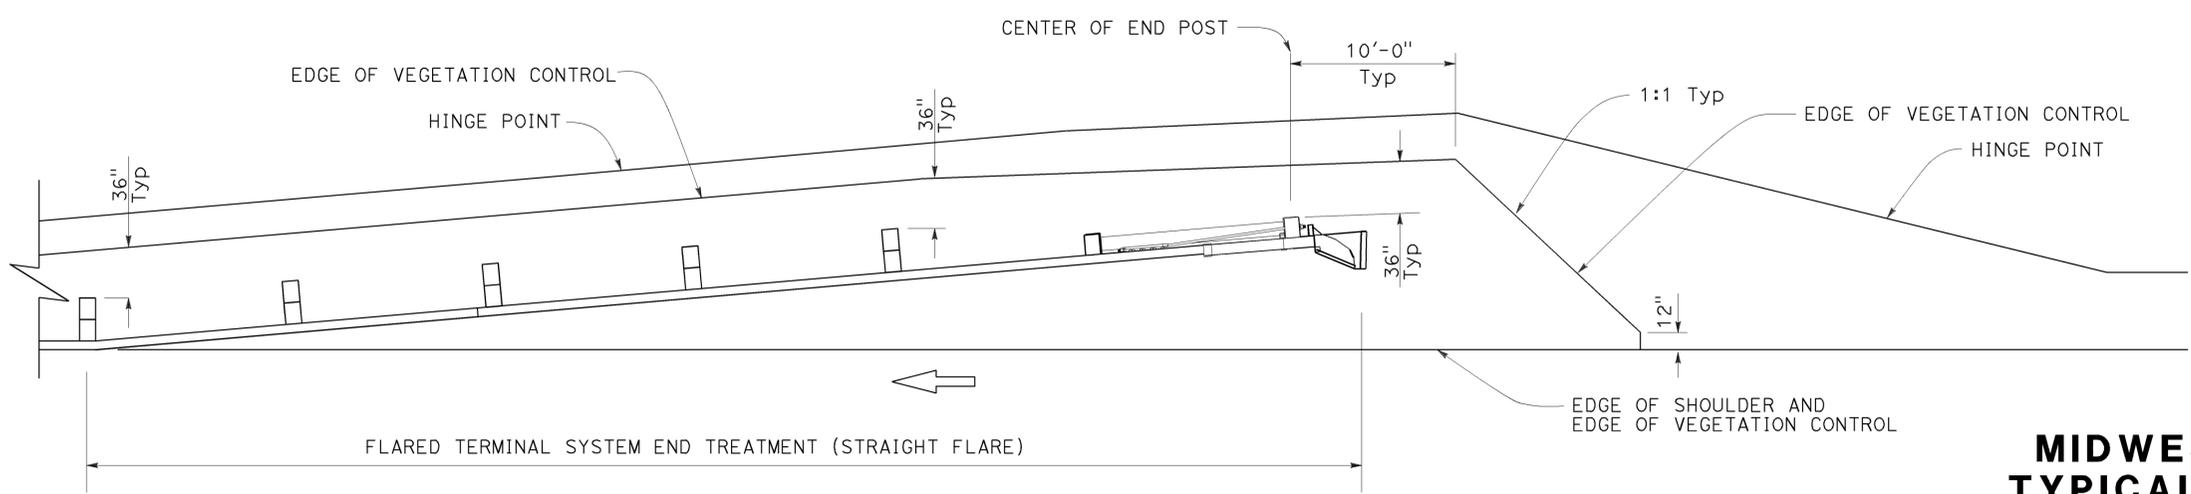

PLAN

STATE OF CALIFORNIA
 DEPARTMENT OF TRANSPORTATION
**MIDWEST GUARDRAIL SYSTEM
 TYPICAL VEGETATION CONTROL
 FOR TERMINAL SYSTEM END TREATMENTS**
 NO SCALE

RSP A77N6 DATED JULY 19, 2013 SUPPLEMENTS THE STANDARD PLANS BOOK DATED 2010.

REVISED STANDARD PLAN RSP A77N6

2010 REVISED STANDARD PLAN RSP A77N6

Dist	COUNTY	ROUTE	POST MILES TOTAL PROJECT	SHEET No.	TOTAL SHEETS
05	SB	101	2.2/3.3	424	786



Randell D. Hiatt
REGISTERED CIVIL ENGINEER

July 19, 2013
PLANS APPROVAL DATE

THE STATE OF CALIFORNIA OR ITS OFFICERS OR AGENTS SHALL NOT BE RESPONSIBLE FOR THE ACCURACY OR COMPLETENESS OF SCANNED COPIES OF THIS PLAN SHEET.


TO ACCOMPANY PLANS DATED 12-7-15

2010 REVISED STANDARD PLAN RSP A77N7

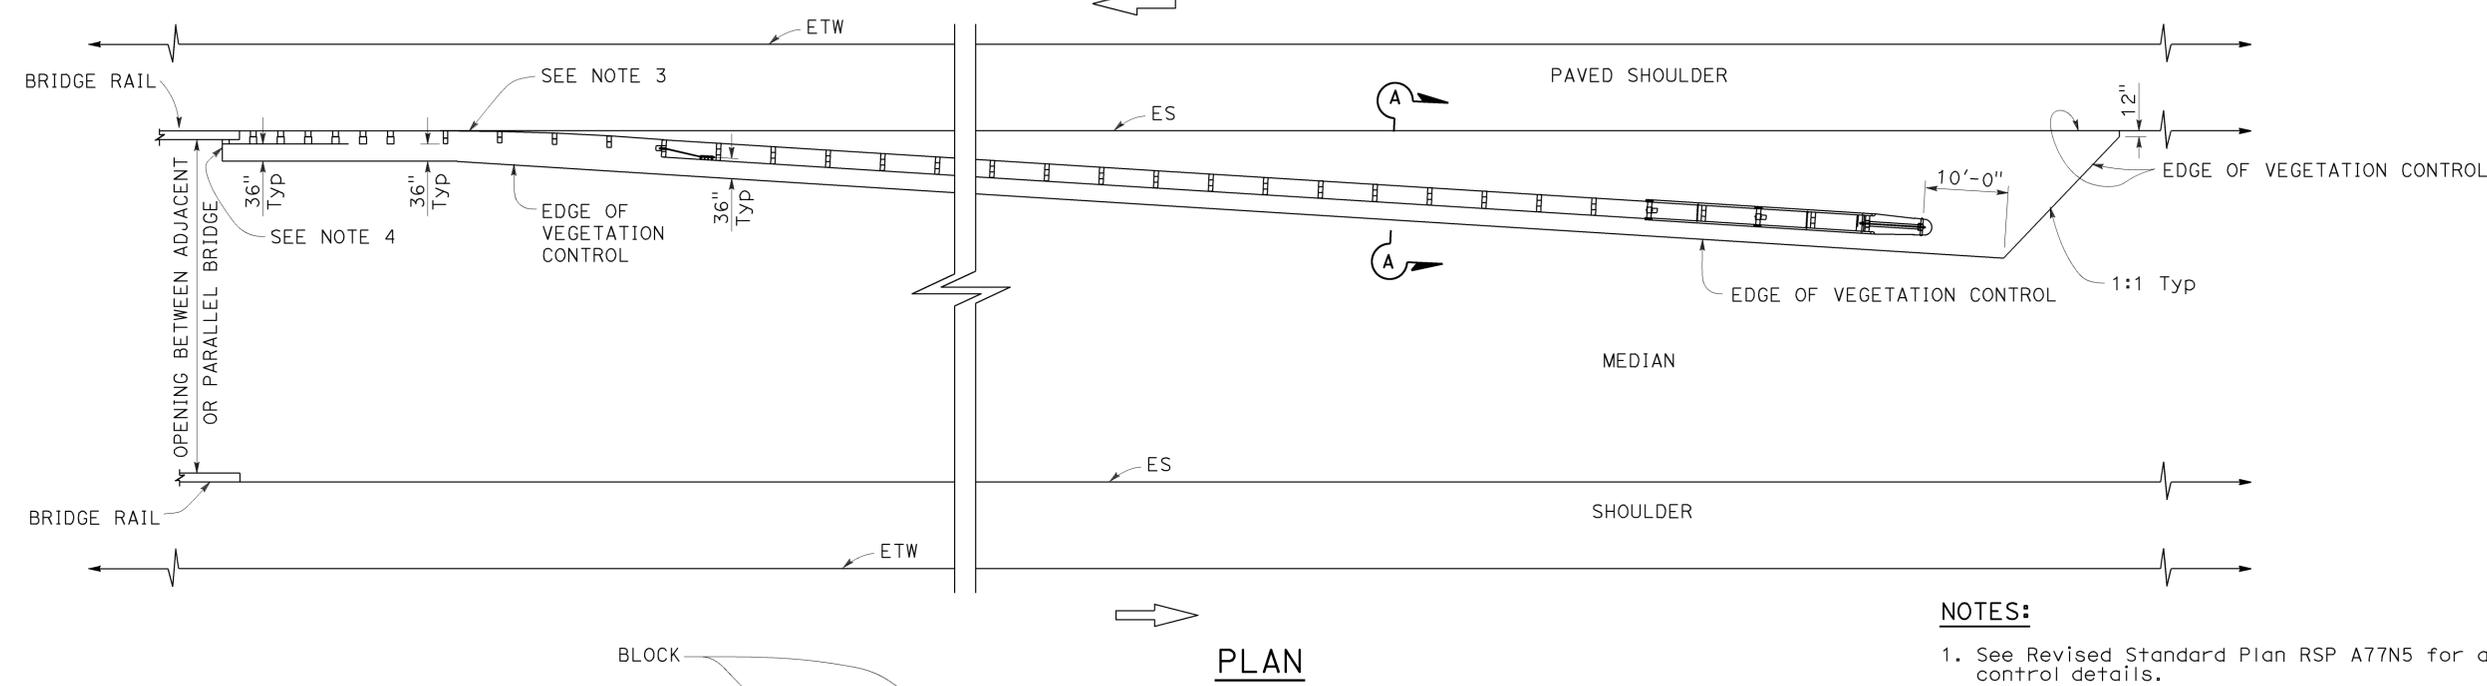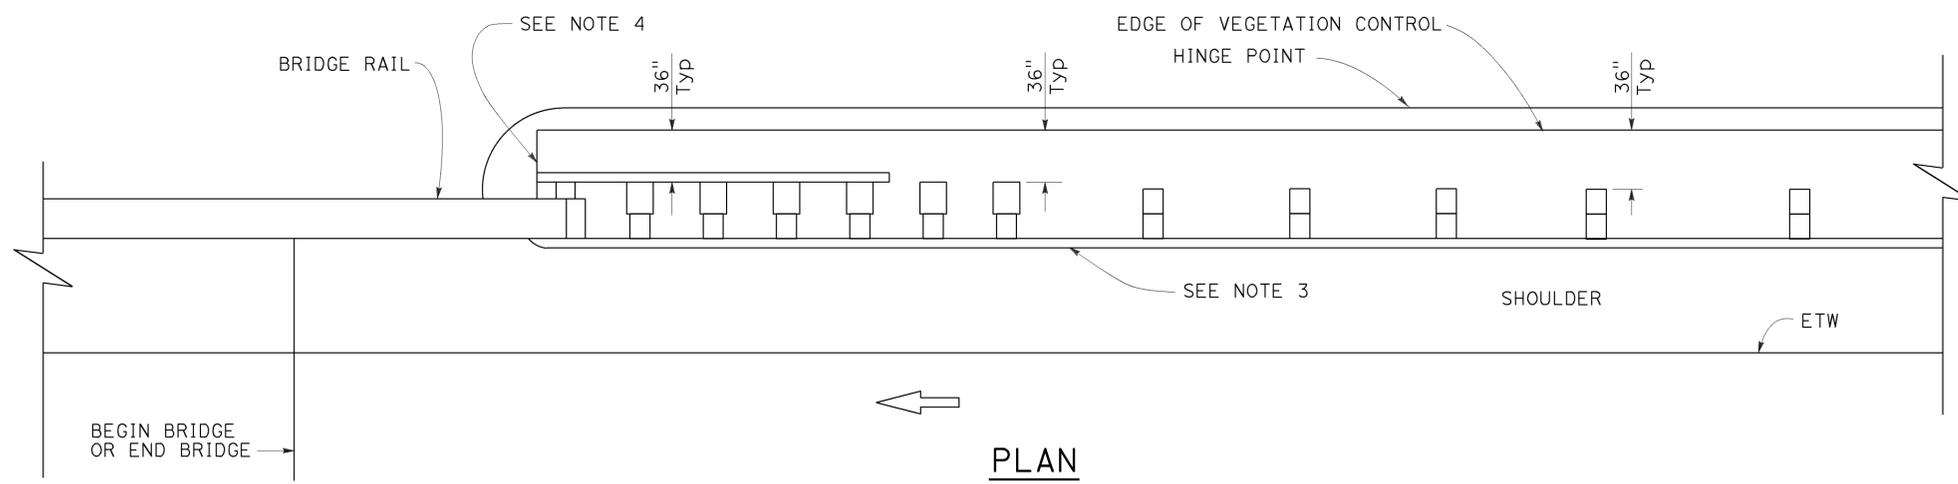

NOTES:

1. See Revised Standard Plan RSP A77N5 for additional vegetation control details.
2. Where the distance between back of post and hinge point is less than 42", construct vegetation control to 6" from hinge point while maintaining the 8" block-out at back of post. If the 8" block-out at back of post can not be maintained, construct vegetation control flush with the back edge of post.
3. Where dike is constructed under railing, construct vegetation control to back edge of dike. Where paved shoulder is constructed within 36" in front of the post, construct vegetation control to the edge of paved shoulder.
4. End vegetation control at end of backside rail element.

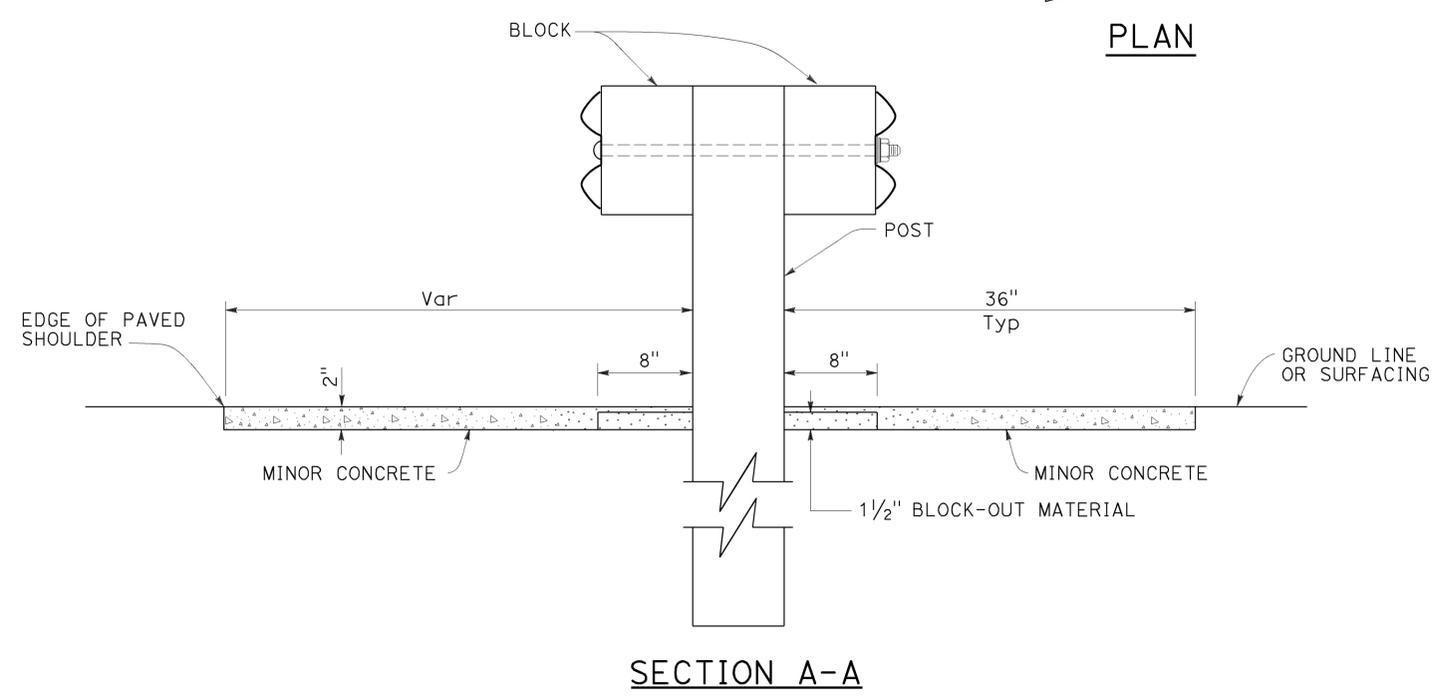

STATE OF CALIFORNIA
DEPARTMENT OF TRANSPORTATION

**MIDWEST GUARDRAIL SYSTEM
TYPICAL VEGETATION CONTROL
AT STRUCTURE APPROACH**

NO SCALE

RSP A77N7 DATED JULY 19, 2013 SUPPLEMENTS THE STANDARD PLANS BOOK DATED 2010.


REVISED STANDARD PLAN RSP A77N7

Dist	COUNTY	ROUTE	POST MILES TOTAL PROJECT	SHEET No.	TOTAL SHEETS
05	SB	101	2.2/3.3	425	786

Randell D. Hiatt
REGISTERED CIVIL ENGINEER

July 19, 2013
PLANS APPROVAL DATE


THE STATE OF CALIFORNIA OR ITS OFFICERS OR AGENTS SHALL NOT BE RESPONSIBLE FOR THE ACCURACY OR COMPLETENESS OF SCANNED COPIES OF THIS PLAN SHEET.

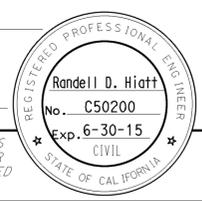

TO ACCOMPANY PLANS DATED 12-7-15

NOTES:

1. See Revised Standard Plan RSP A77N5 for additional vegetation control details.
2. Where the distance between back of post and hinge point is less than 42", construct vegetation control to 6" from hinge point while maintaining the 8" block-out at back of post. If the 8" block-out at back of post can not be maintained, construct vegetation control flush with the back edge of post.
3. Where dike is constructed under railing, construct vegetation control to back edge of dike. Where paved shoulder is constructed within 36" in front of the post, construct vegetation control to the edge of paved shoulder.

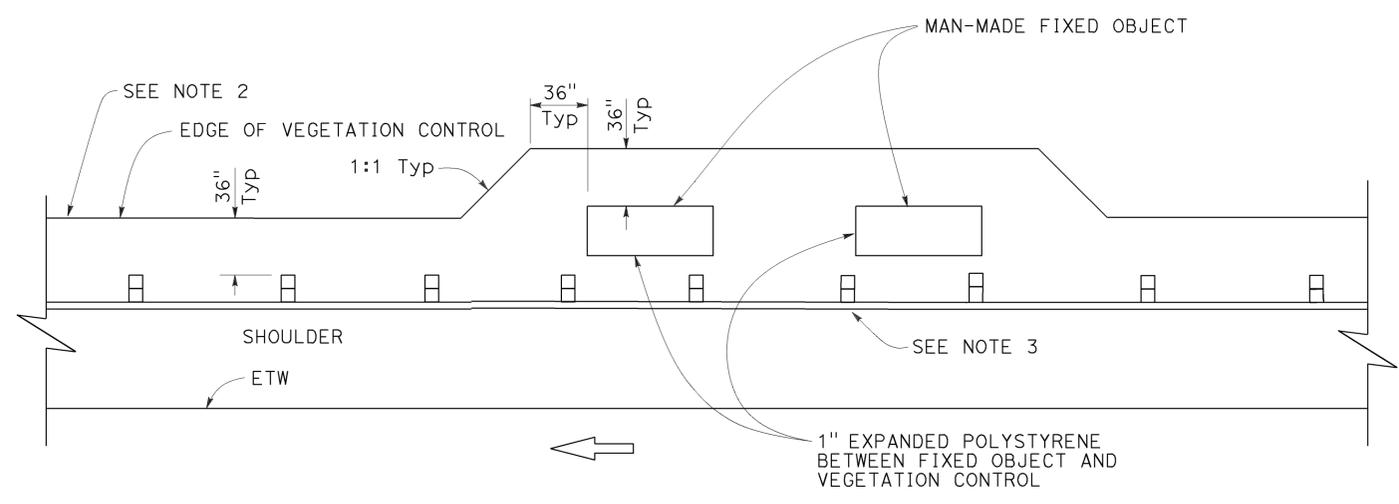

PLAN
Fixed object(s) on shoulder

STATE OF CALIFORNIA
DEPARTMENT OF TRANSPORTATION
**MIDWEST GUARDRAIL SYSTEM
TYPICAL VEGETATION CONTROL
AT FIXED OBJECT**

NO SCALE

RSP A77N8 DATED JULY 19, 2013 SUPPLEMENTS THE STANDARD PLANS BOOK DATED 2010.

REVISED STANDARD PLAN RSP A77N8

2010 REVISED STANDARD PLAN RSP A77N8

NOTES:

1. See Revised Standard Plan RSP A77N5 for additional vegetation control details.
2. Where dike is constructed under railing, construct vegetation control to back edge of dike. Where paved shoulder is constructed within 36" in front of the post, construct vegetation control to the edge of paved shoulder.



Dist	COUNTY	ROUTE	POST MILES TOTAL PROJECT	SHEET No.	TOTAL SHEETS
05	SB	101	2.2/3.3	426	786

Randell D. Hiatt
REGISTERED CIVIL ENGINEER

July 19, 2013
PLANS APPROVAL DATE


THE STATE OF CALIFORNIA OR ITS OFFICERS OR AGENTS SHALL NOT BE RESPONSIBLE FOR THE ACCURACY OR COMPLETENESS OF SCANNED COPIES OF THIS PLAN SHEET.

TO ACCOMPANY PLANS DATED 12-7-15

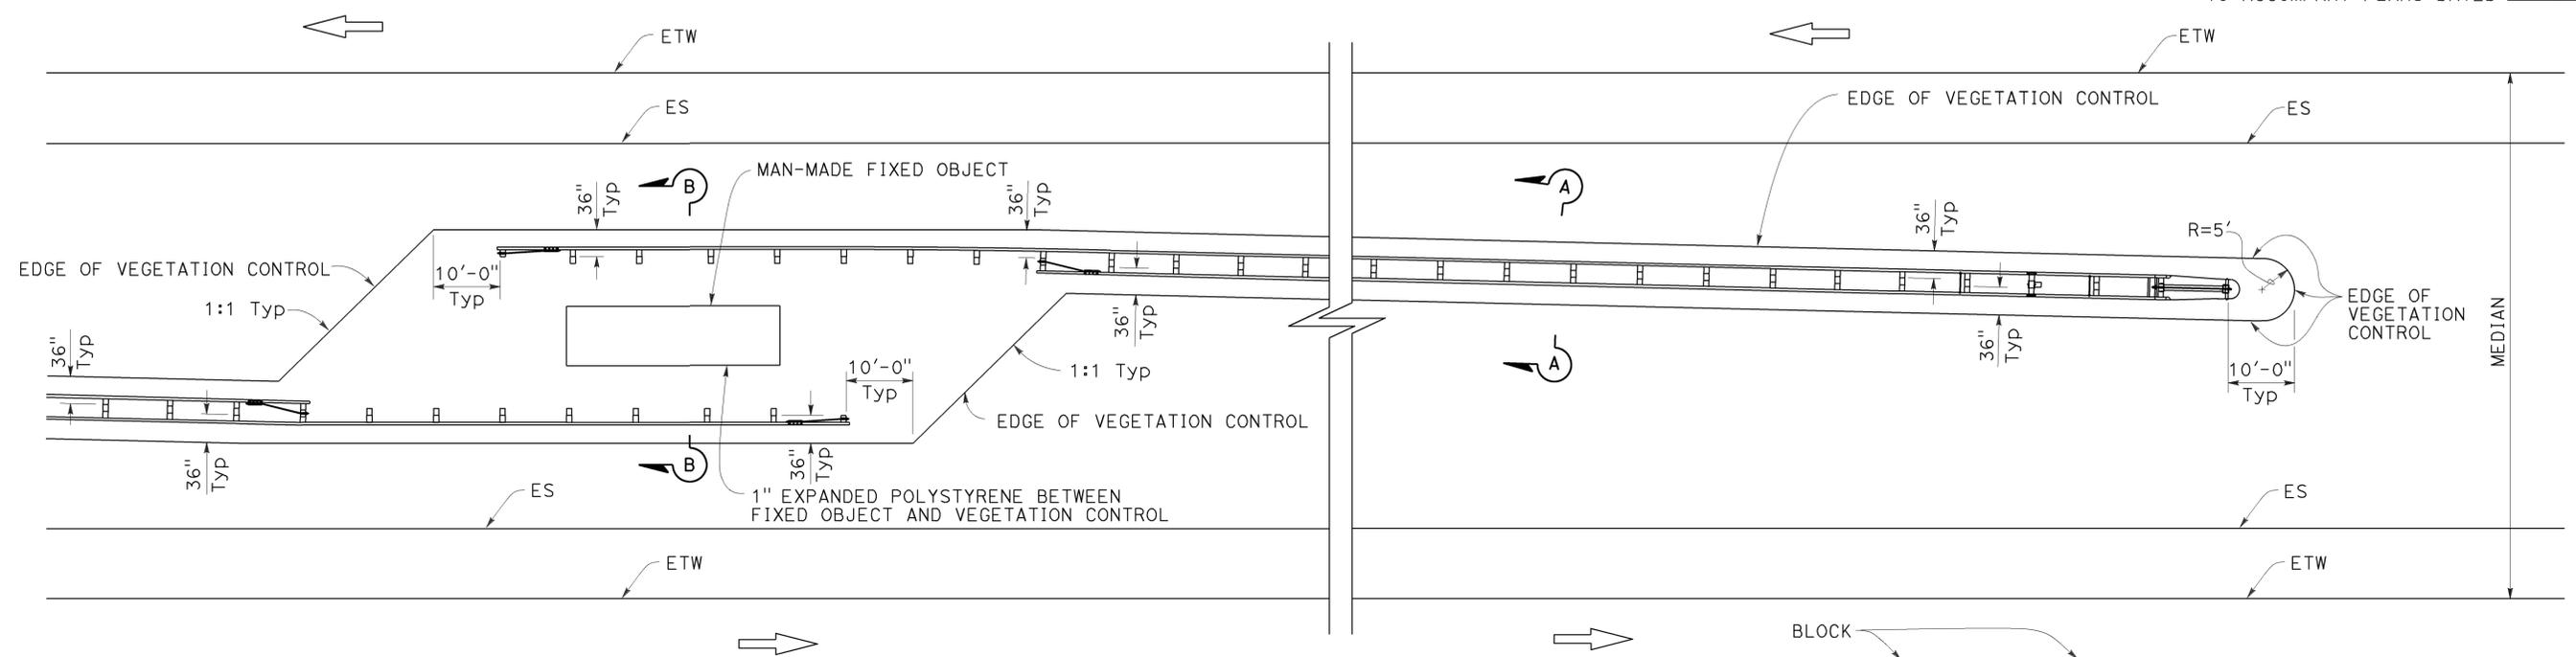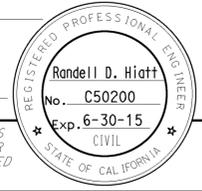


PLAN

Fixed object(s) in median

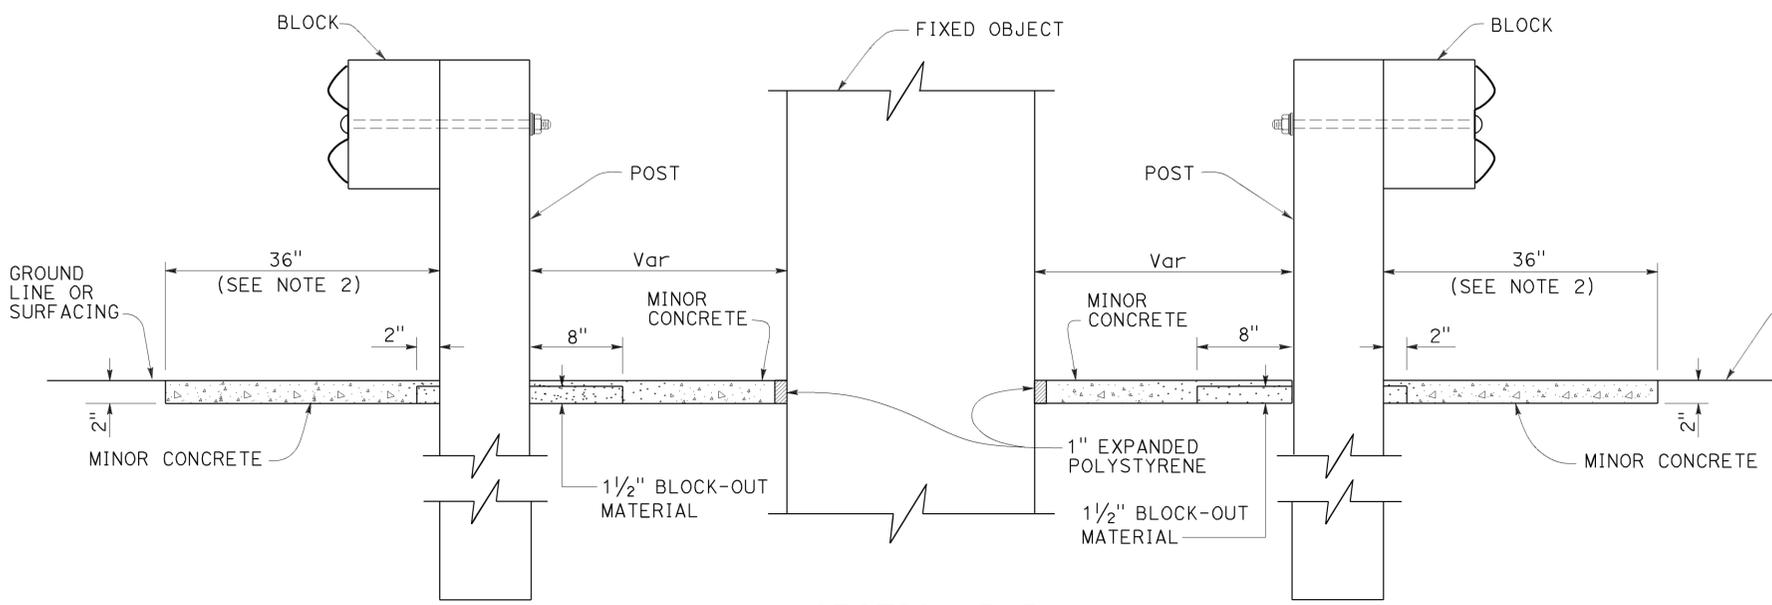

SECTION B-B

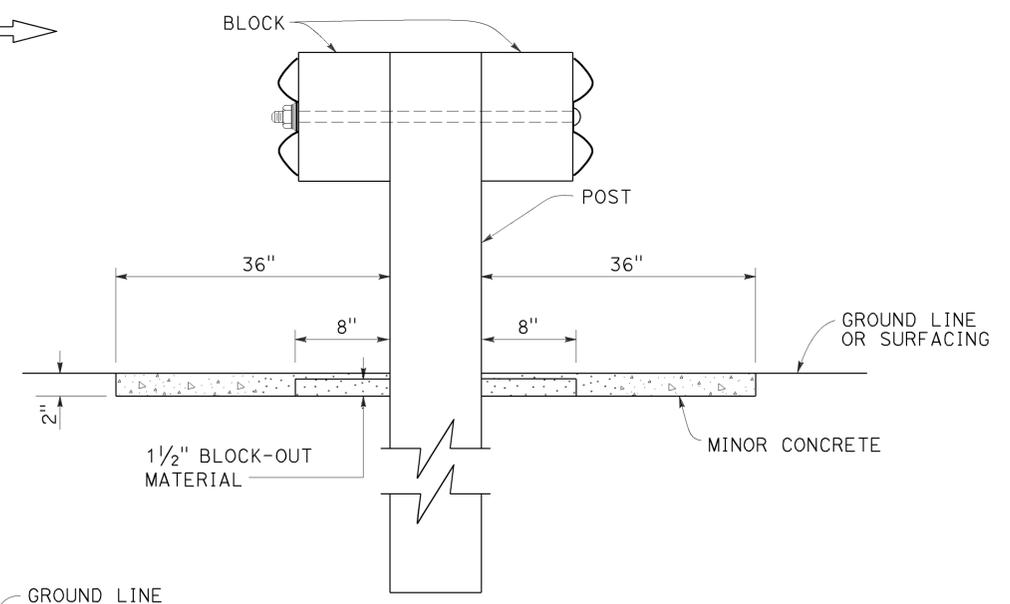

SECTION A-A

**MIDWEST GUARDRAIL SYSTEM
TYPICAL VEGETATION CONTROL
AT FIXED OBJECT**

NO SCALE

RSP A77N9 DATED JULY 19, 2013 SUPPLEMENTS THE STANDARD PLANS BOOK DATED 2010.

REVISED STANDARD PLAN RSP A77N9

2010 REVISED STANDARD PLAN RSP A77N9

Dist	COUNTY	ROUTE	POST MILES TOTAL PROJECT	SHEET No.	TOTAL SHEETS
05	SB	101	2.2/3.3	427	786

Randell D. Hiatt
REGISTERED CIVIL ENGINEER

July 19, 2013
PLANS APPROVAL DATE


THE STATE OF CALIFORNIA OR ITS OFFICERS OR AGENTS SHALL NOT BE RESPONSIBLE FOR THE ACCURACY OR COMPLETENESS OF SCANNED COPIES OF THIS PLAN SHEET.

REGISTERED PROFESSIONAL ENGINEER
No. C50200
Exp. 6-30-15
CIVIL
STATE OF CALIFORNIA

NOTES:


1. See Revised Standard Plan RSP A77N5 for additional vegetation control details.
2. Where dike is constructed under railing, construct vegetation control to back edge of dike. Where paved shoulder is constructed within 36" in front of the post, construct vegetation control to the edge of paved shoulder.

TO ACCOMPANY PLANS DATED 12-7-15

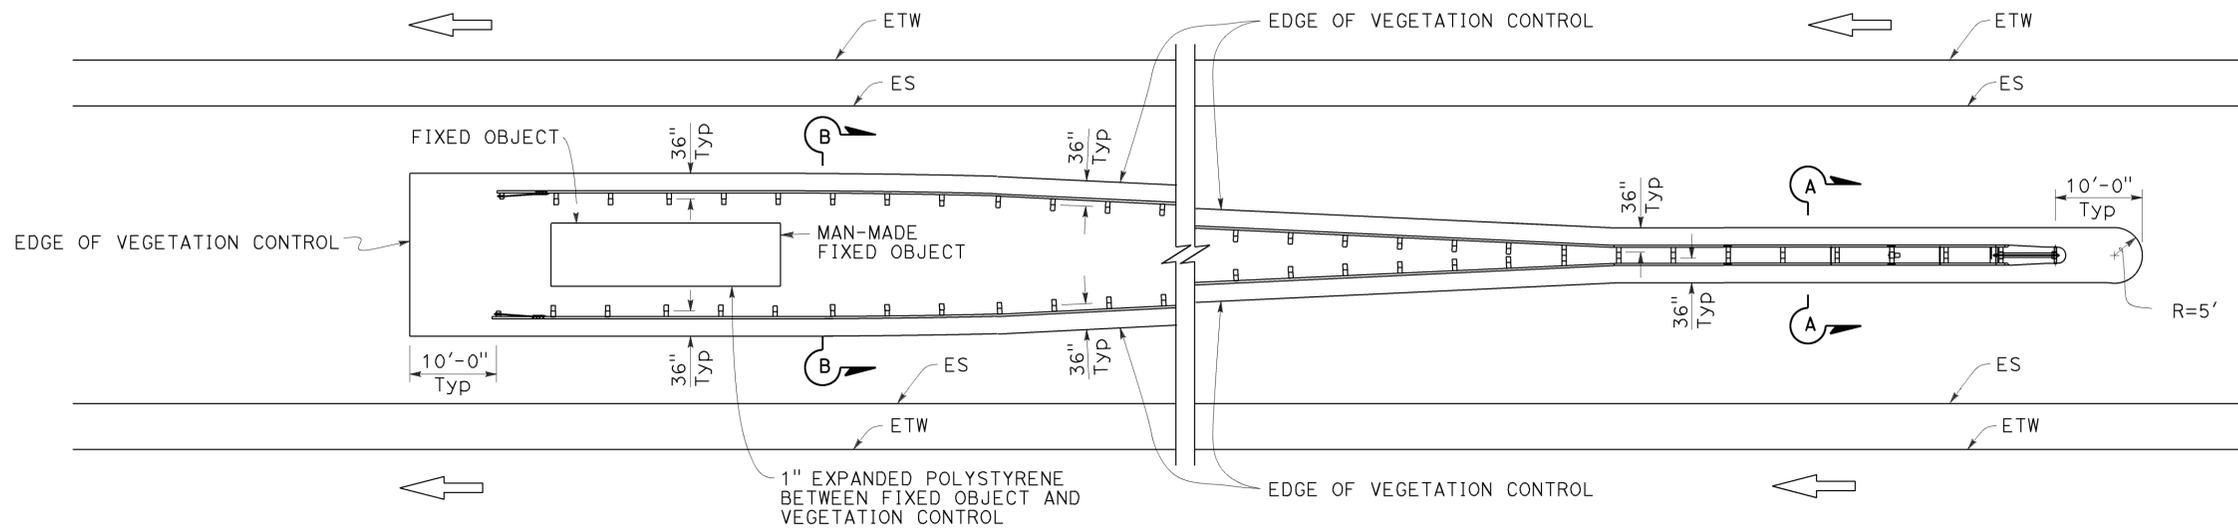


PLAN

Fixed object(s) between separate roadbeds
(One-Way Traffic)

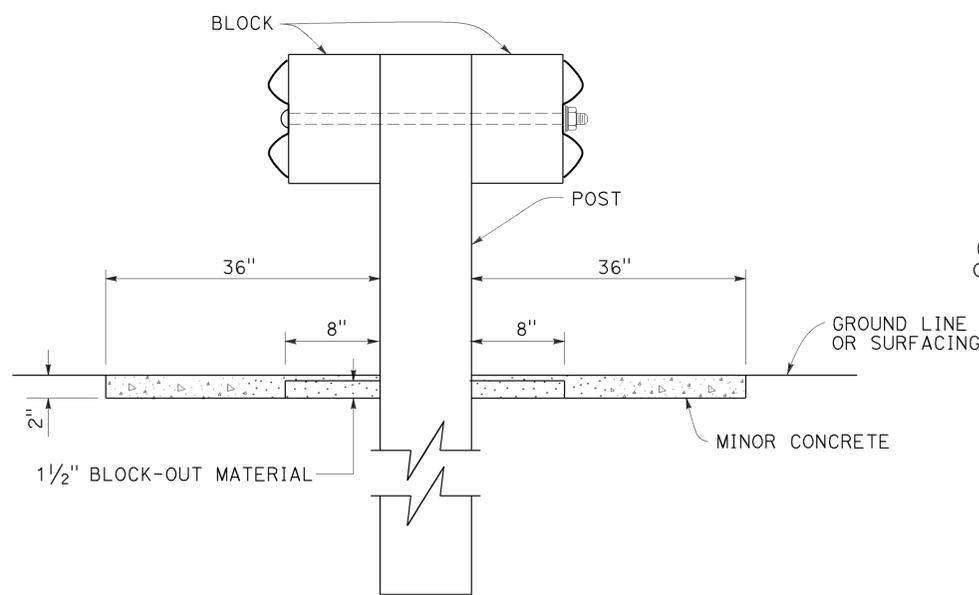

SECTION A-A

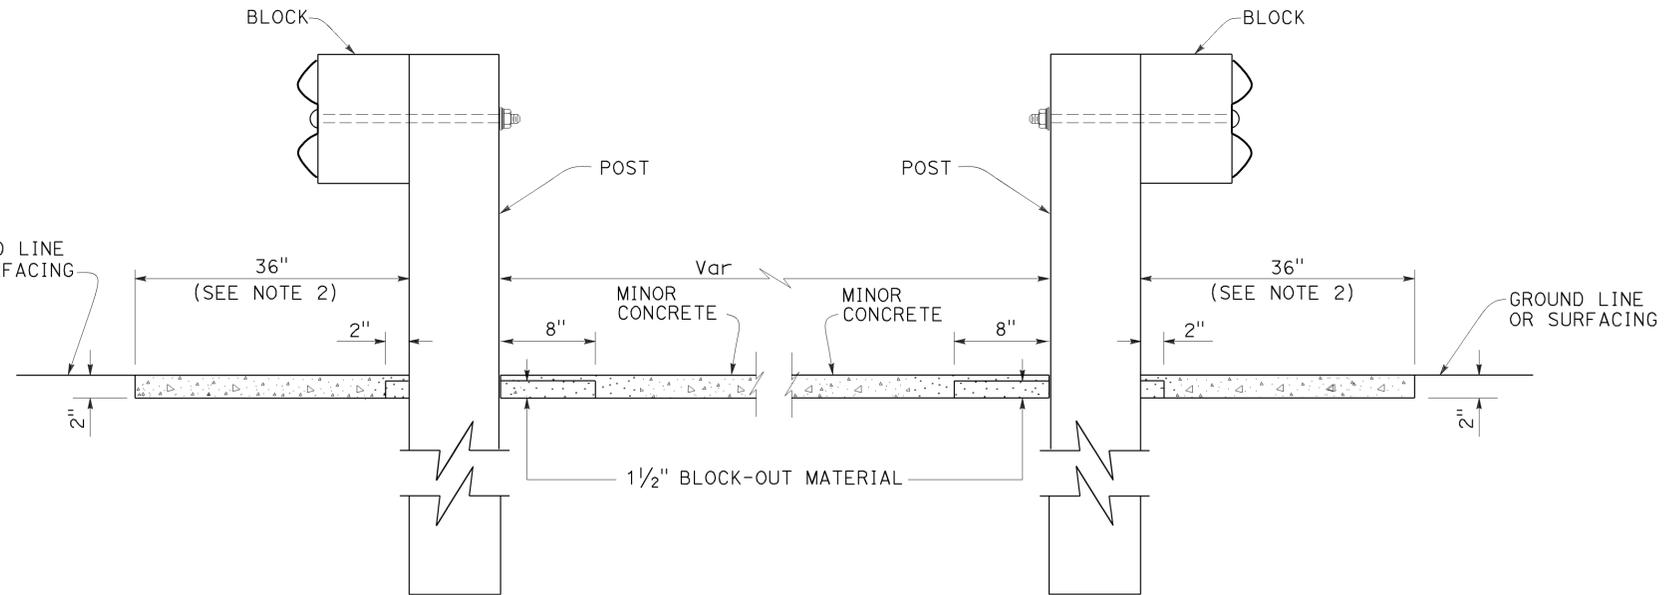

SECTION B-B

STATE OF CALIFORNIA
DEPARTMENT OF TRANSPORTATION

**MIDWEST GUARDRAIL SYSTEM
TYPICAL VEGETATION CONTROL
AT FIXED OBJECT**

NO SCALE

RSP A77N10 DATED JULY 19, 2013 SUPPLEMENTS THE STANDARD PLANS BOOK DATED 2010.

REVISED STANDARD PLAN RSP A77N10

2010 REVISED STANDARD PLAN RSP A77N10

Dist	COUNTY	ROUTE	POST MILES TOTAL PROJECT	SHEET No.	TOTAL SHEETS
05	SB	101	2.2/3.3	428	786


Randell D. Hiatt
REGISTERED CIVIL ENGINEER

November 15, 2013
PLANS APPROVAL DATE

THE STATE OF CALIFORNIA OR ITS OFFICERS OR AGENTS SHALL NOT BE RESPONSIBLE FOR THE ACCURACY OR COMPLETENESS OF SCANNED COPIES OF THIS PLAN SHEET.


TO ACCOMPANY PLANS DATED 12-7-15

Randell D. Hiatt
REGISTERED PROFESSIONAL ENGINEER
No. C50200
Exp. 6-30-15
CIVIL
STATE OF CALIFORNIA

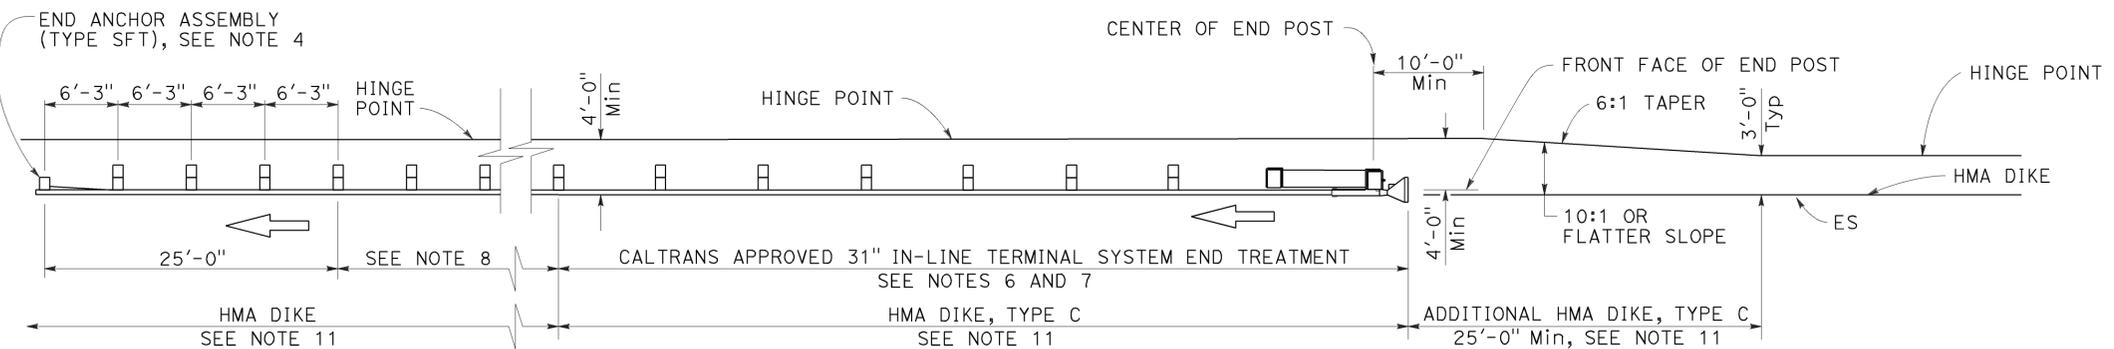


TYPE 11A LAYOUT

(Embankment MGS installation with 31" in-line end treatment at traffic approach end of railing) see Note 5

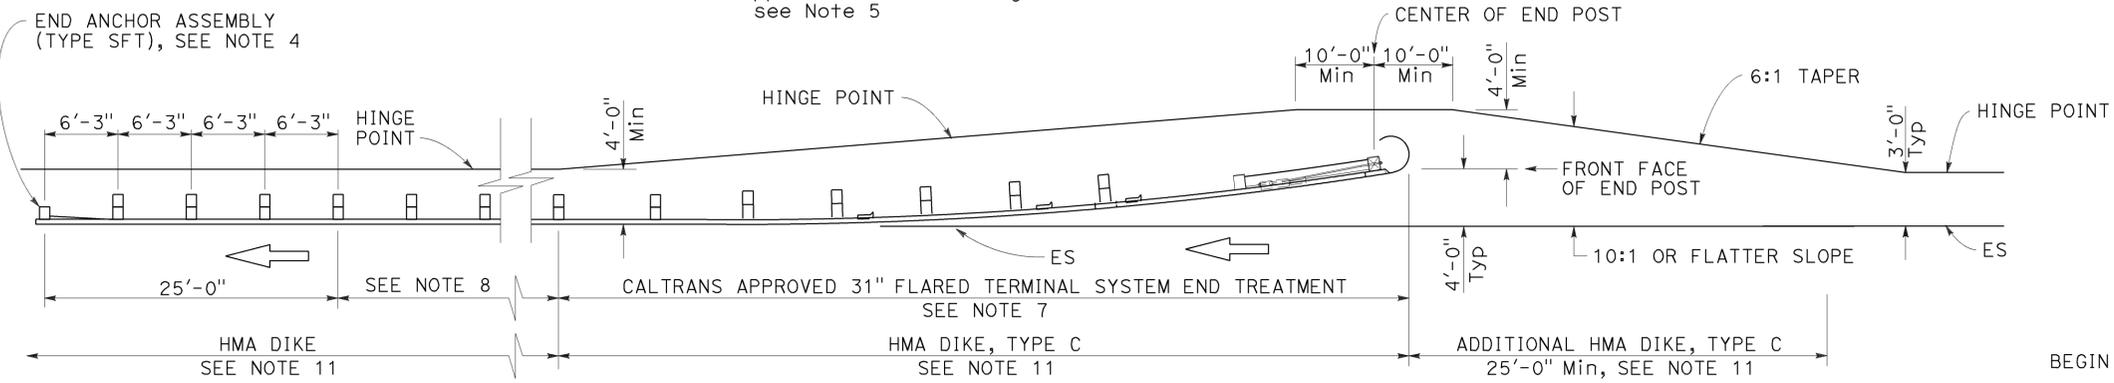


TYPE 11B LAYOUT

(Embankment MGS installation with 31" flared end treatment at traffic approach end of railing) see Note 5

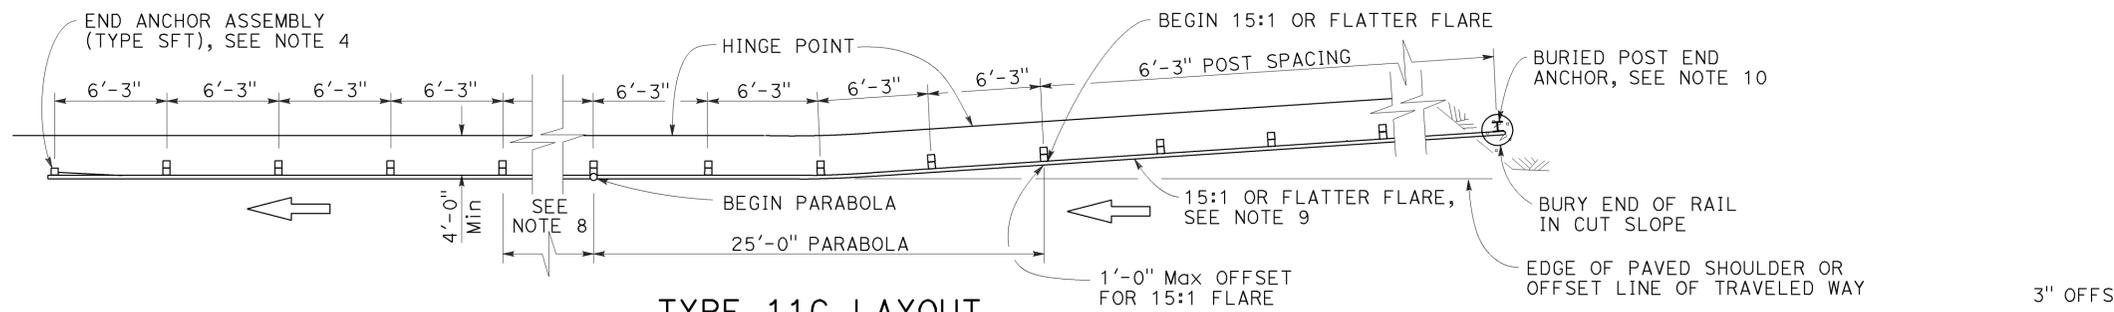


TYPE 11C LAYOUT

(Embankment MGS installation with buried end anchor treatment at traffic approach end of railing) see Notes 5 and 11

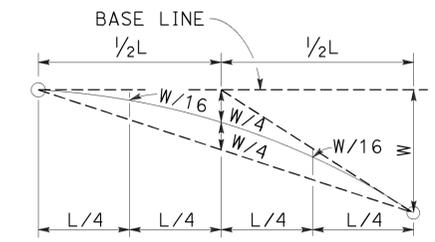

TYPICAL PARABOLIC LAYOUT

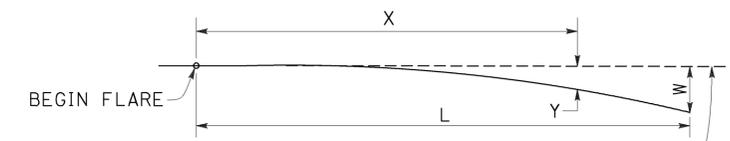


BASE LINE (EDGE OF PAVED SHOULDER OR OFFSET LINE OF EDGE OF TRAVELED WAY)

$$Y = \frac{WX^2}{L^2}$$

Y = OFFSET FROM BASE LINE
W = MAXIMUM OFFSET
X = DISTANCE ALONG BASE LINE
L = LENGTH OF FLARE

PARABOLIC FLARE OFFSETS

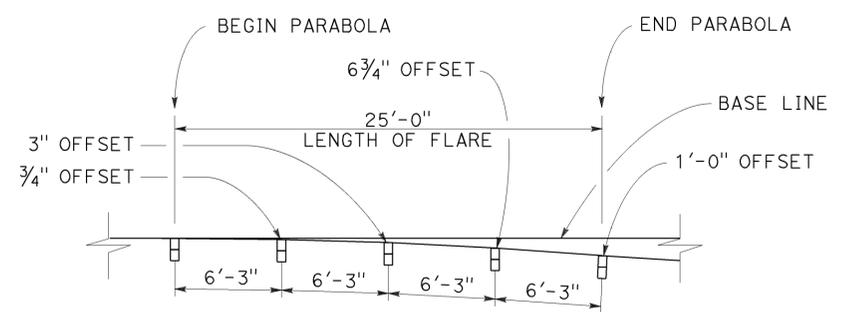

TYPICAL FLARE OFFSETS FOR 1 FOOT Max END OFFSET

STATE OF CALIFORNIA
DEPARTMENT OF TRANSPORTATION

MIDWEST GUARDRAIL SYSTEM TYPICAL LAYOUTS FOR EMBANKMENTS

NO SCALE

RSP A77P1 DATED NOVEMBER 15, 2013 SUPERSEDES RSP A77P1 DATED JULY 19, 2013 THAT SUPPLEMENTS THE STANDARD PLANS BOOK DATED 2010.

REVISED STANDARD PLAN RSP A77P1

NOTES:

- Line post, blocks and hardware to be used are shown on Revised Standard Plans RSP A77L1, RSP A77L2, RSP A77M1, RSP A77N1 and RSP A77N2.
- MGS post spacing to be 6'-3" center to center, except as otherwise noted.
- Except as noted, line posts are 6" x 8" x 6'-0" wood with 6" x 12" x 1'-2" wood blocks. W6 x 8.5 or W6 x 9 steel posts, 6'-0" in length, with 6" x 12" x 1'-2" notched wood blocks or recycled plastic blocks may be used for 6" x 8" x 6'-0" wood post with 6" x 12" x 1'-2" wood blocks where applicable and when specified.
- For End Anchor Assembly (Type SFT) details, see Revised Standard Plan RSP A77S1.
- Layout Types 11A, 11B or 11C are typically used where MGS is recommended to shield embankment slopes and a crashworthy end treatment is required for only one direction of traffic.
- 31" in-line terminal system end treatments are used where site conditions will not accommodate a flared end treatment.
- The type of 31" terminal system end treatment to be used will be shown on the Project Plans.
- Dependent on site conditions (embankment height and side slope), construction of additional MGS (length equal to multiples of 12'-6" with 6'-3" post spacing) may be advisable.
- The 15:1 or flatter flare used with buried end anchors is based on the edge of the paved shoulder or offset line of edge of the traveled way. The length of MGS within the 15:1 or flatter flare is based on site conditions and should be a length equal to multiples of 12'-6".
- For details of the buried post end anchor used with Type 11C Layout, see Revised Standard Plan RSP A77T2.
- Where placement of dike is required with MGS installations, see Revised Standard Plan RSP A77N4 for dike positioning details.

2010 REVISED STANDARD PLAN RSP A77P1


Dist	COUNTY	ROUTE	POST MILES TOTAL PROJECT	SHEET No.	TOTAL SHEETS
05	SB	101	2.2/3.3	429	786

Randell D. Hiatt
REGISTERED CIVIL ENGINEER


August 14, 2015
PLANS APPROVAL DATE

THE STATE OF CALIFORNIA OR ITS OFFICERS OR AGENTS SHALL NOT BE RESPONSIBLE FOR THE ACCURACY OR COMPLETENESS OF SCANNED COPIES OF THIS PLAN SHEET.

TO ACCOMPANY PLANS DATED 12-7-15

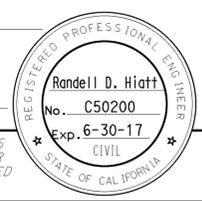


2010 REVISED STANDARD PLAN RSP A77Q1

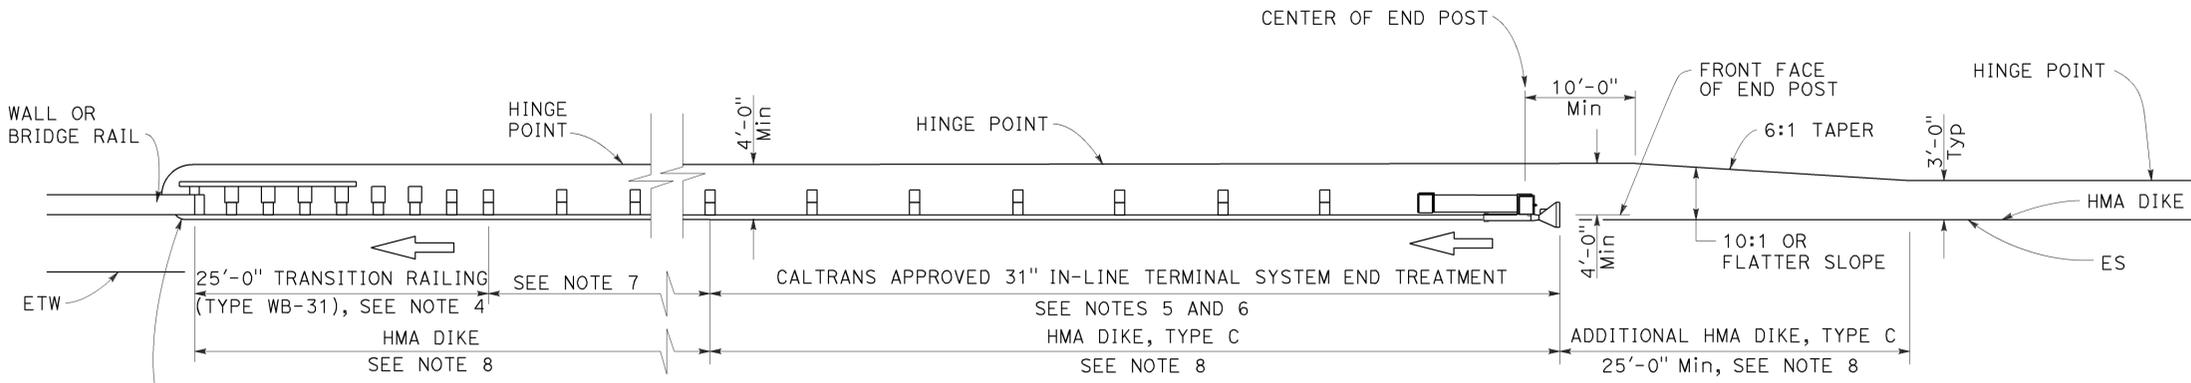

TYPE 12A LAYOUT

(MGS installation at structure approach with 31" in-line end treatment at traffic approach end of railing)
See Note 9

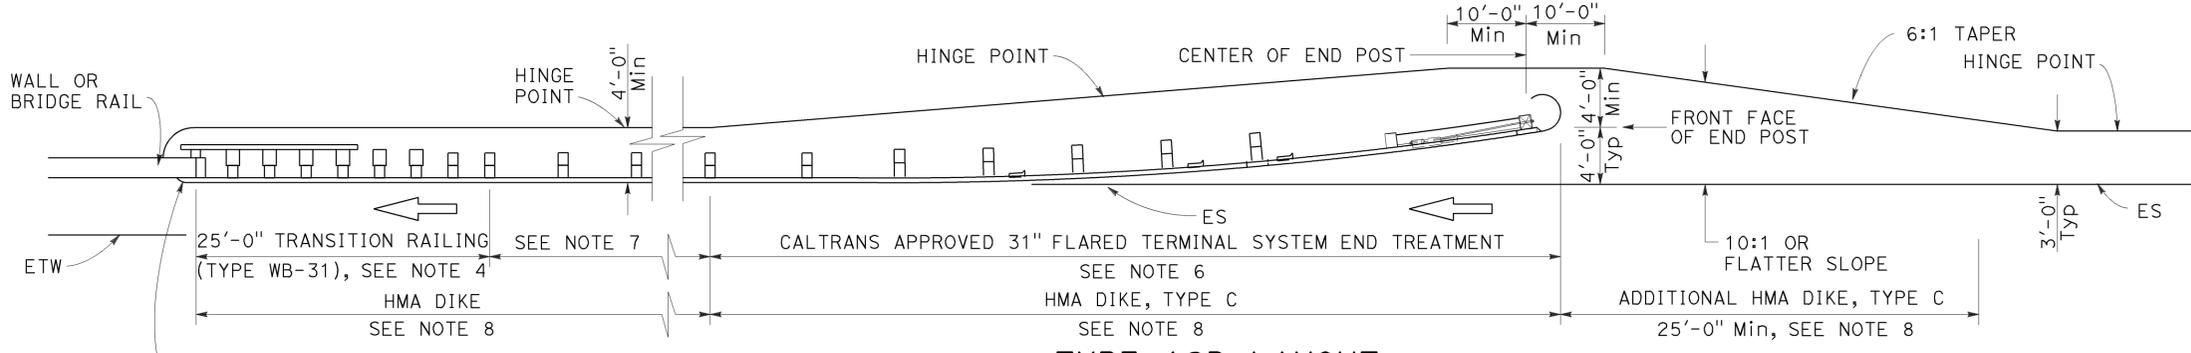

TYPE 12B LAYOUT

(MGS installation at structure approach with 31" Flared end treatment at traffic approach end of railing)
See Note 9

NOTES:

- Line post, blocks and hardware to be used are shown on Revised Standard Plans RSP A77L1, RSP A77L2, RSP A77M1, RSP A77N1 and RSP A77N2.
- MGS post spacing to be 6'-3" center to center, except as otherwise noted.
- Except as noted, line posts are 6" x 8" x 6'-0" wood with 6" x 12" x 1'-2" wood blocks. W6 x 8.5 or W6 x 9 steel posts, 6'-0" in length, with 6" x 12" x 1'-2" notched wood blocks or plastic blocks may be used for 6" x 8" x 6'-0" wood posts with 6" x 12" x 1'-2" wood blocks where applicable and when specified.
- For Transition Railing (Type WB-31) details for Types 12A and 12B Layouts, see Revised Standard Plan RSP A77U4.
- 31" in-line terminal system end treatments are used where site conditions will not accommodate a 31" flared end treatment.
- The type of 31" terminal system end treatment to be used will be shown on the Project Plans.
- Dependent on site conditions (embankment height, side slopes, or other fixed objects), it may be advisable to construct additional guard railing (a length equal to multiples of 12'-6" with 6'-3" post spacing) between the transition railing and end treatment. A 12.5 degree angle of departure can be drawn on the Project Plans from the edge of traveled way through the outer most point of the fixed object to determine the additional length of railing needed.
- Where placement of dike is required with guard railing installations, see Revised Standard Plan RSP A77N4 for dike positioning details.
- Type 12A or Type 12B Layouts are typically used:
 - To the right of approaching traffic, at the end of a structure, on two-lane conventional highway where the roadbed width across the structure is less than 40 feet.
 - To the left of approaching traffic, at the end of a structure, on two-lane conventional highway where the roadbed width across the structure is less than 40 feet.
 - To the right of approaching traffic at the end of each structure on multilane freeways or expressways with separate adjacent or parallel bridges.
 - To the right of approaching traffic at the end of the structure on multilane freeways or expressways with decked median on the bridge.
- See Revised Standard Plan RSP A77Q3 for typical layout used left of approaching traffic at the ends of each structure on multilane freeways or expressways with separate adjacent or parallel bridges.
- For additional details of typical connections to bridge rail, see Connection Detail AA on Revised Standard Plans RSP A77U1 and RSP A77U2 and Connection Detail FF on Revised Standard Plans RSP A77V1 and RSP A77V2.
- For additional details of a typical connection to walls or abutments, see Revised Standard Plan RSP A77U3.

STATE OF CALIFORNIA
DEPARTMENT OF TRANSPORTATION

**MIDWEST GUARDRAIL SYSTEM
TYPICAL LAYOUTS FOR
STRUCTURE APPROACH**

NO SCALE

RSP A77Q1 DATED AUGUST 14, 2015 SUPERSEDES RSP A77Q1 DATED JULY 19, 2013 THAT SUPPLEMENTS THE STANDARD PLANS BOOK DATED 2010.

REVISED STANDARD PLAN RSP A77Q1

Dist	COUNTY	ROUTE	POST MILES TOTAL PROJECT	SHEET No.	TOTAL SHEETS
05	SB	101	2.2/3.3	430	786


Randell D. Hiatt
REGISTERED CIVIL ENGINEER

August 14, 2015
PLANS APPROVAL DATE

THE STATE OF CALIFORNIA OR ITS OFFICERS OR AGENTS SHALL NOT BE RESPONSIBLE FOR THE ACCURACY OR COMPLETENESS OF SCANNED COPIES OF THIS PLAN SHEET.


REGISTERED PROFESSIONAL ENGINEER
No. C50200
Exp. 6-30-17
CIVIL
STATE OF CALIFORNIA

TO ACCOMPANY PLANS DATED 12-7-15

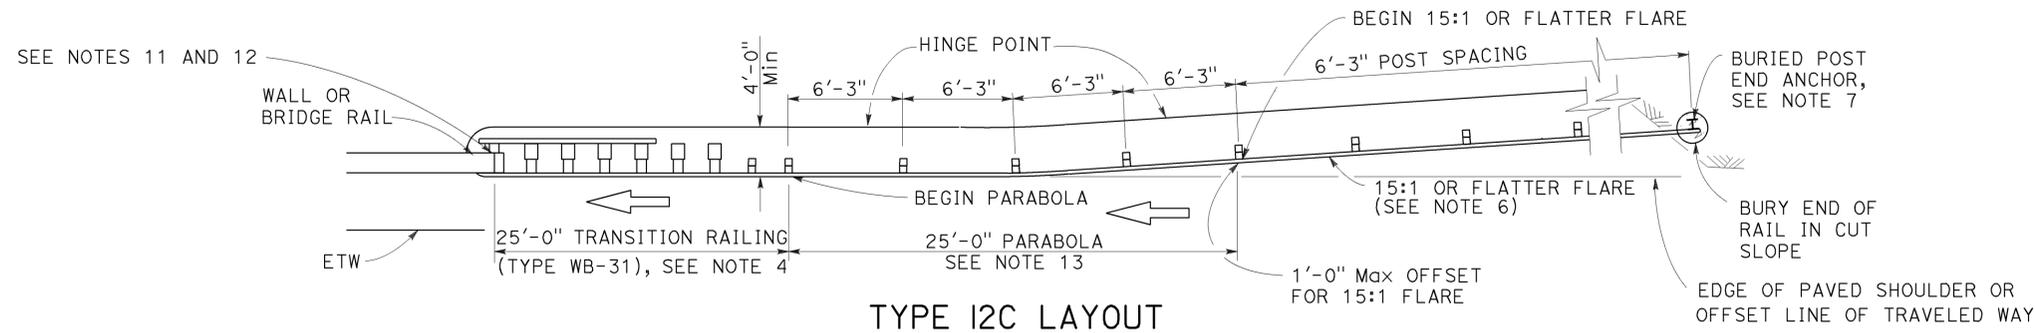


TYPE 12C LAYOUT

(MGS installation at structure approach with a Buried end anchor treatment at traffic approach end of railing)
See Notes 8 and 9

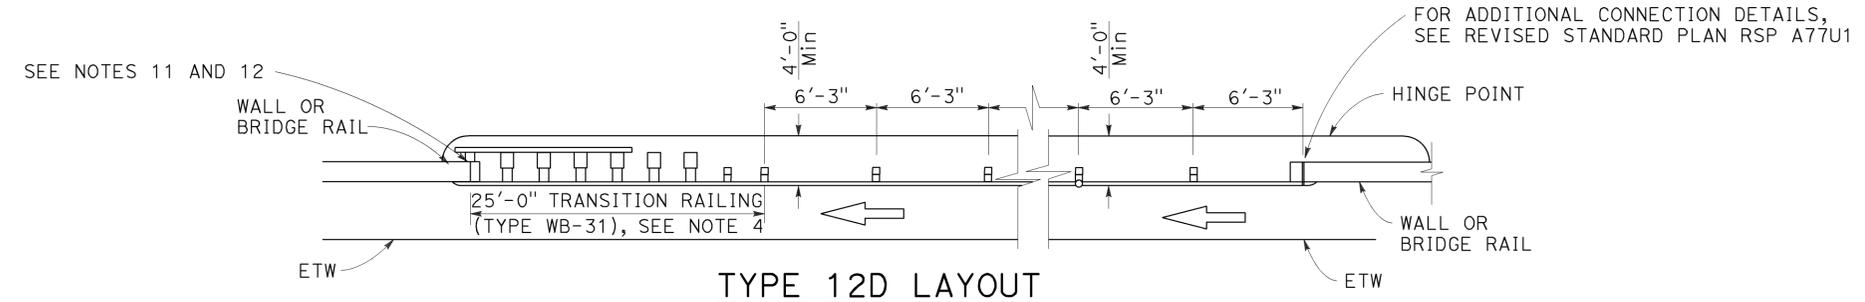

TYPE 12D LAYOUT

(Continuous MGS installation between structures)
See Notes 5 and 9

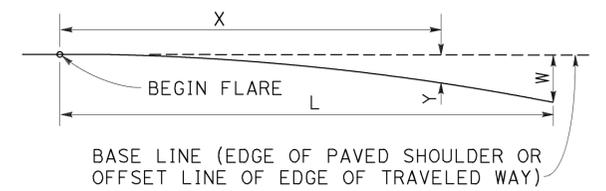


BASE LINE (EDGE OF PAVED SHOULDER OR OFFSET LINE OF EDGE OF TRAVELED WAY)

$$Y = \frac{WX^2}{L^2}$$

Y = OFFSET FROM BASE LINE
W = MAXIMUM OFFSET
X = DISTANCE ALONG BASE LINE
L = LENGTH OF FLARE

PARABOLIC FLARE OFFSETS

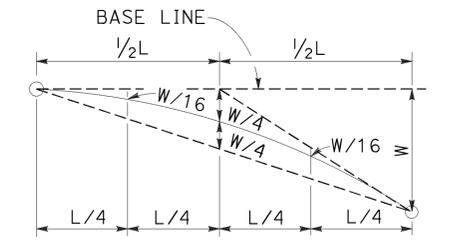

TYPICAL PARABOLIC LAYOUT

NOTES:

- Line post, blocks and hardware to be used are shown on Revised Standard Plans RSP A77L1, RSP A77L2, RSP A77M1, RSP A77N1 and RSP A77N2.
- MGS post spacing to be 6'-3" center to center, except as otherwise noted.
- Except as noted, line posts are 6" x 8" x 6'-0" m wood with 6" x 12" x 1'-2" wood blocks. W6 x 8.5 or W6 x 9 steel posts, 6'-0" in length, with 6" x 12" x 1'-2" notched wood blocks or plastic blocks may be used for 6" x 8" x 6'-0" wood posts with 6" x 12" x 1'-2" wood blocks where applicable and when specified.
- For Transition Railing (Type WB-31) details for Types 12C and 12D Layouts, see Revised Standard Plan RSP A77U4.
- Type 12D layout is typically used where continuous MGS is recommended between structures.
- The 15:1 or flatter flare for Type 12C Layout is based on the edge of the paved shoulder or offset line of edge of the traveled way. The length of MGS with the 15:1 or flatter flare is based on site conditions and should be a length equal to multiples of 12'-6".
- For details of the buried post end anchor used with Type 12C Layout, see Revised Standard Plan RSP A77T2.
- Where placement of dike is required with MGS installations, see Revised Standard Plan RSP A77N4 for dike positioning details.
- Type 12C Layout is typically used:
 - To the right of approaching traffic, at the end of the structure, on two-lane conventional highway where the roadbed width across the structure is less than 40 feet.
 - To the left of approaching traffic, at each of a structure, on two-lane conventional highway where the roadbed width across the structure is less than 40 feet.
 - To the right of approaching traffic at the end of each structure on multilane freeways or expressways with separate adjacent or parallel bridges.
 - To the right of approaching traffic at the end of the structure on multilane freeways or expressways with decked median on the bridge.
- See Revised Standard Plan RSP A77Q3 for typical layout used left of approaching traffic at the ends of each structure on multilane freeways or expressways with separate adjacent or parallel bridges.
- For additional details of typical connections to bridge rail, see Connection Detail AA on Revised Standard Plans RSP A77U1 and RSP A77U2 and Connection Detail FF on Revised Standard Plans RSP A77V1 and RSP A77V2.
- For additional details of a typical connection to walls or abutments, see Revised Standard Plan RSP A77U3.
- For typical flare offsets for 25'-0" length parabola with maximum offset of 1'-0", see Revised Standard Plan RSP A77P1.

STATE OF CALIFORNIA
DEPARTMENT OF TRANSPORTATION

**MIDWEST GUARDRAIL SYSTEM
TYPICAL LAYOUTS FOR
STRUCTURE APPROACH
AND BETWEEN STRUCTURES**

NO SCALE

RSP A77Q2 DATED AUGUST 14, 2015 SUPERSEDES RSP A77Q2 DATED JULY 19, 2013 THAT SUPPLEMENTS THE STANDARD PLANS BOOK DATED 2010.

REVISED STANDARD PLAN RSP A77Q2

2010 REVISED STANDARD PLAN RSP A77Q2



Dist	COUNTY	ROUTE	POST MILES TOTAL PROJECT	SHEET No.	TOTAL SHEETS
05	SB	101	2.2/3.3	431	786

Randell D. Hiatt
REGISTERED CIVIL ENGINEER

August 14, 2015
PLANS APPROVAL DATE



THE STATE OF CALIFORNIA OR ITS OFFICERS OR AGENTS SHALL NOT BE RESPONSIBLE FOR THE ACCURACY OR COMPLETENESS OF SCANNED COPIES OF THIS PLAN SHEET.

TO ACCOMPANY PLANS DATED 12-7-15

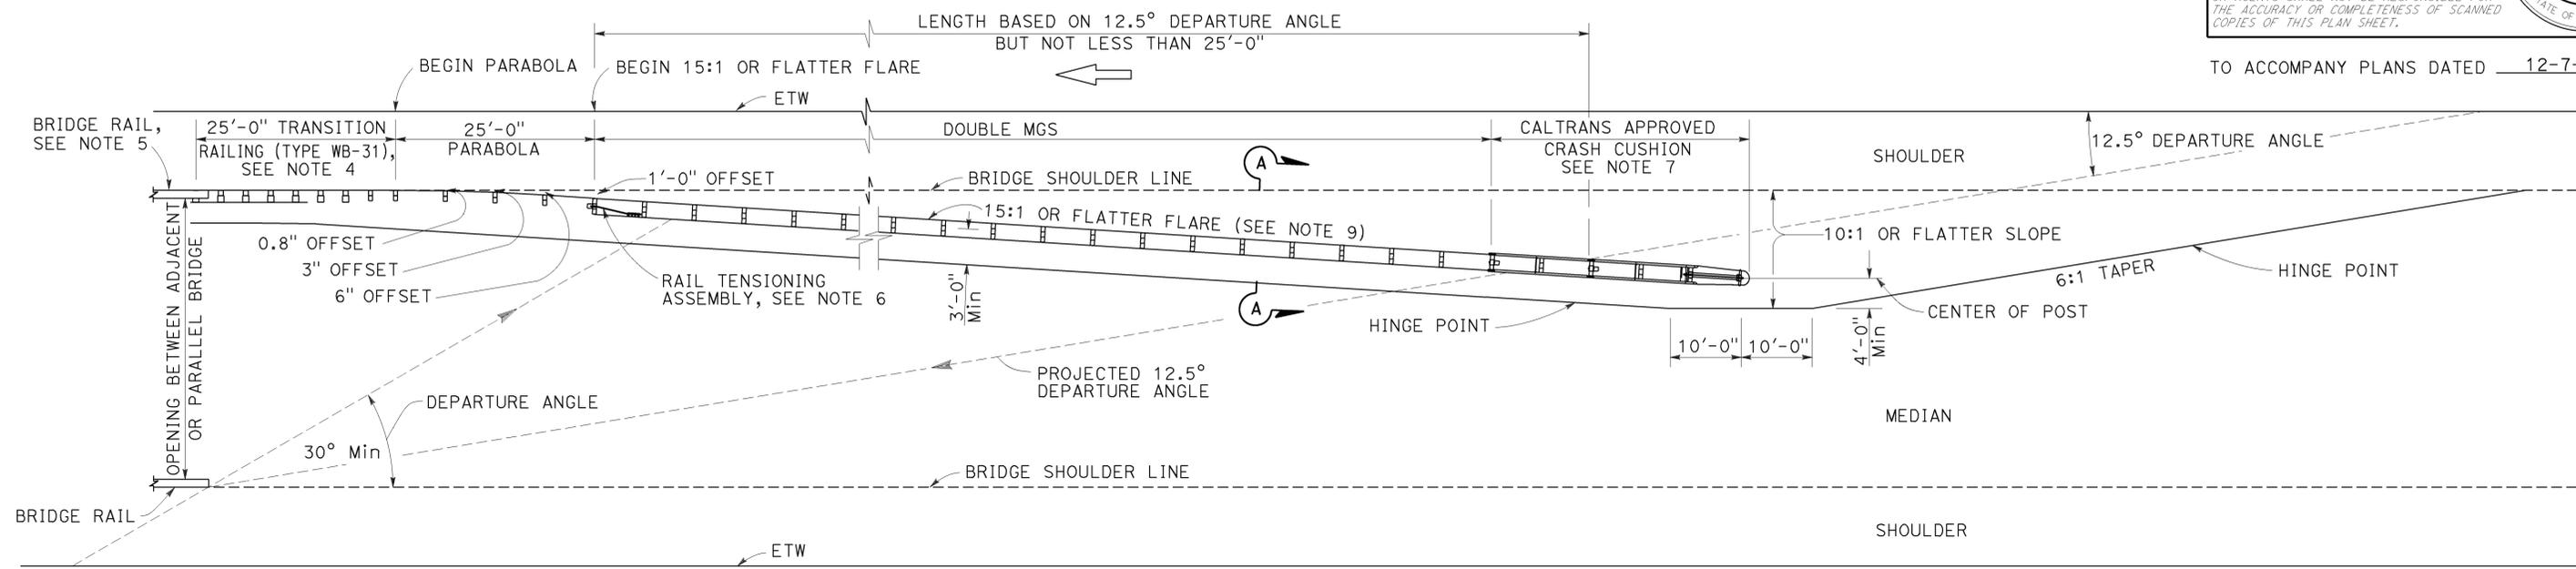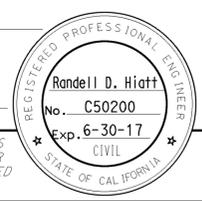

TYPE 12E LAYOUT
See Note 9


5/8" Ø BUTTON HEAD BOLT WITH Hex NUT OR 5/8" Ø ROD, THREADED BOTH ENDS, WITH Hex NUTS. 1/2" Max EXPOSED THREADS AFTER Hex NUT(S) TIGHTENED. NO WASHER ON RAIL FACES FOR BOLTED CONNECTION TO LINE POST

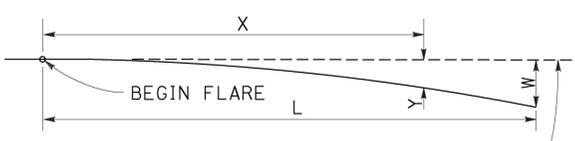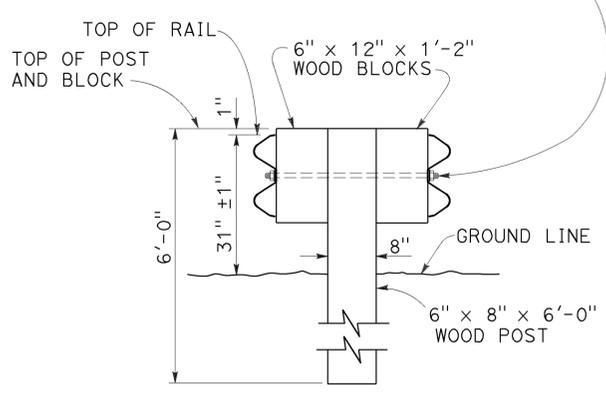

BASE LINE (EDGE OF PAVED SHOULDER OR OFFSET LINE OF EDGE OF TRAVELED WAY)

$$Y = \frac{WX^2}{L^2}$$

Y = OFFSET FROM BASE LINE
W = MAXIMUM OFFSET
X = DISTANCE ALONG BASE LINE
L = LENGTH OF FLARE

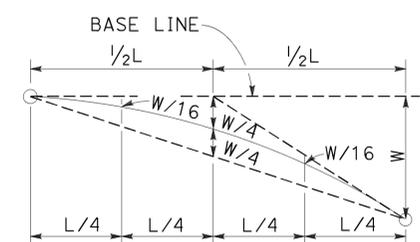

NOTES:

- Line post, blocks and hardware to be used are shown on Revised Standard Plans RSP A77L1, RSP A77L2, RSP A77M1, RSP A77N1 and RSP A77N2.
- MGS post spacing to be 6'-3" center to center, except as otherwise noted.
- Except as noted, line posts are 6" x 8" x 6'-0" wood with 6" x 12" x 1'-2" wood blocks. W6 x 8.5 or W6 x 9 steel posts, 6'-0" in length, with 6" x 12" x 1'-2" notched wood blocks or notched recycled plastic blocks may be used for 6" x 8" x 6'-0" wood line posts with 6" x 12" x 1'-2" wood blocks where applicable and when specified.
- For Transition Railing (Type WB-31) details, see Revised Standard Plan RSP A77U4.
- For additional details of a typical connection to bridge rail, see Connection Detail AA on Revised Standard Plan RSP A77U1.
- For Rail Tensioning Assembly details, see Revised Standard Plan RSP A77S2.
- The type of Crash Cushion to be used will be shown on the Project Plans.
- Type 12E Layout is typically used left of approaching traffic at the end of each structure on multilane freeways or expressways where a median type barrier is not constructed between separated roadbeds.
- The 15:1 or flatter flare is measured off of the edge of traveled way.

STATE OF CALIFORNIA
DEPARTMENT OF TRANSPORTATION
**MIDWEST GUARDRAIL SYSTEM
TYPICAL LAYOUTS FOR
STRUCTURE APPROACH**

NO SCALE

RSP A77Q3 DATED AUGUST 14, 2015 SUPERSEDES RSP A77Q3 DATED JULY 19, 2013 THAT SUPPLEMENTS THE STANDARD PLANS BOOK DATED 2010.

2010 REVISED STANDARD PLAN RSP A77Q3


Dist	COUNTY	ROUTE	POST MILES TOTAL PROJECT	SHEET No.	TOTAL SHEETS
05	SB	101	2.2/3.3	432	786

Randell D. Hiatt
REGISTERED CIVIL ENGINEER

August 14, 2015
PLANS APPROVAL DATE


THE STATE OF CALIFORNIA OR ITS OFFICERS OR AGENTS SHALL NOT BE RESPONSIBLE FOR THE ACCURACY OR COMPLETENESS OF SCANNED COPIES OF THIS PLAN SHEET.

REGISTERED PROFESSIONAL ENGINEER
No. C50200
Exp. 6-30-17
CIVIL
STATE OF CALIFORNIA

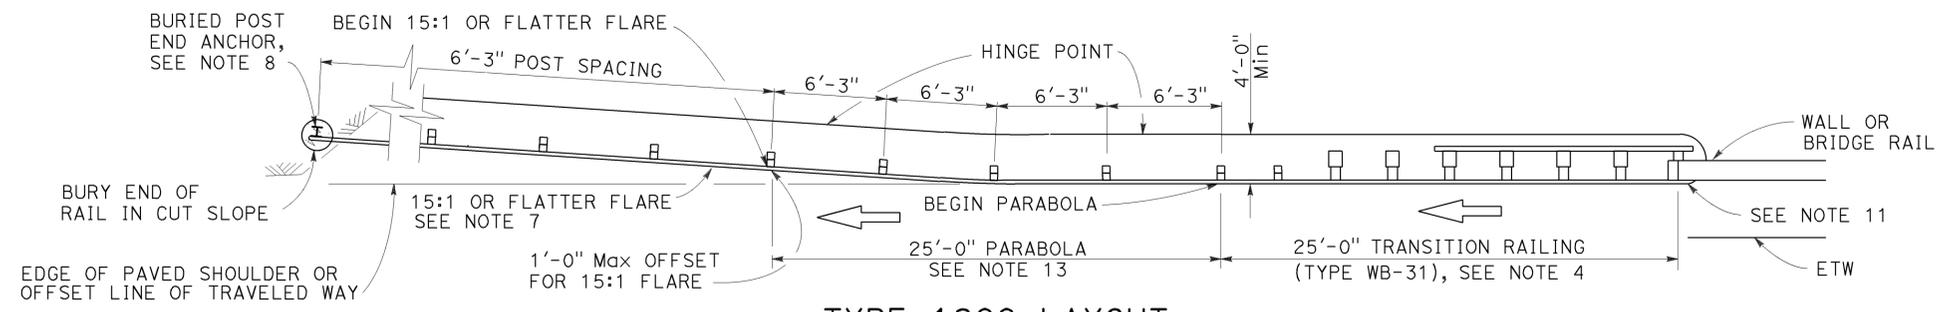

TYPE 12CC LAYOUT

(MGS installation at structure departure with a Buried end anchor treatment at trailing end of railing)
See Notes 9 and 10

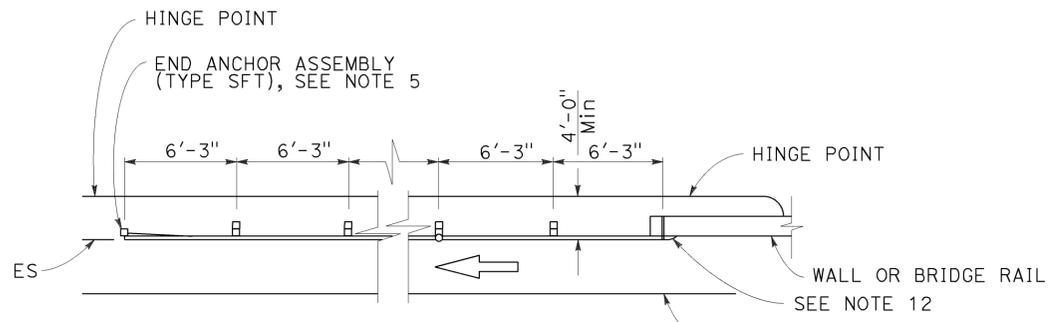

TYPE 12DD LAYOUT

(MGS installation at structure departure With end anchor assembly at trailing end of railing)
See Notes 6 and 9




BASE LINE (EDGE OF PAVED SHOULDER OR OFFSET LINE OF EDGE OF TRAVELED WAY)

$Y = \frac{WX^2}{L^2}$

Y = OFFSET FROM BASE LINE
W = MAXIMUM OFFSET
X = DISTANCE ALONG BASE LINE
L = LENGTH OF FLARE

PARABOLIC FLARE OFFSETS

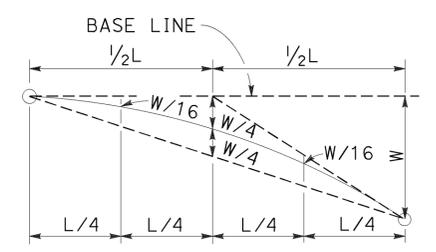

TYPICAL PARABOLIC LAYOUT

NOTES:

- Line post, blocks and hardware to be used are shown on Revised Standard Plans RSP A77L1, RSP A77L2, RSP A77M1, RSP A77N1 and RSP A77N2.
- MSG post spacing to be 6'-3" center to center, except as otherwise noted.
- Except as noted, line posts are 6" x 8" x 6'-0" wood with 6" x 12" x 1'-2" wood blocks. W6 x 8.5 or W6 x 9 steel posts, 6'-0" in length, with 6" x 12" x 1'-2" notched wood blocks or notched recycled plastic blocks may be used for 6" x 8" x 6'-0" wood line posts with 6" x 12" x 1'-2" wood blocks where applicable and when specified.
- For Transition Railing (Type WB-31) details for Type 12CC Layout, see Revised Standard Plan RSP A77U4.
- For details of End Anchor Assembly (Type SFT) used with Type 12DD Layout, see Revised Standard Plan RSP A77S1.
- Type 12DD layout is typically used to the right of traffic departing a structure on two-way conventional highways where the roadbed width across the structure is equal to or greater than 40 feet and MGS is recommended (embankment height, side slopes, other fixed objects). Length of railing to be equal to multiples of 12'-6". For MGS connection details to bridge rail, see Revised Standard Plans RSP A77U1 and RSP A77V1. For MGS connection details to wall, see Revised Standard Plan RSP A77U3.
- The 15:1 or flatter flare for Type 12CC Layout is based on the edge of the paved shoulder or offset line of edge of the traveled way. The length of MGS within the 15:1 or flatter flare is based on site conditions and should be a length equal to multiples of 12'-6".
- For details of the buried post end anchor used with Type 12CC Layout, see Revised Standard Plan RSP A77T2.
- Where placement of dike is required with MGS installations, see Revised Standard Plan RSP A77N4 for dike positioning details.
- Type 12CC Layout is typically used to the right of traffic departing a structure on two-way conventional highways where the roadbed width across the structure is less than 40 feet.
- For additional details of a typical connection to bridge rail for Layout Type 12CC, see Connection Detail CC on Revised Standard Plan RSP A77U2 and Connection Detail HH on Revised Standard Plan RSP A77V2.
- For additional details of a typical connection to bridge rail for Layout Type 12DD, see Connection Detail BB on Revised Standard Plan RSP A77U1 and Connection Detail GG on Revised Standard Plan RSP A77V1.
- For typical flare offsets for 25'-0" length parabola with maximum offset of 1'-0", see Revised Standard Plan RSP A77P1.

STATE OF CALIFORNIA
DEPARTMENT OF TRANSPORTATION

**MIDWEST GUARDRAIL SYSTEM
TYPICAL LAYOUTS FOR
STRUCTURE DEPARTURE**

NO SCALE

RSP A77Q5 DATED AUGUST 14, 2015 SUPERSEDES RSP A77Q5 DATED JULY 19, 2013 THAT SUPPLEMENTS THE STANDARD PLANS BOOK DATED 2010.

REVISED STANDARD PLAN RSP A77Q5

2010 REVISED STANDARD PLAN RSP A77Q5



Dist	COUNTY	ROUTE	POST MILES TOTAL PROJECT	SHEET No.	TOTAL SHEETS
05	SB	101	2.2/3.3	433	786

Randell D. Hiatt
REGISTERED CIVIL ENGINEER


November 15, 2013
PLANS APPROVAL DATE

THE STATE OF CALIFORNIA OR ITS OFFICERS OR AGENTS SHALL NOT BE RESPONSIBLE FOR THE ACCURACY OR COMPLETENESS OF SCANNED COPIES OF THIS PLAN SHEET.


TO ACCOMPANY PLANS DATED 12-7-15

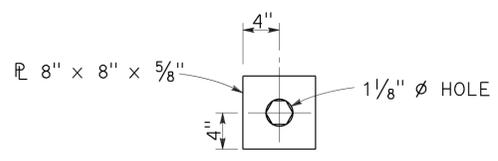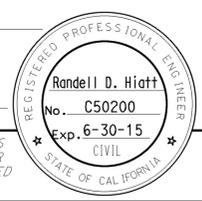


DETAIL "A"
CABLE CONNECTION
END PLATE

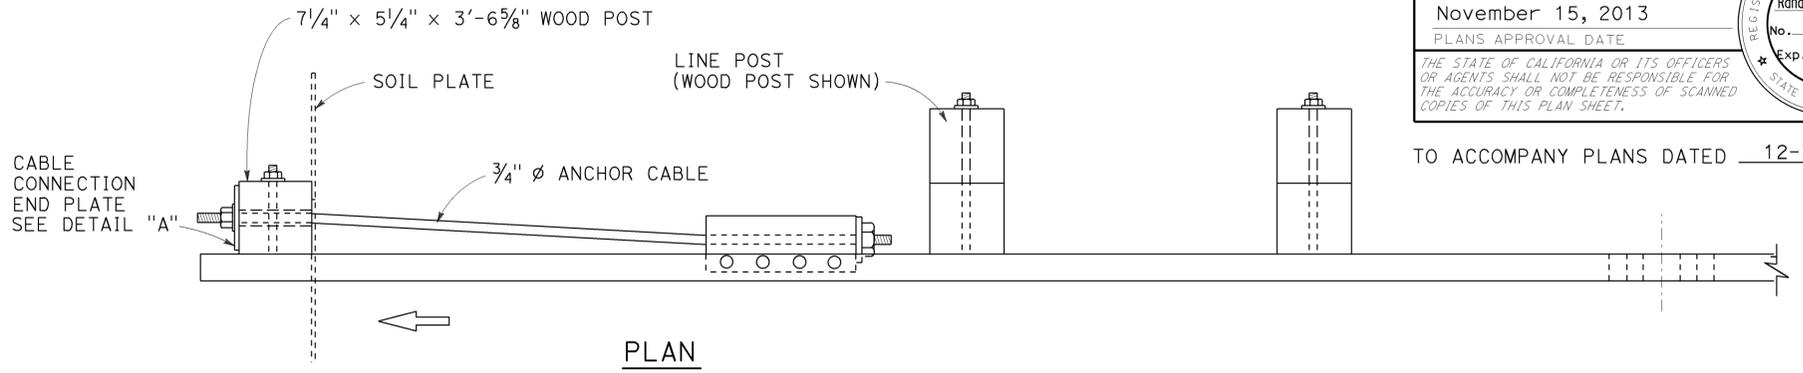

PLAN

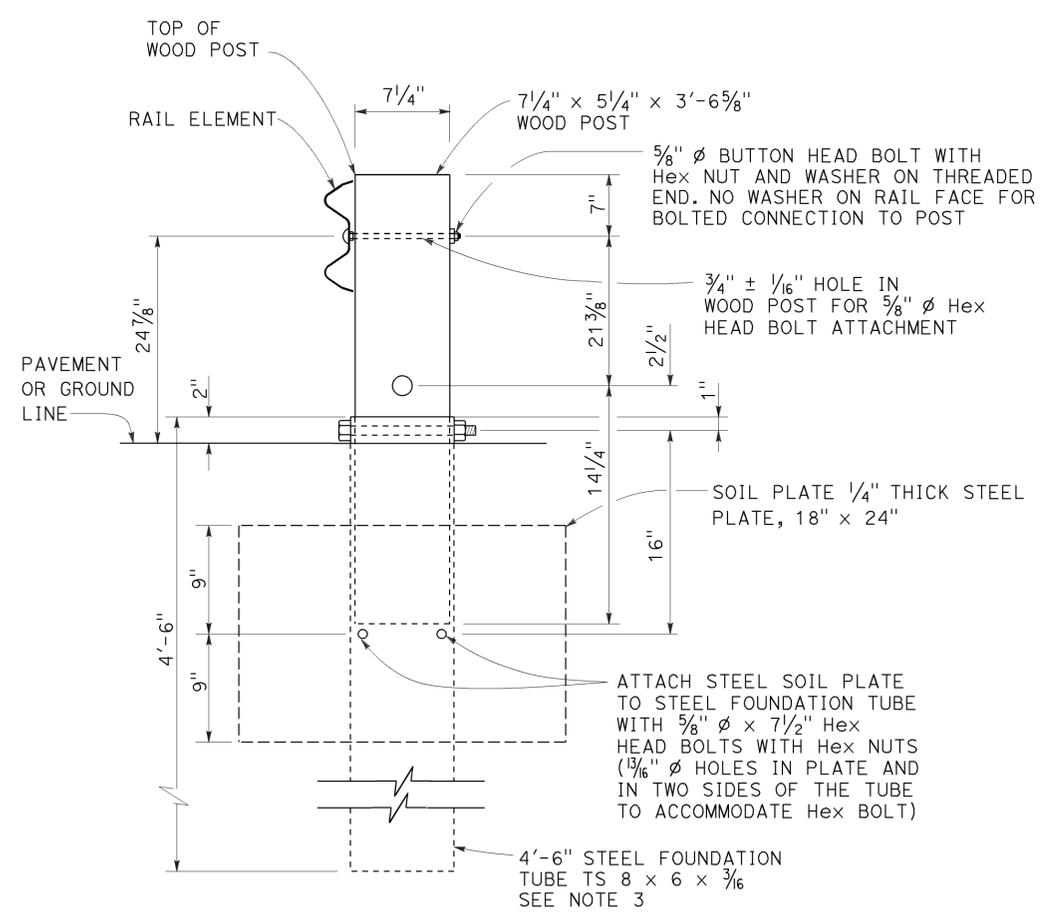

SECTION A-A

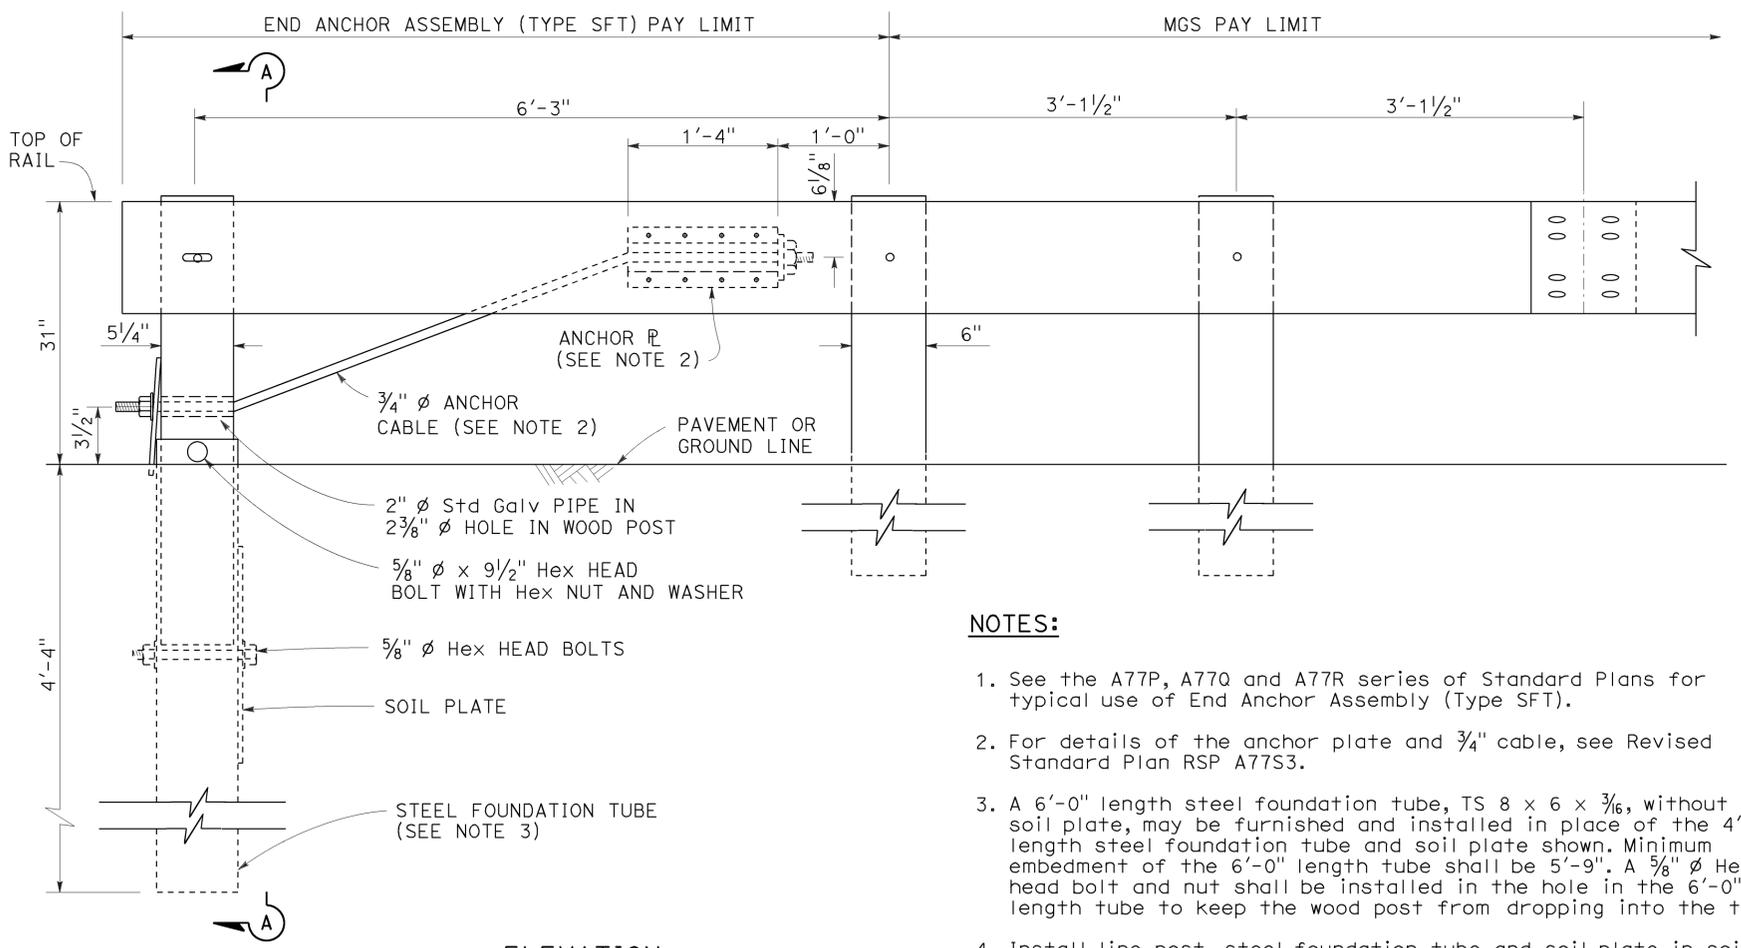

ELEVATION

END ANCHOR
ASSEMBLY (TYPE SFT)
See Note 1

NOTES:

1. See the A77P, A77Q and A77R series of Standard Plans for typical use of End Anchor Assembly (Type SFT).
2. For details of the anchor plate and 3/4" cable, see Revised Standard Plan RSP A77S3.
3. A 6'-0" length steel foundation tube, TS 8 x 6 x 3/16, without a soil plate, may be furnished and installed in place of the 4'-6" length steel foundation tube and soil plate shown. Minimum embedment of the 6'-0" length tube shall be 5'-9". A 5/8" diameter hex head bolt and nut shall be installed in the hole in the 6'-0" length tube to keep the wood post from dropping into the tube.
4. Install line post, steel foundation tube and soil plate in soil.

STATE OF CALIFORNIA
DEPARTMENT OF TRANSPORTATION
MIDWEST GUARDRAIL SYSTEM
END ANCHOR ASSEMBLY
(TYPE SFT)

NO SCALE

RSP A77S1 DATED NOVEMBER 15, 2013 SUPERSEDES RSP A77S1
DATED JULY 19, 2013 THAT SUPPLEMENTS THE STANDARD PLANS BOOK DATED 2010.

REVISED STANDARD PLAN RSP A77S1

2010 REVISED STANDARD PLAN RSP A77S1

Dist	COUNTY	ROUTE	POST MILES TOTAL PROJECT	SHEET No.	TOTAL SHEETS
05	SB	101	2.2/3.3	434	786

Randell D. Hiatt
REGISTERED CIVIL ENGINEER


November 15, 2013
PLANS APPROVAL DATE

THE STATE OF CALIFORNIA OR ITS OFFICERS OR AGENTS SHALL NOT BE RESPONSIBLE FOR THE ACCURACY OR COMPLETENESS OF SCANNED COPIES OF THIS PLAN SHEET.


REGISTERED PROFESSIONAL ENGINEER
No. C50200
Exp. 6-30-15
CIVIL
STATE OF CALIFORNIA

TO ACCOMPANY PLANS DATED 12-7-15

NOTE:
See Revised Standard Plans RSP A77S1, RSP A77S2 and RSP A77T1 for typical use of anchor cable and anchor plate.

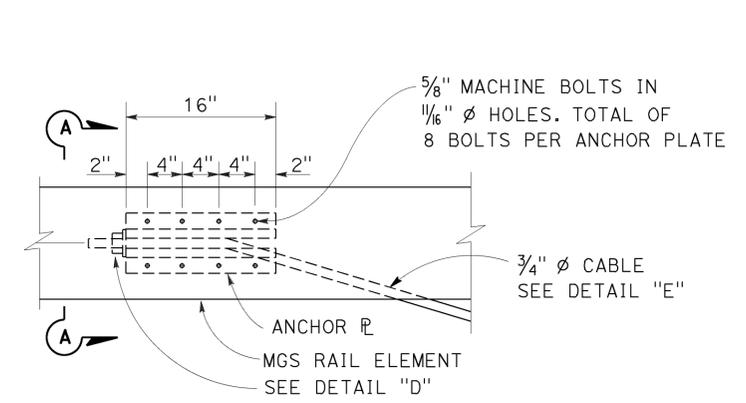


ANCHOR PLATE DETAIL
(MGS shown, TBB similar)

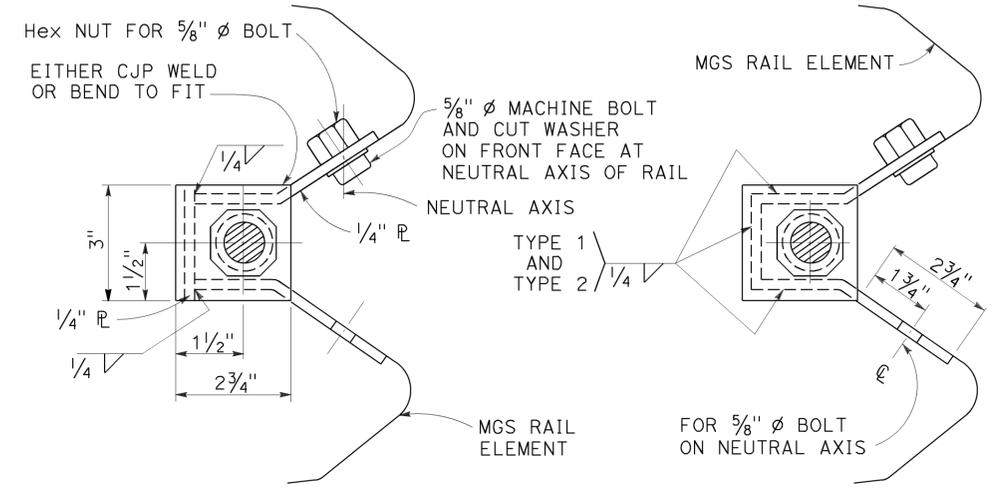


NOTE:
Dimensioning applies to both types.

SECTION A-A (ALTERNATIVE TYPE 1) **SECTION A-A (ALTERNATIVE TYPE 2)**

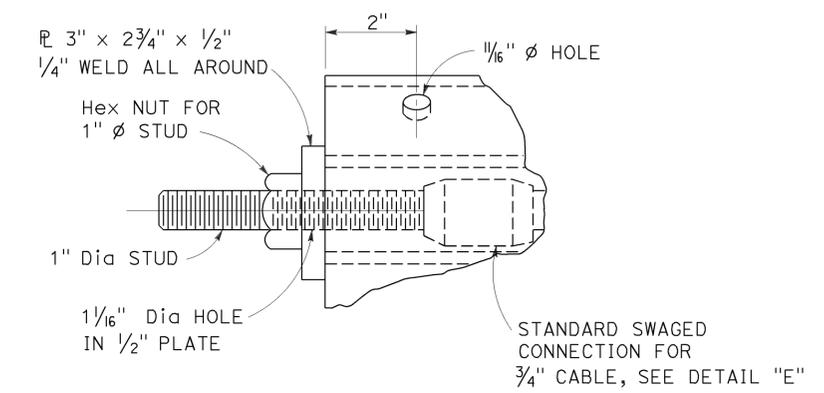

DETAIL "D"

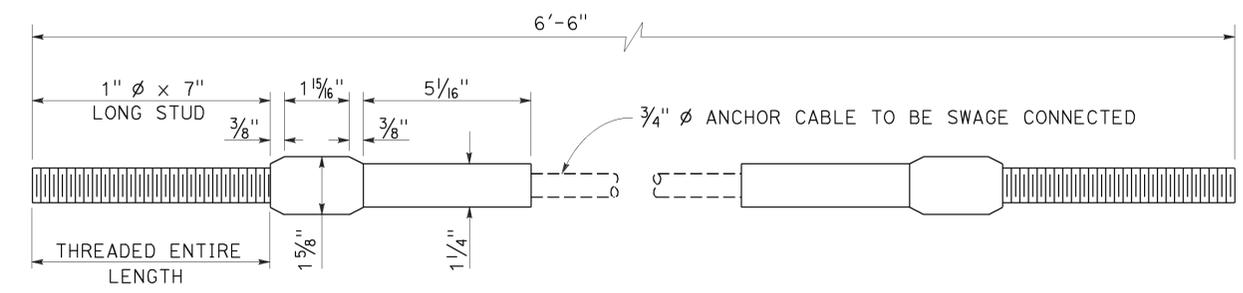

**ANCHOR CABLE WITH
SWAGED FITTING AND STUD
DETAIL "E"**

STATE OF CALIFORNIA
DEPARTMENT OF TRANSPORTATION

**METAL RAILING
ANCHOR CABLE AND
ANCHOR PLATE DETAILS**

NO SCALE
RSP A77S3 DATED NOVEMBER 15, 2013 SUPERSEDES RSP A77S3
DATED JULY 19, 2013 THAT SUPPLEMENTS THE STANDARD PLANS BOOK DATED 2010.

2010 REVISED STANDARD PLAN RSP A77S3



Dist	COUNTY	ROUTE	POST MILES TOTAL PROJECT	SHEET No.	TOTAL SHEETS
05	SB	101	2.2/3.3	435	786

Randell D. Hiatt
REGISTERED CIVIL ENGINEER

November 15, 2013
PLANS APPROVAL DATE

THE STATE OF CALIFORNIA OR ITS OFFICERS OR AGENTS SHALL NOT BE RESPONSIBLE FOR THE ACCURACY OR COMPLETENESS OF SCANNED COPIES OF THIS PLAN SHEET.


TO ACCOMPANY PLANS DATED 12-7-15

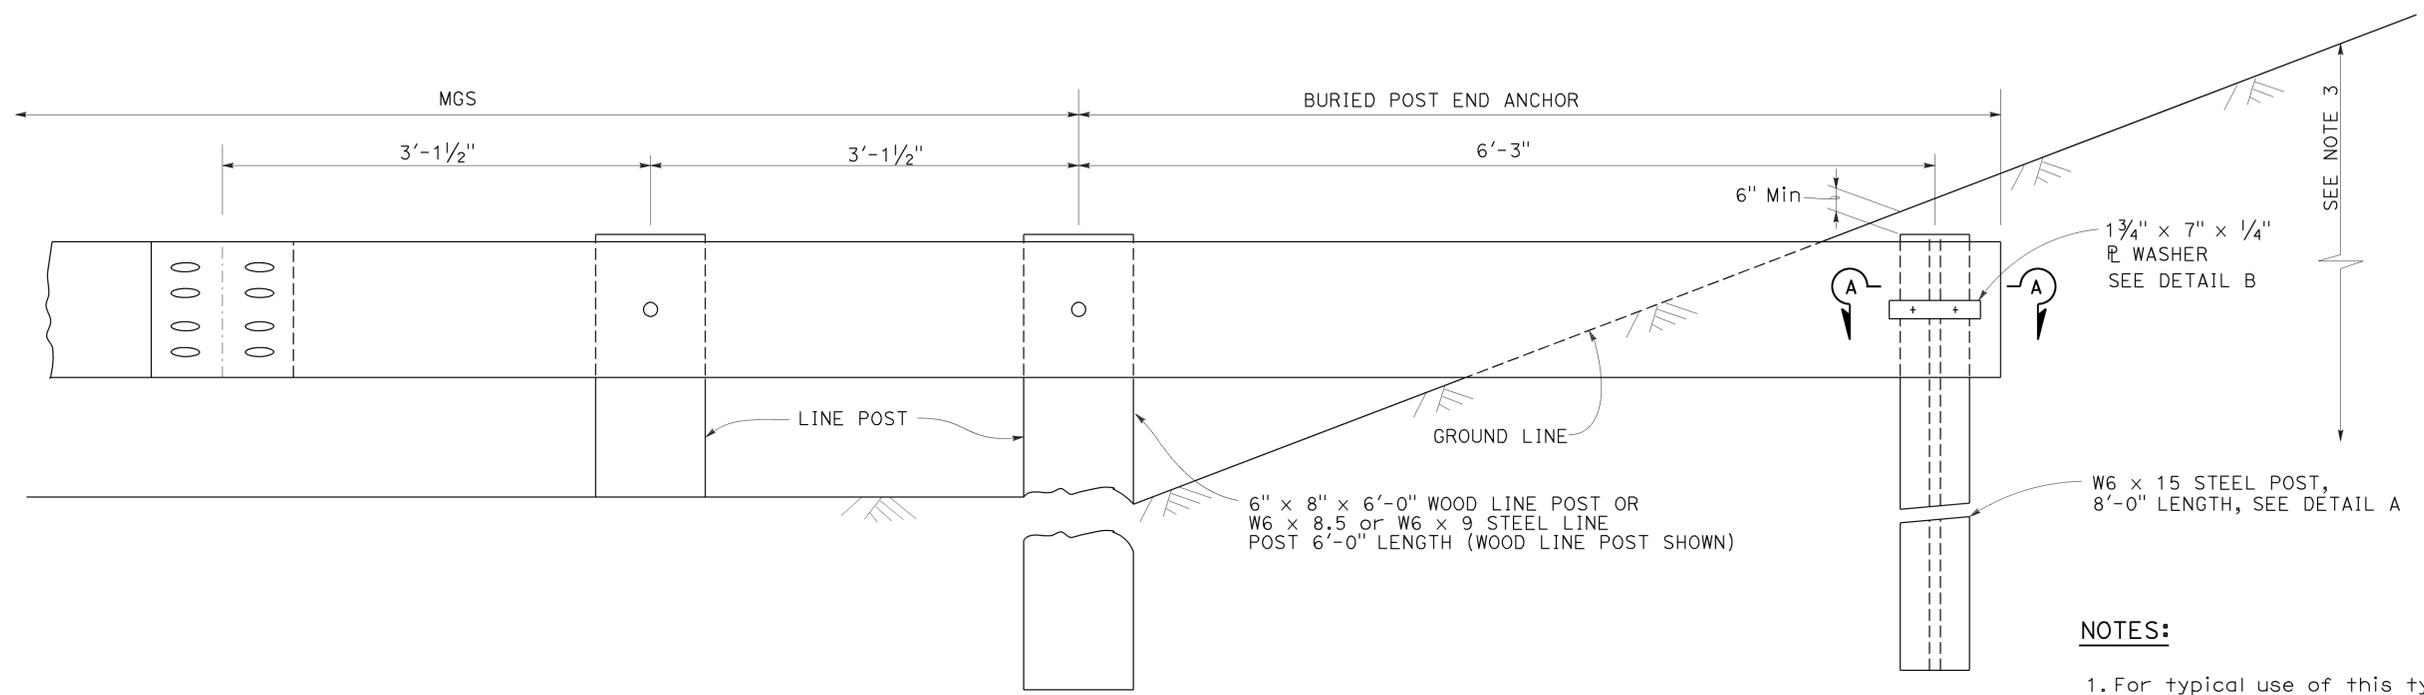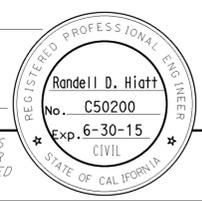


BURIED POST END ANCHOR
See Note 3

NOTES:


1. For typical use of this type of end anchor with MGS see the A77P, A77Q and A77R Series of the Standard Plans.
2. Holes excavation in the slope to construct the buried post end anchor shall be backfilled with selected earth, placed in layers approximately 1'-0" thick. Each layer shall be moistened and thoroughly compacted.
3. The buried post end anchor shall only be constructed at those locations where the slope perpendicular to the roadway is non-traversable.

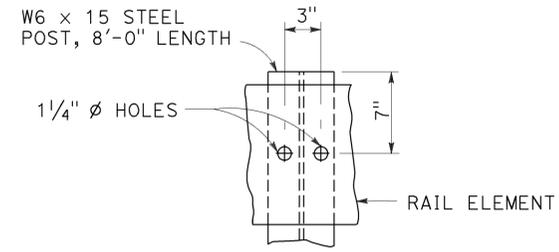

DETAIL A

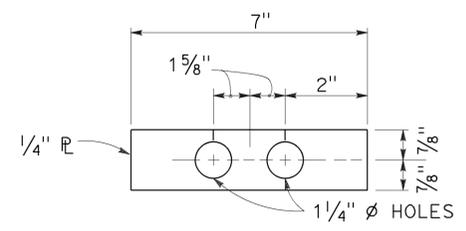

DETAIL B

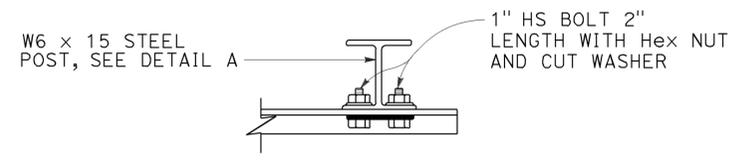

SECTION A-A

STATE OF CALIFORNIA
DEPARTMENT OF TRANSPORTATION
**MIDWEST GUARDRAIL SYSTEM
BURIED POST END ANCHOR**
NO SCALE

RSP A77T2 DATED NOVEMBER 15, 2013 SUPERSEDES RSP A77T2
DATED JULY 19, 2013 THAT SUPPLEMENTS THE STANDARD PLANS BOOK DATED 2010.

REVISED STANDARD PLAN RSP A77T2

2010 REVISED STANDARD PLAN RSP A77T2

Dist	COUNTY	ROUTE	POST MILES TOTAL PROJECT	SHEET No.	TOTAL SHEETS
05	SB	101	2.2/3.3	436	786


Randell D. Hiatt
REGISTERED CIVIL ENGINEER

July 19, 2013
PLANS APPROVAL DATE


THE STATE OF CALIFORNIA OR ITS OFFICERS OR AGENTS SHALL NOT BE RESPONSIBLE FOR THE ACCURACY OR COMPLETENESS OF SCANNED COPIES OF THIS PLAN SHEET.

REGISTERED PROFESSIONAL ENGINEER
No. C50200
Exp. 6-30-15
CIVIL
STATE OF CALIFORNIA

TO ACCOMPANY PLANS DATED 12-7-15

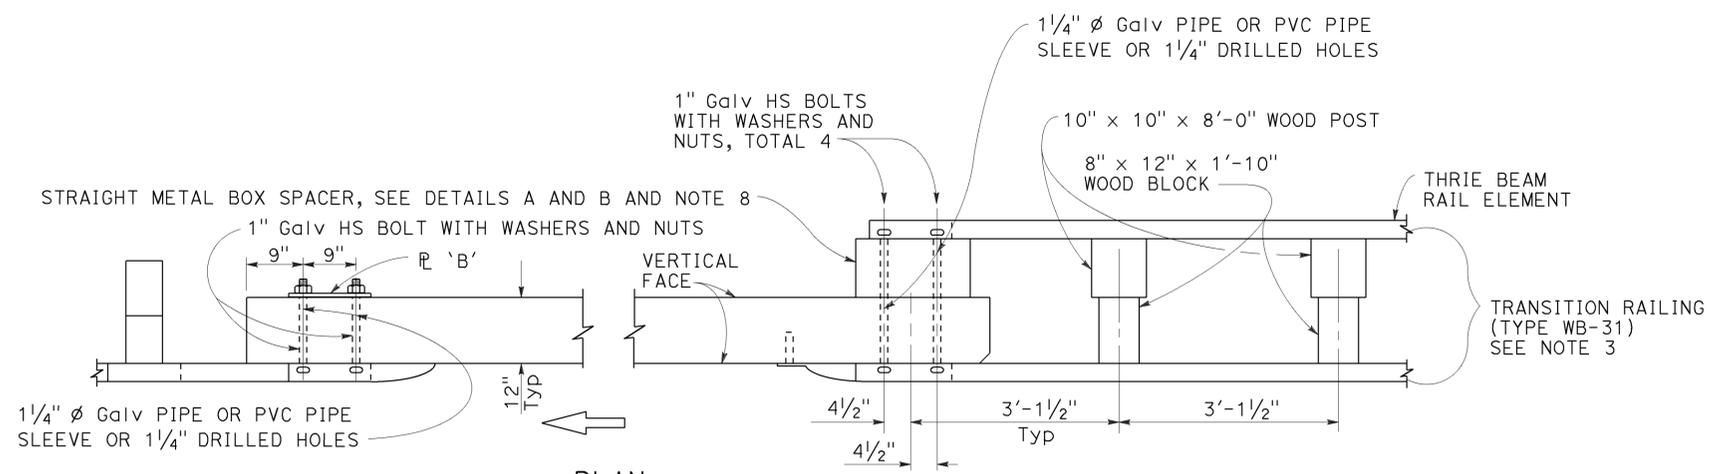

PLAN

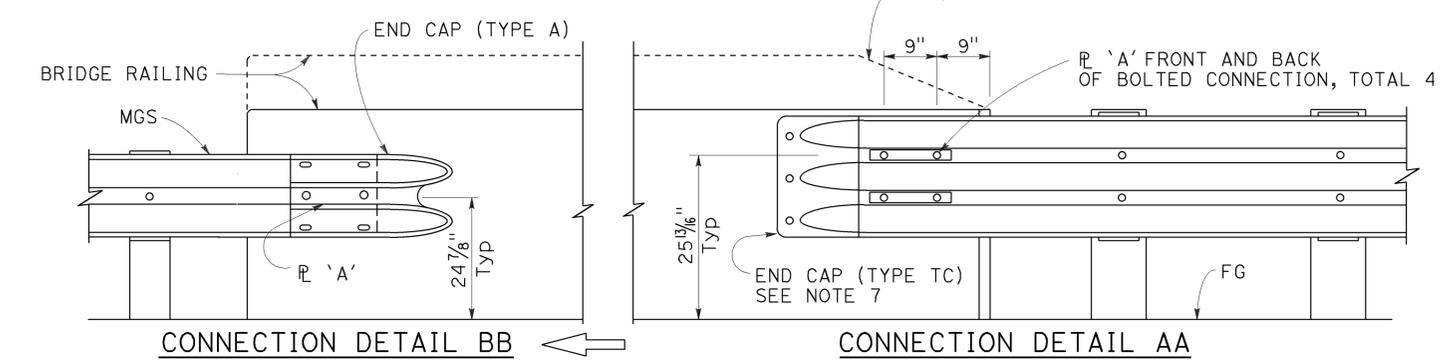


ELEVATION

MIDWEST GUARDRAIL SYSTEM CONNECTION TO BRIDGE RAILING WITHOUT SIDEWALK

NOTES:

1. See Revised Standard Plan RSP A77U2 for additional connection details to bridges without sidewalks.
2. Additional details of posts, blocks and hardware are shown on Revised Standard Plans RSP A77M1, RSP A77N1 and RSP A77N2.
3. For additional details of Transition Railing (Type WB-31), see Revised Standard Plan RSP A77U4. Transition Railing (Type WB-31) transitions the 12 gauge MGS railing section to a heavier gage nested thrie beam railing section which is connected to the concrete bridge railing.
4. For typical use of Connection Detail AA, see Layout Types 12A and 12B on Revised Standard Plan RSP A77Q1, Layout Types 12C and 12D on Revised Standard Plan RSP A77Q2, and Layout Type 12E on Revised Standard Plan RSP A77Q3.
5. For typical use of Connection Detail BB, see Layout Type 12D (structure departure railing connection) on Revised Standard Plan RSP A77Q2 and Layout Type 12DD on Revised Standard Plan RSP A77Q5.
6. Where the height of the bridge railing exceeds the height of the thrie beam railing by more than 1" at Connection Detail AA, taper the top of the end of the bridge railing at 4:1 to match the top elevation of the thrie beam rail.
7. For details of End Cap (Type TC), see Revised Standard Plan RSP A77U4.
8. See Revised Standard Plan RSP A77U4 for additional details regarding depth dimension for straight metal box spacer.

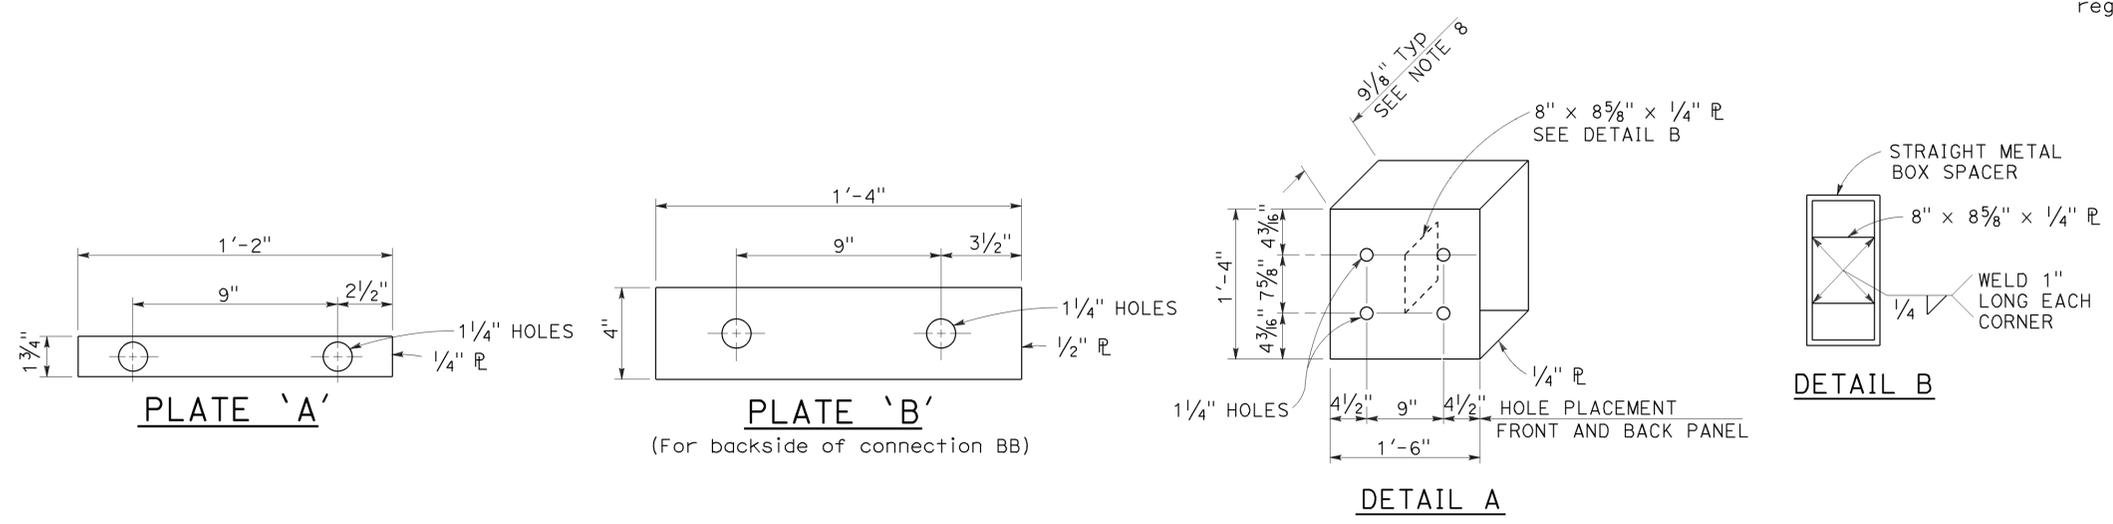

STRAIGHT METAL BOX SPACER

STATE OF CALIFORNIA
DEPARTMENT OF TRANSPORTATION
MIDWEST GUARDRAIL SYSTEM CONNECTIONS TO BRIDGE RAILINGS WITHOUT SIDEWALKS
DETAILS No. 1

NO SCALE

RSP A77U1 DATED JULY 19, 2013 SUPPLEMENTS THE STANDARD PLANS BOOK DATED 2010.

REVISED STANDARD PLAN RSP A77U1

2010 REVISED STANDARD PLAN RSP A77U1

Dist	COUNTY	ROUTE	POST MILES TOTAL PROJECT	SHEET No.	TOTAL SHEETS
05	SB	101	2.2/3.3	437	786



Randell D. Hiatt
REGISTERED CIVIL ENGINEER

July 19, 2013
PLANS APPROVAL DATE

THE STATE OF CALIFORNIA OR ITS OFFICERS OR AGENTS SHALL NOT BE RESPONSIBLE FOR THE ACCURACY OR COMPLETENESS OF SCANNED COPIES OF THIS PLAN SHEET.

REGISTERED PROFESSIONAL ENGINEER
No. C50200
Exp. 6-30-15
CIVIL
STATE OF CALIFORNIA


TO ACCOMPANY PLANS DATED 12-7-15

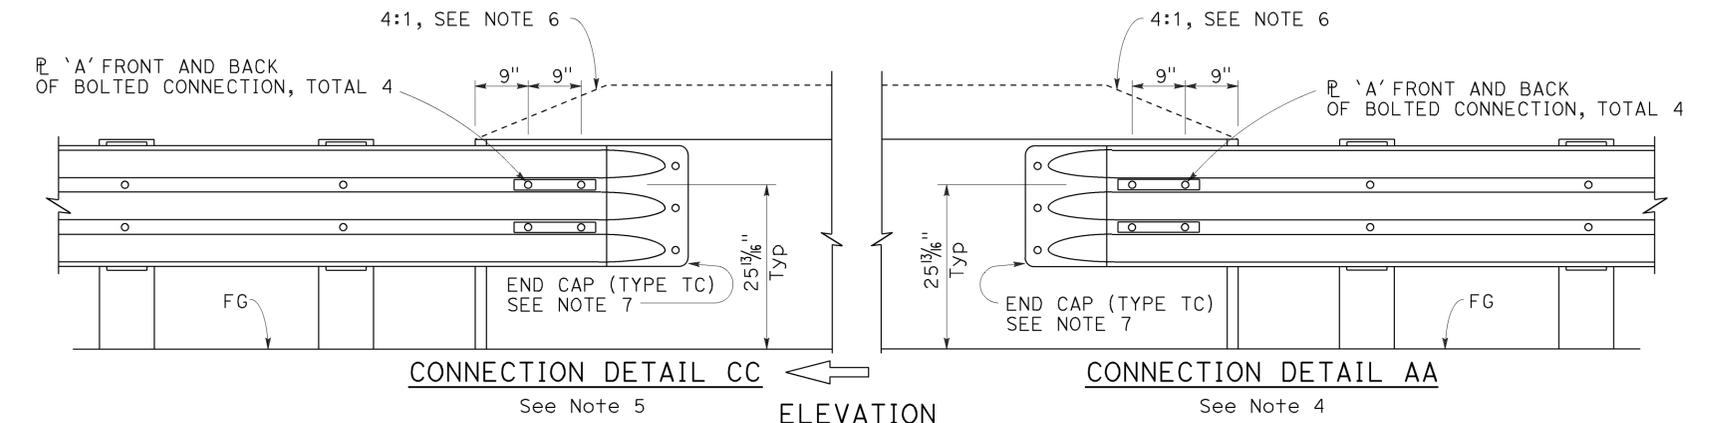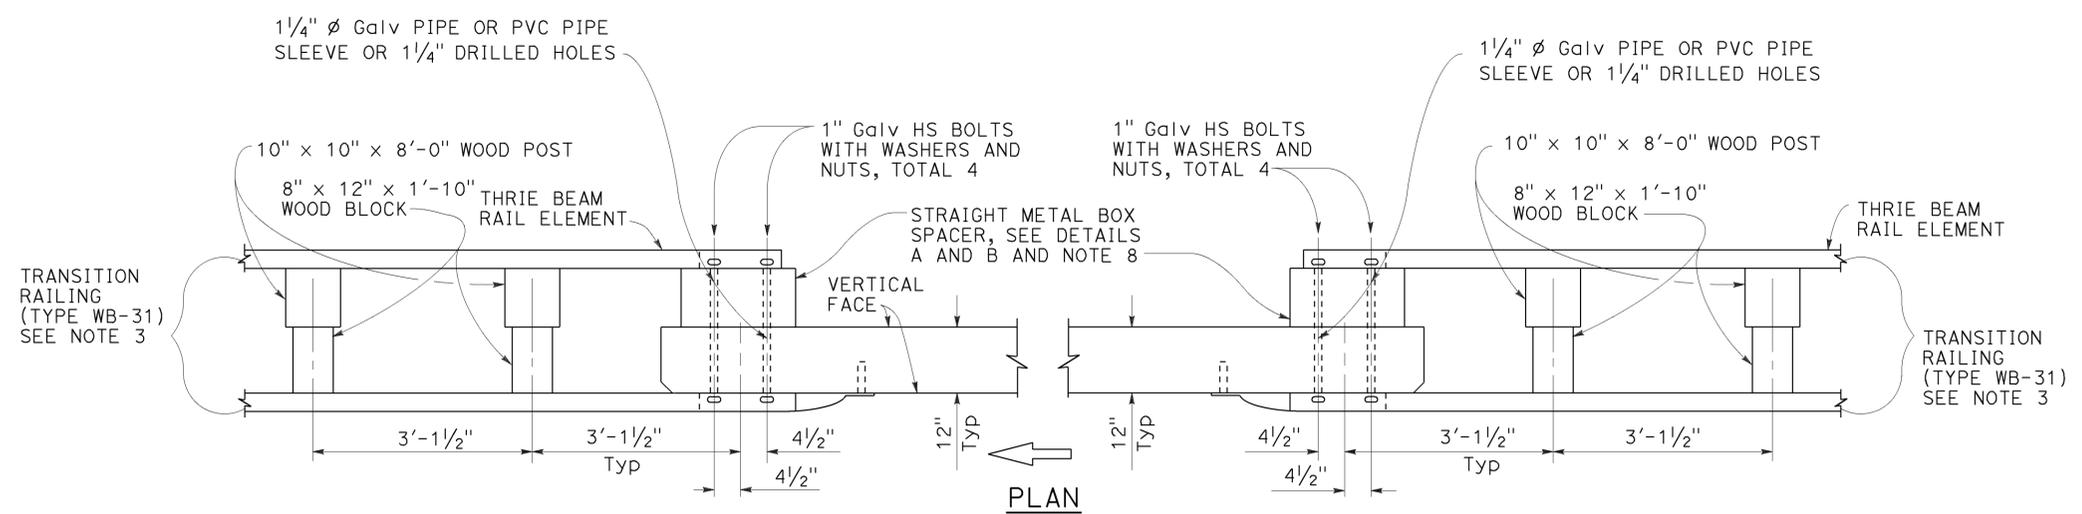

MIDWEST GUARDRAIL SYSTEM CONNECTION TO BRIDGE RAILING WITHOUT SIDEWALK

NOTES:

1. See Revised Standard Plan RSP A77U1 for additional connection details to bridges without sidewalks.
2. Additional details of posts, blocks and hardware are shown on Revised Standard Plans RSP A77M1, RSP A77N1 and RSP A77N2.
3. For additional details of Transition Railing (Type WB-31), see Revised Standard Plan RSP A77U4. Transition Railing (Type WB-31) transitions the 12 gauge MGS railing section to a heavier gage nested thrie beam railing section which is connected to the concrete bridge railing.
4. For typical use of Connection Detail AA, see Layout Types 12A and 12B on Revised Standard Plan RSP A77Q1, Layout Types 12C and 12D on Revised Standard Plan RSP A77Q2, and Layout Type 12E on Revised Standard Plan RSP A77Q3.
5. For typical use of Connection Detail CC, see Layout Types 12AA and 12BB on Revised Standard Plan RSP A77Q4 and Layout Type 12CC on Revised Standard Plan RSP A77Q5.
6. Where the height of the bridge railing exceeds the height of the thrie beam railing by more than 1" at Connection Detail AA and connection Detail CC, taper the top of the end of the bridge railing at 4:1 to match the top elevation of the thrie beam railing.
7. For details of End Cap (Type TC), see Revised Standard Plan RSP A77U4.
8. See Revised Standard Plan RSP A77U4 for additional details regarding depth dimension for straight metal box spacer.

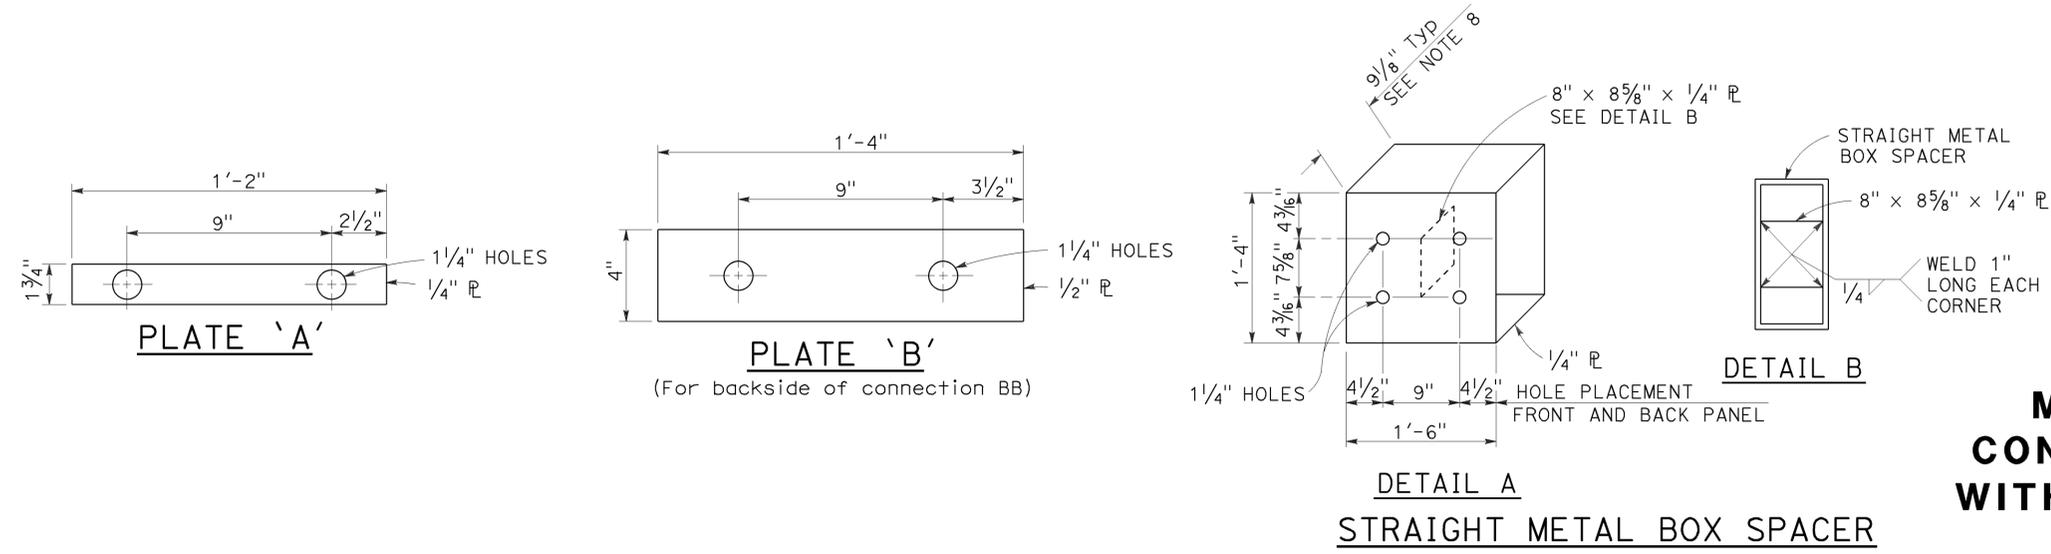

STATE OF CALIFORNIA
DEPARTMENT OF TRANSPORTATION

**MIDWEST GUARDRAIL SYSTEM
CONNECTIONS TO BRIDGE RAILINGS
WITHOUT SIDEWALKS DETAILS No. 2**

NO SCALE

RSP A77U2 DATED JULY 19, 2013 SUPPLEMENTS THE STANDARD PLANS BOOK DATED 2010.

REVISED STANDARD PLAN RSP A77U2

2010 REVISED STANDARD PLAN RSP A77U2






Dist	COUNTY	ROUTE	POST MILES TOTAL PROJECT	SHEET No.	TOTAL SHEETS
05	SB	101	2.2/3.3	438	786

Randell D. Hiatt
REGISTERED CIVIL ENGINEER



January 23, 2015
PLANS APPROVAL DATE

THE STATE OF CALIFORNIA OR ITS OFFICERS OR AGENTS SHALL NOT BE RESPONSIBLE FOR THE ACCURACY OR COMPLETENESS OF SCANNED COPIES OF THIS PLAN SHEET.

REGISTERED PROFESSIONAL ENGINEER
No. C50200
Exp. 6-30-15
CIVIL
STATE OF CALIFORNIA

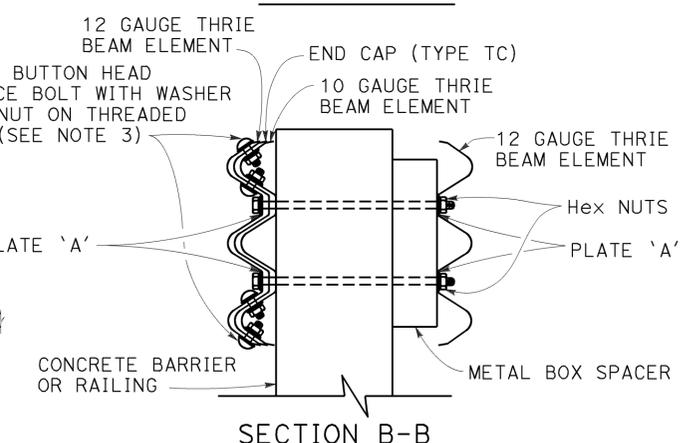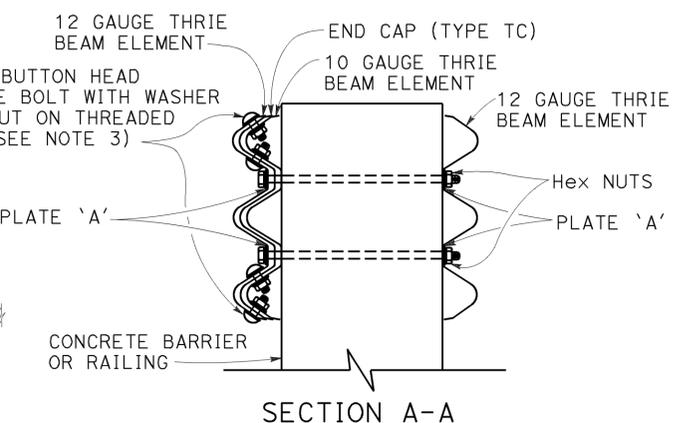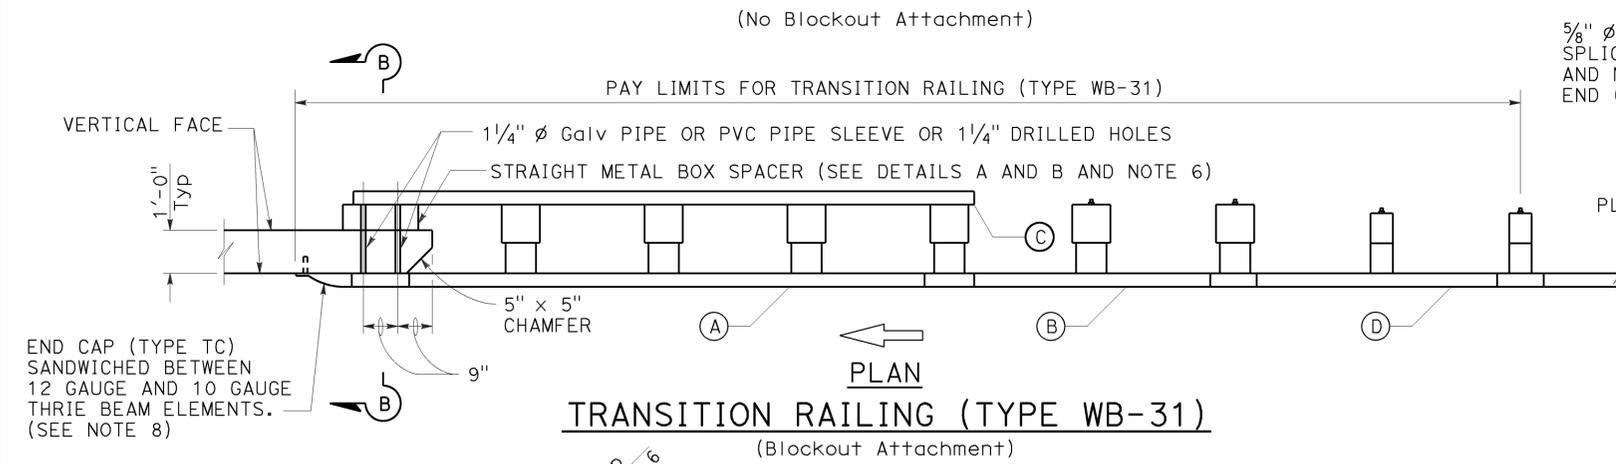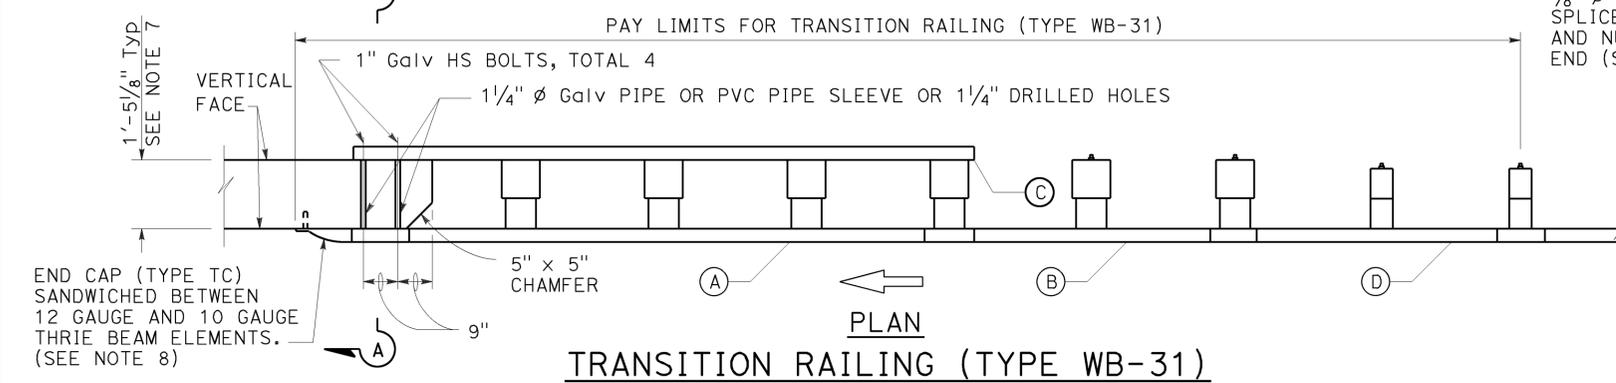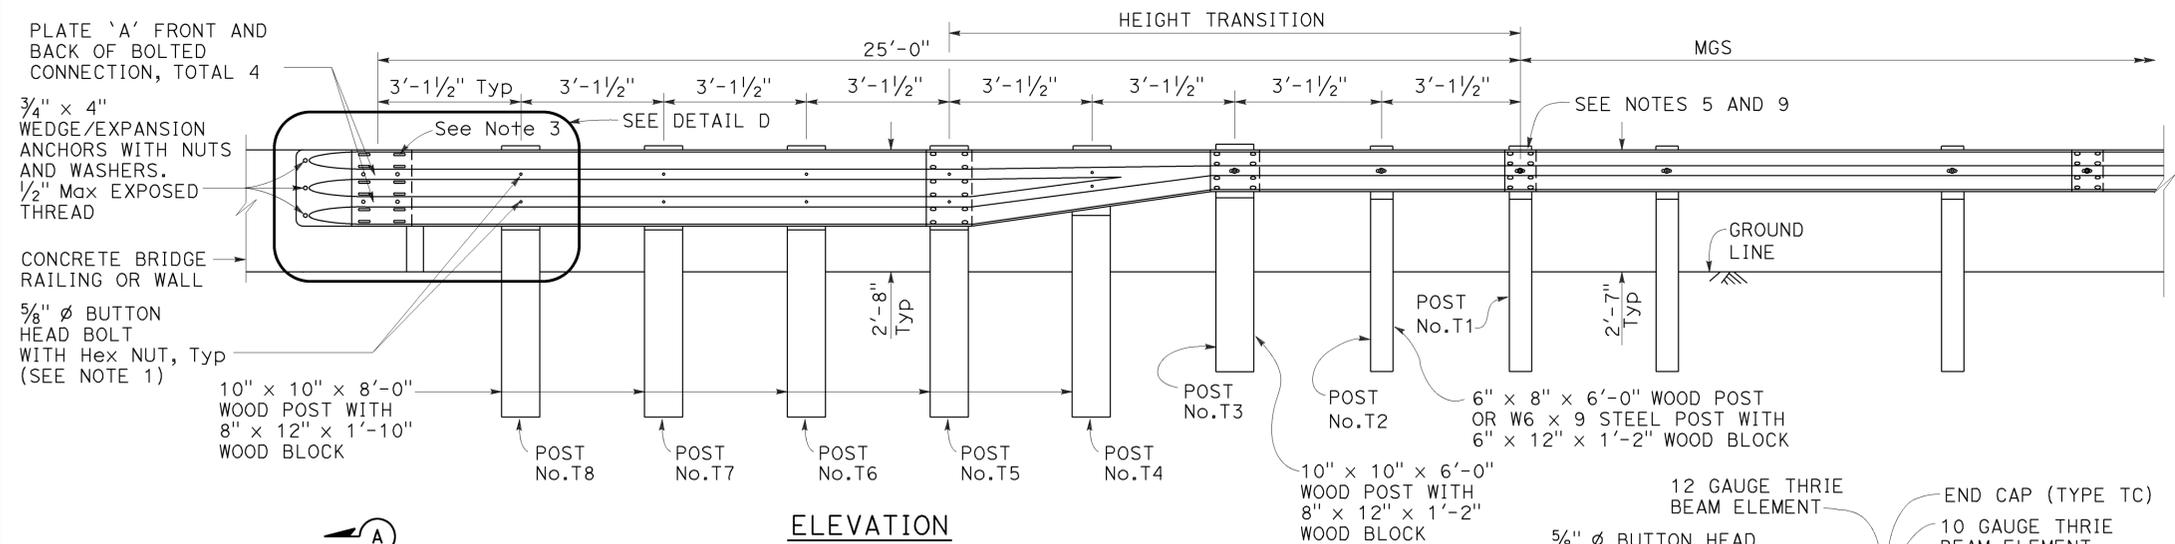

- LEGEND:**
- (A) NESTED THRIE BEAM ELEMENTS (ONE 12 GAUGE ELEMENT NESTED OVER ONE 10 GAUGE ELEMENT).
 - (B) ONE ASYMMETRICAL 10 GAUGE "W" BEAM TO THRIE BEAM ELEMENT.
 - (C) ONE 12 GAUGE THRIE BEAM ELEMENT.
 - (D) ONE 10 GAUGE "W" BEAM RAIL ELEMENT (7'-3/2" LENGTH)
- 10 GAUGE = 0.138" THICK
12 GAUGE = 0.108" THICK

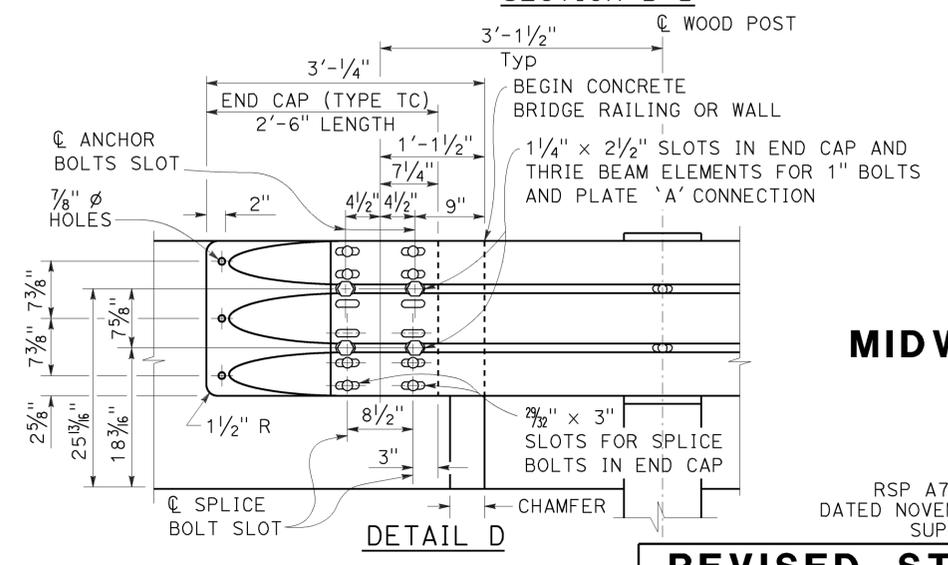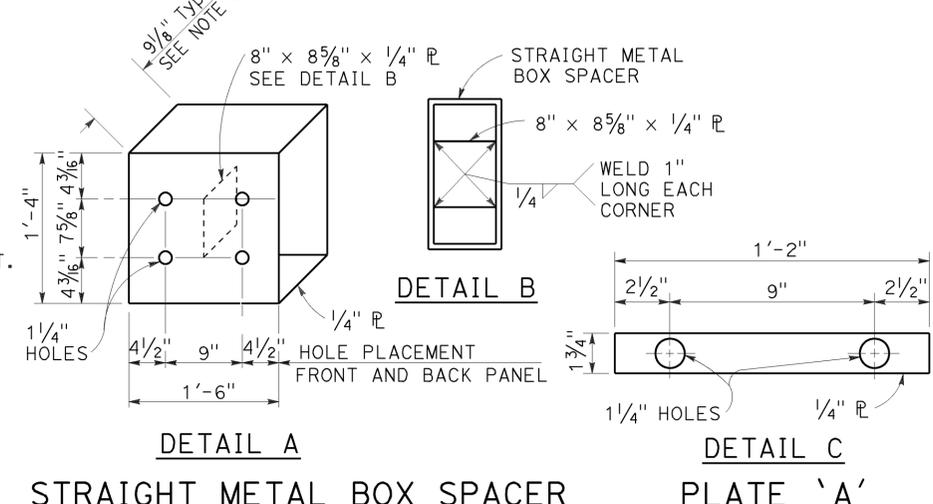

- NOTES:** TO ACCOMPANY PLANS DATED 12-7-15
1. Use 5/8" ϕ Button head bolts and hex nuts for connections to posts. No washer on rail face for bolted connections to post.
 2. The nested rail elements, end cap, and "W" beam to thrie beam element may be spliced together prior to bolting the elements to the wood post and concrete barrier or railing.
 3. Exterior splice bolt holes for rail element splices at Post No. T5 and the connection to the concrete barrier or railing shall be the standard 29/32" x 1 1/8" slot size. Interior splice bolt holes at these locations may be increased up to 1 1/4" ϕ . Only the top 4 and the bottom 4 splice bolts with washers and nuts are required for rail splices at Post No. T5 and the connection to the concrete barrier or railing.
 4. The top elevation of Posts No. T2 through No. T7 shall not project more than 1" above the top elevation of the rail element.
 5. Typically, the railing connected to Transition Railing (Type WB-31) will be either standard railing section of MGS with height transition ratio of 150:1 or a Caltrans approved 31" end treatment attached to Post No. T1.
 6. The depth of the metal box spacer varies from the 9/8" to 1 1/2" and is dependent on the width of the concrete railing or wall. The combined dimension for the depth of the metal box spacer plus the width of railing or wall is typically 21 1/8". Where the space between the backside of the concrete railing or wall and the rear thrie beam element is less than 1 1/2", metal plates similar to Plate 'A' are to be used as spacers.
 7. Where the width of the concrete railing or wall is greater than 17 1/8", wood blocks are to be used to fill the space created between the backside of Posts No. T5 through No. T8 and the rear thrie beam element. These wood blocks shall be 8" in width and 1'-2" in length. The dimension between the front thrie beam element and the rear thrie beam element is to match the width of the concrete railing or wall.
 8. End cap may be installed over 12 gauge and 10 gauge thrie beam elements where transition railing is installed on the departure end of bridge railing.
 9. Conform standard railing section height to 31" at Post No. T1 using height transition ratio of 150:1.

STATE OF CALIFORNIA
DEPARTMENT OF TRANSPORTATION

**MIDWEST GUARDRAIL SYSTEM
TRANSITION RAILING
(TYPE WB-31)**

NO SCALE

RSP A77U4 DATED JANUARY 23, 2015 SUPERSEDES RSP A77U4 DATED NOVEMBER 15, 2013 AND RSP A77U4 DATED JULY 19, 2013 THAT SUPPLEMENTS THE STANDARD PLANS BOOK DATED 2010.

REVISED STANDARD PLAN RSP A77U4

2010 REVISED STANDARD PLAN RSP A77U4



Dist	COUNTY	ROUTE	POST MILES TOTAL PROJECT	SHEET No.	TOTAL SHEETS
05	SB	101	2.2/3.3	439	786

Randell D. Hiatt
REGISTERED CIVIL ENGINEER

July 19, 2013
PLANS APPROVAL DATE


THE STATE OF CALIFORNIA OR ITS OFFICERS OR AGENTS SHALL NOT BE RESPONSIBLE FOR THE ACCURACY OR COMPLETENESS OF SCANNED COPIES OF THIS PLAN SHEET.

TO ACCOMPANY PLANS DATED 12-7-15



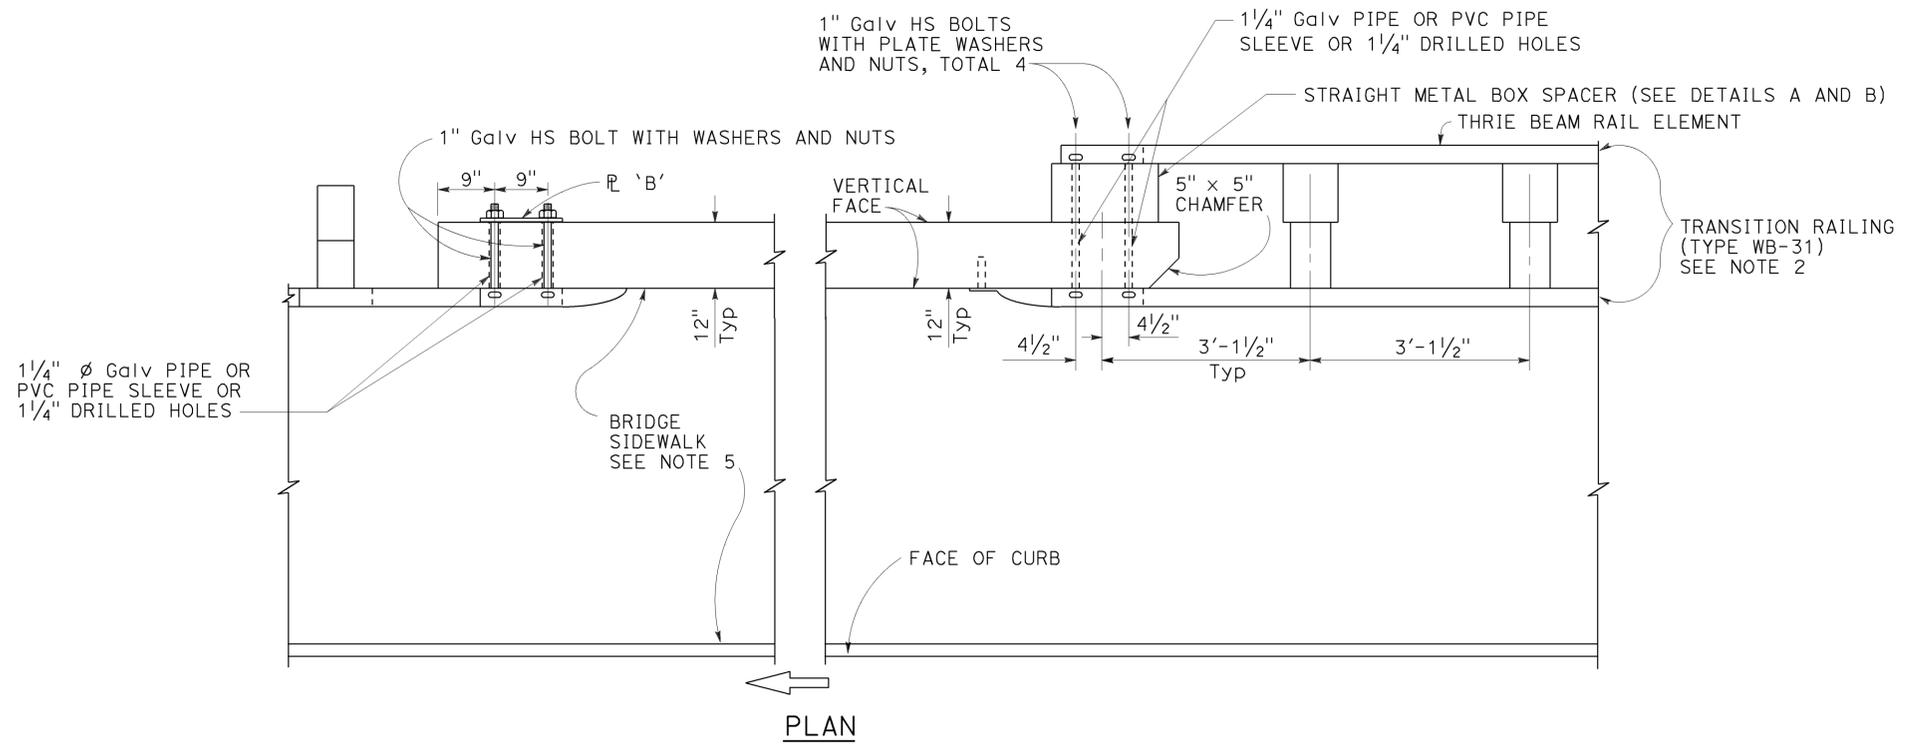
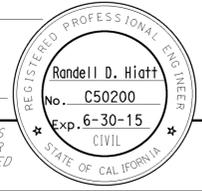


NOTES:

1. See Revised Standard Plan RSP A77V2 for additional connection details to bridges with sidewalks.
2. For additional details of Transition Railing (Type WB-31), see Revised Standard Plan RSP A77U4. Transition Railing (Type WB-31) transitions the 12 gauge MGS railing section to a heavier gage nested thrie beam railing section which is connected to the concrete bridge railing.
3. For typical use of Connection Detail FF, see Layout Types 12A and 12B on Revised Standard Plan RSP A77Q1.
4. For typical use of Connection Detail GG, see Layout Type 12D on Revised Standard Plan RSP A77Q2 and Layout Type 12DD on Revised Standard Plan RSP A77Q5.
5. Where the bridge sidewalk is not continued beyond the end of the bridge railing, the portion of the sidewalk beyond each end of the bridge railing shall be transitioned down from the top elevation of the sidewalk, for its entire width, to the finished grade of the adjacent roadbed. The longitudinal slope of each sidewalk elevation transition shall not exceed 8.33 percent.
6. For details of End Cap (Type TC), see Revised Standard Plan RSP A77U4.
7. See Revised Standard Plan RSP A77U4 for additional details regarding depth dimension for straight metal box spacer.

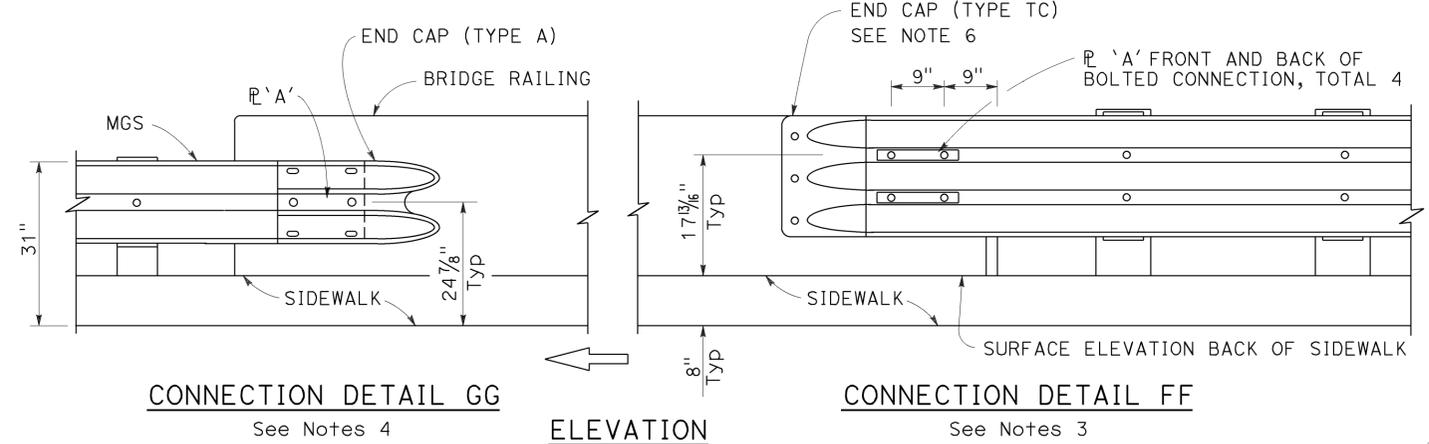

MIDWEST GUARDRAIL SYSTEM CONNECTION TO BRIDGE RAILING WITH SIDEWALKS

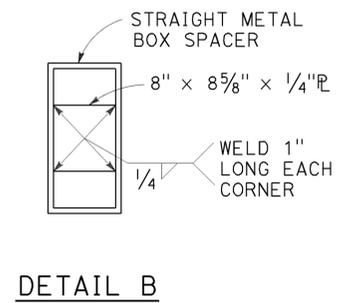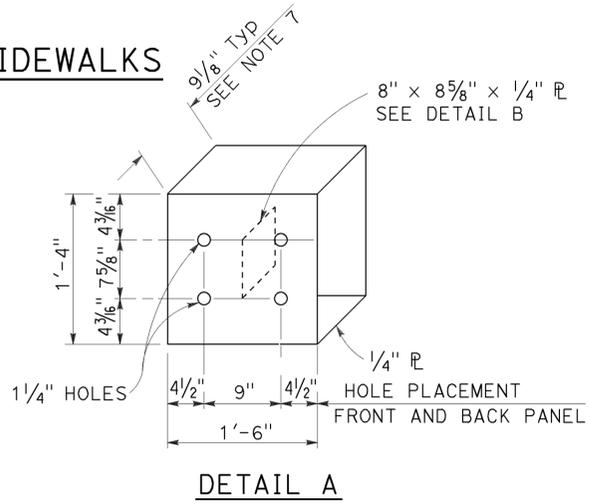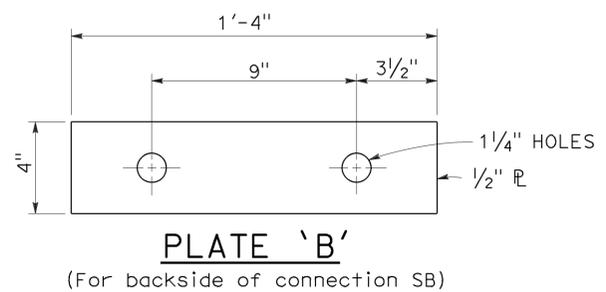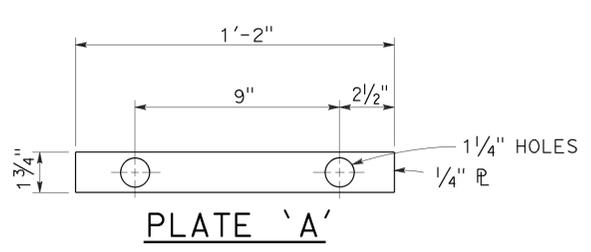

MIDWEST GUARDRAIL SYSTEM CONNECTIONS TO BRIDGE RAILINGS WITH SIDEWALKS DETAILS No. 1

NO SCALE

RSP A77V1 DATED JULY 19, 2013 SUPPLEMENTS THE STANDARD PLANS BOOK DATED 2010.

REVISED STANDARD PLAN RSP A77V1

2010 REVISED STANDARD PLAN RSP A77V1

Dist	COUNTY	ROUTE	POST MILES TOTAL PROJECT	SHEET No.	TOTAL SHEETS
05	SB	101	2.2/3.3	440	786


Randell D. Hiatt
REGISTERED CIVIL ENGINEER

July 19, 2013
PLANS APPROVAL DATE


THE STATE OF CALIFORNIA OR ITS OFFICERS OR AGENTS SHALL NOT BE RESPONSIBLE FOR THE ACCURACY OR COMPLETENESS OF SCANNED COPIES OF THIS PLAN SHEET.

REGISTERED PROFESSIONAL ENGINEER
No. C50200
Exp. 6-30-15
CIVIL
STATE OF CALIFORNIA

TO ACCOMPANY PLANS DATED 12-7-15

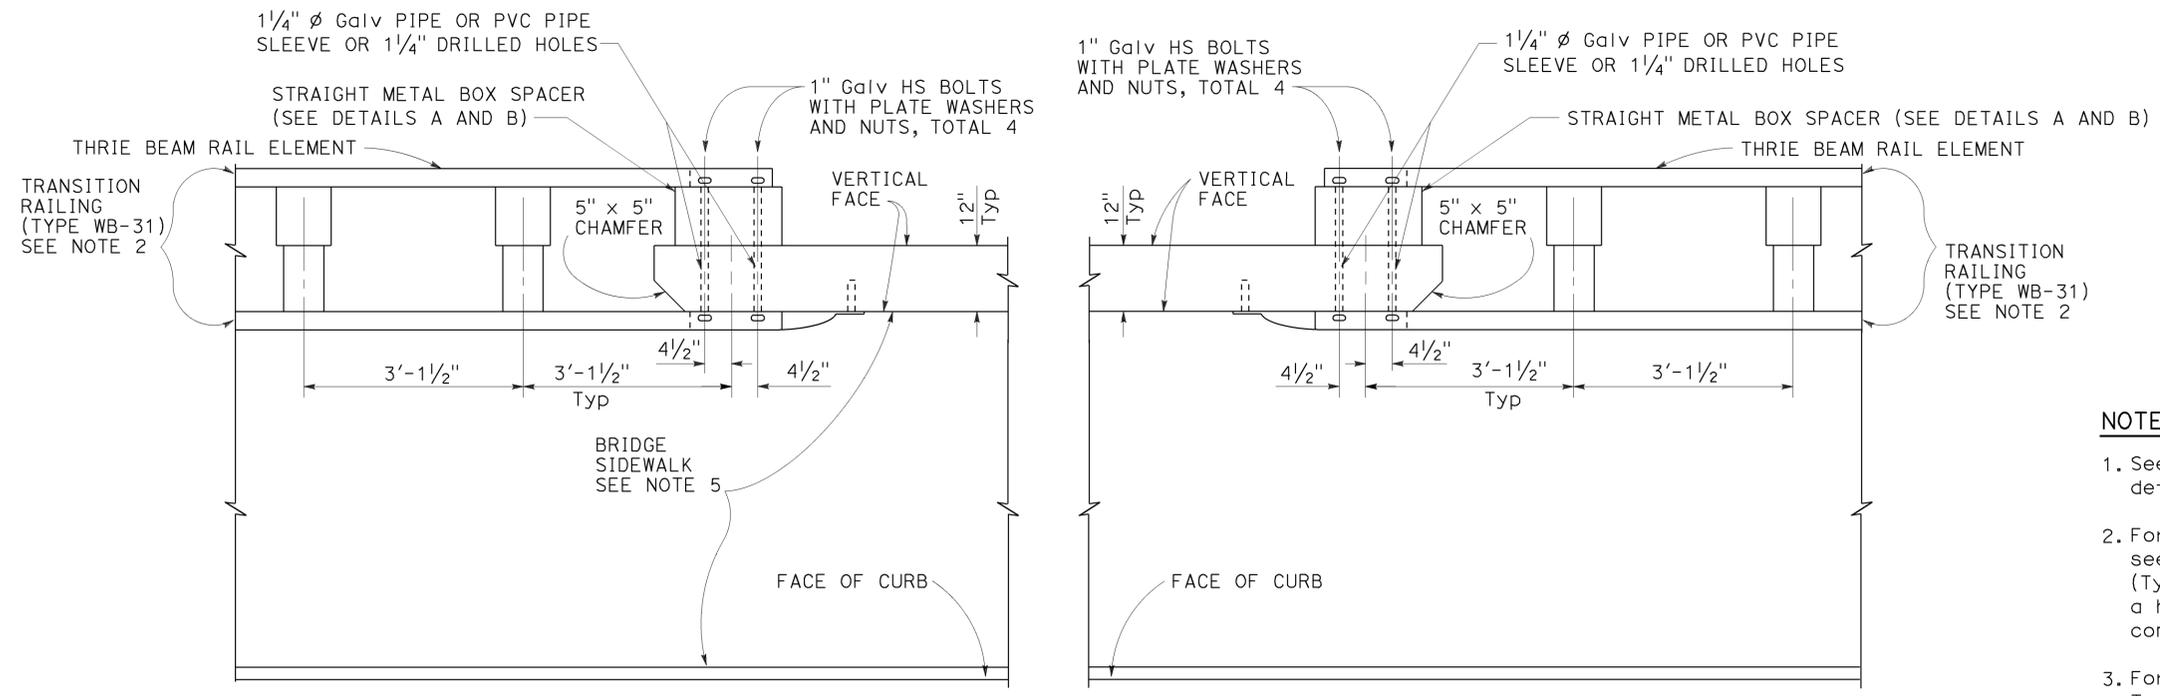

PLAN

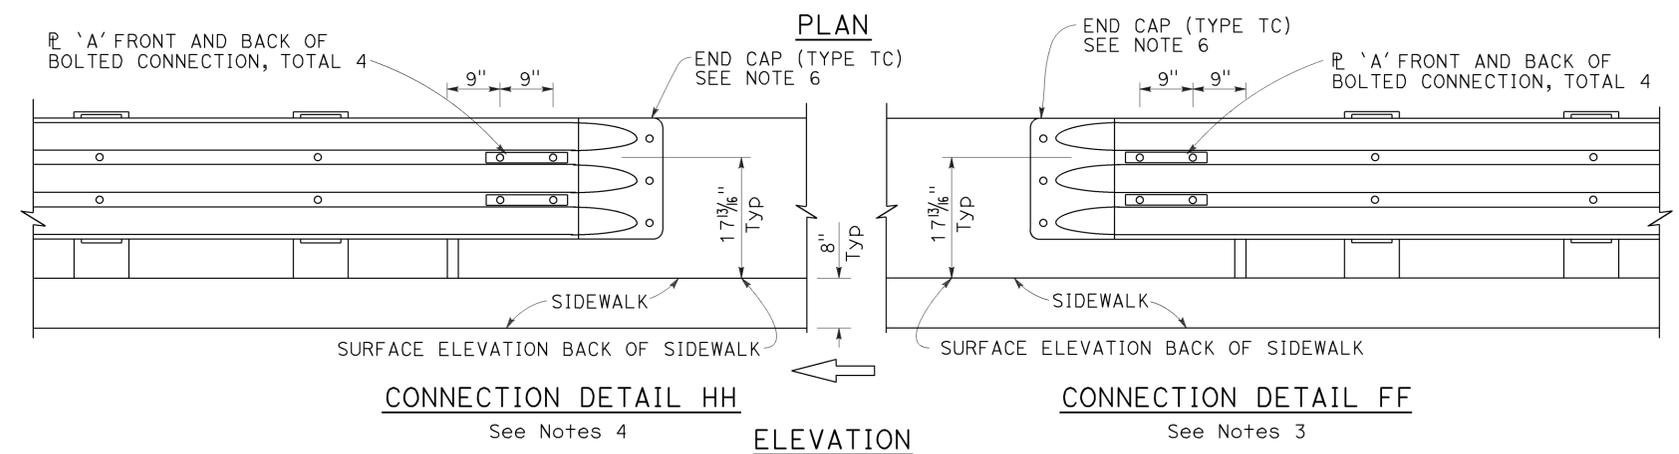

CONNECTION DETAIL HH

CONNECTION DETAIL FF

ELEVATION

MIDWEST GUARDRAIL SYSTEM CONNECTION TO BRIDGE RAILING WITH SIDEWALKS

NOTES:

1. See Revised Standard Plan RSP A77V1 for additional connection details to bridges with sidewalks.
2. For additional details of Transition Railing (Type WB-31), see Revised Standard Plan RSP A77U4. Transition Railing (Type WB-31) transitions the 12 gauge MGS railing section to a heavier gage nested thrie beam railing section which is connected to the concrete bridge railing.
3. For typical use of Connection Detail FF, see Layout Types 12A and 12B on Revised Standard Plan RSP A77Q1.
4. For typical use of Connection Detail HH, see Layout Types 12AA and 12BB on Revised Standard Plan RSP A77Q4.
5. Where the bridge sidewalk is not continued beyond the end of the bridge railing, the portion of the sidewalk beyond each end of the bridge railing shall be transitioned down from the top elevation of the sidewalk, for its entire width, to the finished grade of the adjacent roadbed. The longitudinal slope of each sidewalk elevation transition shall not exceed 8.33 percent.
6. For details of End Cap (Type TC), see Revised Standard Plan RSP A77U4.
7. See Revised Standard Plan RSP A77U4 for additional details regarding depth dimension for straight metal box spacer.

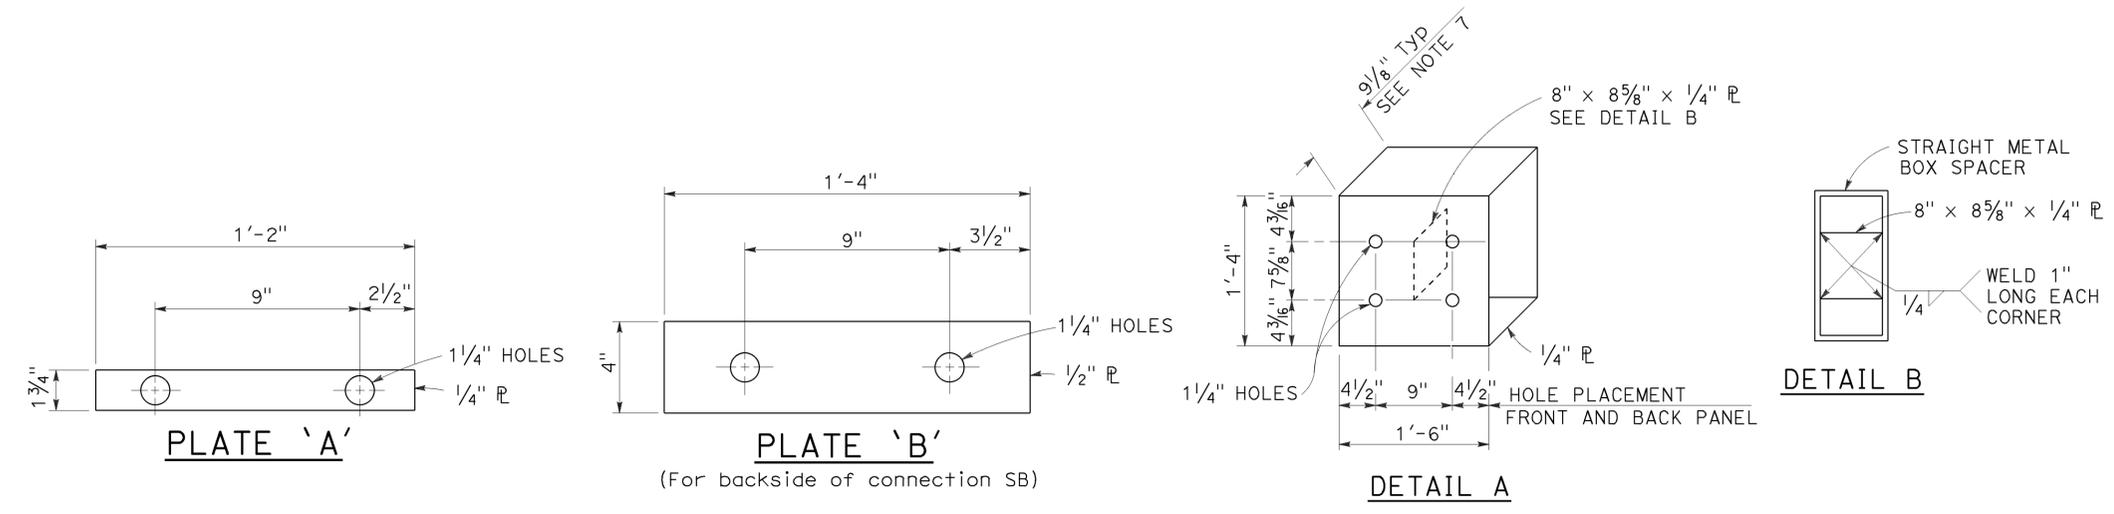


PLATE 'A'

PLATE 'B'

DETAIL A

DETAIL B

STRAIGHT METAL BOX SPACER

STATE OF CALIFORNIA
DEPARTMENT OF TRANSPORTATION

MIDWEST GUARDRAIL SYSTEM CONNECTIONS TO BRIDGE RAILINGS WITH SIDEWALKS DETAILS No. 2

NO SCALE

RSP A77V2 DATED JULY 19, 2013 SUPPLEMENTS THE STANDARD PLANS BOOK DATED 2010.

REVISED STANDARD PLAN RSP A77V2

2010 REVISED STANDARD PLAN RSP A77V2

Dist	COUNTY	ROUTE	POST MILES TOTAL PROJECT	SHEET No.	TOTAL SHEETS
05	SB	101	2.2/3.3	441	786

Randell D. Hiatt
REGISTERED CIVIL ENGINEER









July 19, 2013
PLANS APPROVAL DATE

THE STATE OF CALIFORNIA OR ITS OFFICERS OR AGENTS SHALL NOT BE RESPONSIBLE FOR THE ACCURACY OR COMPLETENESS OF SCANNED COPIES OF THIS PLAN SHEET.

REGISTERED PROFESSIONAL ENGINEER
Randell D. Hiatt
No. C50200
Exp. 6-30-15
CIVIL
STATE OF CALIFORNIA

TO ACCOMPANY PLANS DATED 12-7-15

- NOTES:**
- All holes in steel post to be $\frac{1}{8}$ " Dia maximum. Holes in wood posts and wood blocks to be $\frac{3}{4}$ " Dia $\pm \frac{1}{16}$ ".
 - Dimensions shown for wood post are nominal.
 - For use with W6 x 8.5 or W6 x 9 steel post.
 - For use with W6 x 15 steel post.
 - Notched face of block faces steel post.

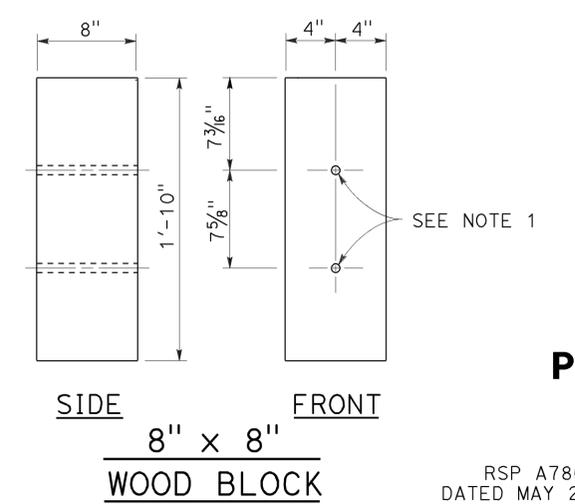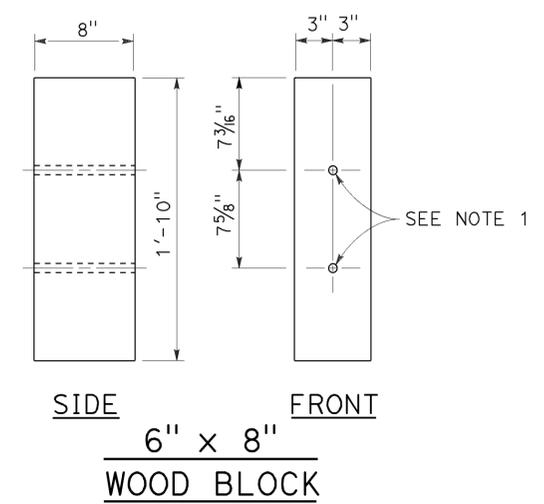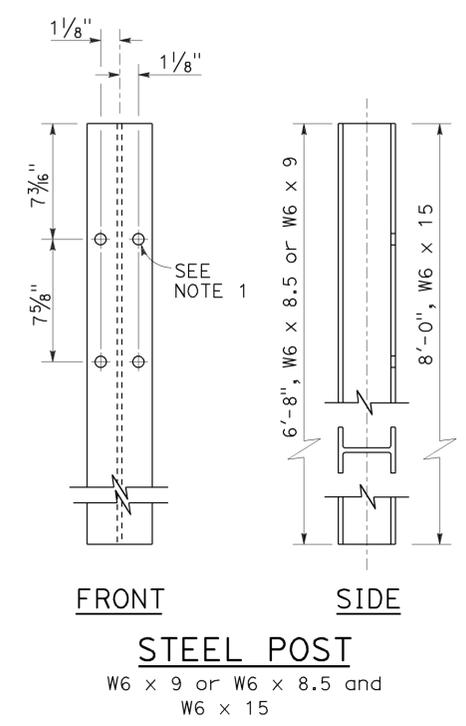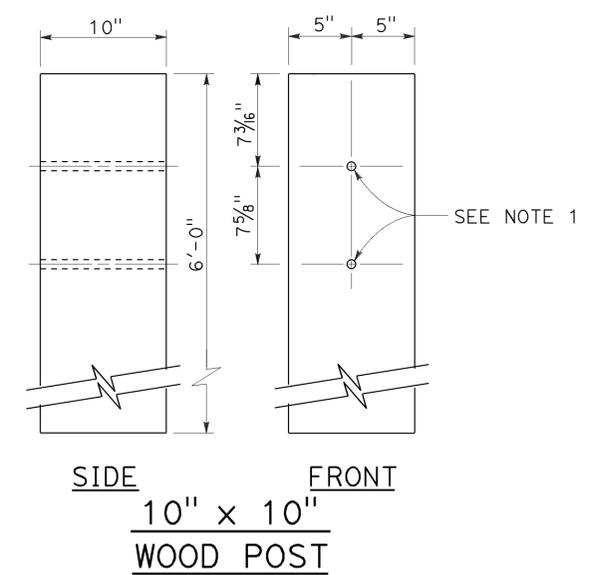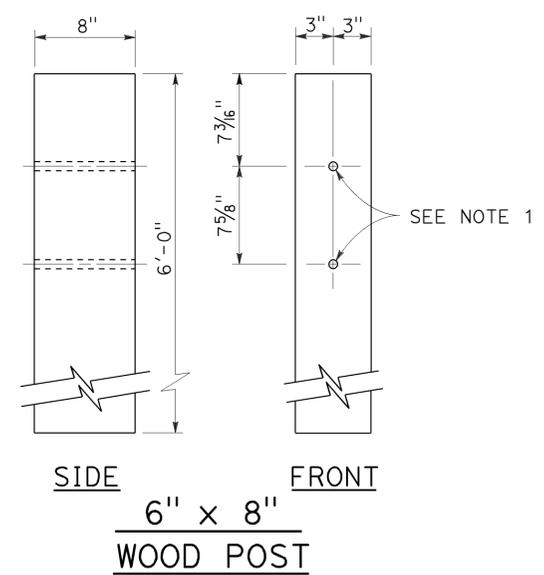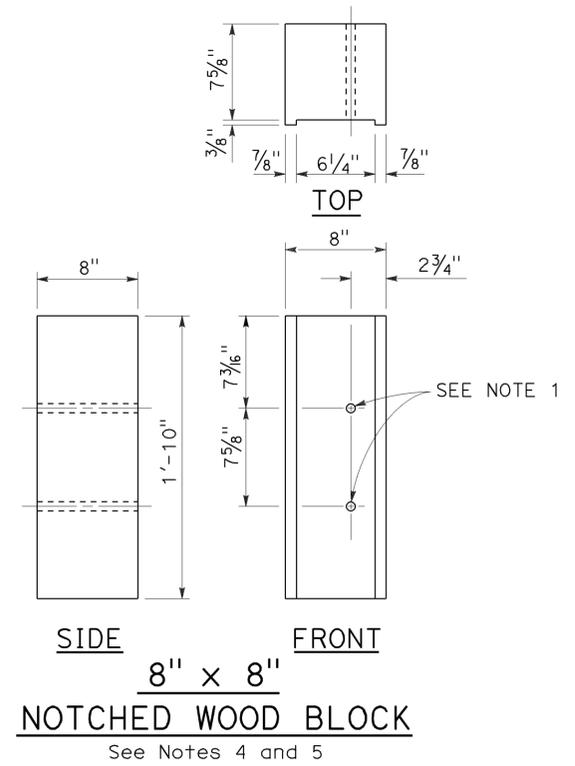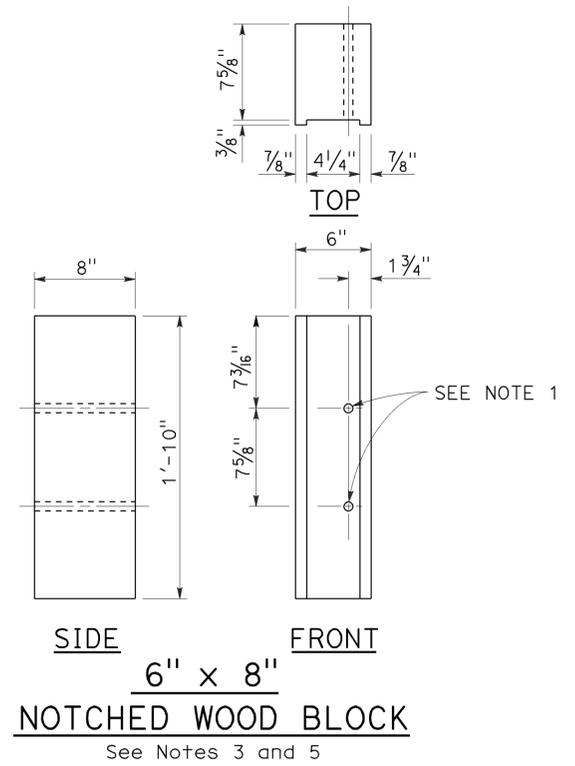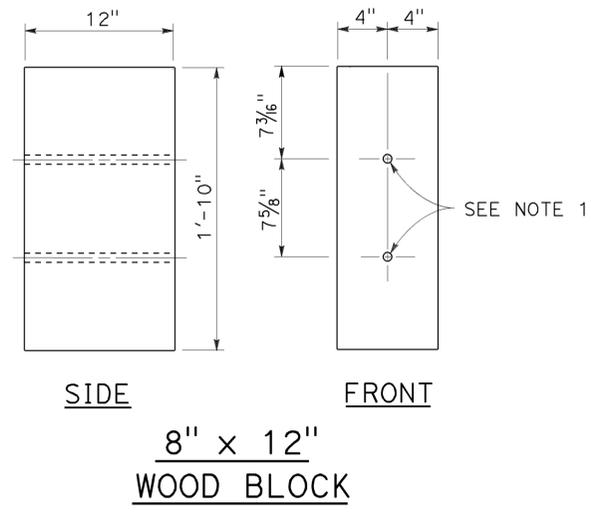

STATE OF CALIFORNIA
DEPARTMENT OF TRANSPORTATION




**THREE BEAM BARRIER
POST AND BLOCK DETAILS**

NO SCALE


RSP A78C2 DATED JULY 19, 2013 SUPERSEDES STANDARD PLAN A78C2
DATED MAY 20, 2011 - PAGE 92 OF THE STANDARD PLANS BOOK DATED 2010.

REVISED STANDARD PLAN RSP A78C2

2010 REVISED STANDARD PLAN RSP A78C2

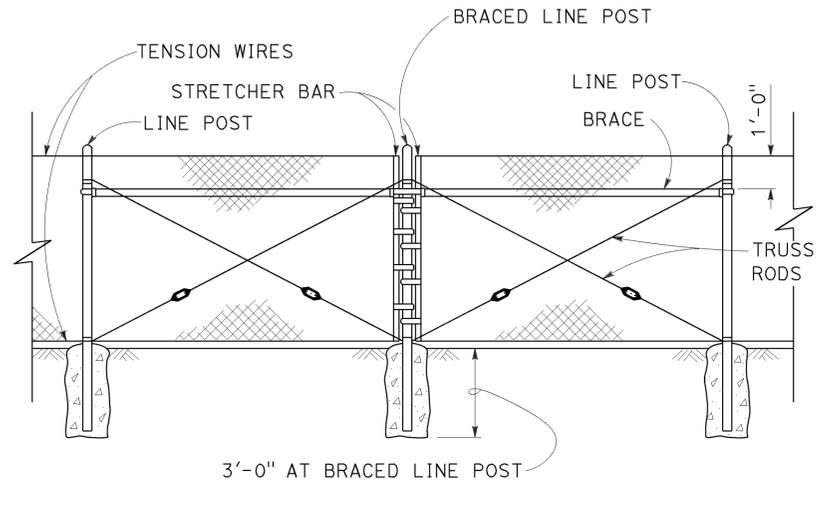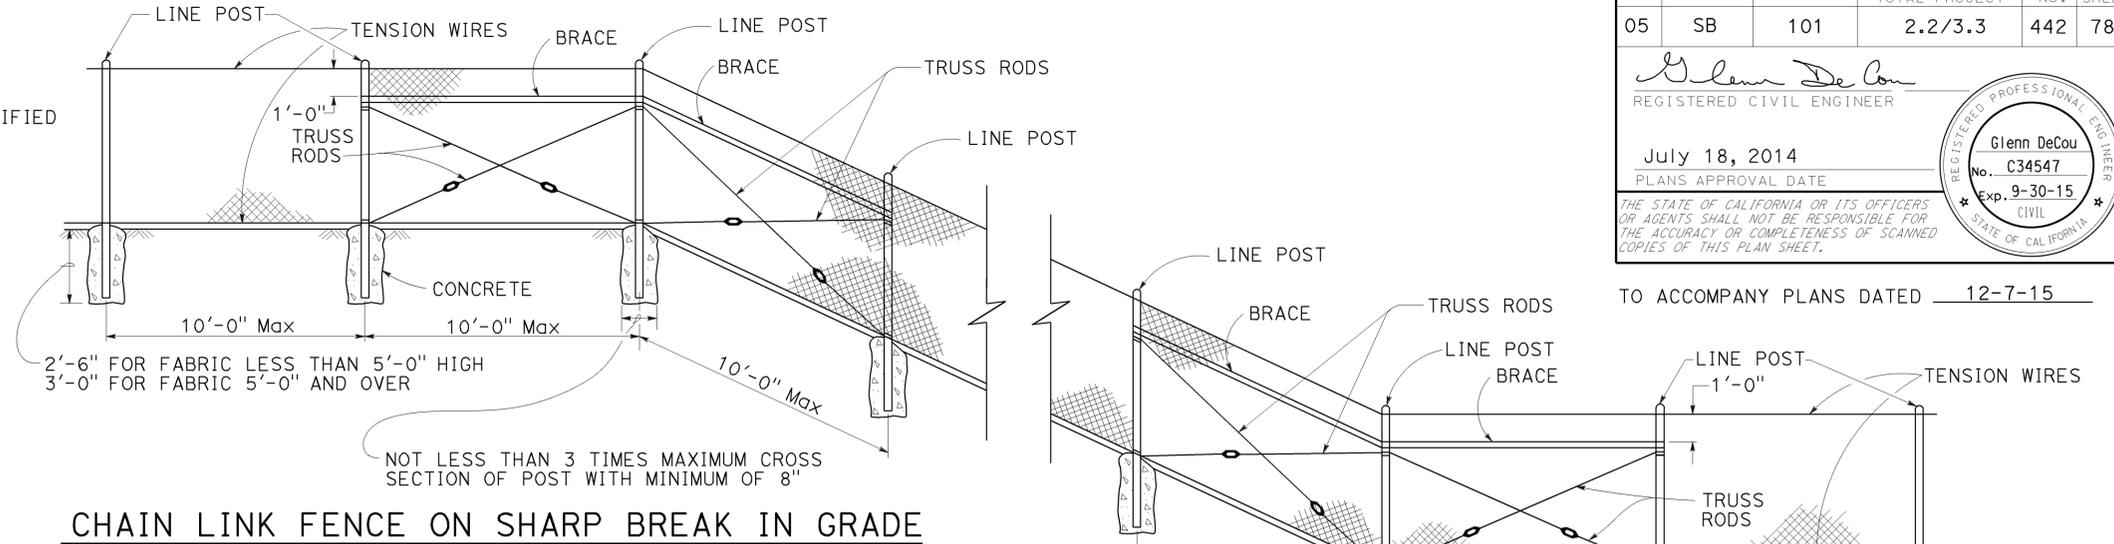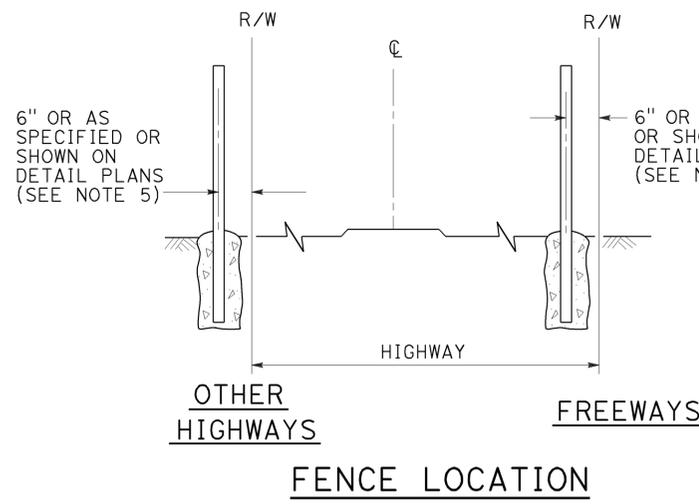

BRACED LINE POST INSTALLATION
Braced line post at intervals not exceeding 1000'

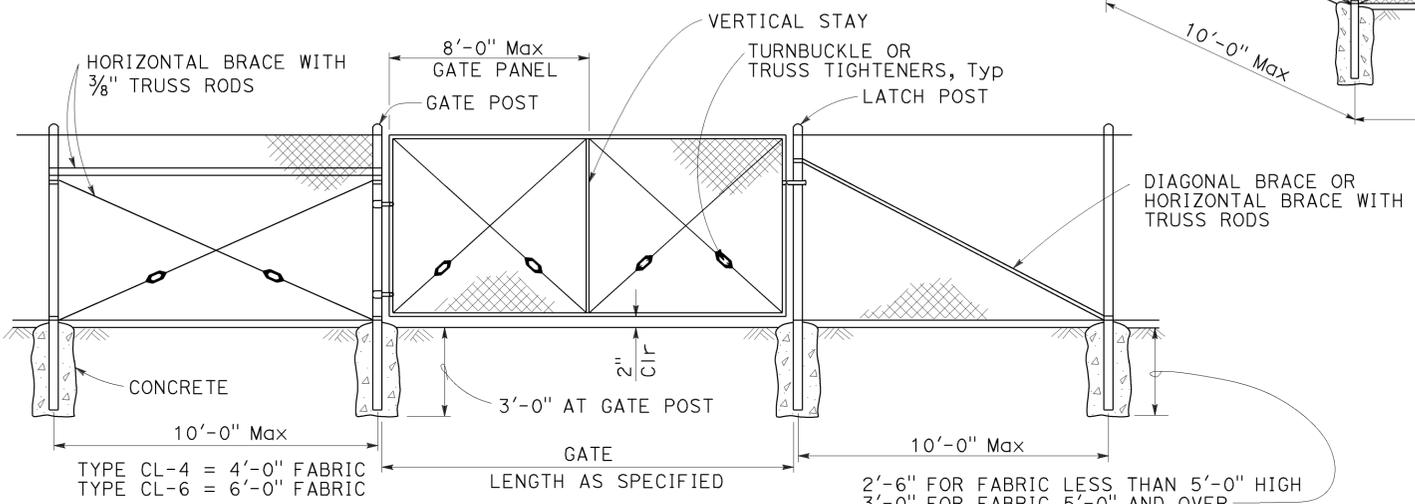


CHAIN LINK GATE INSTALLATION

- NOTES:**
- The table below shows minimum sized posts and braces complying with the specifications. Larger or heavier post and brace sizes may be used upon approval.
 - Sections shown in the tables must also comply with the strength requirements and other provisions of the Specifications.
 - Other sections which comply with the strength requirements and other provisions of the Specifications may be used upon approval.
 - Options exercised shall be uniform on any one project.
 - Offset to be 2'-0" at monument locations, measured at right angles to R/W lines. Taper to achieve offset to be at least 20'-0" long.
 - See Revised Standard Plan RSP A85B for Brace, Stretcher Bar, and Truss Tightener Details.

GATE POST			
FENCE HEIGHT	GATE WIDTHS	ROUND OD PIPE	WEIGHT (lb/ft)
6'-0" AND LESS	UP THRU 6'-0"	2.875"	5.80
	OVER 6'-0" THRU 12'-0"	4.500"	10.80
	OVER 12'-0" THRU 18'-0"	5.563"	14.63
OVER 6'-0" TO 8'-0" Max	OVER 18'-0" TO 24'-0" Max	6.625"	18.99
	UP THRU 6'-0"	3.500"	7.58
	OVER 6'-0" THRU 12'-0"	5.563"	14.63
	OVER 12'-0" THRU 18'-0"	6.625"	18.99
	OVER 18'-0" TO 24'-0" Max	8.625"	28.58

Above post dimensions and weights are minimums. Larger sizes may be used upon approval.

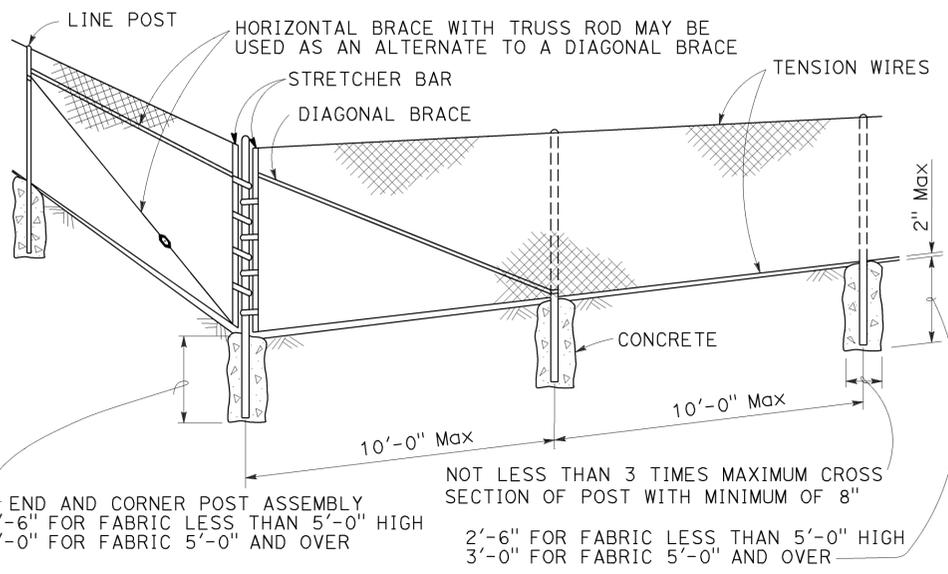

TYPICAL MEMBER DIMENSIONS (See Notes)										
FENCE HEIGHT	LINE POSTS				END, LATCH AND CORNER POSTS		BRACES			
	ROUND OD PIPE	WEIGHT (lb/ft)	ROLL FORMED		ROUND OD PIPE	WEIGHT (lb/ft)	ROUND OD PIPE	WEIGHT (lb/ft)	ROLL FORMED	
			SECTION	WEIGHT (lb/ft)					SECTION	WEIGHT (lb/ft)
6'-0" AND LESS	1.900"	2.72	1.875" x 1.625"	1.85	2.375"	3.65	1.66"	2.27	1.625" x 1.25"	1.35
OVER 6'-0" TO 8'-0" Max	2.375"	3.65	2.25" x 1.70"	2.78	2.875"	5.80	1.66"	2.27	1.625" x 1.25"	1.35

STATE OF CALIFORNIA
DEPARTMENT OF TRANSPORTATION
CHAIN LINK FENCE
NO SCALE

RSP A85 DATED JULY 18, 2014 SUPERSEDES STANDARD PLAN A85
DATED MAY 20, 2011 - PAGE 112 OF THE STANDARD PLANS BOOK DATED 2010.


REVISED STANDARD PLAN RSP A85

2010 REVISED STANDARD PLAN RSP A85


DIST	COUNTY	ROUTE	POST MILES TOTAL PROJECT	SHEET NO.	TOTAL SHEETS
05	SB	101	2.2/3.3	443	786

Glenn DeCou
 REGISTERED CIVIL ENGINEER
 October 19, 2012
 PLANS APPROVAL DATE
 THE STATE OF CALIFORNIA OR ITS OFFICERS OR AGENTS SHALL NOT BE RESPONSIBLE FOR THE ACCURACY OR COMPLETENESS OF SCANNED COPIES OF THIS PLAN SHEET.


REGISTERED PROFESSIONAL ENGINEER
 Glenn DeCou
 No. C34547
 Exp. 9-30-13
 CIVIL
 STATE OF CALIFORNIA

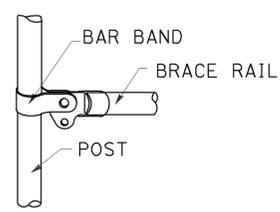

BRACE RAIL

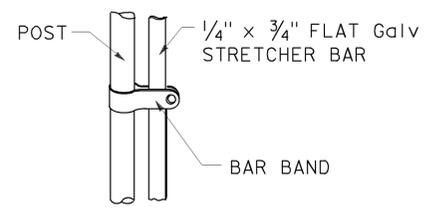

STRETCHER BAR

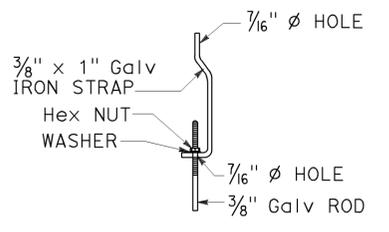


TRUSS TIGHTENER


NOTES:

1. All material for abutment connection to be galvanized.
2. The chain link fabric shall be replaced by barbed wire strands at 12" maximum centers between the double posts.
3. When the width of the culvert makes it necessary to anchor a post to the top of the culvert, a cast iron shoe or other device approved by the Engineer shall be used.
4. Fencing over stream and around headwall may also use Barbed Wire or Wire Mesh fencing with either wood post or steel post installation.
5. See Standard Plan A85 for Chain Link fence dimensions. See Standard Plan A86 for Barbed Wire and Wire Mesh fence dimensions and for wood post and steel post installation.


TO ACCOMPANY PLANS DATED 12-7-15

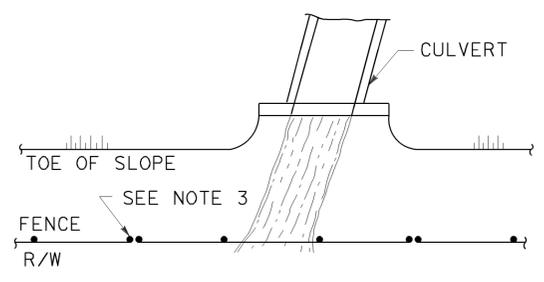

PLAN

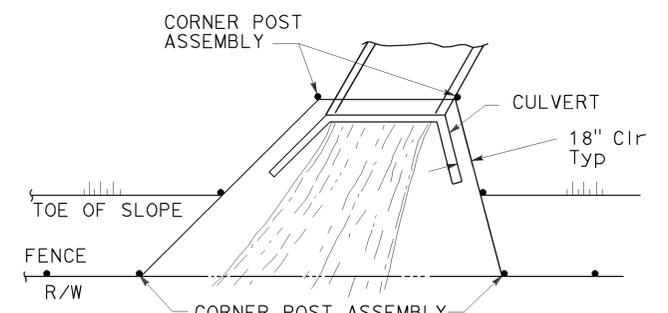


PLAN

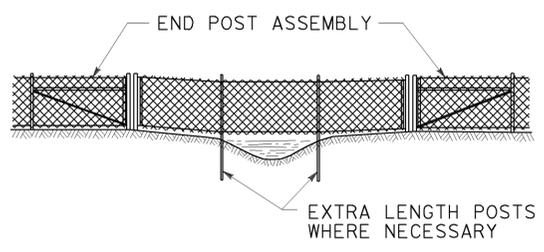

ELEVATION


INSTALLATION OVER STREAM

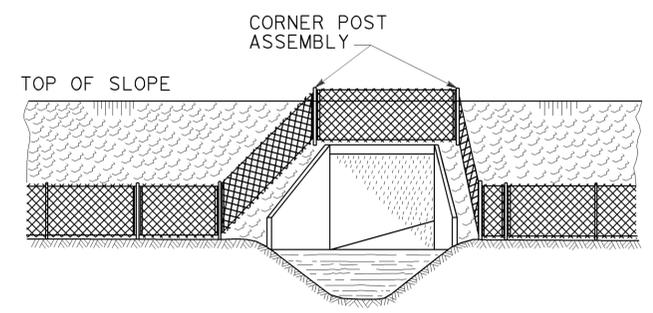


ELEVATION

INSTALLATION AROUND HEADWALL


See Note 4

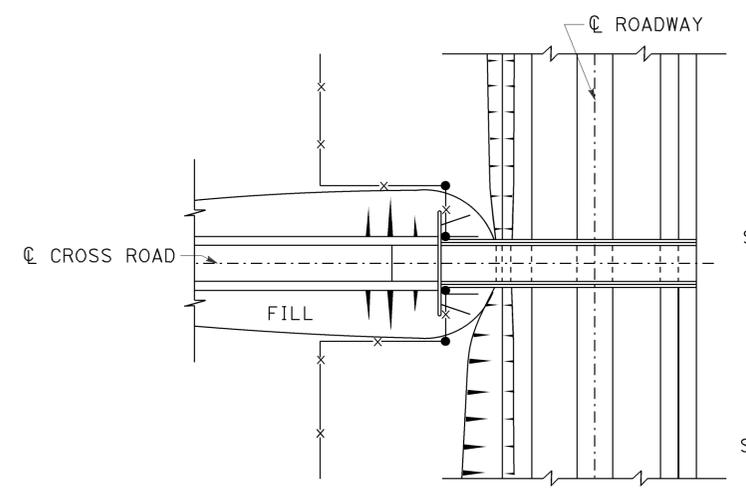

PLAN OF ROADWAY - OVERCROSSING

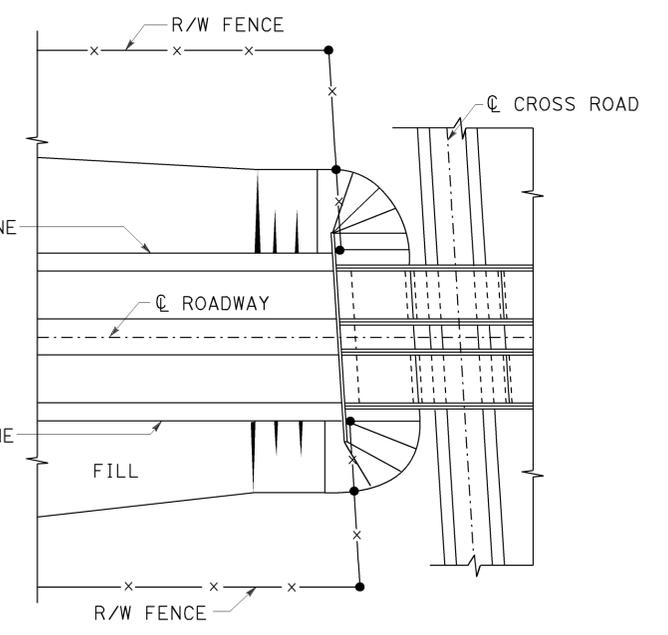

PLAN OF ROADWAY - UNDERCROSSING

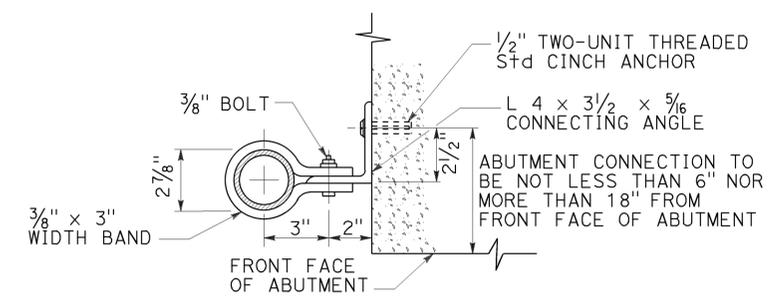

ABUTMENT CONNECTION

TYPICAL INSTALLATION AT BRIDGES

ABUTMENT CONNECTION TO BE NOT LESS THAN 6" NOR MORE THAN 18" FROM FRONT FACE OF ABUTMENT

STATE OF CALIFORNIA
DEPARTMENT OF TRANSPORTATION

CHAIN LINK FENCE DETAILS

NO SCALE

RSP A85B DATED OCTOBER 19, 2012 SUPERSEDES STANDARD PLAN A85B DATED MAY 20, 2011 - PAGE 114 OF THE STANDARD PLANS BOOK DATED 2010.

REVISED STANDARD PLAN RSP A85B

2010 REVISED STANDARD PLAN RSP A85B


Dist	COUNTY	ROUTE	POST MILES TOTAL PROJECT	SHEET No.	TOTAL SHEETS
05	SB	101	2.2/3.3	444	786

Raymond Don Tsztsoo
 REGISTERED CIVIL ENGINEER
 October 19, 2012
 PLANS APPROVAL DATE


REGISTERED PROFESSIONAL ENGINEER
 Raymond Don Tsztsoo
 No. C37332
 Exp. 6-30-14
 CIVIL
 STATE OF CALIFORNIA

THE STATE OF CALIFORNIA OR ITS OFFICERS OR AGENTS SHALL NOT BE RESPONSIBLE FOR THE ACCURACY OR COMPLETENESS OF SCANNED COPIES OF THIS PLAN SHEET.


TO ACCOMPANY PLANS DATED 12-7-15

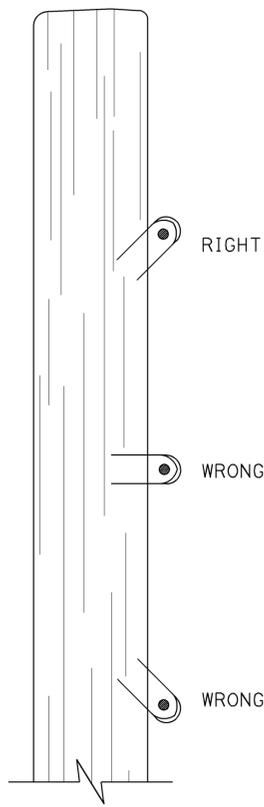

DRIVE STAPLES AT ANGLE

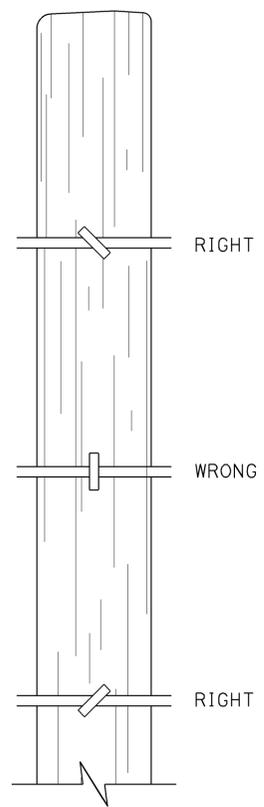


DO NOT DRIVE STAPLES PARALLEL TO SIDE OF POST

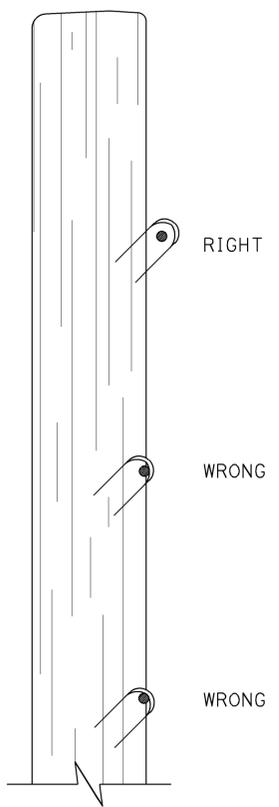


LEAVE WIRE LOOSE IN STAPLE

LINE POST STAPLING DETAILS


(Apply to rectangular/square and round posts)
Do not staple vertical wire in wire mesh.

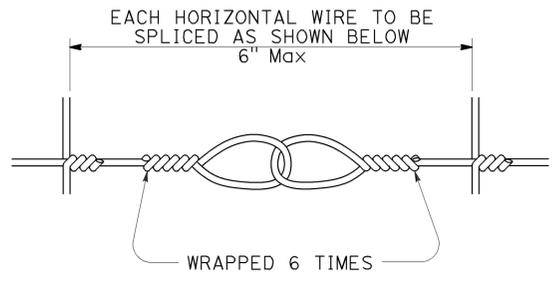

SPLICE DETAIL FOR BARBED WIRE/WIRE MESH FENCE

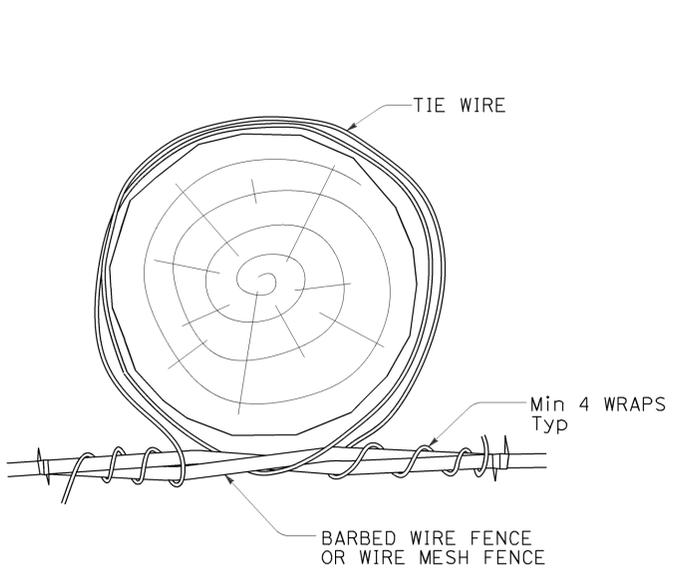


OPTION A

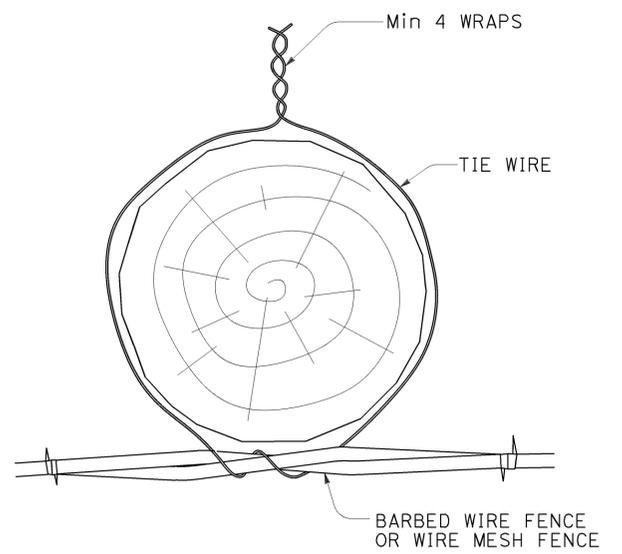

OPTION B

LINE POST WIRE TIE OPTION DETAILS

(Option details also apply to rectangular/square posts)

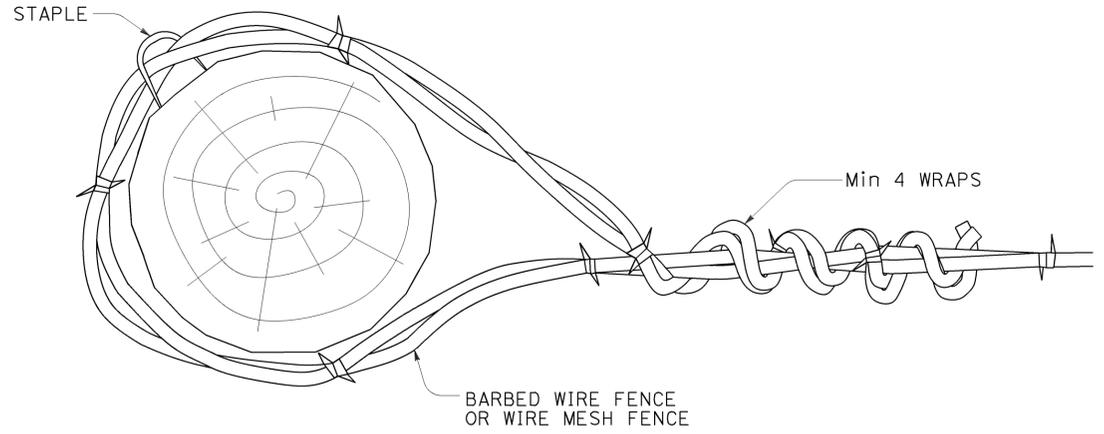

END, LATCH, PULL, AND CORNER POST DETAIL

(Also applies to rectangular/square posts)

STATE OF CALIFORNIA
DEPARTMENT OF TRANSPORTATION

BARBED WIRE AND WIRE MESH FENCE - MISCELLANEOUS DETAILS



NO SCALE

RSP A86D DATED OCTOBER 19, 2012 SUPPLEMENTS THE STANDARD PLANS BOOK DATED 2010.


REVISED STANDARD PLAN RSP A86D

2010 REVISED STANDARD PLAN RSP A86D

TO ACCOMPANY PLANS DATED 12-7-15

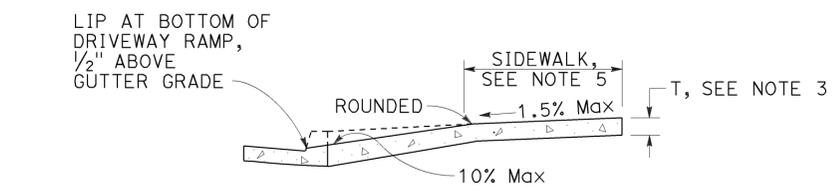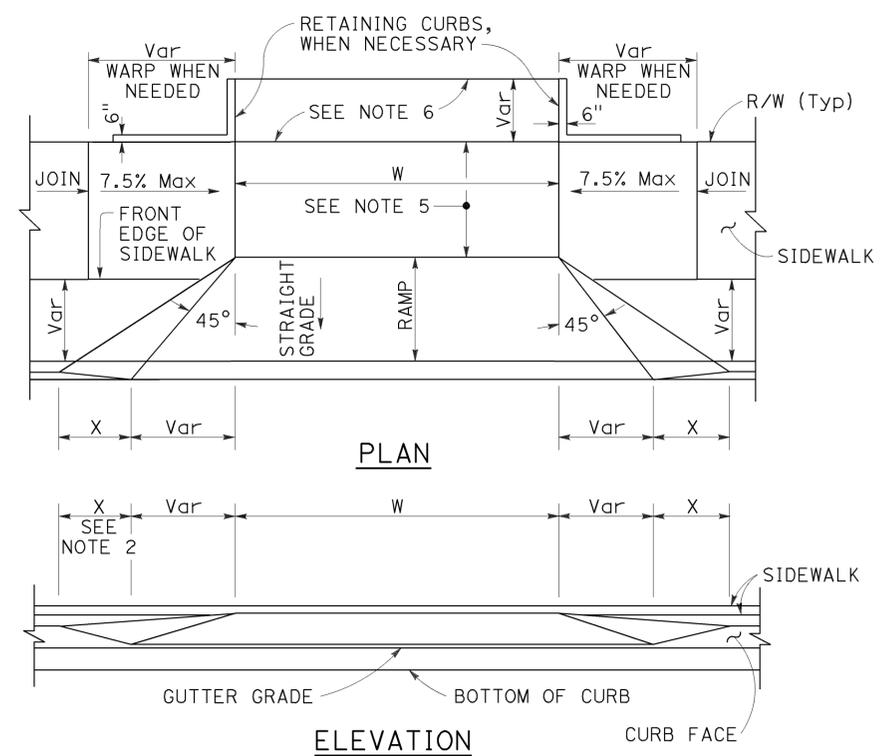

CASE A
Typical driveway, sidewalk not depressed

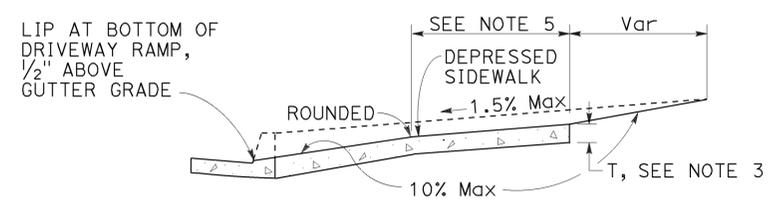

CASE B
Driveway with depressed sidewalk

SECTIONS


TABLE A

CURB TYPE	DIMENSIONS			
	"H1"	"H2"	"W1"	"W2"
A1-6	1'-2"	6"	7 1/2"	1 1/2"
A1-8	1'-4"	8"	8"	2"
A2-6	1'-0"	6"	2'-7 1/2"	1 1/2"
A2-8	1'-2"	8"	2'-8"	2"
A3-6	6"	5"	7 1/4"	1 1/4"
A3-8	8"	7"	7 3/4"	1 3/4"
B1-4	1'-0"	4"	7 1/2"	2 1/2"
B1-6	1'-2"	6"	9"	4"
B2-4	10"	4"	2'-7 1/2"	2 1/2"
B2-6	1'-0"	6"	2'-9"	4"
B3-4	4"	3"	7"	2"
B3-6	6"	5"	8 1/2"	3 1/2"
D-4	10"	4"	1'-6"	1'-1"
D-6	1'-0"	6"	2'-2"	1'-9"


CURB QUANTITIES

TYPE	CUBIC YARDS PER LINEAR FOOT
A1-6	0.02585
A1-8	0.03084
A2-6	0.05903
A2-8	0.06379
A3-6	0.01036
A3-8	0.01435
B1-4	0.02185
B1-6	0.02930
B2-4	0.05515
B2-6	0.06171
B3-4	0.00641
B3-6	0.01074
B4	0.05709
D-4	0.04083
D-6	0.06804
E	0.06661


DRIVEWAYS

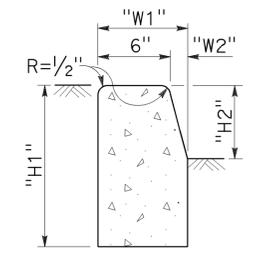


TYPE A1 CURBS
See Table A

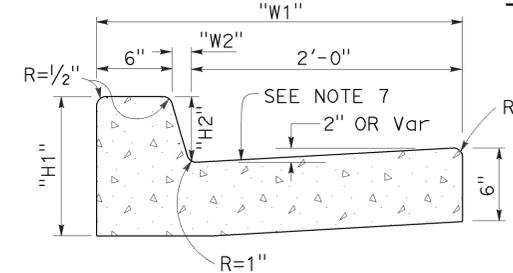


TYPE A2 CURBS
See Table A

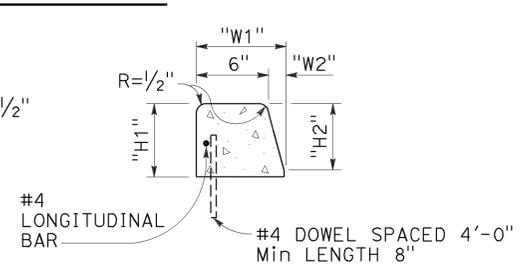


TYPE A3 CURBS
Superimposed on existing pavement
See Table A

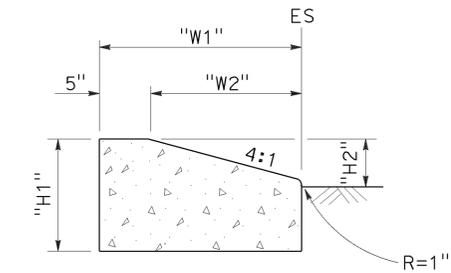


TYPE D CURBS
See Table A

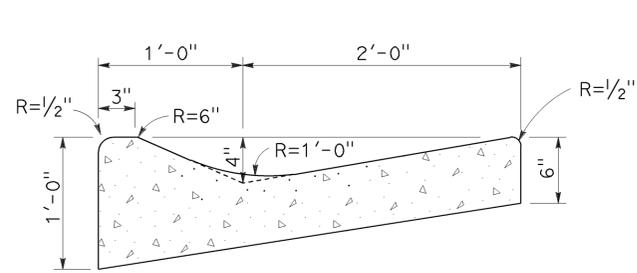


TYPE E CURB

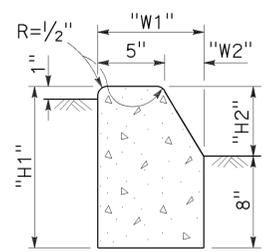


TYPE B1 CURBS
See Table A

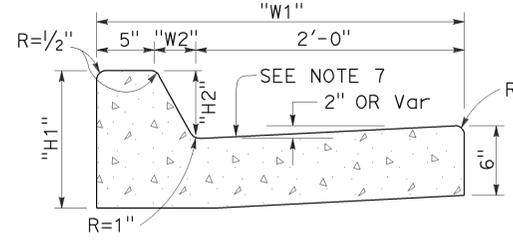


TYPE B2 CURBS
See Table A

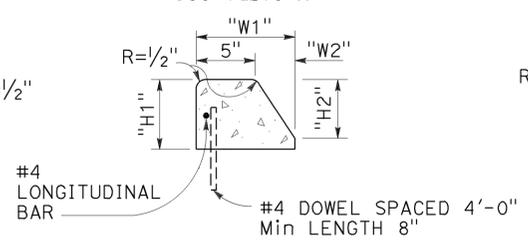

TYPE B3 CURBS
Superimposed on existing pavement
See Table A

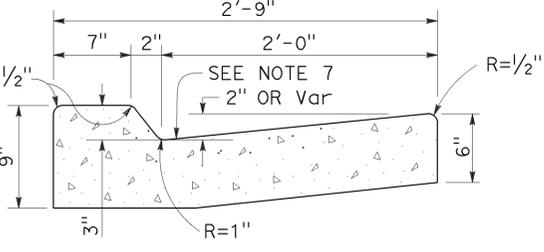

TYPE B4 CURBS

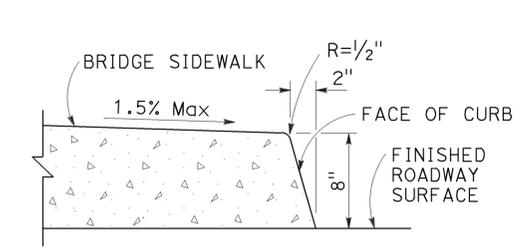

TYPE H CURB
On Bridges

CURBS

- NOTES:**
- Case A driveway section typically applies.
 - X=3'-0" except for curb heights over 10" where 4:1 slopes shall be used on curb slope.
 - Sidewalk and ramp thickness "T" at driveway shall be 4" for residential and 6" for commercial.
 - Difference in slope of the driveway ramp and the slope of a line between the gutter and a point on the roadway 5'-0" from gutter line shall not exceed 15%. Reduce driveway ramp slope, not gutter slope, where required.

- Minimum width of clear passageway for sidewalk shall be 4'-2".
- Retaining curbs and acquisition of construction easement may be necessary for narrow sidewalks or curb heights in excess of 6".
- Across the pedestrian route at curb ramp locations, the gutter pan slope shall not exceed 1" of depth for each 2'-0" of width.

STATE OF CALIFORNIA
DEPARTMENT OF TRANSPORTATION

CURBS AND DRIVEWAYS

NO SCALE


RSP A87A DATED JULY 19, 2013 SUPERSEDES STANDARD PLAN A87A
DATED MAY 20, 2011 - PAGE 119 OF THE STANDARD PLANS BOOK DATED 2010.

REVISED STANDARD PLAN RSP A87A


2010 REVISED STANDARD PLAN RSP A87A




TO ACCOMPANY PLANS DATED 12-7-15

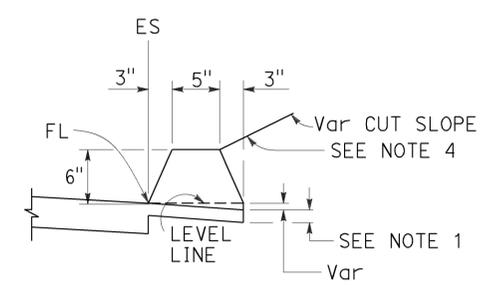


TYPE A
See Note 3

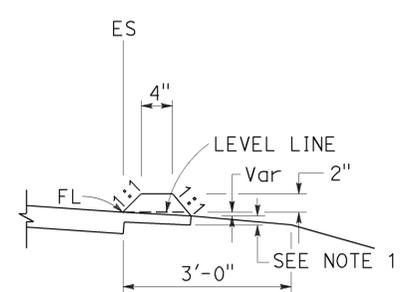


TYPE C

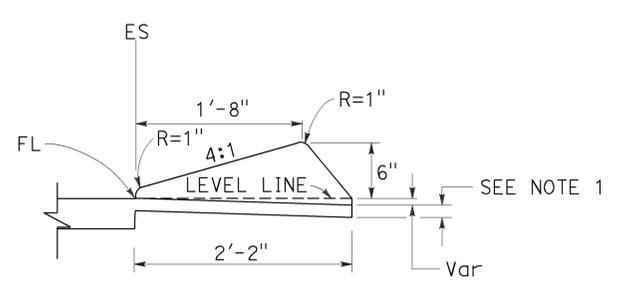

TYPE D

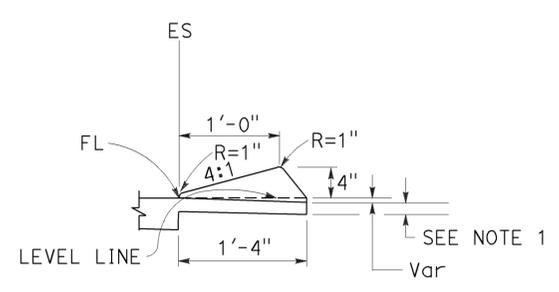


TYPE E

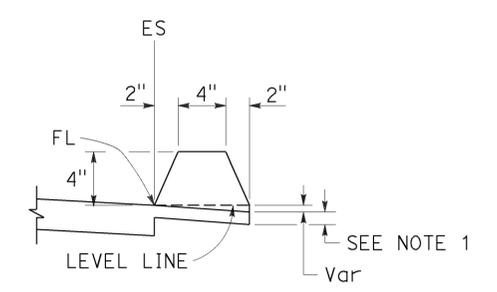


TYPE F
See Note 5


DIKES

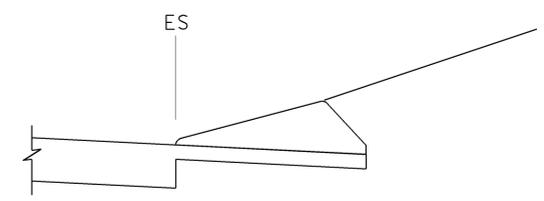


CASE C-1
Cut Slope

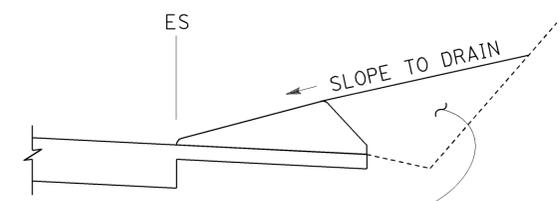

CASE C-2
Cut Slope

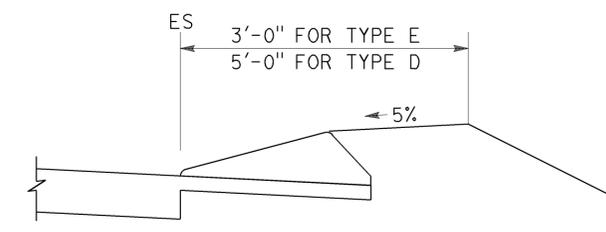

CASE F

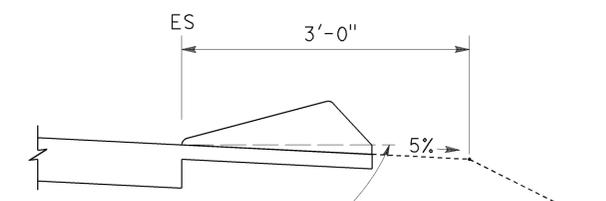

CASE R
See Note 2

TYPE D AND E BACKFILL DETAILS

NOTES:

- For HMA shoulders only, extend top layer of HMA placed on the shoulder under dike with no joint at the ES. For projects with OGFC shoulders, do not extend OGFC under dike. See project plans for modified dike detail.
- Case R applies to retrofit only projects where restrictive conditions do not provide enough width for Case F backfill.
- Type A dike only to be used where restrictive slope conditions do not provide enough width to use Type D or Type E dike.
- Fill and compact with excavated material to top of dike.
- Use Type F dike, where dike is required with guard railing installations. See Revised Standard Plan RSP A77N4 for dike positioning details.

DIKE QUANTITIES

TYPE	CUBIC YARDS PER LINEAR FOOT
A	0.0135
C	0.0038
D	0.0293
E	0.0130
F	0.0066

Quantities based on 5% cross slope.

STATE OF CALIFORNIA
DEPARTMENT OF TRANSPORTATION

HOT MIX ASPHALT DIKES

NO SCALE

RSP A87B DATED JULY 19, 2013 SUPERSEDES STANDARD PLAN A87B
DATED MAY 20, 2011 - PAGE 120 OF THE STANDARD PLANS BOOK DATED 2010.


REVISED STANDARD PLAN RSP A87B

2010 REVISED STANDARD PLAN RSP A87B


Dist	COUNTY	ROUTE	POST MILES TOTAL PROJECT	SHEET No.	TOTAL SHEETS
05	SB	101	2.2/3.3	447	786

H. David Cordova
 REGISTERED CIVIL ENGINEER
 No. C41957
 Exp. 3-31-16
 CIVIL
 STATE OF CALIFORNIA


July 3, 2015
 PLANS APPROVAL DATE
 THE STATE OF CALIFORNIA OR ITS OFFICERS OR AGENTS SHALL NOT BE RESPONSIBLE FOR THE ACCURACY OR COMPLETENESS OF SCANNED COPIES OF THIS PLAN SHEET.

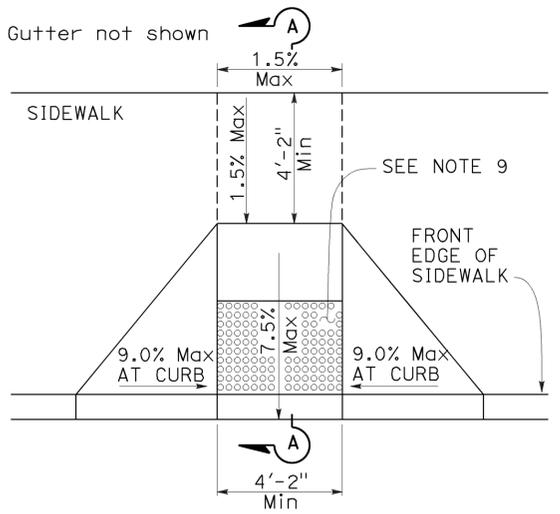


CASE A

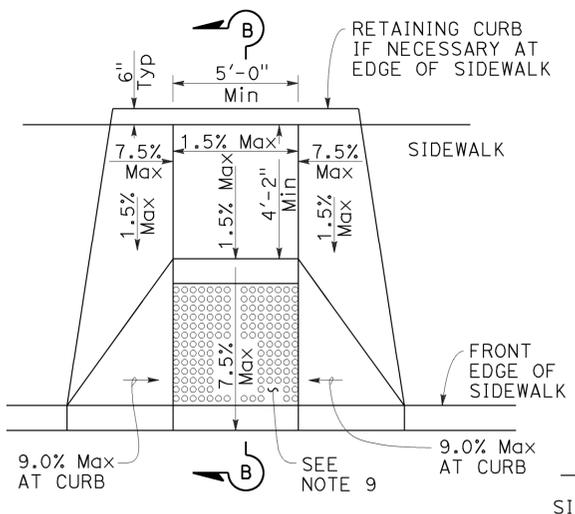


CASE B

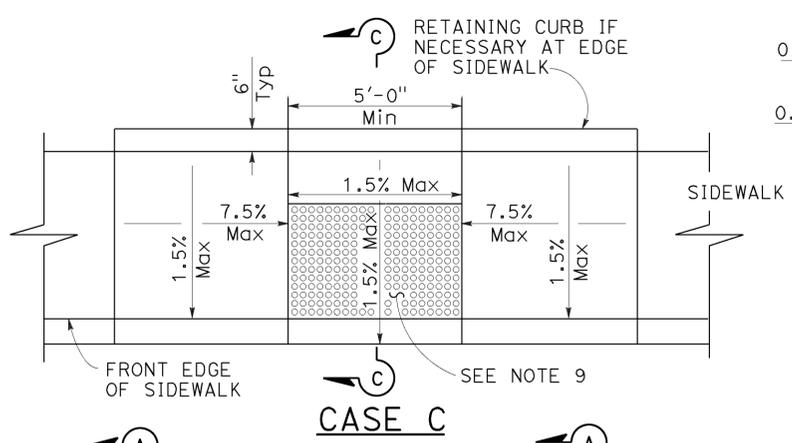


CASE C

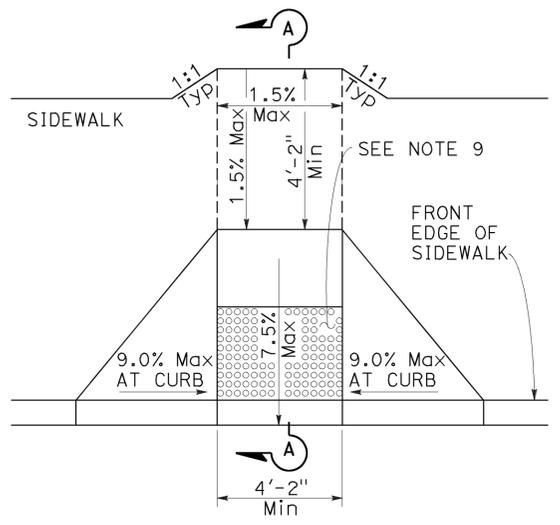


CASE D

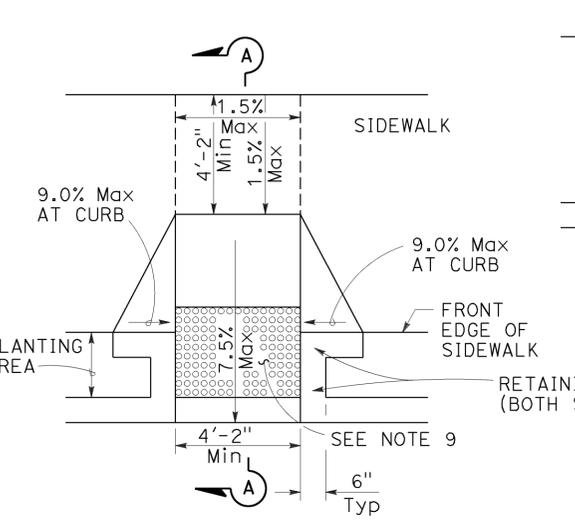


CASE E

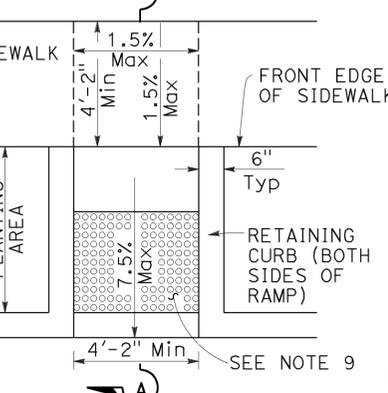

CASE F

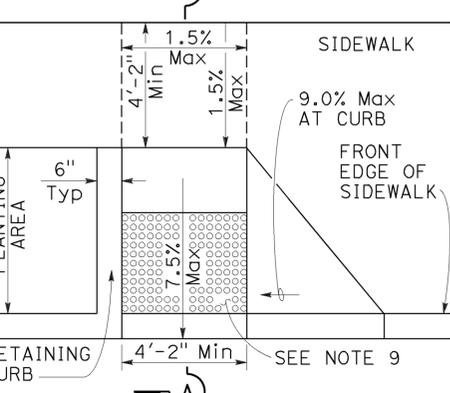


CASE G

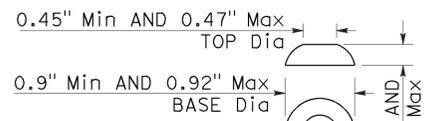


RAISED TRUNCATED DOME

NOTES:


- As site conditions dictate, Case A through Case G curb ramps may be used for corner installations similar to those shown in Detail A and Detail B. The case of curb ramps used in Detail A do not have to be the same. Case A through Case G curb ramps also may be used at mid block locations, as site conditions dictate.
- If distance from curb to back of sidewalk is too short to accommodate ramp and 4'-2" platform (landing) as shown in Case A, the sidewalk may be depressed longitudinally as in Case B, or C or may be widened as in Case D.
- When ramp is located in center of curb return, crosswalk configuration must be similar to that shown for Detail B.
- As site conditions dictate, the retaining curb side and the flared side of the Case G ramp shall be constructed in reversed position.
- If located on a curve, the sides of the ramp need not be parallel, but the minimum width of the ramp shall be 4'-2".
- Side slope of ramp flares vary uniformly from a maximum of 9.0% at curb to conform with longitudinal sidewalk slope adjacent to top of the ramp, except in Case C and Case F.
- Transitions from ramps and landing to walks, gutters or streets shall be flush (no lip) and free of abrupt changes.
- Counter slopes of adjoining gutters and road surfaces immediately adjacent to and within 24 inches of the curb ramp shall not be steeper than 1:20 (5.0%). Gutter pan slope shall not exceed 1" of depth for each 2'-0" of width.
- Curb ramps shall have a detectable warning surface that extends the full width and 3'-0" depth of the ramp. A 4'-0" wide detectable warning surface may be used on a 4'-2" wide curb ramp. Detectable Warning Surfaces shall conform to the requirements in the Standard Specifications.
- Sidewalk and ramp thickness, "T", shall be 3 1/2" minimum.
- Utility pull boxes, manholes, vaults and all other utility facilities within the boundaries of the curb ramp will be relocated or adjusted to grade by the owner prior to, or in conjunction with, curb ramp construction.
- Detectable warning surface may have to be cut to allow removal of utility covers while maintaining full detectable warning width and depth.

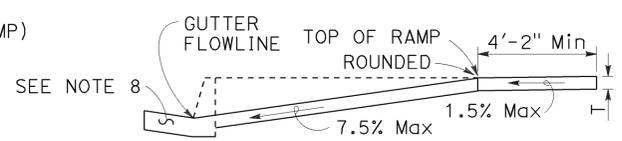

SECTION A-A

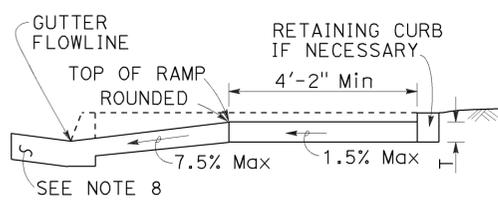

SECTION B-B

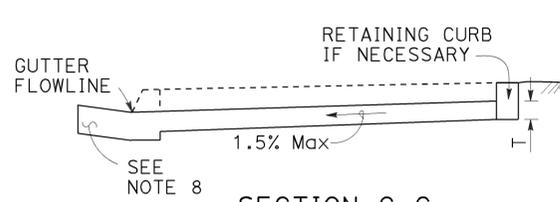


SECTION C-C



**RAISED TRUNCATED DOME PATTERN (IN-LINE)
DETECTABLE WARNING SURFACE**


See Note 9

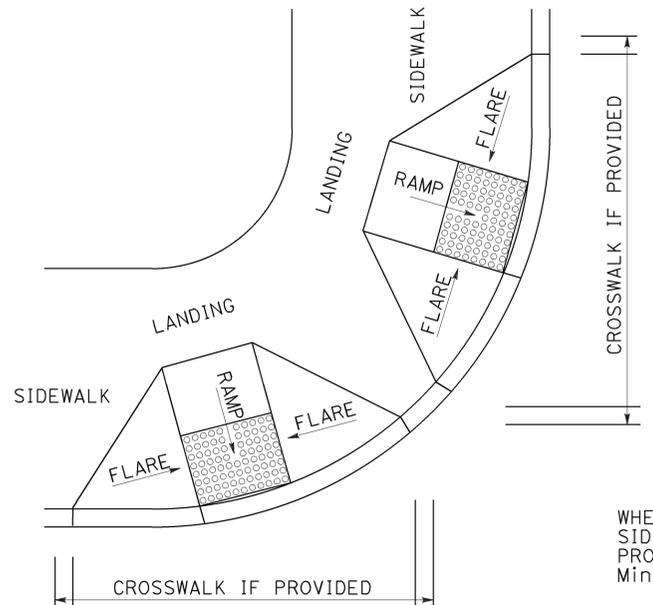

DETAIL A

**TYPICAL TWO-RAMP
CORNER INSTALLATION**


See Note 1

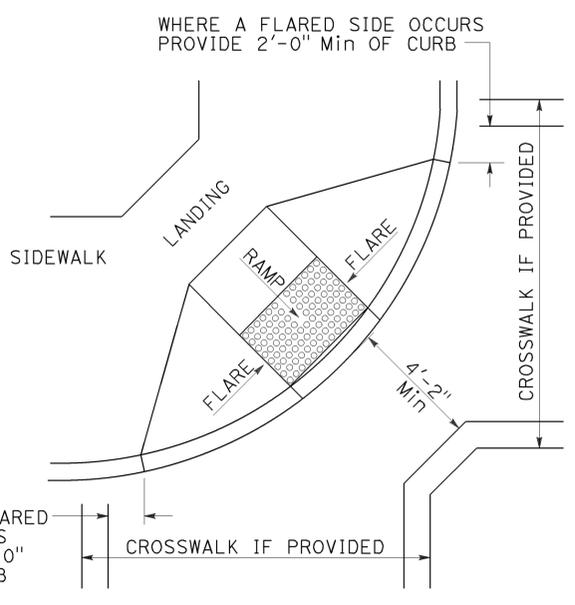

DETAIL B

**TYPICAL ONE-RAMP
CORNER INSTALLATION**

See Notes 1 and 3

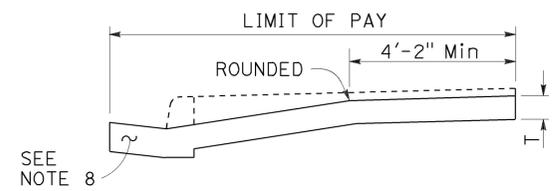

RETROFIT PAY LIMITS

Existing curb and sidewalk

STATE OF CALIFORNIA
DEPARTMENT OF TRANSPORTATION
CURB RAMP DETAILS
NO SCALE

RSP A88A DATED JULY 3, 2015 SUPERSEDES RSP A88A DATED MARCH 21, 2014 AND RSP A88A DATED JULY 19, 2013 AND STANDARD PLAN A88A DATED MAY 20, 2011 - PAGE 121 OF THE STANDARD PLANS BOOK DATED 2010.



2010 REVISED STANDARD PLAN RSP A88A

Dist	COUNTY	ROUTE	POST MILES TOTAL PROJECT	SHEET No.	TOTAL SHEETS
05	SB	101	2.2/3.3	448	786

H. David Cordova
 REGISTERED CIVIL ENGINEER
 July 3, 2015
 PLANS APPROVAL DATE
THE STATE OF CALIFORNIA OR ITS OFFICERS OR AGENTS SHALL NOT BE RESPONSIBLE FOR THE ACCURACY OR COMPLETENESS OF SCANNED COPIES OF THIS PLAN SHEET.

2010 REVISED STANDARD PLAN RSP A88B





Gutter not shown

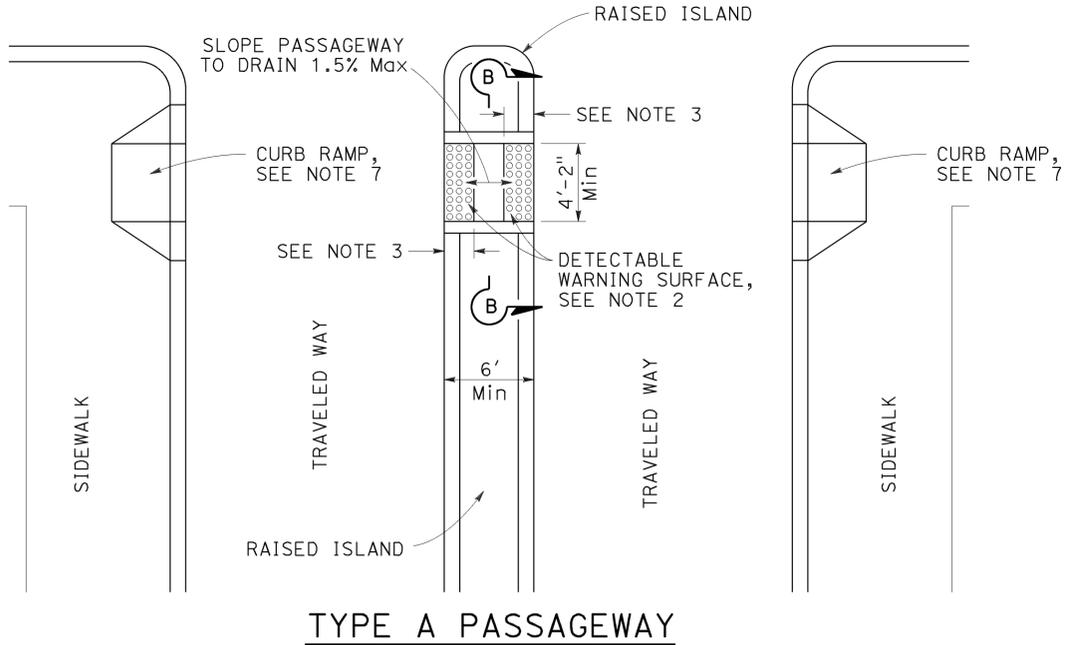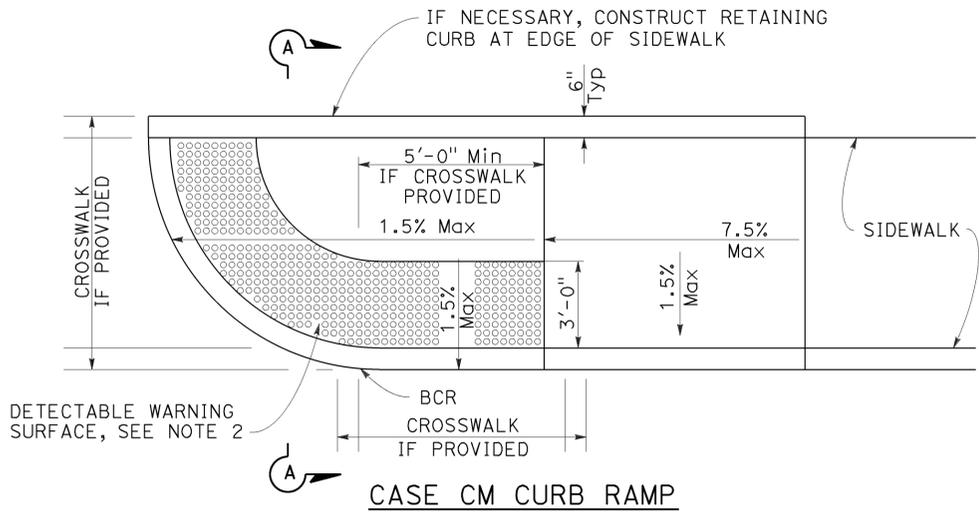

NOTES:

1. Sidewalk, ramp and passageway thickness, "t", shall be 3 1/2" minimum.
2. For details of detectable warning surfaces, see Revised Standard Plan RSP A88A.
3. Where an island passageway length is greater than or equal to 6'-0", but less than 8'-0", each detectable warning surface shall extend the full width and 2'-0" depth of the passageway length. Where an island passageway length is greater than or equal to 8'-0", each detectable warning surface shall extend the full width and 3'-0" depth of the passageway length. A 4'-0" wide detectable warning surface may be used on a 4'-2" wide island passageway.
4. Transitions from ramps to walks, gutters or streets shall be flush (no lip) and free of abrupt changes.
5. Utility pull boxes, manholes, vaults and all other utility facilities within the boundaries of the curb ramp will be relocated or adjusted to grade by the owner prior to, or in conjunction with, curb ramp construction.
6. Detectable warning surface may have to be cut to allow removal of utility covers while maintaining full detectable warning width and depth.
7. For additional curb ramp details, see Revised Standard Plan RSP A88A.

TO ACCOMPANY PLANS DATED 12-7-15

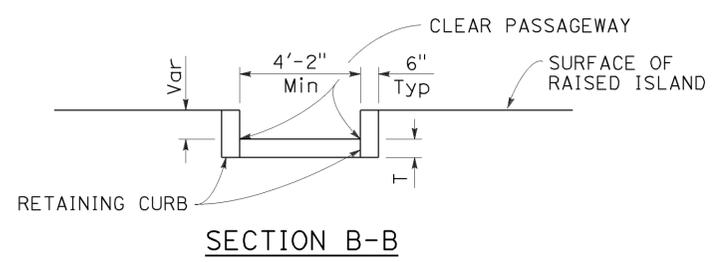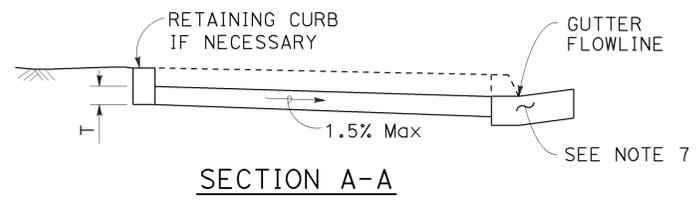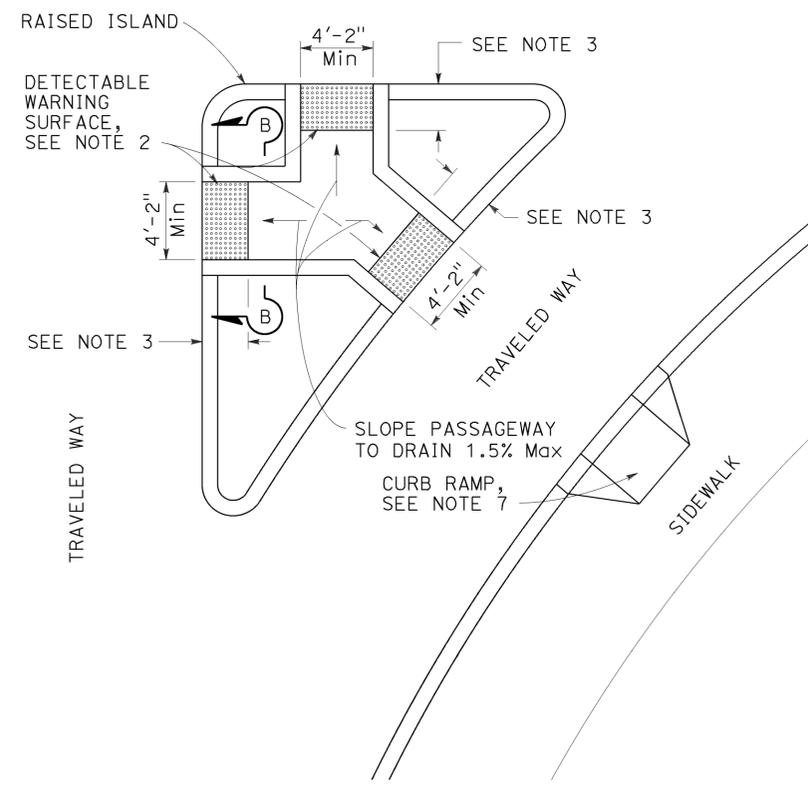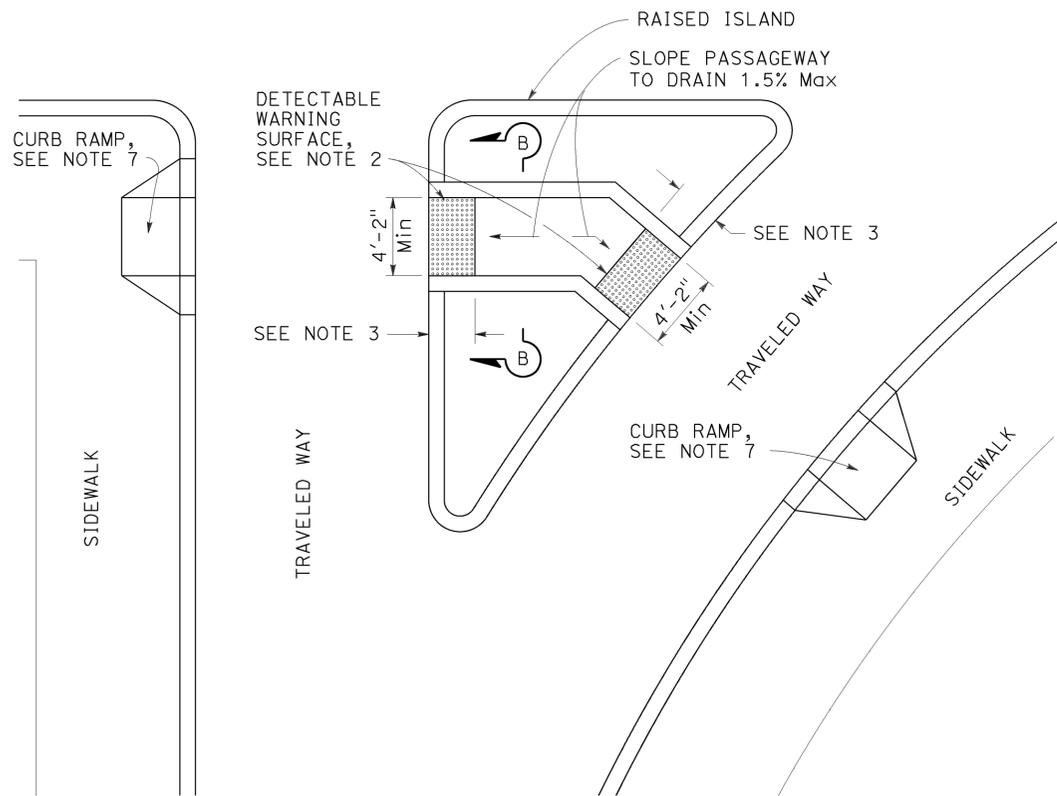

STATE OF CALIFORNIA
 DEPARTMENT OF TRANSPORTATION
CURB RAMP AND ISLAND PASSAGEWAY DETAILS
 NO SCALE

RSP A88B DATED JULY 3, 2015 SUPERSEDES RSP A88B DATED MARCH 21, 2014 AND RSP A88B DATED JULY 19, 2013 AND STANDARD PLAN A88B DATED MAY 20, 2011 - PAGE 122 OF THE STANDARD PLANS BOOK DATED 2010.

REVISED STANDARD PLAN RSP A88B


DIST	COUNTY	ROUTE	POST MILES TOTAL PROJECT	SHEET No.	TOTAL SHEETS
05	SB	101	2.2/3.3	449	786

H. David Cordova
 REGISTERED CIVIL ENGINEER
 No. C41957
 Exp. 3-31-16
 CIVIL
 STATE OF CALIFORNIA


July 3, 2015
 PLANS APPROVAL DATE

THE STATE OF CALIFORNIA OR ITS OFFICERS OR AGENTS SHALL NOT BE RESPONSIBLE FOR THE ACCURACY OR COMPLETENESS OF SCANNED COPIES OF THIS PLAN SHEET.

TO ACCOMPANY PLANS DATED 12-7-15

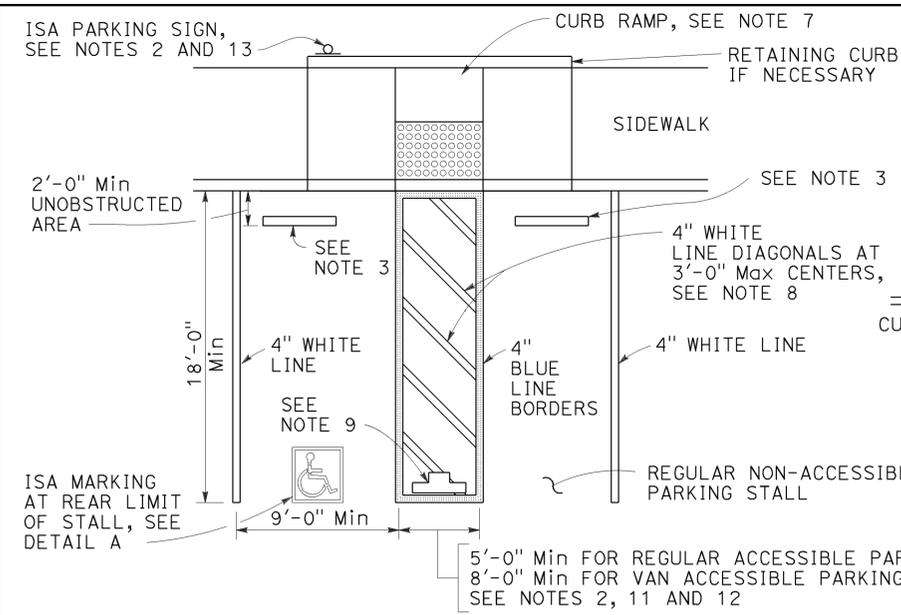


SINGLE PARKING STALL

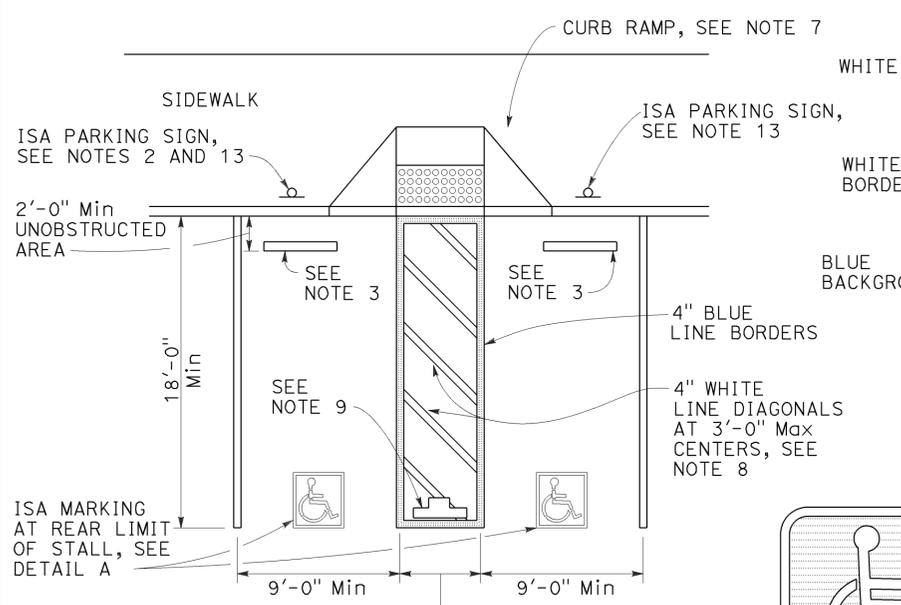


DOUBLE PARKING STALL

TABLE A

TOTAL NUMBER OF PARKING SPACES PROVIDED IN PARKING FACILITY	MINIMUM NUMBER OF REQUIRED ACCESSIBLE PARKING SPACES
1-25	1
26-50	2
51-75	3
76-100	4
101-150	5
151-200	6
201-300	7
301-400	8
401-500	9
501-1000	2 PERCENT OF TOTAL
1001 AND OVER	20 PLUS 1 FOR EACH 100 OR FRACTION THEREOF OVER 1000

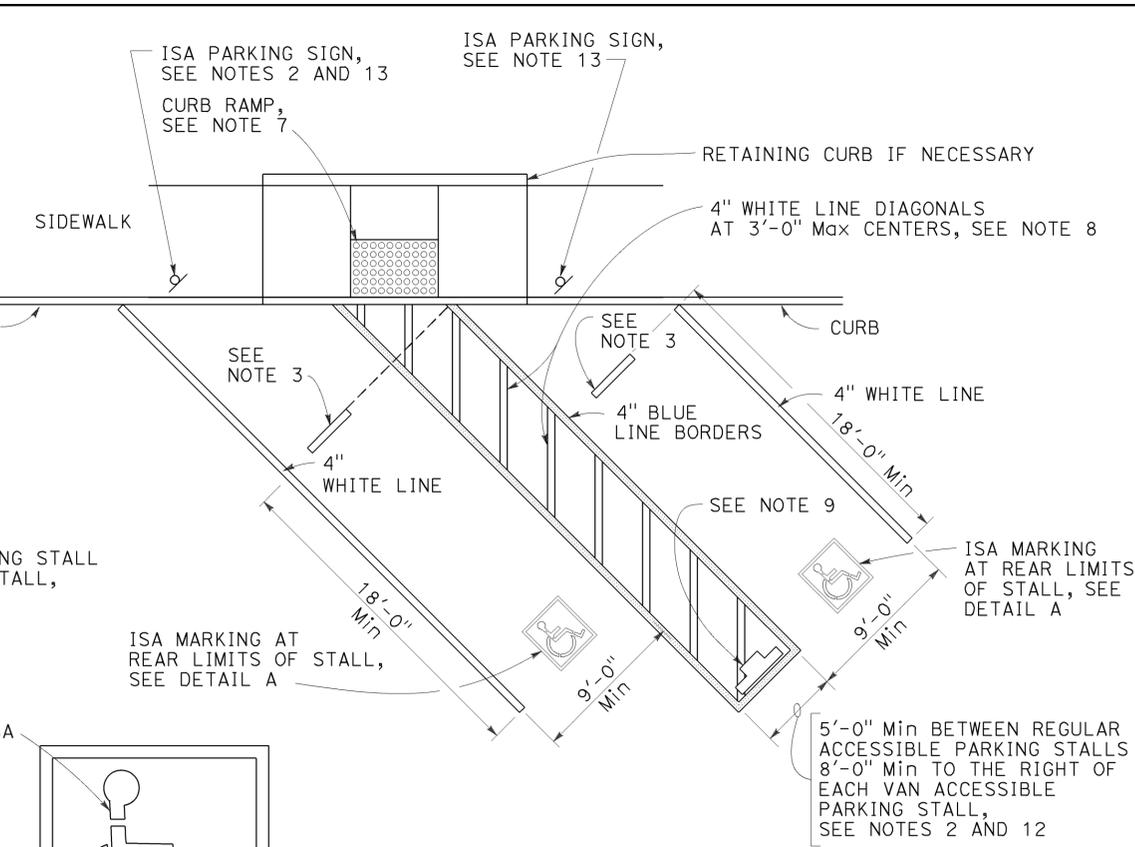

DIAGONAL DOUBLE PARKING STALLS

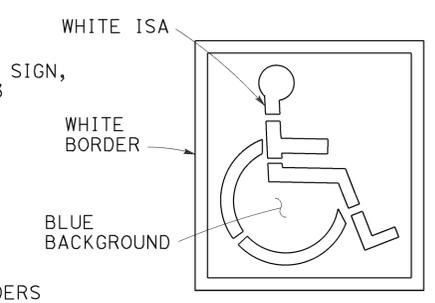

DETAIL A



SIGN R99 (CA)



PLAQUE R99B (CA)

SIGN R99 (CA) with PLAQUE R99B (CA)
See Note 6



SIGN R99C (CA)
See Note 6



SIGN R100B (CA)
See Note 10



SIGN R7-8b
See Notes 2 and 6

NOTES:

1. Accessible parking spaces serving a particular building shall be located on the shortest accessible route of travel from adjacent parking to an accessible entrance. In parking facilities that do not serve a particular building, accessible parking shall be located on the shortest accessible route of travel to an accessible pedestrian entrance of the parking facility.
2. One in every six accessible off-street parking stalls, but not less than one, shall be served by an accessible aisle of 8'-0" minimum width and shall be signed van accessible. The R7-8b sign shall be mounted below the R99B (CA) plaque or the R99C (CA) sign.
3. In each parking stall, a curb or parking bumper shall be provided if required to prevent encroachment of vehicles over the required width of walkways. Parking stalls shall be so located that persons with disabilities are not compelled to wheel or walk behind parked vehicles other than their own. For more parking bumper requirements, see the Special Provisions.
4. Parking spaces and access aisles shall be level with surface slopes not exceeding 1.5% in all directions.
5. Table A shall be used to determine the required number of accessible parking stalls in each parking lot or garage.
6. Where Plaque R99B (CA), Sign R99C (CA) or Sign R7-8b are installed, the bottom of the sign or plaque panel shall be a minimum of 7'-0" above the surrounding surface.
7. Curb ramps shall conform to the details shown on Revised Standard Plan RSP A88A.
8. Blue paint, instead of white may be used for marking accessibility aisles in areas where snow may cause white markings to not be visible.
9. The words "NO PARKING", shall be painted in white letters no less than 1'-0" high and located so that it is visible to traffic enforcement officials. See Revised Standard Plan RSP A90B for details of the "NO PARKING" pavement marking.
10. A R100B (CA) sign shall be posted in a conspicuous place at each entrance to off-street parking facilities or immediately adjacent to and visible from each stall. The sign shall include the address where the towed vehicle may be reclaimed and the telephone number of the local traffic law enforcement agency.
11. Where a single (non-van) accessible parking space is provided, the loading and unloading access aisle shall be on the passenger side of the vehicle as the vehicle is going forward into the parking space.
12. Where a van accessible parking space is provided, the loading and unloading access aisle shall be 8'-0" wide minimum, and shall be on the passenger side of the vehicle as the vehicle is going forward into the parking space.
13. Accessible Parking Only Sign shall be Sign R99C (CA) or Sign R99 (CA) with Plaque R99B (CA).

LEGEND

ISA = International Symbol of Accessibility

STATE OF CALIFORNIA
DEPARTMENT OF TRANSPORTATION

ACCESSIBLE PARKING OFF-STREET
NO SCALE

OFF-STREET PARKING SIGNS
(Parking lot or garage)
See Note 6

RSP A90A DATED JULY 3, 2015 SUPERSEDES RSP A90A DATED JULY 19, 2013 AND STANDARD PLAN A90A DATED MAY 20, 2011 - PAGE 123 OF THE STANDARD PLANS BOOK DATED 2010.

REVISED STANDARD PLAN RSP A90A

2010 REVISED STANDARD PLAN RSP A90A


Dist	COUNTY	ROUTE	POST MILES TOTAL PROJECT	SHEET No.	TOTAL SHEETS
05	SB	101	2.2/3.3	450	786

William K. Farnbach
 REGISTERED CIVIL ENGINEER
 July 19, 2013
 PLANS APPROVAL DATE

THE STATE OF CALIFORNIA OR ITS OFFICERS
 OR AGENTS SHALL NOT BE RESPONSIBLE FOR
 THE ACCURACY OR COMPLETENESS OF SCANNED
 COPIES OF THIS PLAN SHEET.


REGISTERED PROFESSIONAL ENGINEER
 William K. Farnbach
 No. C49042
 Exp. 9-30-14
 CIVIL
 STATE OF CALIFORNIA

TO ACCOMPANY PLANS DATED 12-7-15

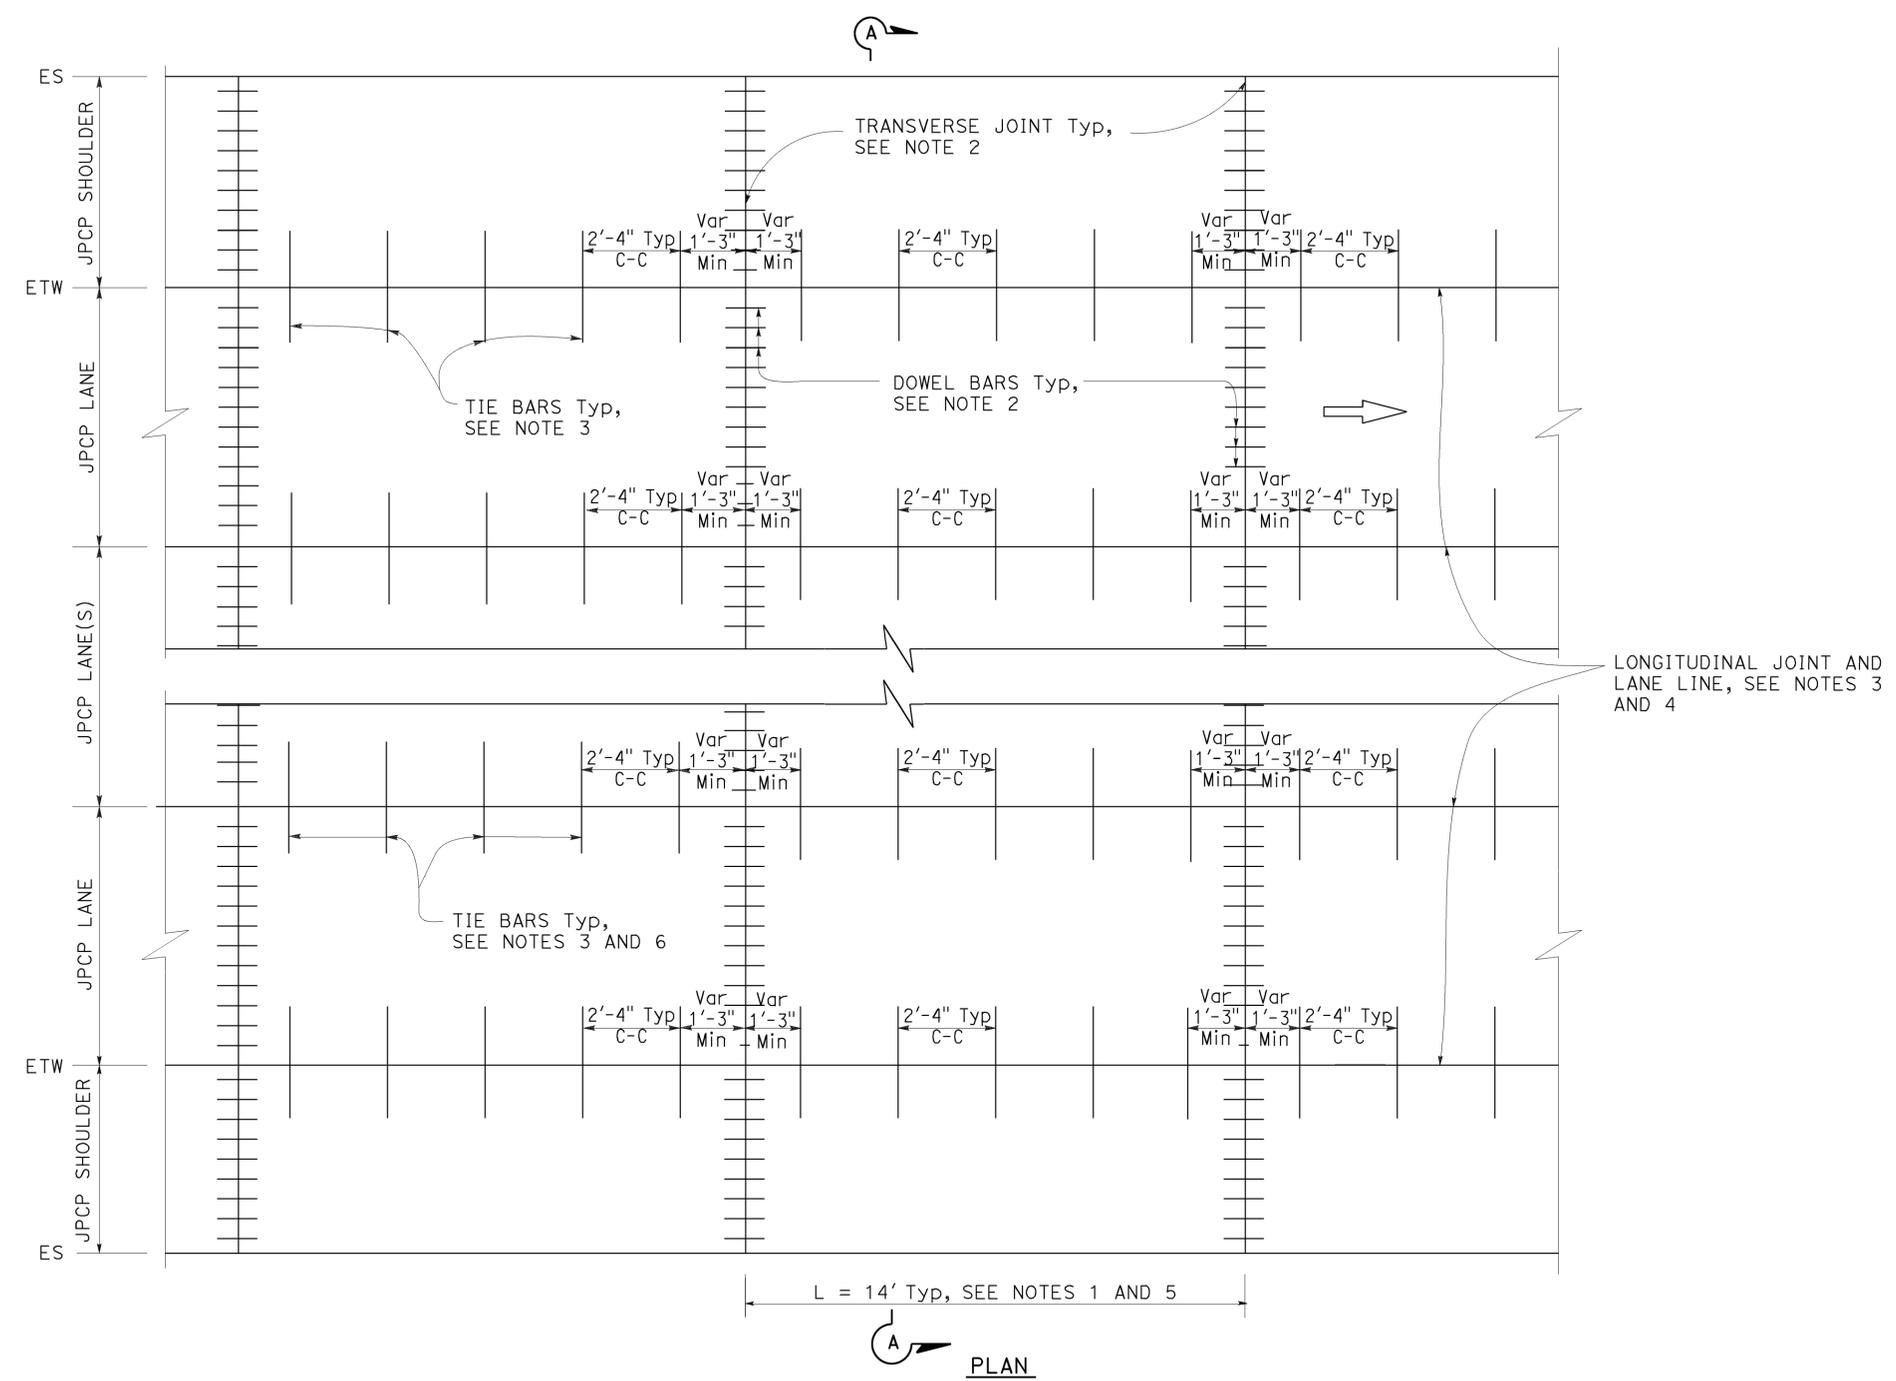

NOTES:

1. Transverse joint spacing may be adjusted to no less than 10' and no more than 14' to conform to bridges, change in pavement type, and hardened concrete pavement.
2. For transverse joint and dowel bar details not shown, see Revised Standard Plan RSP P10.
3. For longitudinal joint and tie bar details not shown, see Revised Standard Plan RSP P15.
4. For additional longitudinal joint layout details, see Revised Standard Plan RSP P18.
5. For joint layout at intersections, see Project Plans.
6. For dowel bars at longitudinal joint. see Revised Standard Plan RSP P18.

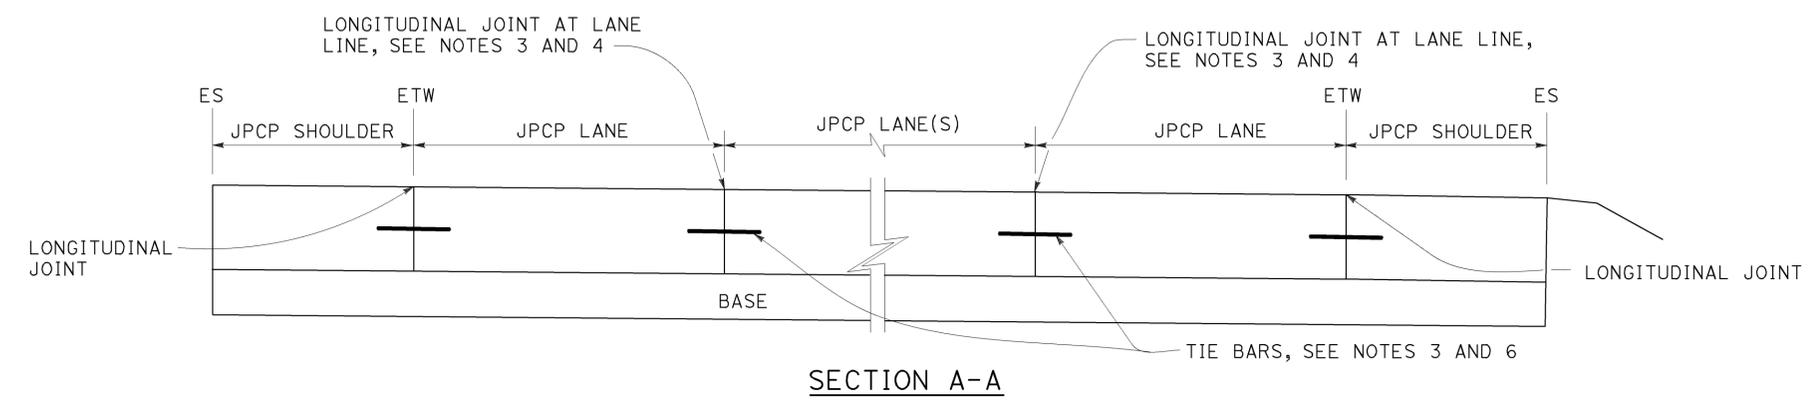


STATE OF CALIFORNIA
 DEPARTMENT OF TRANSPORTATION
**JOINTED PLAIN
 CONCRETE PAVEMENT
 NEW CONSTRUCTION**
 NO SCALE


RSP P1 DATED JULY 19, 2013 SUPERSEDES STANDARD PLAN P1 DATED MAY 20, 2011 - PAGE 125 OF THE STANDARD PLANS BOOK DATED 2010.

REVISED STANDARD PLAN RSP P1


2010 REVISED STANDARD PLAN RSP P1

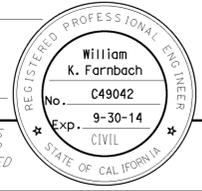

TO ACCOMPANY PLANS DATED 12-7-15

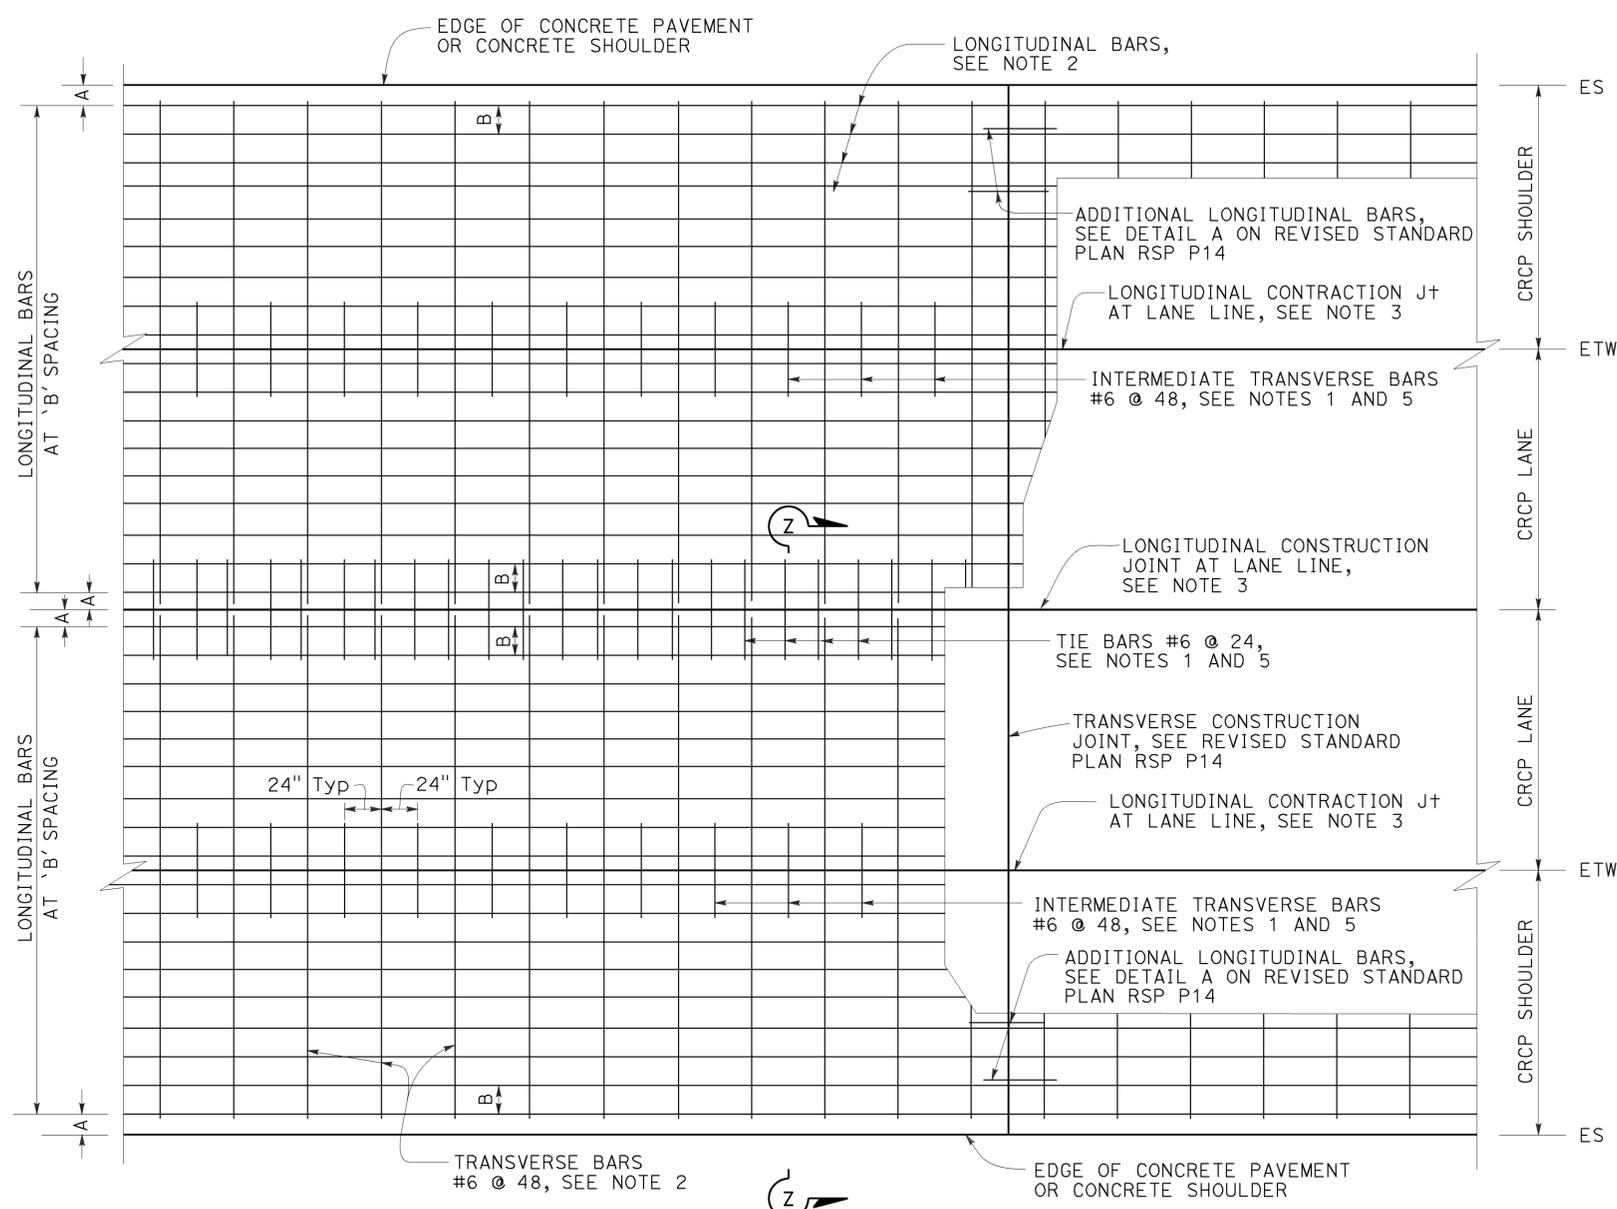

PLAN
See Note 4

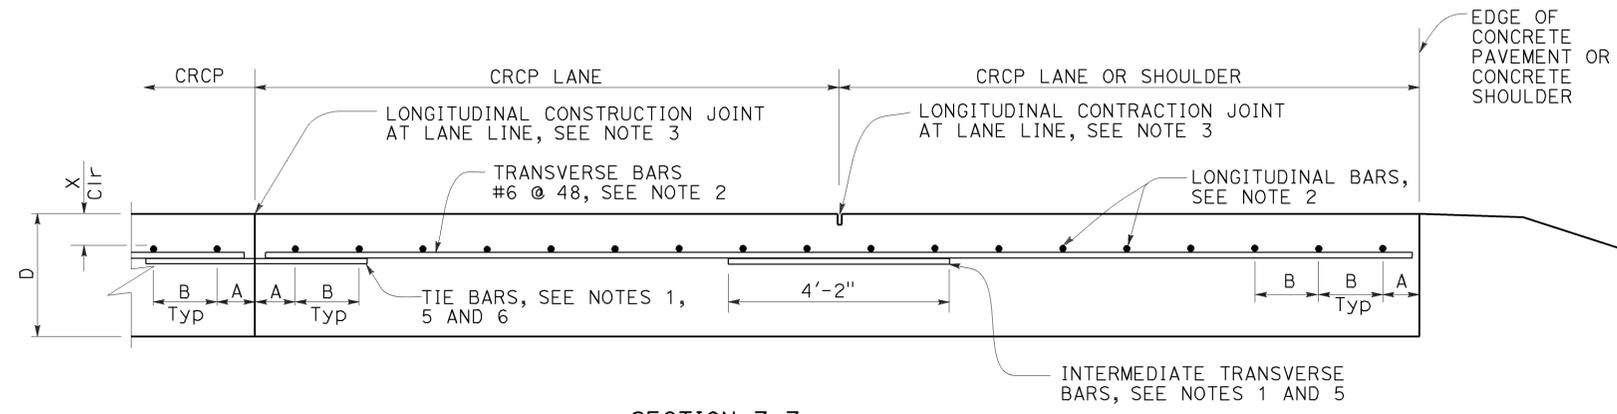

SECTION Z-Z

TABLE No. 1 LONGITUDINAL BAR REINFORCEMENT

SLAB THICKNESS AND BAR SIZE		FIRST SPACING AT EDGE OR JOINT	REGULAR BARS	ADDITIONAL BARS AT TRANSVERSE CONSTRUCTION JOINT	Cir
D	BAR SIZE	SPACING A	SPACING B	SPACING 2 x B	X
.75'	#6	3" TO 4"	8.0"	16"	4"
.80'	#6	3" TO 4"	7.5"	15"	4"
.85'	#6	3" TO 4"	7.0"	14"	4"
.90'	#6	3" TO 4"	6.5"	13"	4"
.95'	#6	3" TO 4"	6.25"	12.5"	4"
1.00'	#6	3" TO 4"	6.0"	12"	5"
1.05'	#6	3" TO 4"	5.75"	11.5"	5"
1.10'	#6	3" TO 4"	5.5"	11"	5.5"

NOTES:

1. Place transverse tie bars and intermediate transverse bars parallel to and in the same plane as transverse bars.
2. The length of lap splices for bar reinforcement must be at least 25".
3. For longitudinal contraction and construction joint details, see Revised Standard Plan RSP P16.
4. For curved lane layout see Revised Standard Plan RSP P16.
5. For tie bar and intermediate transverse bar details see Revised Standard Plan RSP P16.

STATE OF CALIFORNIA
 DEPARTMENT OF TRANSPORTATION
**CONTINUOUSLY REINFORCED
 CONCRETE PAVEMENT**
 NO SCALE

RSP P4 DATED JULY 19, 2013 SUPERSEDES RSP P4 DATED APRIL 20, 2012 AND STANDARD PLAN P4 DATED MAY 20, 2011 - PAGE 128 OF THE STANDARD PLANS BOOK DATED 2010.

REVISED STANDARD PLAN RSP P4


2010 REVISED STANDARD PLAN RSP P4

Dist	COUNTY	ROUTE	POST MILES TOTAL PROJECT	SHEET No.	TOTAL SHEETS
05	SB	101	2.2/3.3	452	786

William K. Farnbach
 REGISTERED CIVIL ENGINEER
 July 19, 2013
 PLANS APPROVAL DATE

THE STATE OF CALIFORNIA OR ITS OFFICERS OR AGENTS SHALL NOT BE RESPONSIBLE FOR THE ACCURACY OR COMPLETENESS OF SCANNED COPIES OF THIS PLAN SHEET.

REGISTERED PROFESSIONAL ENGINEER
 William K. Farnbach
 No. C49042
 Exp. 9-30-14
 CIVIL
 STATE OF CALIFORNIA

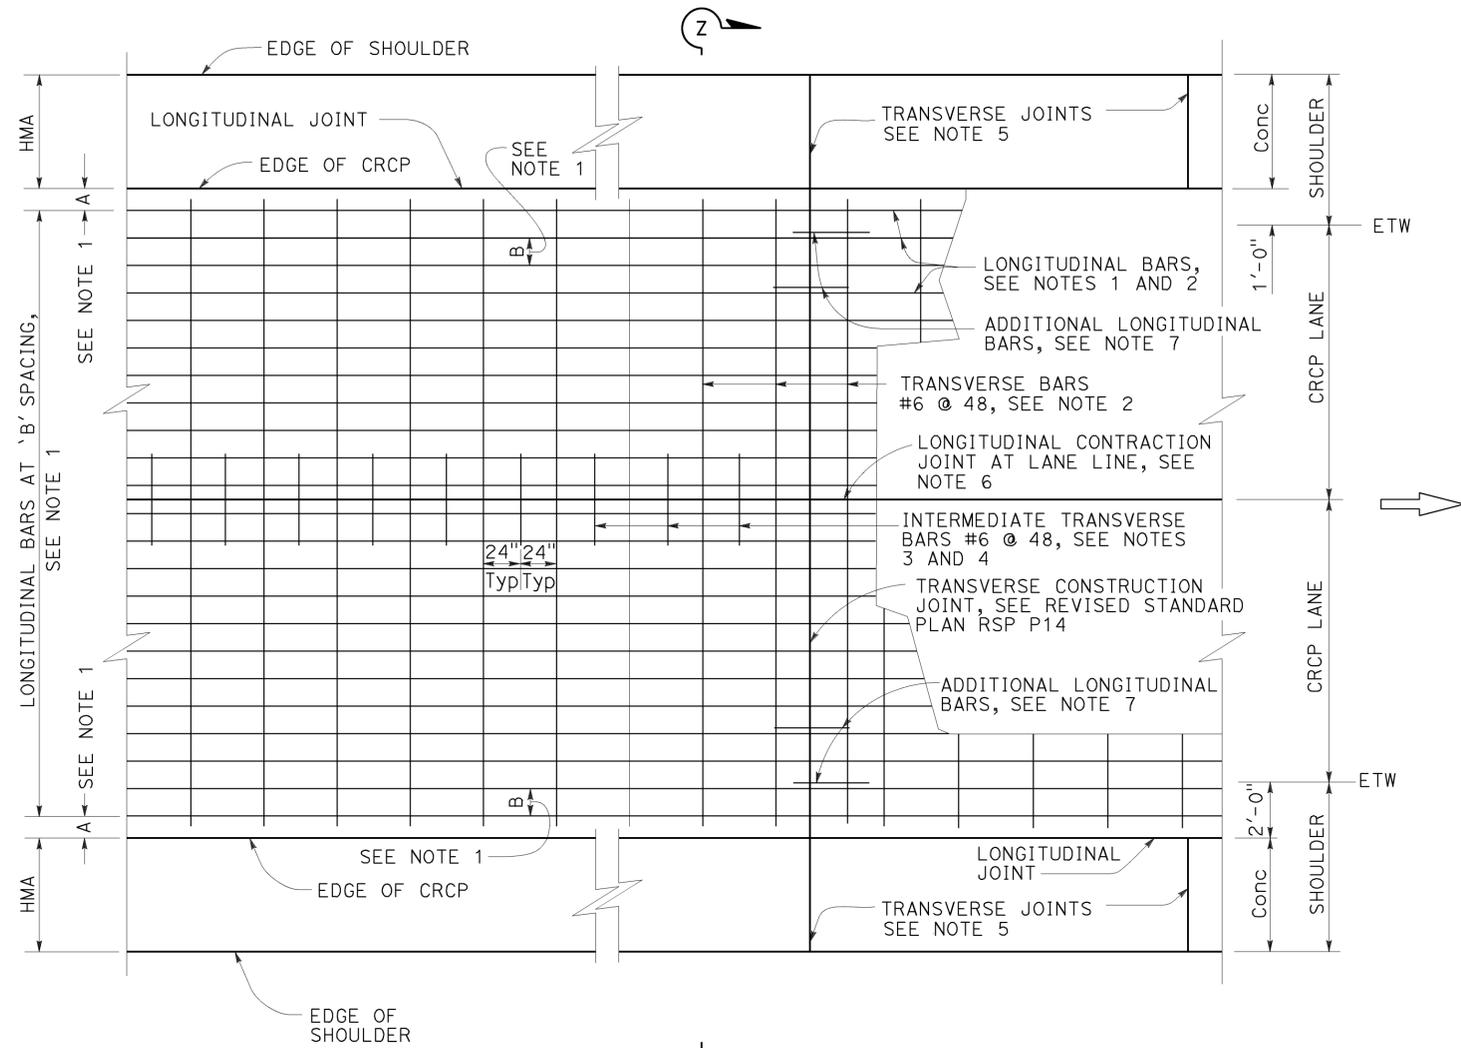


PLAN
See Note 8

NOTES:


1. For longitudinal bar size, spacing and clearances, see Revised Standard Plan RSP P4.
2. The length of lap splices for bar reinforcement must be at least 25".
3. For tie bar and intermediate transverse bar details, see Revised Standard Plan RSP P16.
4. Place Intermediate transverse bars parallel to and in the same plane as transverse bars.
5. Construct transverse joints at right angle to the longitudinal joints in adjacent CRCP. Space joints at no less than 10' intervals and no more than 14' intervals. Match location of JPCP transverse joint with CRCP transverse construction joint, expansion joint or wide flange beam. Omit dowel bars.
6. For longitudinal contraction and construction joint details, see Revised Standard Plan RSP P16.
7. For additional longitudinal bars detail, see Detail A on Revised Standard Plans RSP P14.
8. For longitudinal construction joint plan layout not shown, see Revised Standard Plan RSP P4. For tie bar details at longitudinal construction joint, see Revised Standard Plan RSP P16.
9. For limits of rumble strips, see Project Plans.

ABBREVIATION:


D = Thickness of CRCP

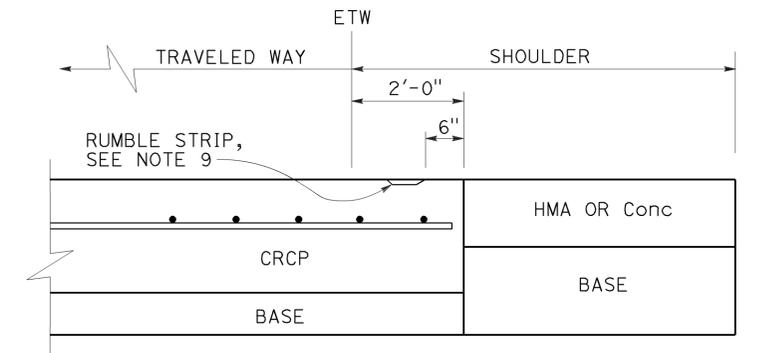

DETAIL A

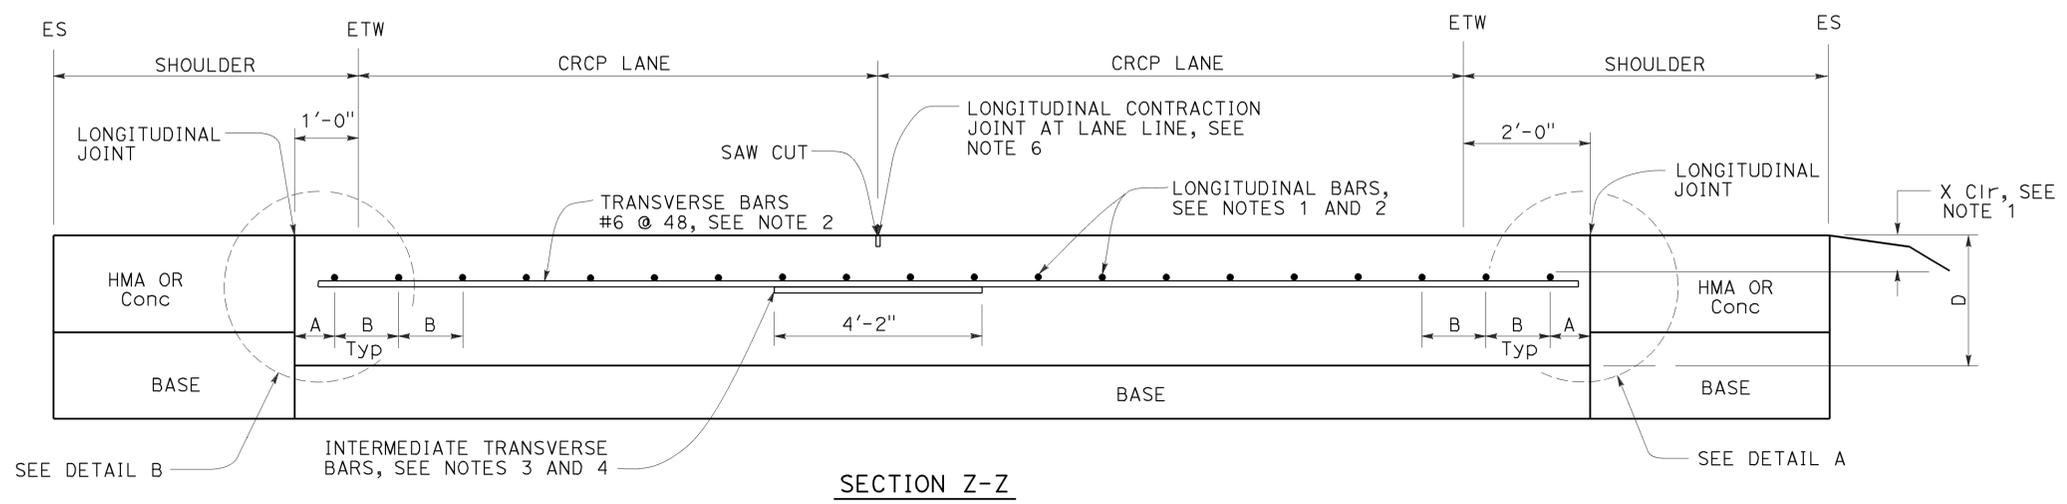

SECTION Z-Z

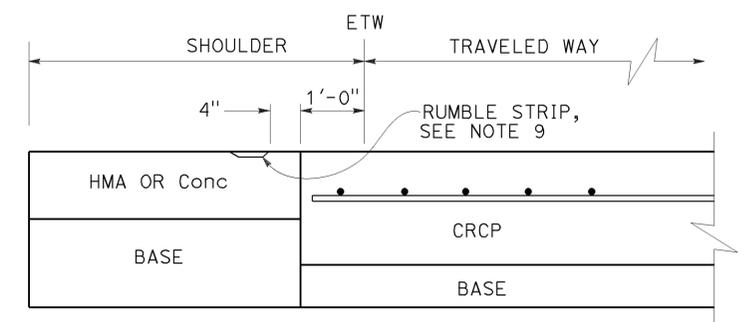

DETAIL B

STATE OF CALIFORNIA
 DEPARTMENT OF TRANSPORTATION
**CONTINUOUSLY REINFORCED
 CONCRETE PAVEMENT
 (WIDENED LANE)**
 NO SCALE

RSP P5A DATED JULY 19, 2013 SUPPLEMENTS THE STANDARD PLANS BOOK DATED 2010.


REVISED STANDARD PLAN RSP P5A

2010 REVISED STANDARD PLAN RSP P5A


Dist	COUNTY	ROUTE	POST MILES TOTAL PROJECT	SHEET No.	TOTAL SHEETS
05	SB	101	2.2/3.3	453	786

William K. Farnbach
 REGISTERED CIVIL ENGINEER
 July 19, 2013
 PLANS APPROVAL DATE

THE STATE OF CALIFORNIA OR ITS OFFICERS OR AGENTS SHALL NOT BE RESPONSIBLE FOR THE ACCURACY OR COMPLETENESS OF SCANNED COPIES OF THIS PLAN SHEET.

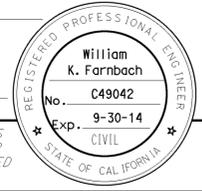

TO ACCOMPANY PLANS DATED 12-7-15


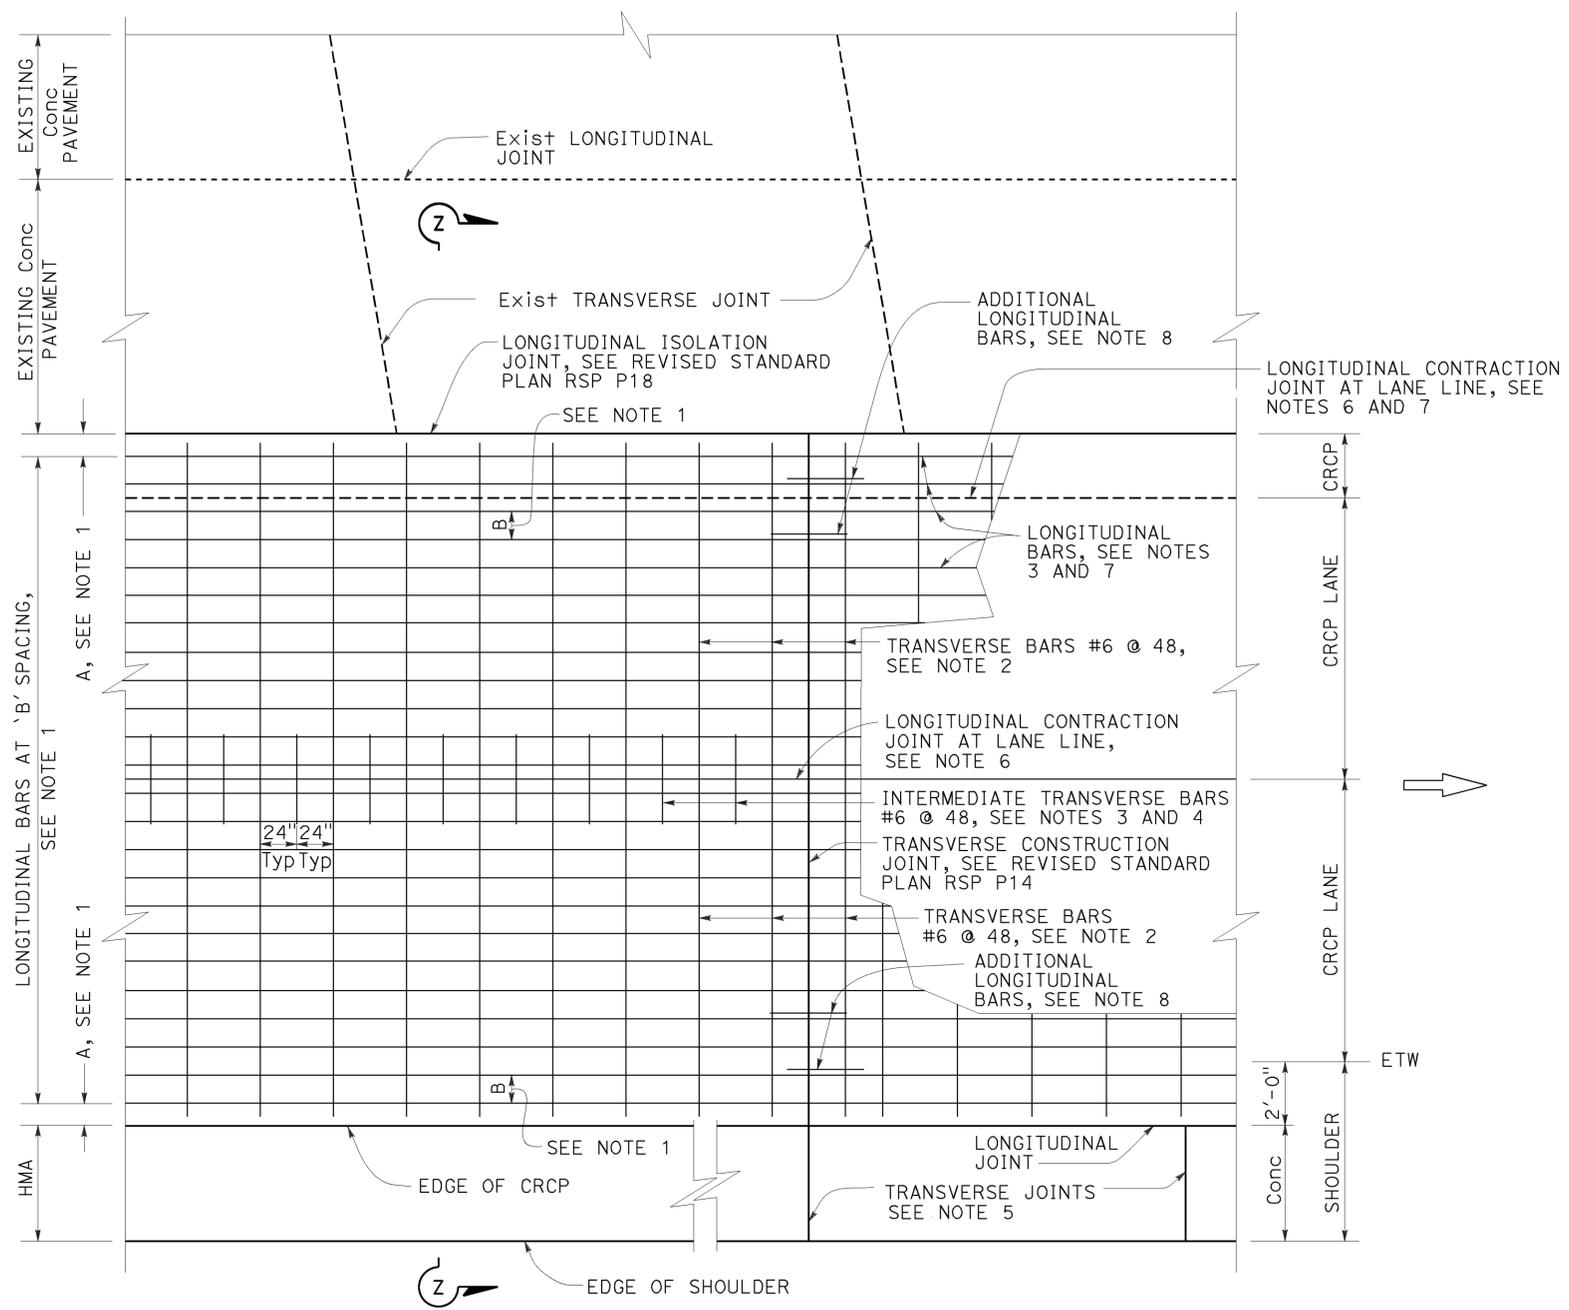


NOTES:

1. For longitudinal bar size, spacing and clearances, see Revised Standard Plan RSP P4.
2. The length of lap splices for bar reinforcement must be at least 25".
3. For tie bar and intermediate transverse bar details, see Revised Standard Plan RSP P16.
4. Place Intermediate transverse bars parallel to and in the same plane as transverse bars.
5. Construct transverse joints at right angle to the longitudinal joints in adjacent CRCP. Space joints at no less than 10' intervals and no more than 14' intervals. Match location of JPCP transverse joint with CRCP transverse construction joint, expansion joint or wide flange beam. Omit dowel bars.
6. For longitudinal contraction and construction joint details, see Revised Standard Plan RSP P16.
7. Do not construct longitudinal contraction joint when edge of new CRCP is less than 3'-3" from lane line.
8. For additional longitudinal bars detail, see Detail A on Revised Standard Plan RSP P14.
9. For longitudinal construction joint plan layout not shown, see Revised Standard Plan RSP P4. For tie bar details at longitudinal construction joint, see Revised Standard Plan RSP P16.
10. For limits of rumble strips, see Project Plans.

ABBREVIATION:

D = Thickness of CRCP

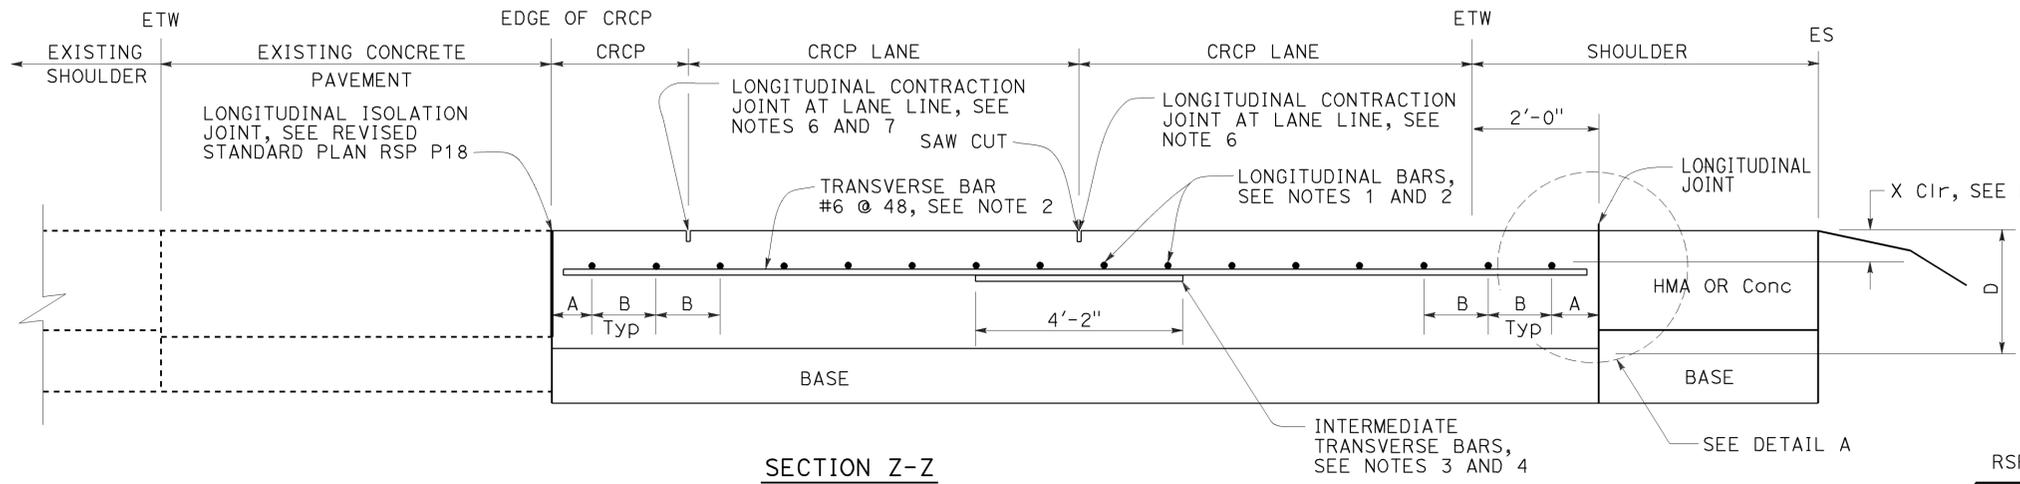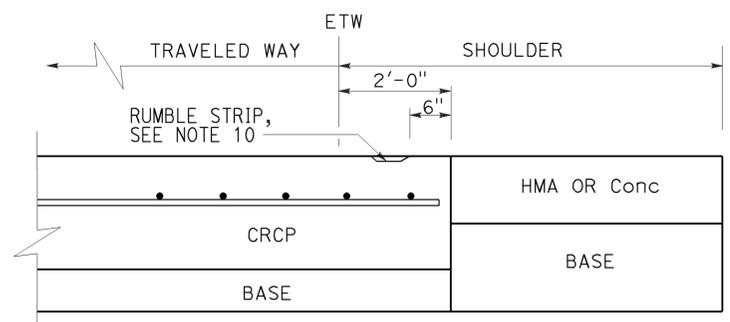

STATE OF CALIFORNIA
 DEPARTMENT OF TRANSPORTATION
**CONTINUOUSLY REINFORCED
 CONCRETE PAVEMENT
 (WIDENED LANE)
 LANE AND SHOULDER
 ADDITION OR REPLACEMENT**

NO SCALE

RSP P5B DATED JULY 19, 2013 SUPPLEMENTS THE STANDARD PLANS BOOK DATED 2010.

REVISED STANDARD PLAN RSP P5B

2010 REVISED STANDARD PLAN RSP P5B


Dist	COUNTY	ROUTE	POST MILES TOTAL PROJECT	SHEET No.	TOTAL SHEETS
05	SB	101	2.2/3.3	454	786

Flora Bautista
 REGISTERED CIVIL ENGINEER
 October 30, 2015
 PLANS APPROVAL DATE

THE STATE OF CALIFORNIA OR ITS OFFICERS OR AGENTS SHALL NOT BE RESPONSIBLE FOR THE ACCURACY OR COMPLETENESS OF SCANNED COPIES OF THIS PLAN SHEET.


REGISTERED PROFESSIONAL ENGINEER
 Florante E. Bautista
 No. C54859
 Exp. 6-30-16
 CIVIL
 STATE OF CALIFORNIA

TO ACCOMPANY PLANS DATED 12-7-15

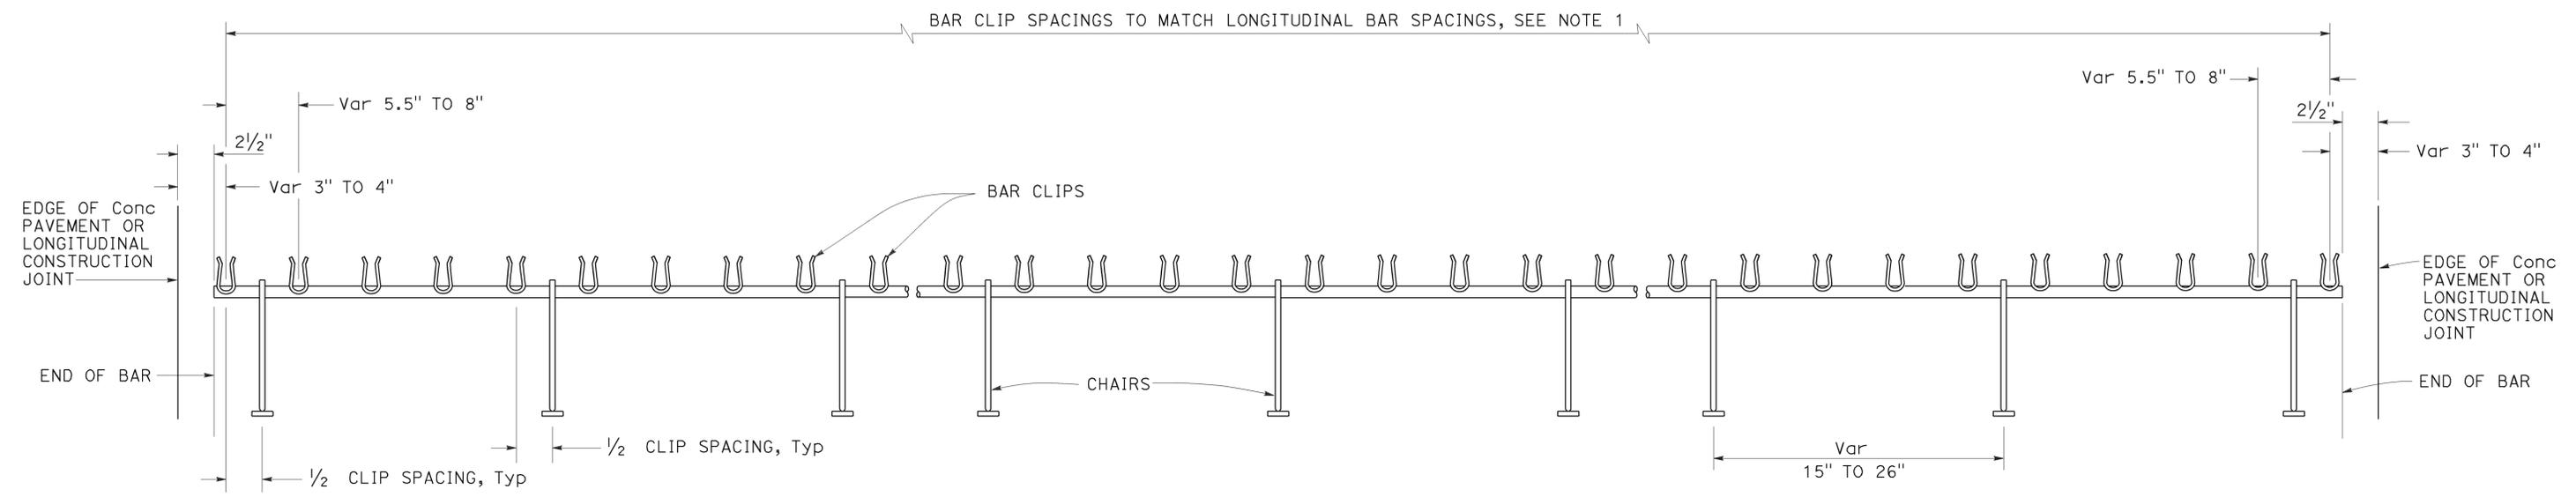


TRANSVERSE BAR ASSEMBLY


- NOTES:**
1. See Revised Standard Plan RSP P4 for spacing of longitudinal bars.
 2. Tensile strength of chair shall be at least 50,000 psi.
 3. Wire sizes shown are minimum required.
 4. For concrete cover (X), see Table 1 in Revised Standard Plan RSP P4.

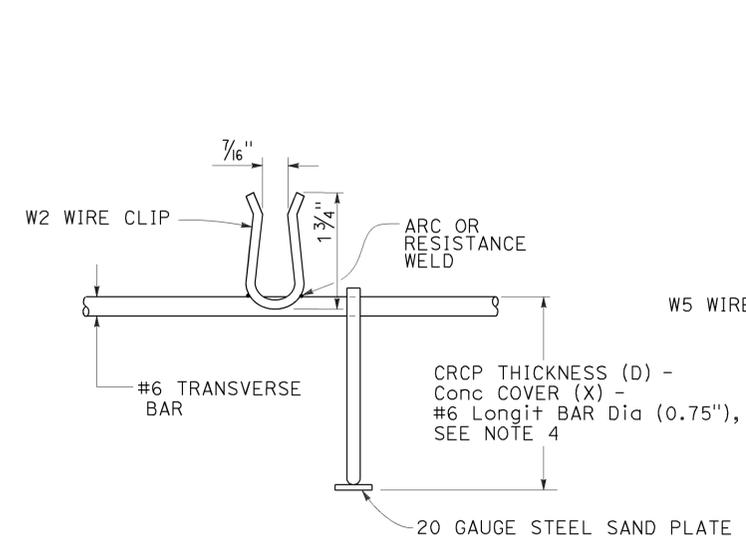

#6 BAR CLIP DETAIL

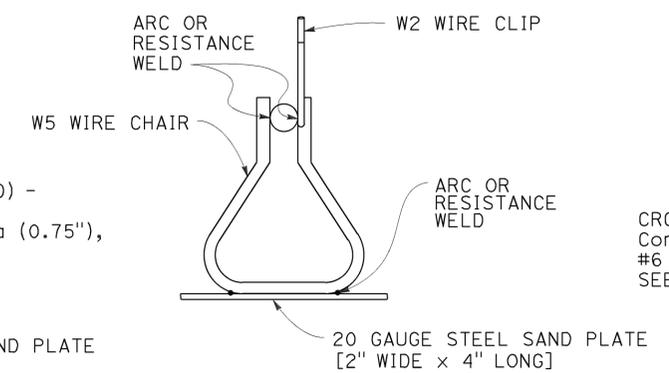

CHAIR DETAIL

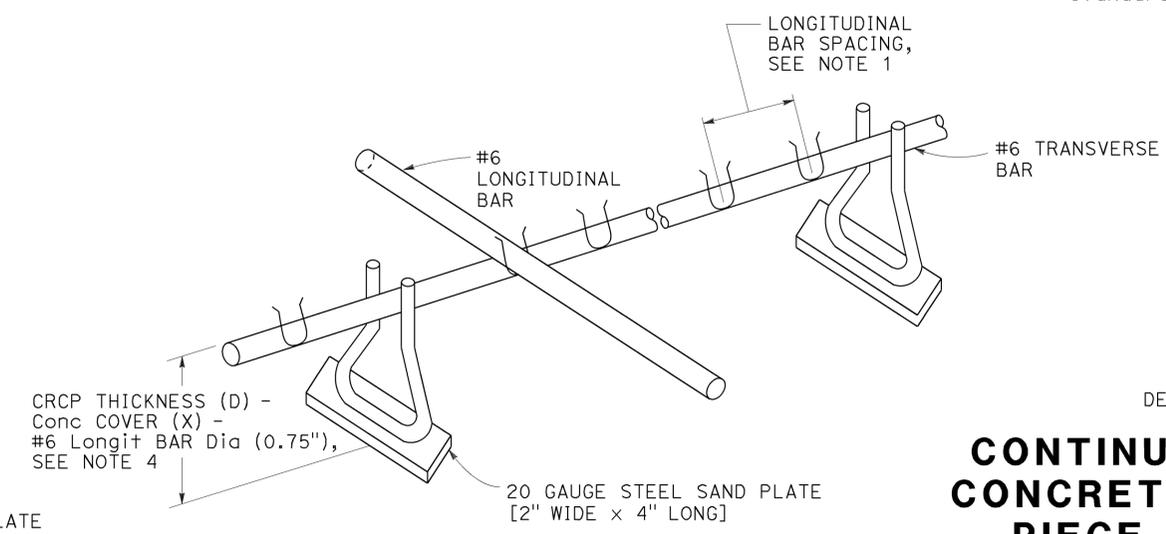

ISOMETRIC VIEW OF CHAIR ASSEMBLY

STATE OF CALIFORNIA
 DEPARTMENT OF TRANSPORTATION

**CONTINUOUSLY REINFORCED
 CONCRETE PAVEMENT-SINGLE
 PIECE TRANSVERSE BAR
 ASSEMBLY**

NO SCALE

RSP P13 DATED OCTOBER 30, 2015 SUPERSEDES RSP P13 DATED OCTOBER 19, 2012 AND STANDARD PLAN P13 DATED MAY 20, 2011 - PAGE 133 OF THE STANDARD PLANS BOOK DATED 2010.

2010 REVISED STANDARD PLAN RSP P13

Dist	COUNTY	ROUTE	POST MILES TOTAL PROJECT	SHEET No.	TOTAL SHEETS
05	SB	101	2.2/3.3	455	786

William K. Farnbach
 REGISTERED CIVIL ENGINEER
 July 19, 2013
 PLANS APPROVAL DATE
THE STATE OF CALIFORNIA OR ITS OFFICERS OR AGENTS SHALL NOT BE RESPONSIBLE FOR THE ACCURACY OR COMPLETENESS OF SCANNED COPIES OF THIS PLAN SHEET.




TO ACCOMPANY PLANS DATED 12-7-15

NOTES:

1. For longitudinal bar size, spacing and clearances, see Table 1 on Revised Standard Plan RSP P4.
2. The length of lap splices for bar reinforcement must be at least 25".
3. For tie bars in longitudinal construction joint, see Revised Standard Plan RSP P16.
4. Place additional longitudinal bars parallel to and in the same plane as the longitudinal bars.
5. Place additional longitudinal bars symmetrically about longitudinal construction joint.


ABBREVIATION

D = Thickness of CRCP

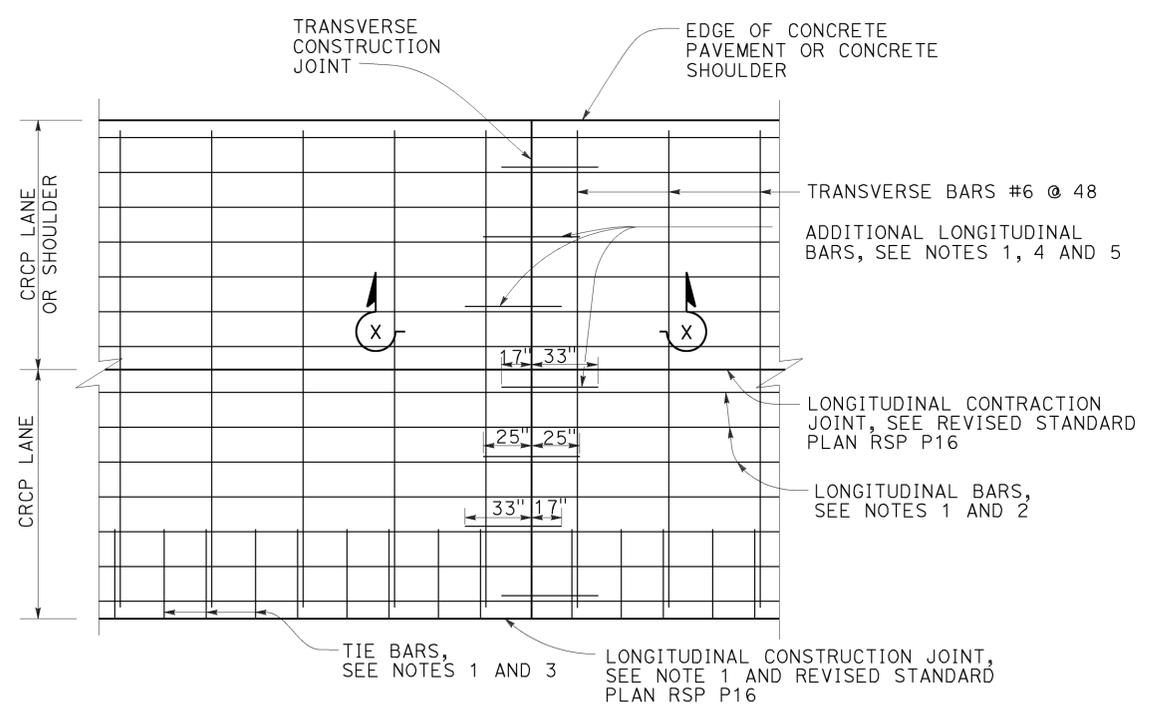

DETAIL A

Additional longitudinal bars at transverse construction joint

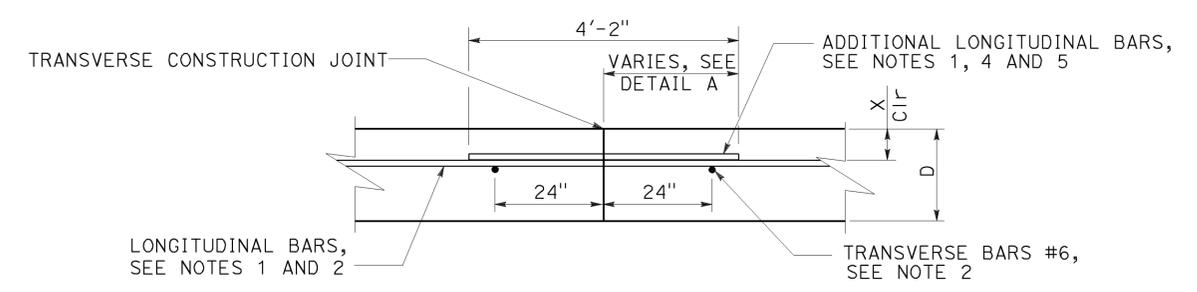

SECTION X-X

TRANSVERSE CONSTRUCTION JOINT

STATE OF CALIFORNIA
 DEPARTMENT OF TRANSPORTATION
**CONTINUOUSLY REINFORCED
 CONCRETE PAVEMENT
 TRANSVERSE CONSTRUCTION JOINT**

NO SCALE

RSP P14 DATED JULY 19, 2013 SUPPLEMENTS THE STANDARD PLANS BOOK DATED 2010.

REVISED STANDARD PLAN RSP P14


2010 REVISED STANDARD PLAN RSP P14

Dist	COUNTY	ROUTE	POST MILES TOTAL PROJECT	SHEET No.	TOTAL SHEETS
05	SB	101	2.2/3.3	456	786


William K. Farnbach
 REGISTERED CIVIL ENGINEER
 July 19, 2013
 PLANS APPROVAL DATE
 THE STATE OF CALIFORNIA OR ITS OFFICERS OR AGENTS SHALL NOT BE RESPONSIBLE FOR THE ACCURACY OR COMPLETENESS OF SCANNED COPIES OF THIS PLAN SHEET.

REGISTERED PROFESSIONAL ENGINEER
 William K. Farnbach
 No. C49042
 Exp. 9-30-14
 CIVIL
 STATE OF CALIFORNIA


TO ACCOMPANY PLANS DATED 12-7-15

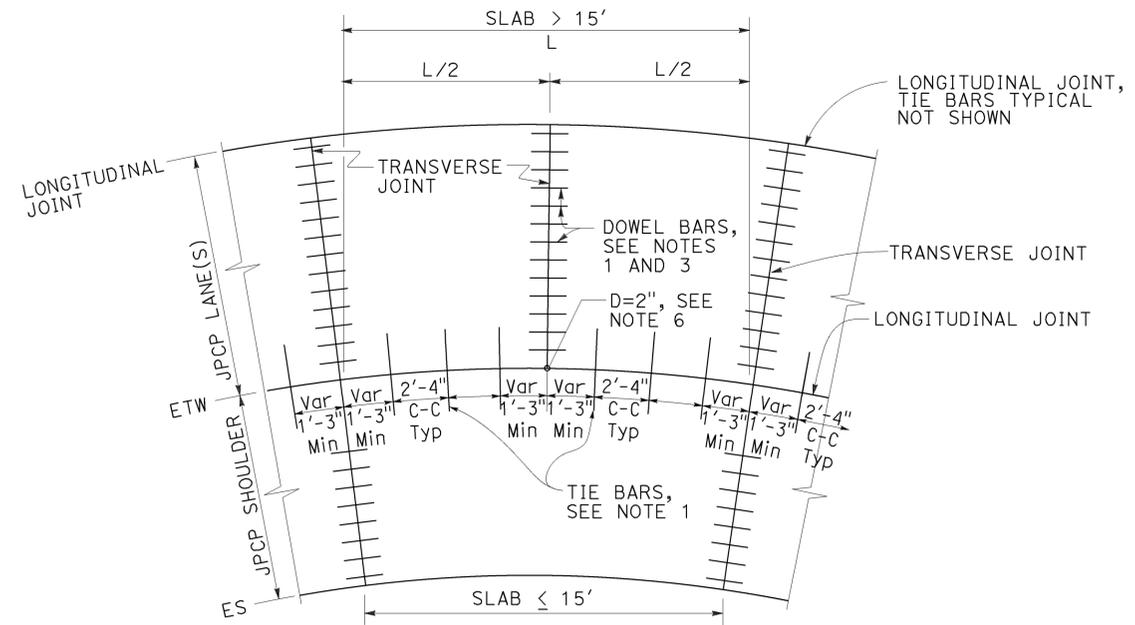


TIE BAR LAYOUT IN CURVED LANES

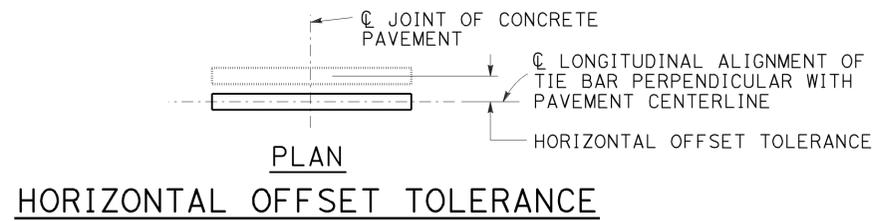


HORIZONTAL OFFSET TOLERANCE

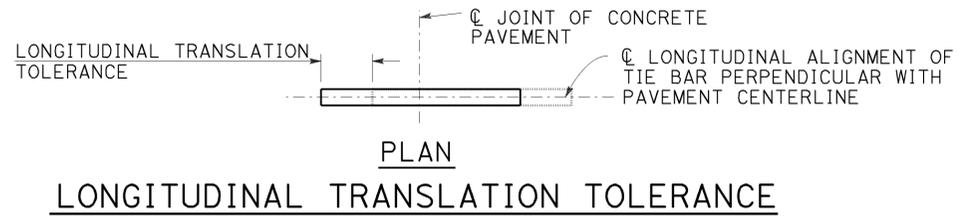


LONGITUDINAL TRANSLATION TOLERANCE

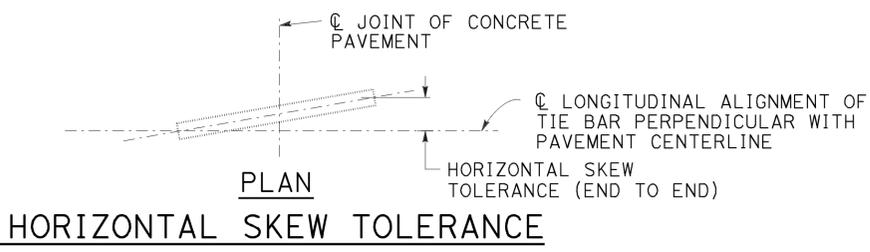


HORIZONTAL SKEW TOLERANCE

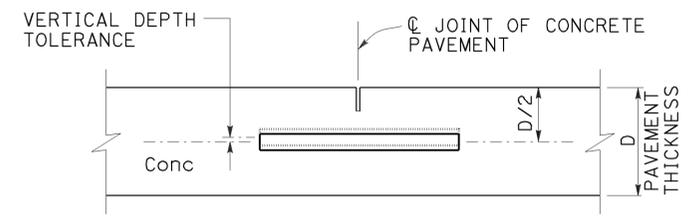


VERTICAL DEPTH TOLERANCE

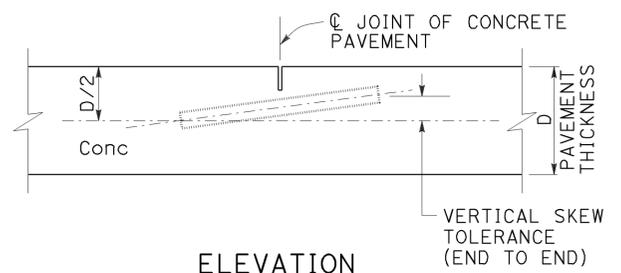


VERTICAL SKEW TOLERANCE

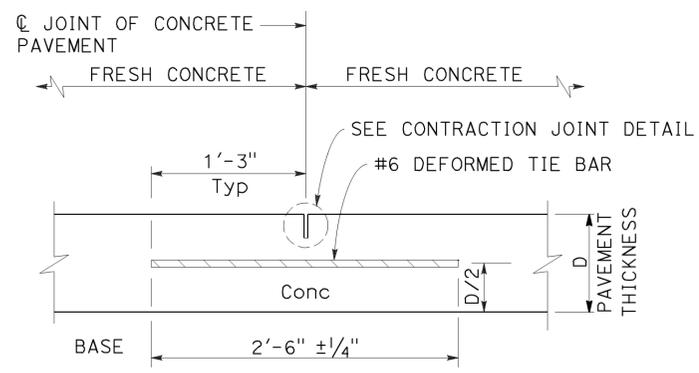


LONGITUDINAL CONTRACTION JOINT

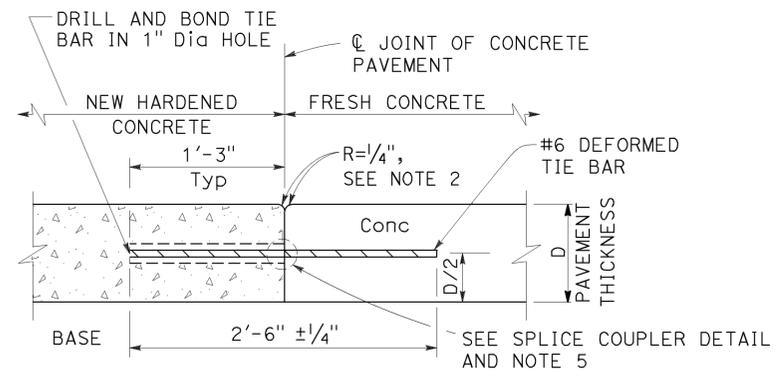

LONGITUDINAL CONSTRUCTION JOINT

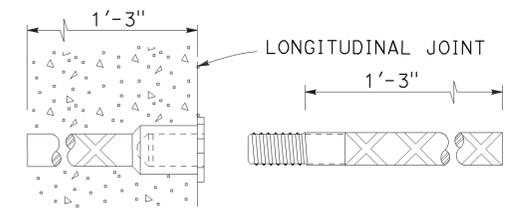

ALTERNATIVE SPLICE COUPLER

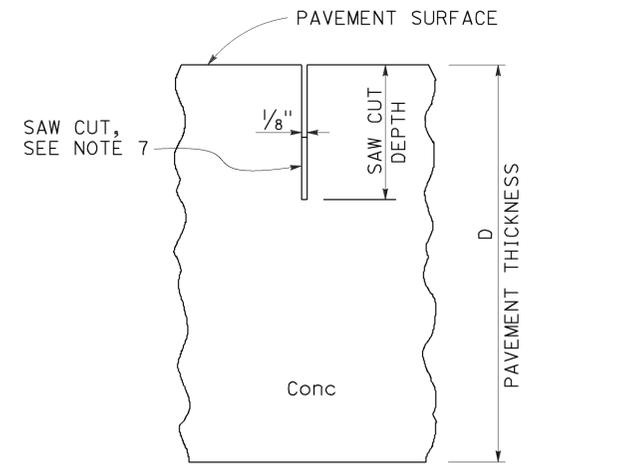

CONTRACTION JOINT DETAIL

- NOTES:**
1. See Revised Standard Plan RSP P1 for typical dowel bar and tie bar placement and locations.
 2. Where new pavement is placed against existing concrete pavement, rounding the corner is not required.
 3. For dowel bar sizes, See Revised Standard Plan RSP P10.
 4. Tie bar details apply to inside widenings.
 5. Use either drill and bond or splice couplers.
 6. Full depth drilled hole. Fill hole with filler material.
 7. The bottom of the saw cut must be at least 0.5" clear of any dowel bar, tie bar and bar reinforcement.

STATE OF CALIFORNIA
 DEPARTMENT OF TRANSPORTATION
**CONCRETE PAVEMENT -
 TIE BAR
 DETAILS**
 NO SCALE

RSP P15 DATED JULY 19, 2013 SUPPLEMENTS THE STANDARD PLANS BOOK DATED 2010.


2010 REVISED STANDARD PLAN RSP P15

Dist	COUNTY	ROUTE	POST MILES TOTAL PROJECT	SHEET No.	TOTAL SHEETS
05	SB	101	2.2/3.3	457	786

Florante E. Bautista
 REGISTERED CIVIL ENGINEER
 October 30, 2015
 PLANS APPROVAL DATE
THE STATE OF CALIFORNIA OR ITS OFFICERS OR AGENTS SHALL NOT BE RESPONSIBLE FOR THE ACCURACY OR COMPLETENESS OF SCANNED COPIES OF THIS PLAN SHEET.

REGISTERED PROFESSIONAL ENGINEER
 Florante E. Bautista
 No. C54859
 Exp. 6-30-16
 CIVIL
 STATE OF CALIFORNIA



TO ACCOMPANY PLANS DATED 12-7-15

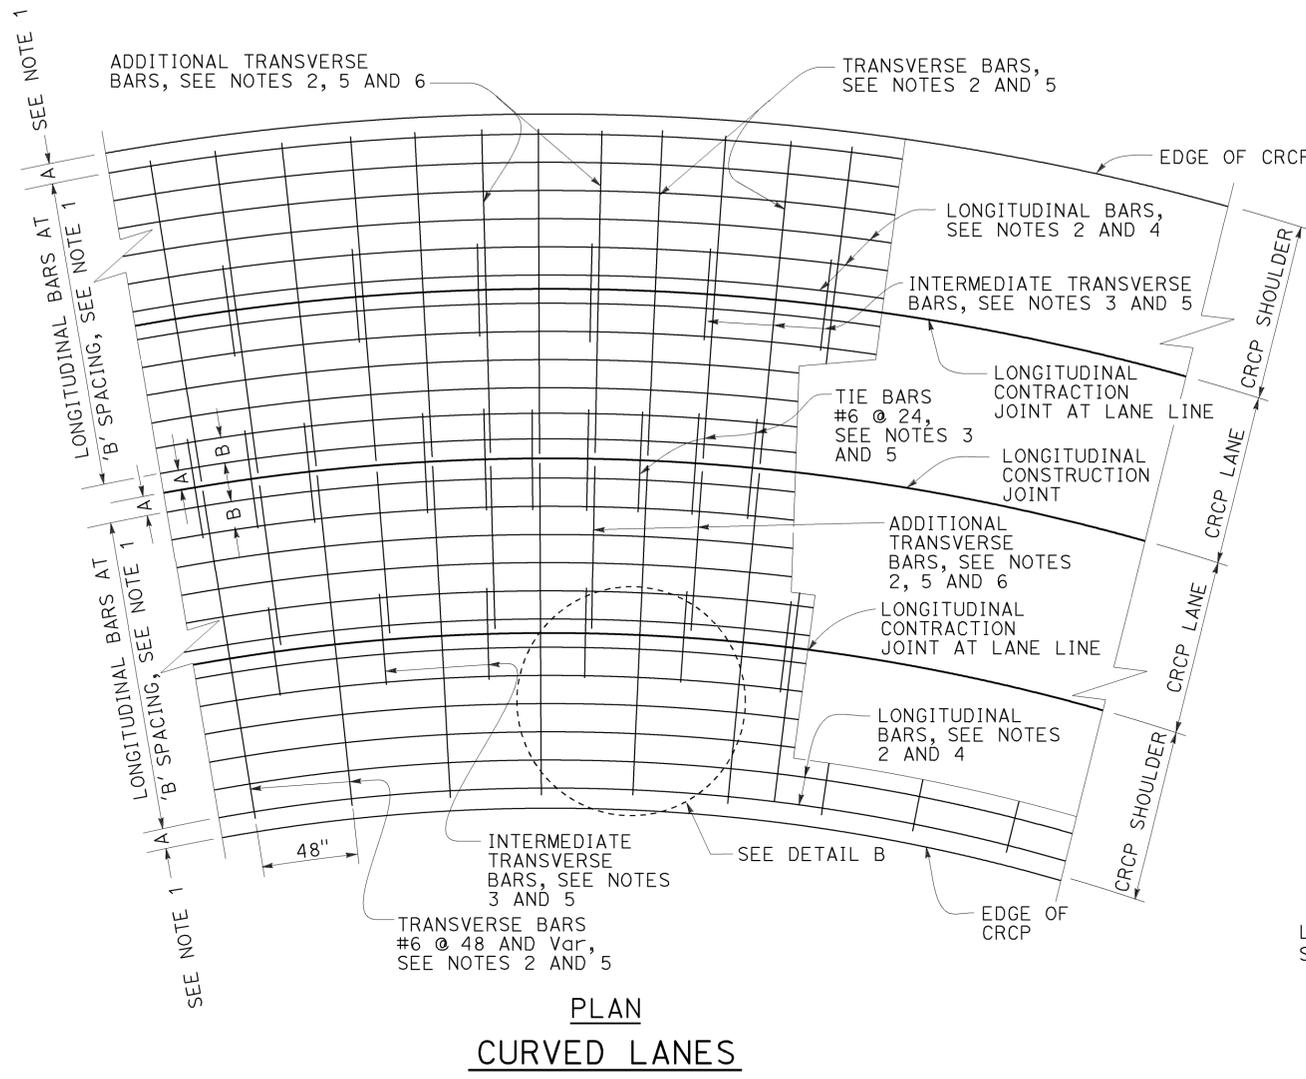


**PLAN
CURVED LANES**

- NOTES:**
1. For longitudinal bar spacing and clearances, see Table 1 on Revised Standard Plan RSP P4.
 2. The length of lap splices for bar reinforcement must be at least 25".
 3. Place tie bars and intermediate transverse bars parallel to and in the same plane as the transverse bars.
 4. Place longitudinal bars parallel to roadway curvature.
 5. Place transverse bars, additional transverse bars, tie bars and intermediate transverse bars perpendicular to the pavement curvature.
 6. Place additional transverse bars where required, see Detail B.
 7. The bottom of the saw cut must be at least 0.5" clear of any dowel bar, tie bar and bar reinforcement.


ABBREVIATION:
D = Thickness of CRCP

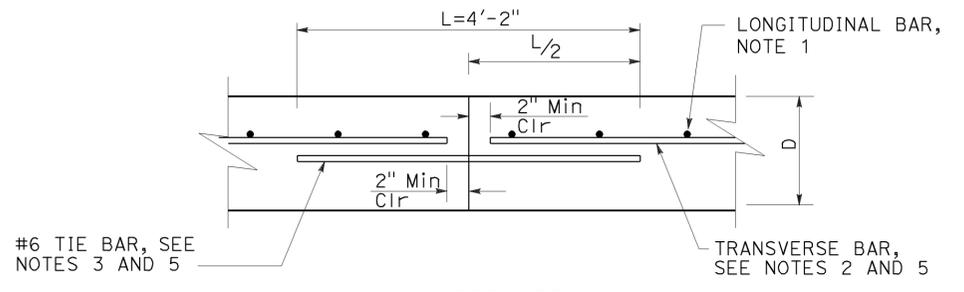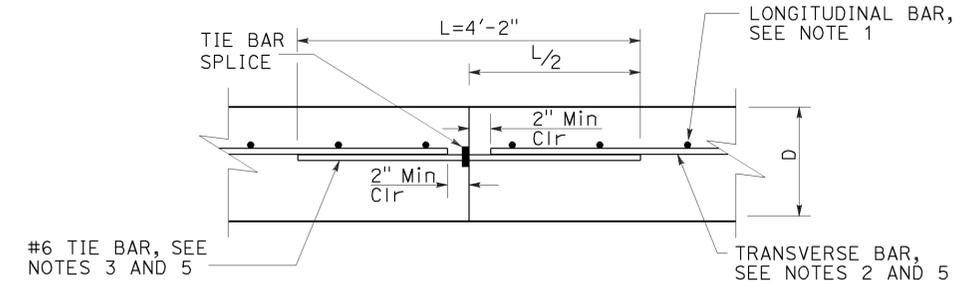


**ALTERNATE
LONGITUDINAL CONSTRUCTION JOINT**

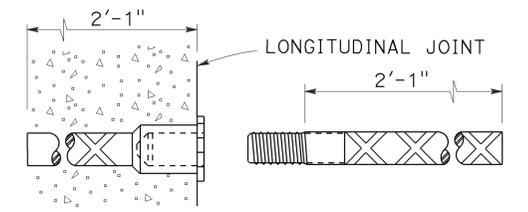


TIE BAR SPLICE COUPLER DETAIL

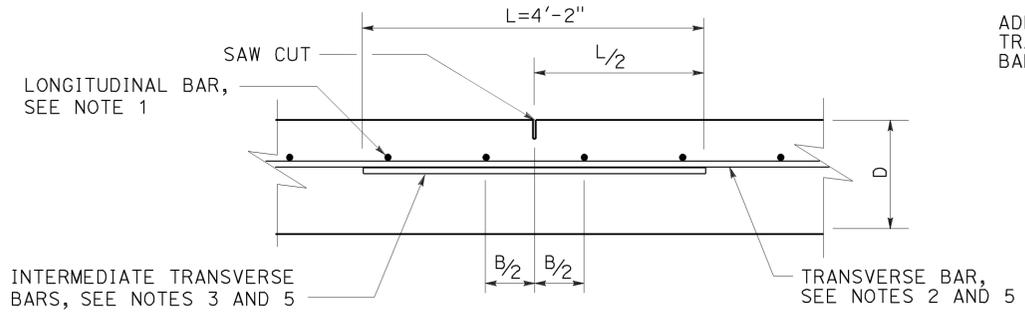

LONGITUDINAL CONTRACTION JOINT

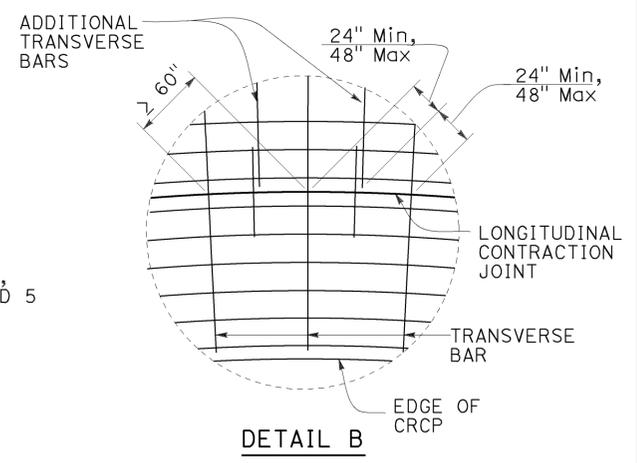

DETAIL B

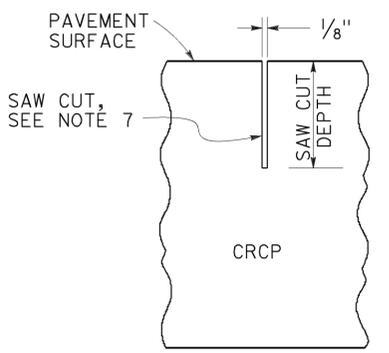

CONTRACTION JOINT SAW CUT DETAIL

STATE OF CALIFORNIA
DEPARTMENT OF TRANSPORTATION

**CONTINUOUSLY REINFORCED
CONCRETE PAVEMENT
TIE BARS AND JOINT DETAILS**

NO SCALE

RSP P16 DATED OCTOBER 30, 2015 SUPPLEMENTS RSP P16 DATED JULY 19, 2013 THAT SUPPLEMENTS THE STANDARD PLANS BOOK DATED 2010.

2010 REVISED STANDARD PLAN RSP P16


Dist	COUNTY	ROUTE	POST MILES TOTAL PROJECT	SHEET No.	TOTAL SHEETS
05	SB	101	2.2/3.3	458	786

William K. Farnbach
 REGISTERED CIVIL ENGINEER
 July 19, 2013
 PLANS APPROVAL DATE
 THE STATE OF CALIFORNIA OR ITS OFFICERS OR AGENTS SHALL NOT BE RESPONSIBLE FOR THE ACCURACY OR COMPLETENESS OF SCANNED COPIES OF THIS PLAN SHEET.


TO ACCOMPANY PLANS DATED 12-7-15

NOTES:


- "U" frame shape assembly shown. Use either "U" frame shape or "A" frame shape.
- Wire sizes shown are the minimum required.
- All wire intersections must be resistance welded.
- Weld may be at top or bottom of tie bars.
- Use anchor pins where soil or granular base is used.

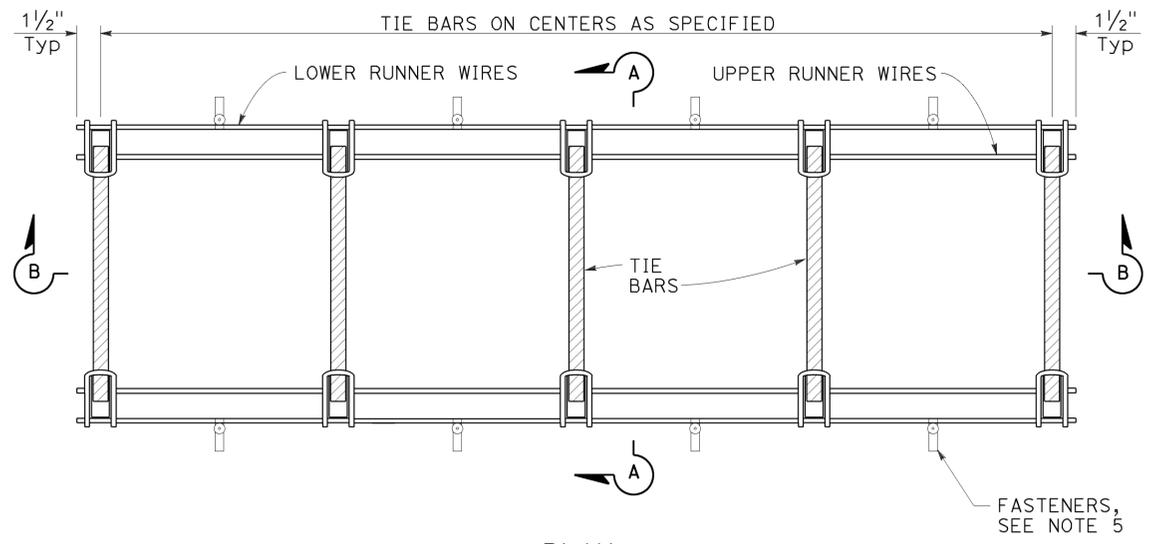


TIE BAR BASKET
 (Tie bars at longitudinal joint)
 See Note 1

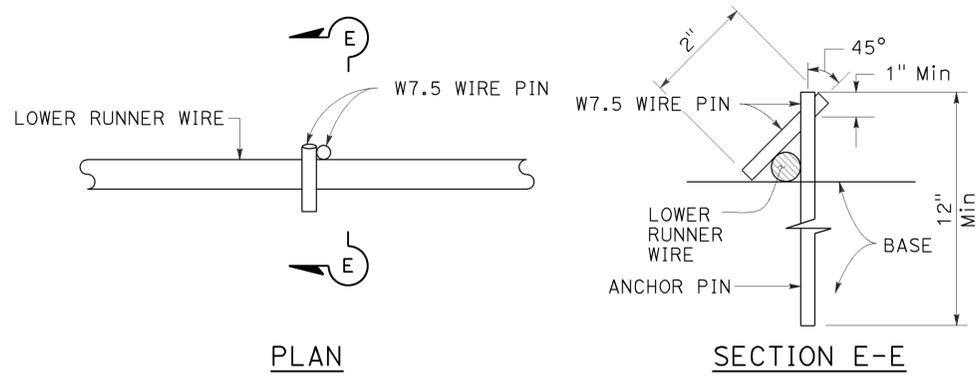


ANCHOR PIN DETAIL
 See Note 5

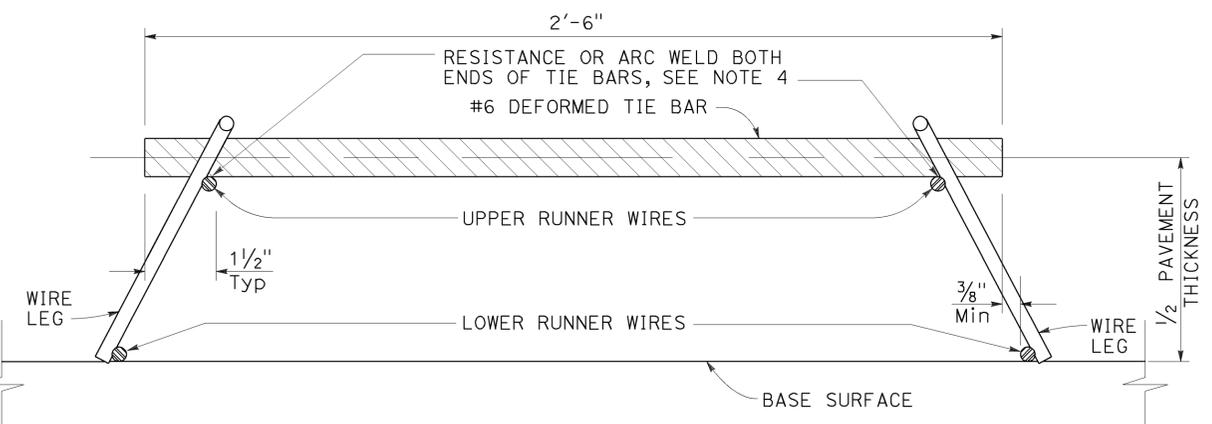


SECTION A-A

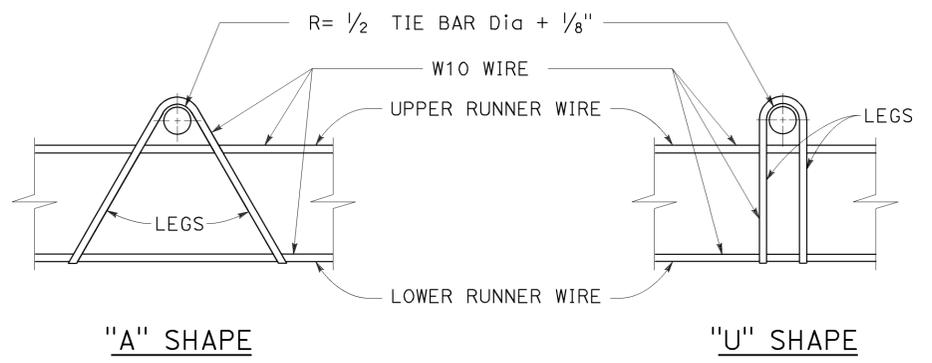

ASSEMBLY FRAME DETAILS
 See Note 1

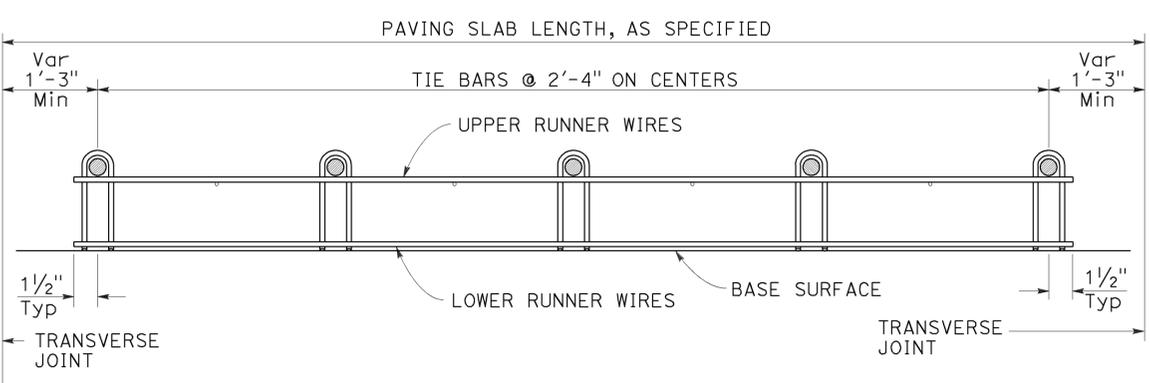

SECTION B-B
 See Note 1

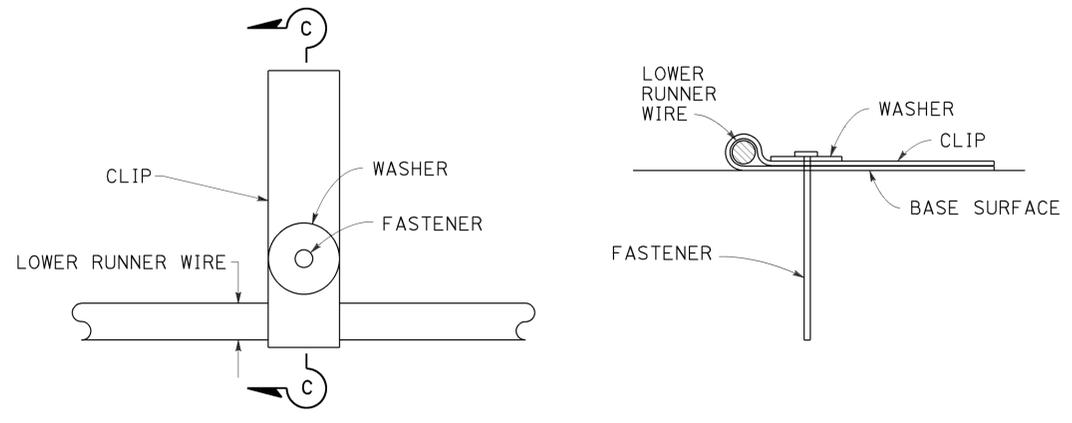

FASTENER DETAIL

STATE OF CALIFORNIA
 DEPARTMENT OF TRANSPORTATION
**CONCRETE PAVEMENT
 TIE BAR BASKET
 DETAILS**
 NO SCALE


RSP P17 DATED JULY 19, 2013 SUPERSEDES STANDARD PLAN P17
 DATED MAY 20, 2011 - PAGE 134 OF THE STANDARD PLANS BOOK DATED 2010.

REVISED STANDARD PLAN RSP P17


2010 REVISED STANDARD PLAN RSP P17

Dist	COUNTY	ROUTE	POST MILES TOTAL PROJECT	SHEET No.	TOTAL SHEETS
05	SB	101	2.2/3.3	459	786

William K. Farnbach
 REGISTERED CIVIL ENGINEER
 July 19, 2013
 PLANS APPROVAL DATE
 THE STATE OF CALIFORNIA OR ITS OFFICERS OR AGENTS SHALL NOT BE RESPONSIBLE FOR THE ACCURACY OR COMPLETENESS OF SCANNED COPIES OF THIS PLAN SHEET.

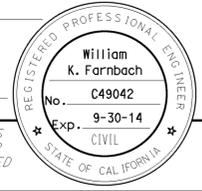

TO ACCOMPANY PLANS DATED 12-7-15

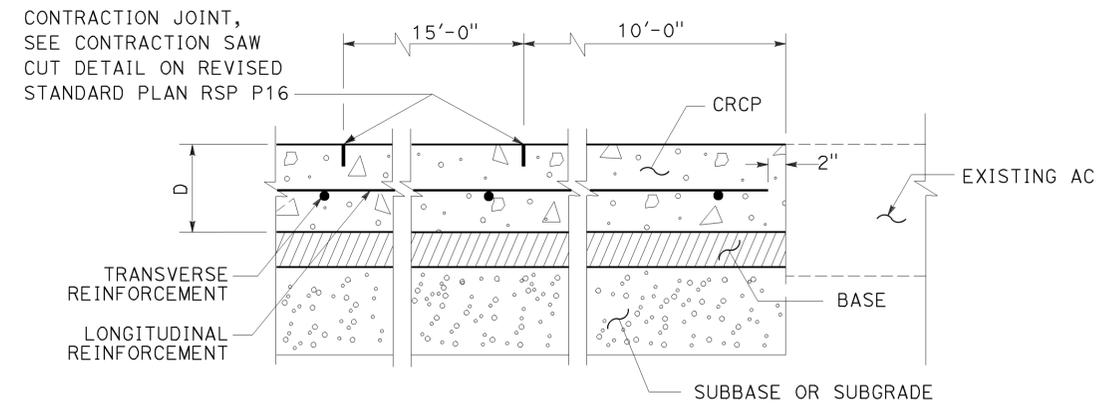


TERMINAL JOINT TYPE A
(For Existing AC)


- NOTES:**
- For the locations of wide flange beam terminal, pavement anchors and expansion joints, see Projects Plans.
 - See Revised Standard Plans RSP P31B and RSP P32A.

ABBREVIATIONS


- D = Thickness of CRCP
 A = Depth of HMA as shown on Project Plans
 U = Thickness of Base

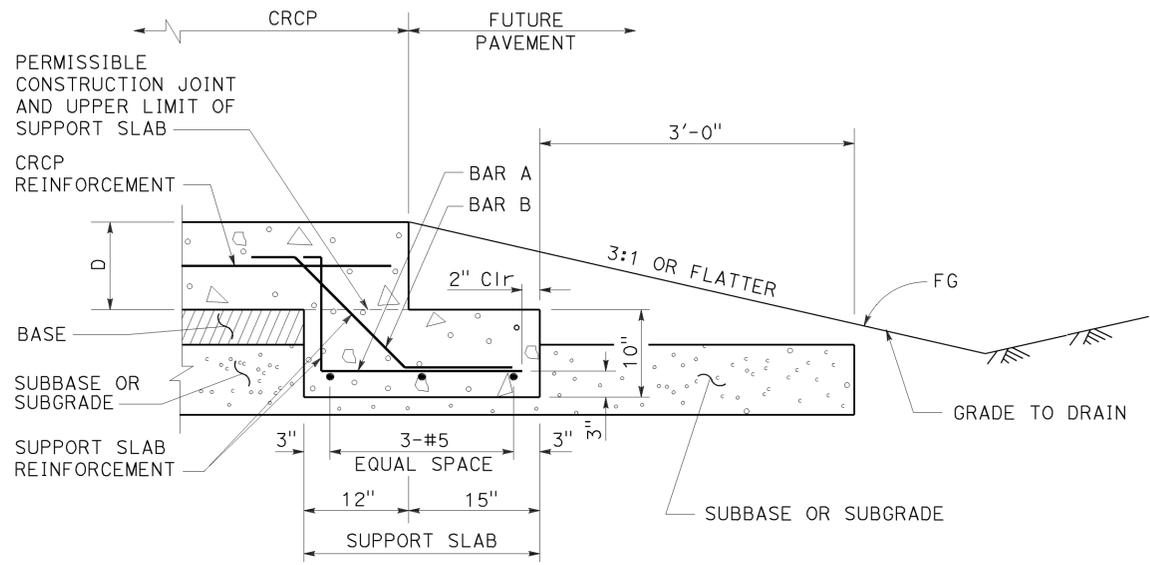


TERMINAL JOINT TYPE B
(For Future Pavement)

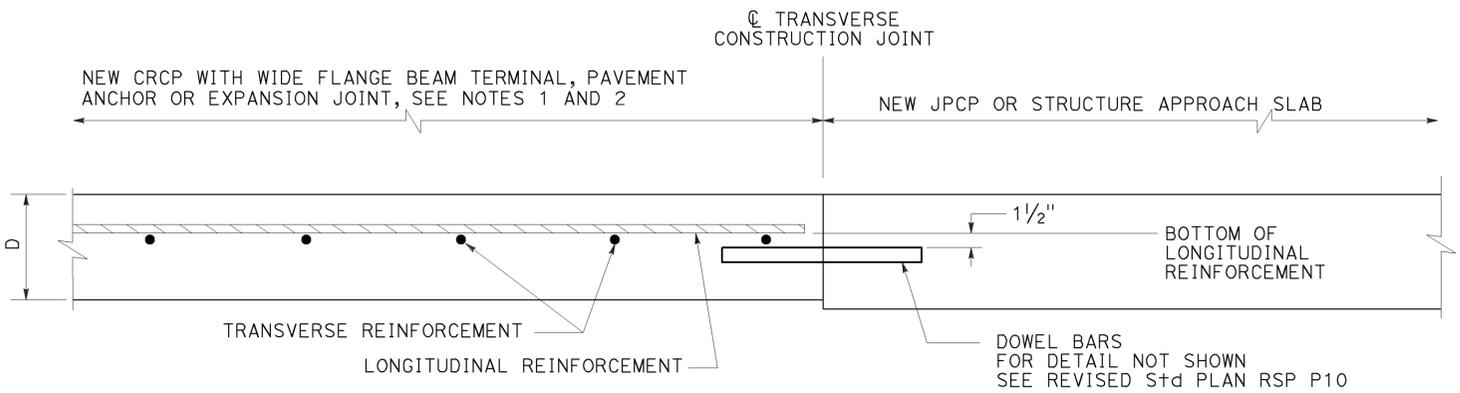


TERMINAL JOINT TYPE E
(For New JPCP or Structure Approach Slabs)

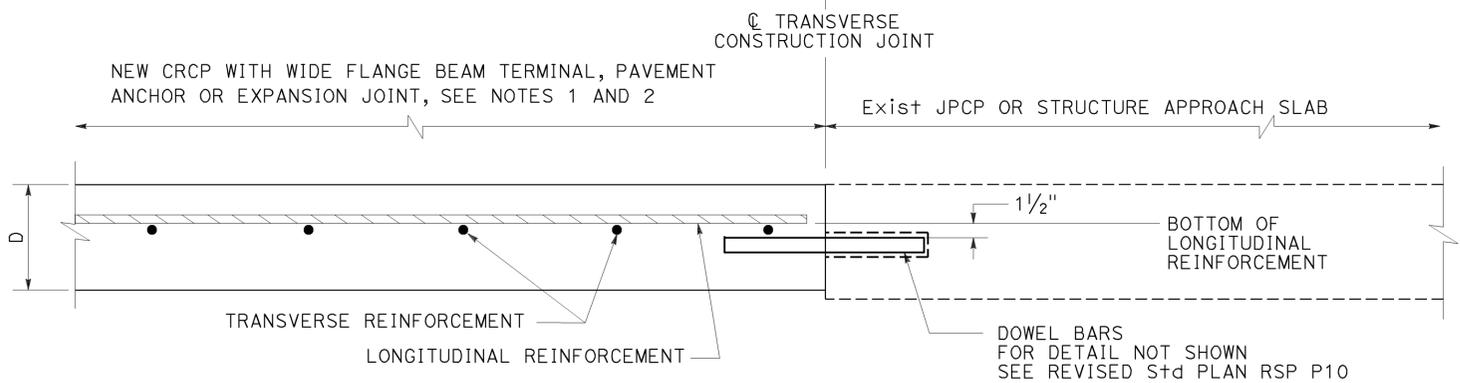


TERMINAL JOINT TYPE D
(For Existing JPCP or Structure Approach Slabs)

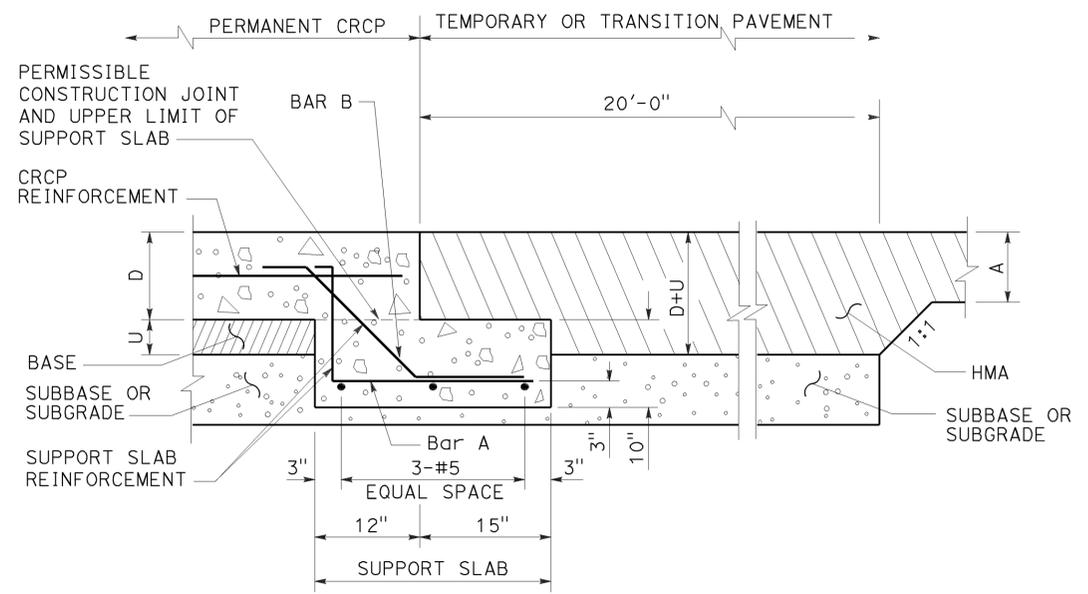

TERMINAL JOINT TYPE C
(For Temporary HMA Pavement)

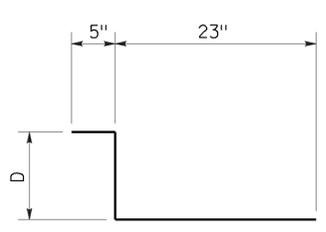

BAR "A" (#5)
AT 12" C-C

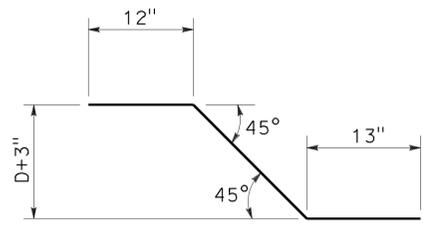

BAR "B" (#5)
AT 12" C-C

STATE OF CALIFORNIA
 DEPARTMENT OF TRANSPORTATION
**CONTINUOUSLY REINFORCED
 CONCRETE PAVEMENT
 TERMINAL JOINT DETAILS**
 NO SCALE

RSP P31A DATED JULY 19, 2013 SUPERSEDES STANDARD PLAN P31A DATED MAY 20, 2011 - PAGE 138 OF THE STANDARD PLANS BOOK DATED 2010.


REVISED STANDARD PLAN RSP P31A

2010 REVISED STANDARD PLAN RSP P31A


Dist	COUNTY	ROUTE	POST MILES TOTAL PROJECT	SHEET No.	TOTAL SHEETS
05	SB	101	2.2/3.3	460	786

Florante E. Bautista
 REGISTERED CIVIL ENGINEER
 April 20, 2012
 PLANS APPROVAL DATE
THE STATE OF CALIFORNIA OR ITS OFFICERS OR AGENTS SHALL NOT BE RESPONSIBLE FOR THE ACCURACY OR COMPLETENESS OF SCANNED COPIES OF THIS PLAN SHEET.


2010 REVISED STANDARD PLAN RSP P31B

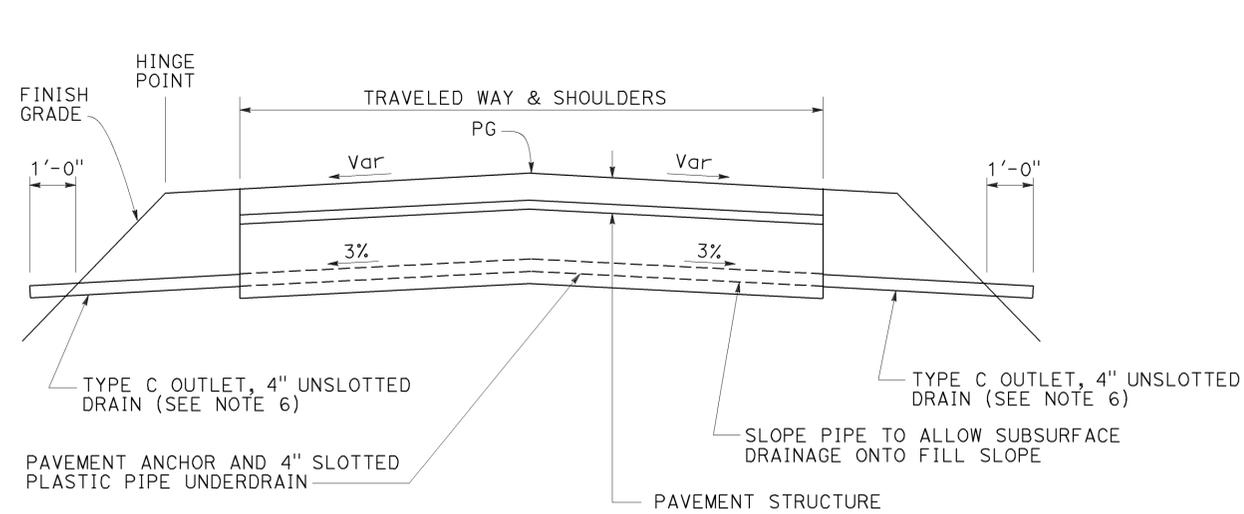


PAVEMENT ANCHOR PROFILE

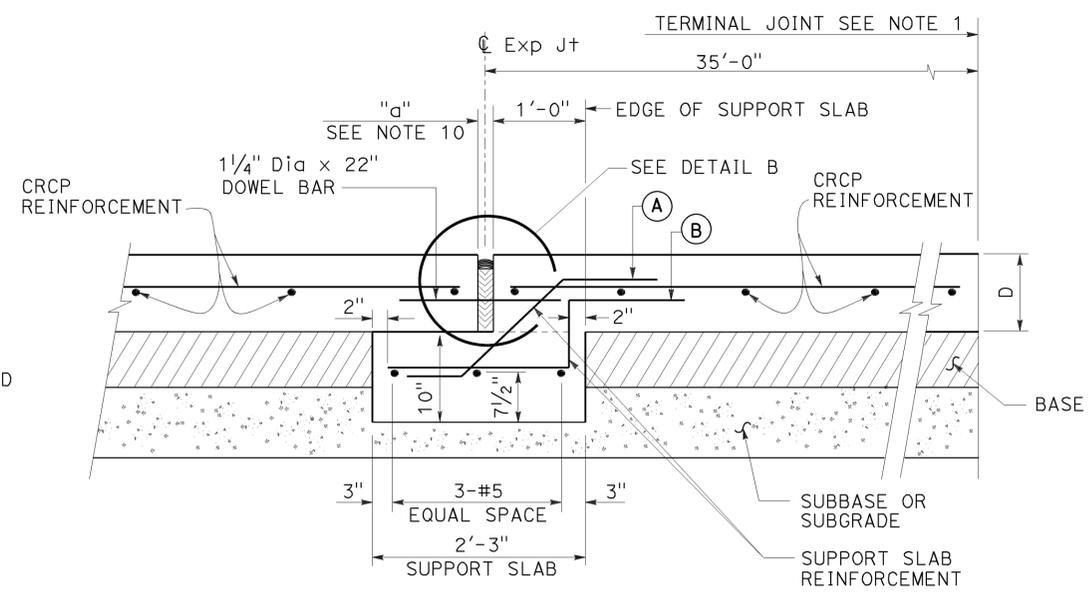

EXPANSION JOINT TYPE AN

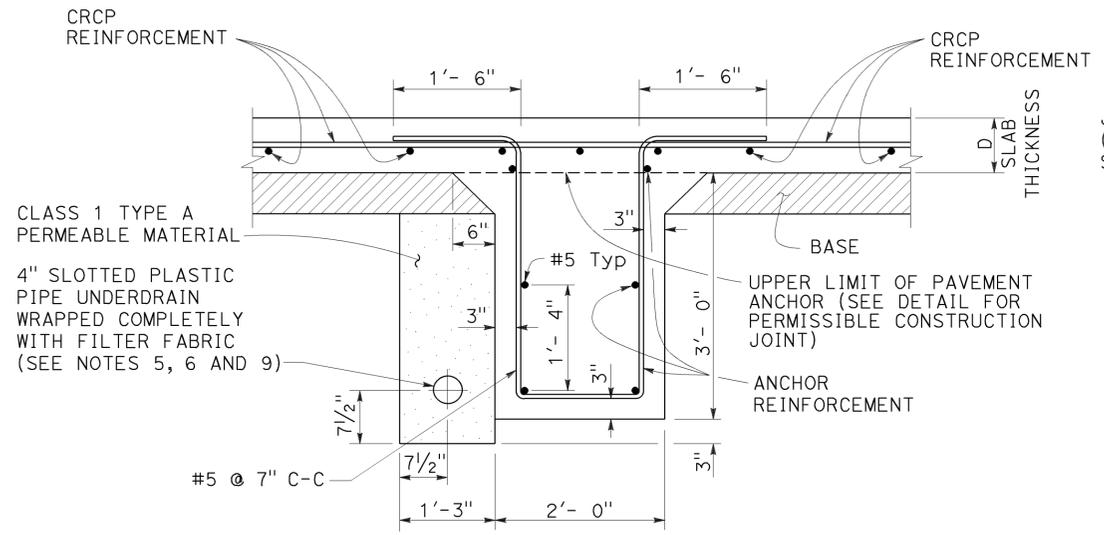

PAVEMENT ANCHOR

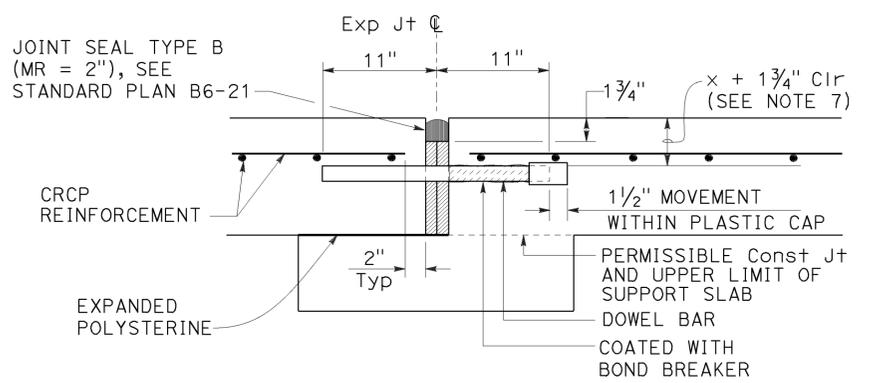


DETAIL B


(For layout, tolerances, and other details not shown, see Revised Standard Plan RSP P10.)

NOTES:

1. For the locations of the terminal joints, expansion joints and pavement anchors, see project plans.
2. The CRCP shall continue across the pavement anchor and expansion joints as shown.
3. Details of reinforcement, tie bars, and longitudinal joints (and if necessary, transverse construction joints) are shown on Revised Standard Plan RSP P4.
4. Transverse construction joints are not allowed within 20'-0" of the pavement anchor.
5. When placing pipe through concrete barrier, use 4" unslotted plastic pipe wrapped completely with 3/8" polystyrene.
6. See Standard Plan D99B for details not shown.
7. See Revised Standard Plan RSP P4 for "x".
8. D = thickness of CRCP
9. Place the 4" Slotted Plastic Pipe on the high side of the longitudinal grade.
10. See Standard Plan B6-21 for "a".

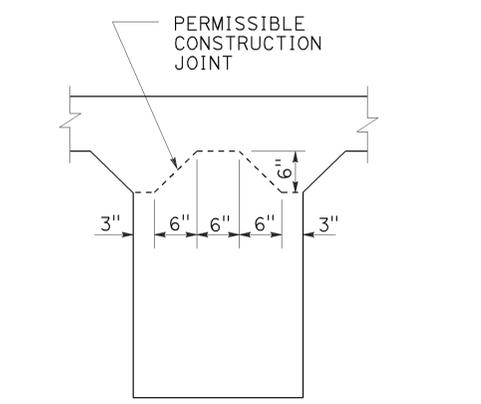

PAVEMENT ANCHOR DETAIL SHOWING PERMISSIBLE CONSTRUCTION JOINT

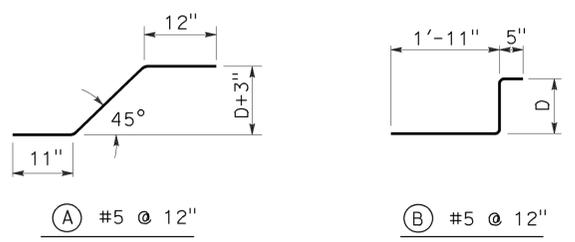

REINFORCEMENT DETAIL

STATE OF CALIFORNIA
DEPARTMENT OF TRANSPORTATION

**CONTINUOUSLY REINFORCED
CONCRETE PAVEMENT-
EXPANSION JOINT AND ANCHOR DETAILS**

NO SCALE

RSP P31B DATED APRIL 20, 2012 SUPERSEDES STANDARD PLAN P31B
DATED MAY 20, 2011 - PAGE 139 OF THE STANDARD PLANS BOOK DATED 2010.


REVISED STANDARD PLAN RSP P31B

Dist	COUNTY	ROUTE	POST MILES TOTAL PROJECT	SHEET No.	TOTAL SHEETS
05	SB	101	2.2/3.3	461	786

Florante E. Bautista
 REGISTERED CIVIL ENGINEER
 April 20, 2012
 PLANS APPROVAL DATE
THE STATE OF CALIFORNIA OR ITS OFFICERS OR AGENTS SHALL NOT BE RESPONSIBLE FOR THE ACCURACY OR COMPLETENESS OF SCANNED COPIES OF THIS PLAN SHEET.




TO ACCOMPANY PLANS DATED 12-7-15

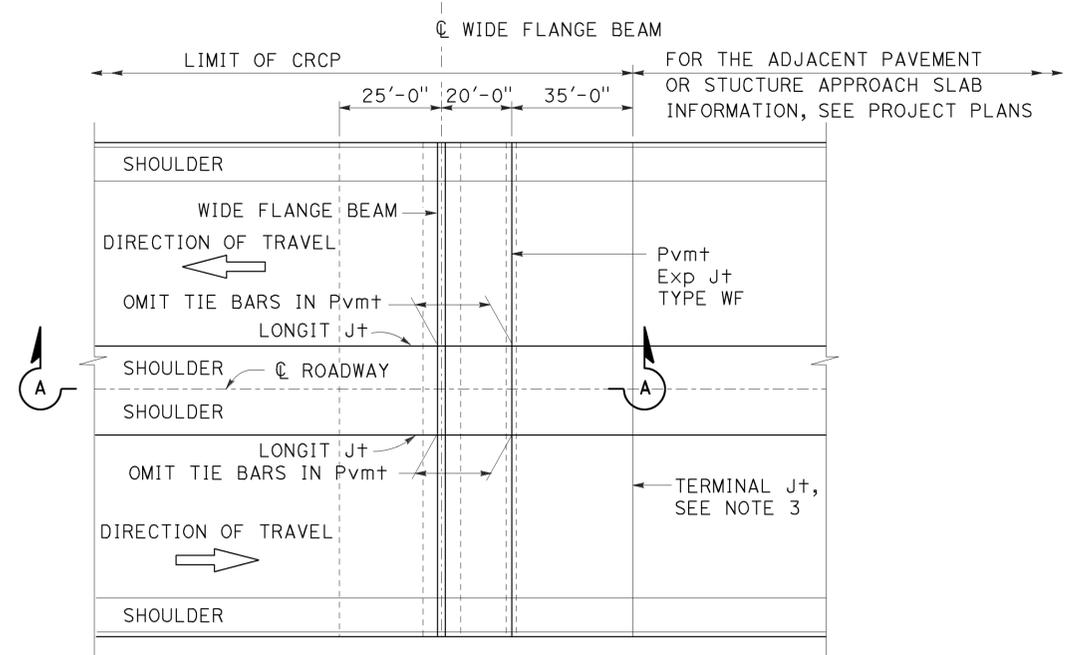


PLAN

NOTES:


1. For additional details on reinforcement member quantities of the wide flange beam terminal and Pavement Expansion Joint Type WF, see Revised Standard Plan RSP P32B.
2. For reinforcement (A), (B), and (C) Details, see Revised Standard Plan RSP P32B.
3. For the Pavement Terminal Joint Details, see Standard Plan P31A. For Pavement Terminal Joint Type, see Project Plans.
4. See Revised Standard Plan RSP P4 for "x".
5. D = Thickness of CRCP
6. See Standard Plan B6-21 for "a".

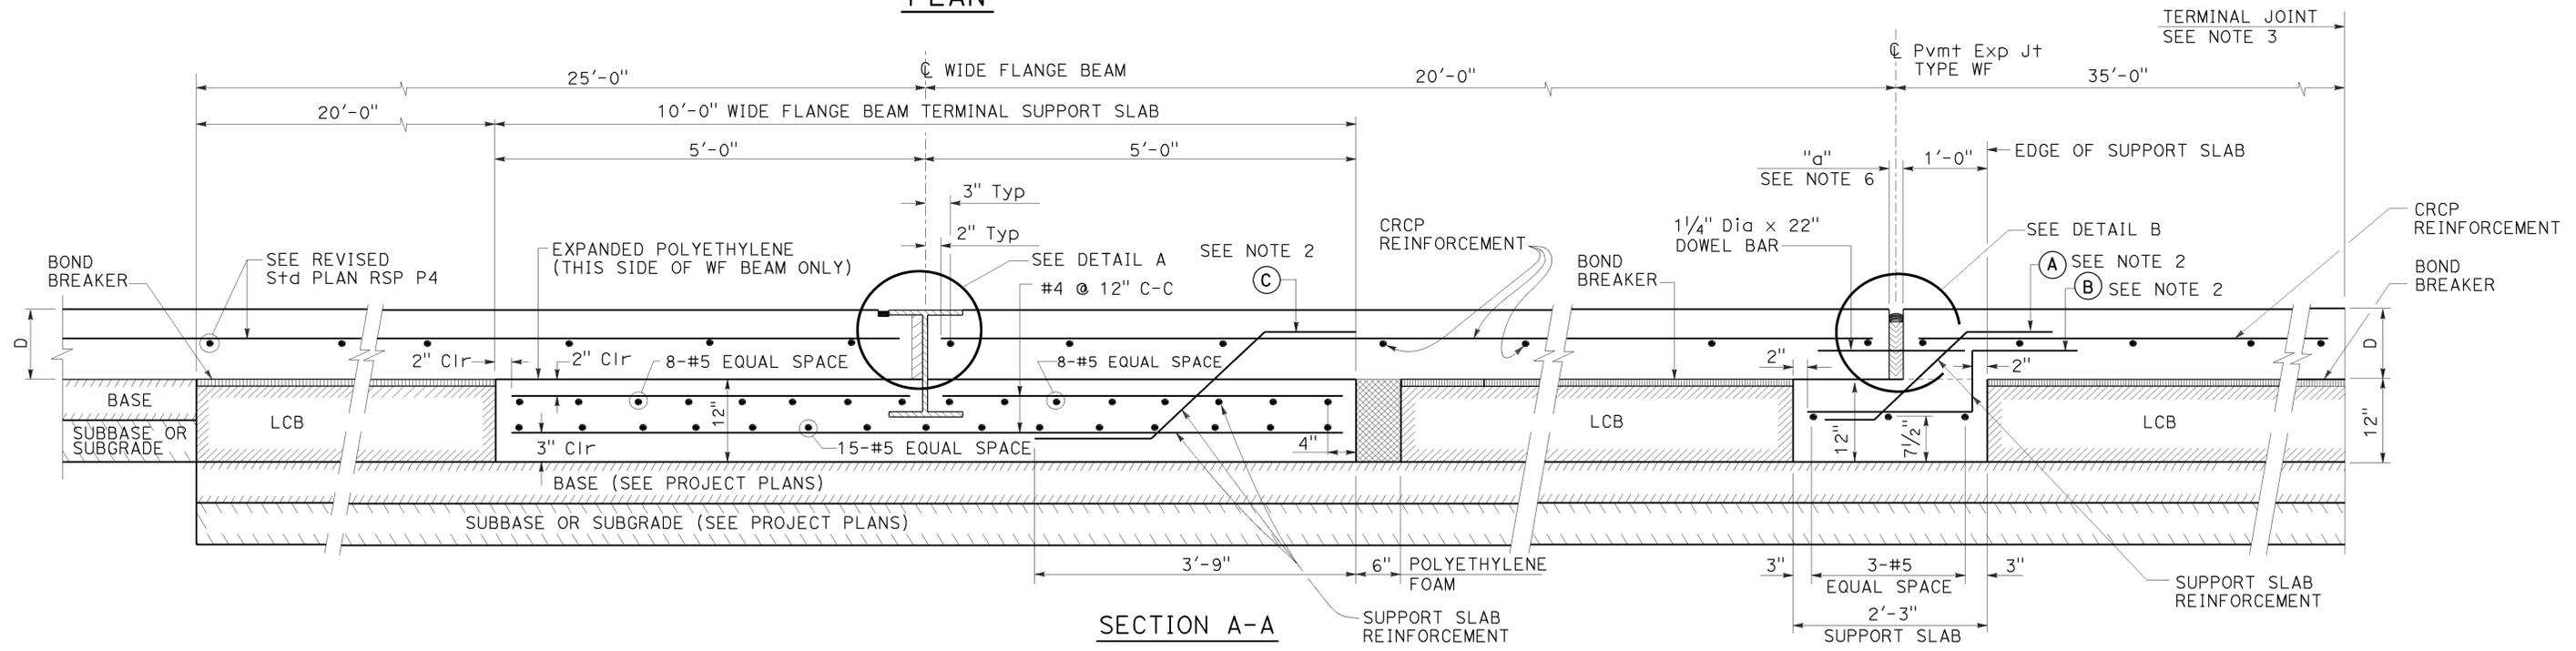

SECTION A-A

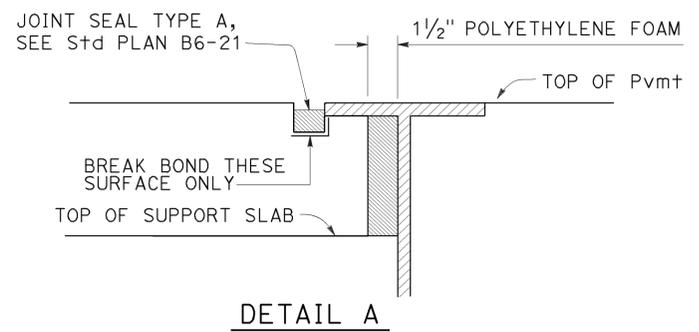

DETAIL A

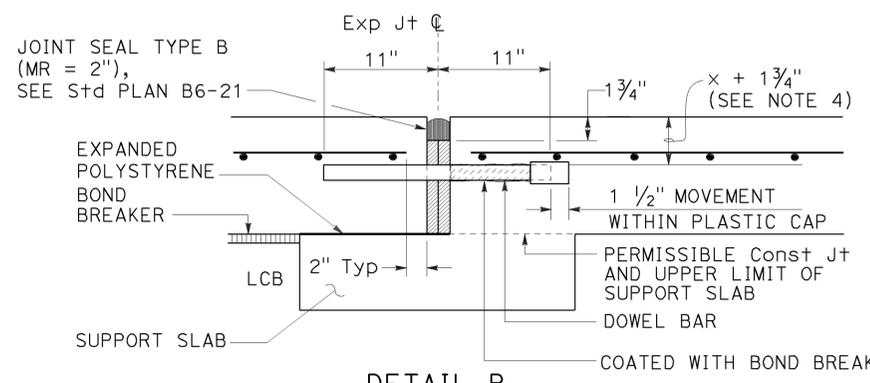

DETAIL B

STATE OF CALIFORNIA
 DEPARTMENT OF TRANSPORTATION
**CONTINUOUSLY REINFORCED
 CONCRETE PAVEMENT -
 WIDE FLANGE BEAM TERMINALS**

NO SCALE

RSP P32A DATED APRIL 20, 2012 SUPERSEDES STANDARD PLAN P32A
 DATED MAY 20, 2011 - PAGE 140 OF THE STANDARD PLANS BOOK DATED 2010.

REVISED STANDARD PLAN RSP P32A


For layout, tolerances, and other details not shown see Revised Std Plan RSP P10.

2010 REVISED STANDARD PLAN RSP P32A


TO ACCOMPANY PLANS DATED 12-7-15

- LEGEND:**
- b_f - FLANGE WIDTH
 - t_f - FLANGE THICKNESS
 - t_w - WEB THICKNESS
 - d_b - BEAM DEPTH
 - D1 - PAVEMENT THICKNESSES
 - D2 - PAVEMENT THICKNESSES


- NOTES:**
1. Studs must be electric arc end welded with complete fusion. Any stud dislodged in shipping or that can be dislodged by hammer must be replaced.
 2. Weld 3/8" plate to each end of wide flange beam at pavement edges only. End plate covers the entire wide flange beam.
 3. Extend polyethylene foam to the sides and edges of the front part of the plate.

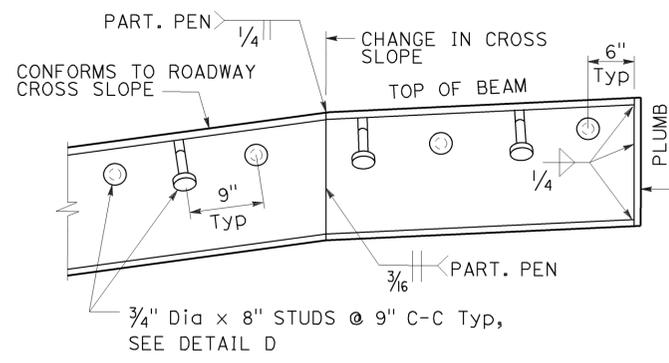

WIDE FLANGE DETAIL

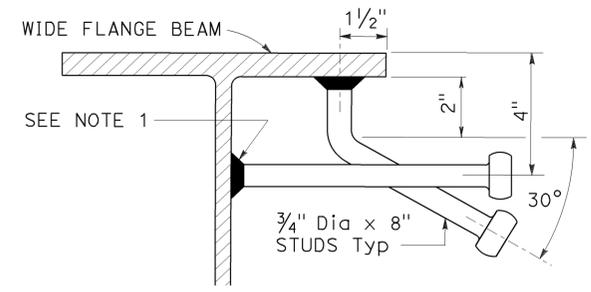


DETAIL D

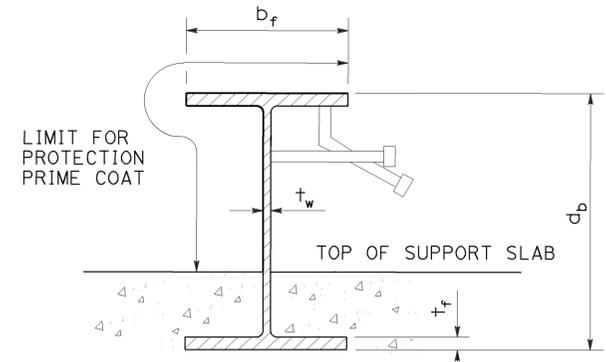


WIDE FLANGE PAINTING DETAIL


See "TABLE OF BEAM SIZES"

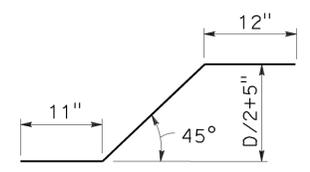


(A) #5 @ 12"

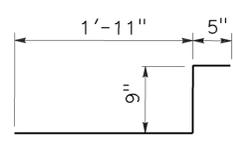


(B) #5 @ 12"

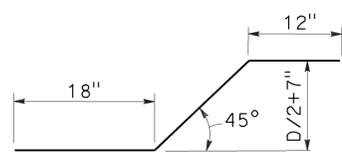


(C) #4 @ 12"

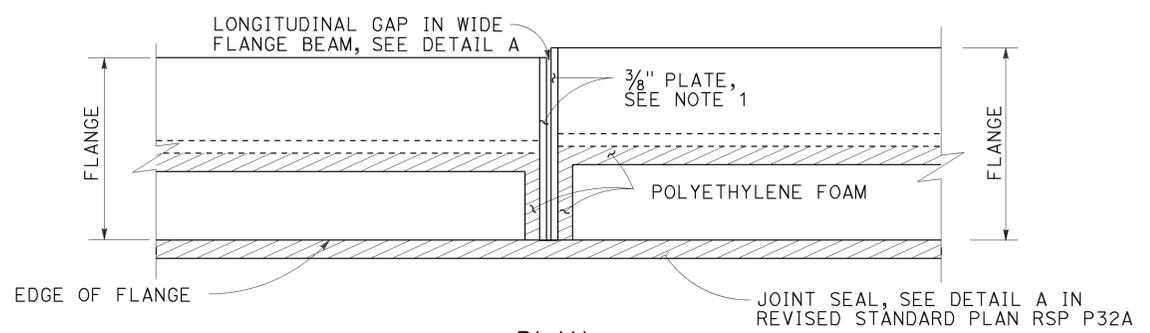


PLAN

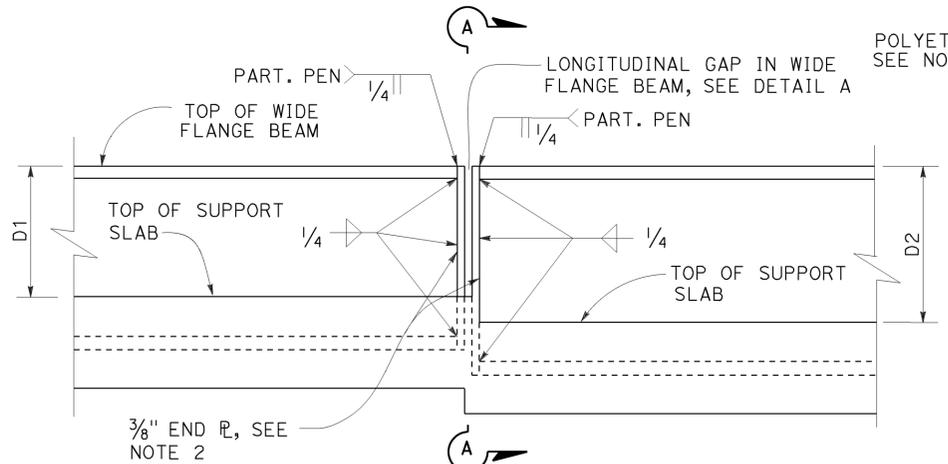

ELEVATION

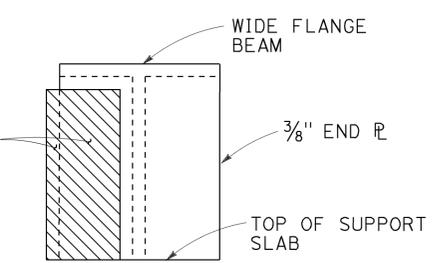

SECTION A-A

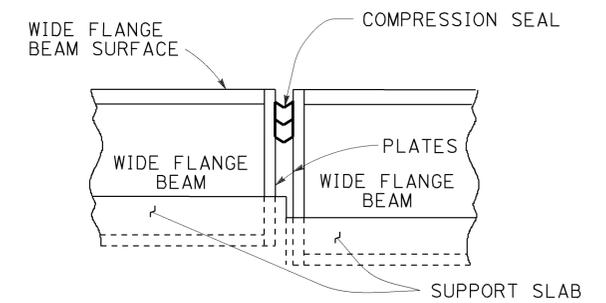

DETAIL A

PAVEMENT THICKNESS	WIDE FLANGE BEAM DESIGNATION	d _b	b _f	t _f	t _w
.75'	W14 x 43	13.70"	8.00"	0.53"	0.31"
.80'	W14 x 68	14.04"	10.04"	0.72"	0.42"
.85'	W16 x 89	16.75"	10.37"	0.88"	0.53"
.90'	W16 x 89	16.75"	10.37"	0.88"	0.53"
.95'	W18 x 97	18.59"	11.15"	0.87"	0.54"
1.00'	W18 x 97	18.59"	11.15"	0.87"	0.54"
1.05'	W18 x 97	18.59"	11.15"	0.87"	0.54"
1.10'	W18 x 97	18.59"	11.15"	0.87"	0.54"

ITEM	PAVEMENT THICKNESS								
	.75'	.80'	.85'	.90'	.95'	1.00'	1.05'	1.10'	
WIDE FLANGE BEAM	CONCRETE	4.8 CY	4.8 CY	4.8 CY	4.8 CY	4.8 CY	4.8 CY	4.8 CY	
TERMINAL SLAB	REINFORCING STEEL	552.0 LBS	552.2 LBS	552.4 LBS	552.6 LBS	552.8 LBS	553.0 LBS	553.1 LBS	553.3 LBS
Exp JOINT TYPE	CONCRETE	1.1 CY	1.1 CY	1.1 CY	1.1 CY	1.1 CY	1.1 CY	1.1 CY	
WIDE FLANGE SUPPORT SLAB	REINFORCING STEEL	99.9 LBS	99.9 LBS	100.2 LBS	100.5 LBS	100.8 LBS	101.1 LBS	101.1 LBS	101.6 LBS
STEEL BEAM (WEIGHT OF WIDE FLANGE BEAM AND STUDS)		43.0 LBS/LF +2 PLATES @ 14.9 LBS EA	69.51 LBS/LF +2 PLATES @ 14.9 LBS EA	90.51 LBS/LF +2 PLATES @ 18.5 LBS EA	90.51 LBS/LF +2 PLATES @ 18.5 LBS EA	98.51 LBS/LF +2 PLATES @ 22.0 LBS EA	98.51 LBS/LF +2 PLATES @ 22.0 LBS EA	98.51 LBS/LF +2 PLATES @ 22.0 LBS EA	98.51 LBS/LF +2 PLATES @ 22.0 LBS EA

STATE OF CALIFORNIA
DEPARTMENT OF TRANSPORTATION

**CONTINUOUSLY REINFORCED
CONCRETE PAVEMENT
WIDE FLANGE BEAM TERMINALS**

NO SCALE

RSP P32B DATED JULY 19, 2013 SUPERSEDES RSP P32B DATED APRIL 20, 2012 AND STANDARD PLAN P32B DATED MAY 20, 2011 - PAGE 141 OF THE STANDARD PLANS BOOK DATED 2010.

2010 REVISED STANDARD PLAN RSP P32B

Dist	COUNTY	ROUTE	POST MILES TOTAL PROJECT	SHEET No.	TOTAL SHEETS
05	SB	101	2.2/3.3	463	786

Srikanth N. Balasubramanian
REGISTERED CIVIL ENGINEER


October 30, 2015
PLANS APPROVAL DATE

THE STATE OF CALIFORNIA OR ITS OFFICERS OR AGENTS SHALL NOT BE RESPONSIBLE FOR THE ACCURACY OR COMPLETENESS OF SCANNED COPIES OF THIS PLAN SHEET.


Srikanth N. Balasubramanian
REGISTERED PROFESSIONAL ENGINEER
No. C56426
Exp. 6-30-17
CIVIL
STATE OF CALIFORNIA

TO ACCOMPANY PLANS DATED 12-7-15


ABBREVIATIONS:
TE TAPERED EDGE

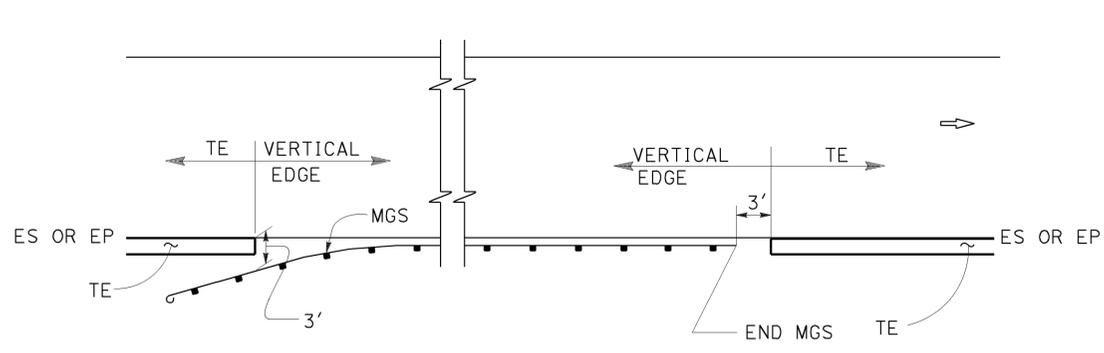


MGS

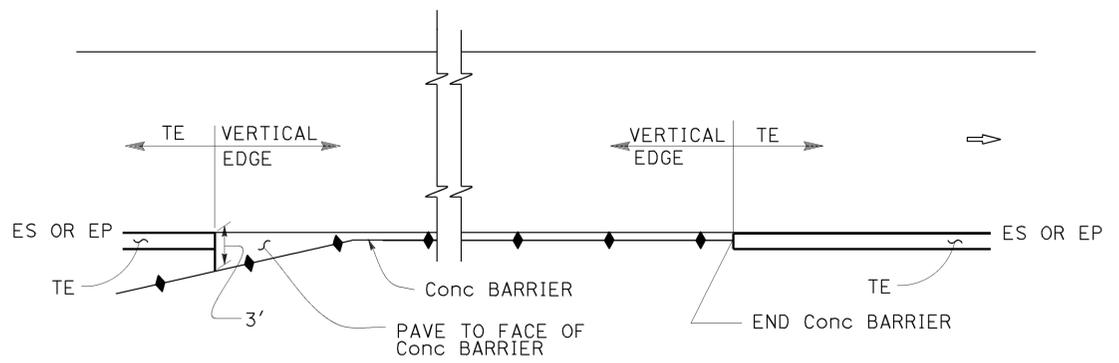


CONCRETE BARRIER

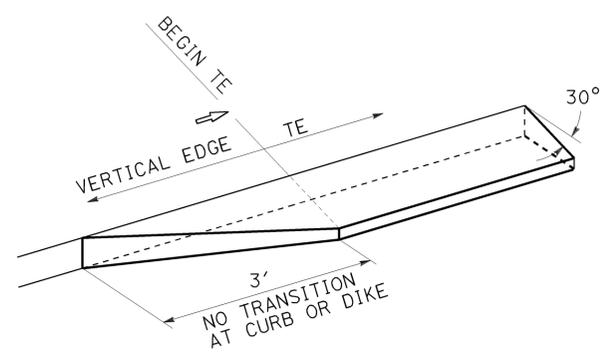

TRANSITION DETAIL FOR CONCRETE ONLY

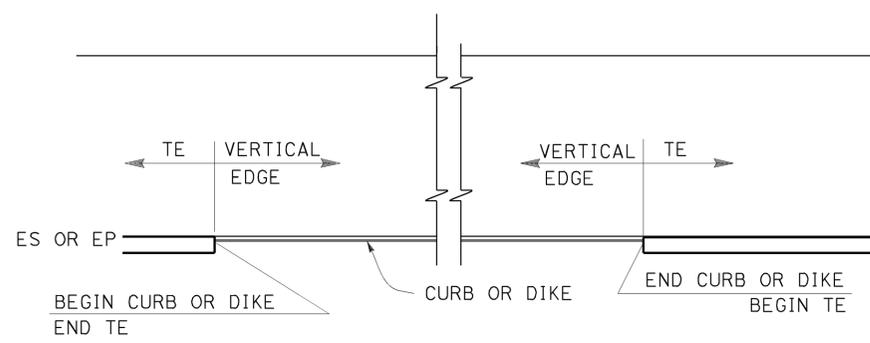


CURB OR DIKE

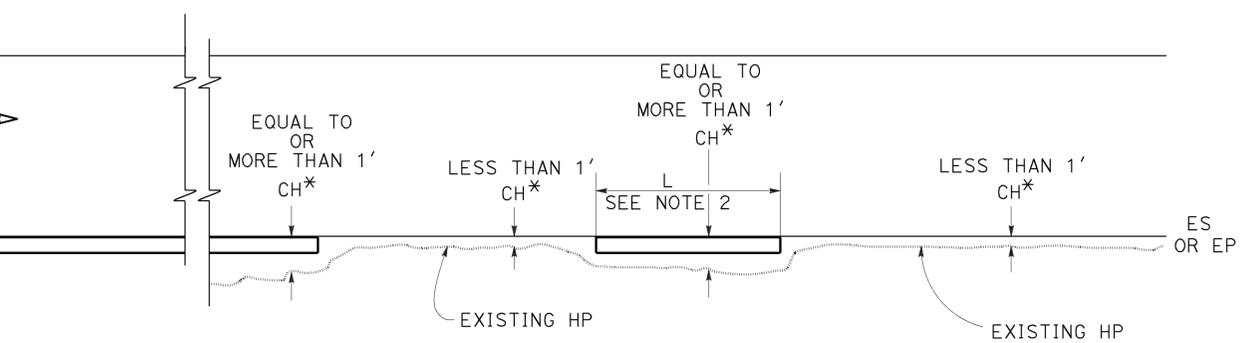


NARROW SIDE SLOPE

* CH = Distance from ES or EP to existing HP.

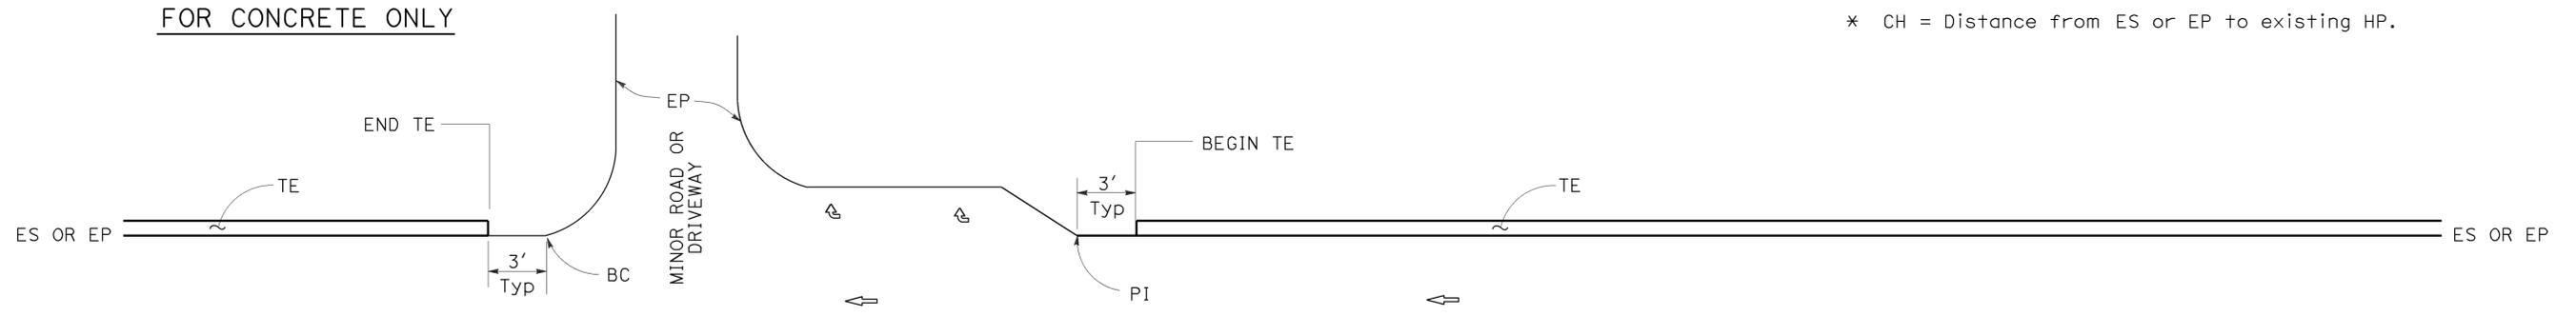

STATE ROUTE

STATE ROUTE

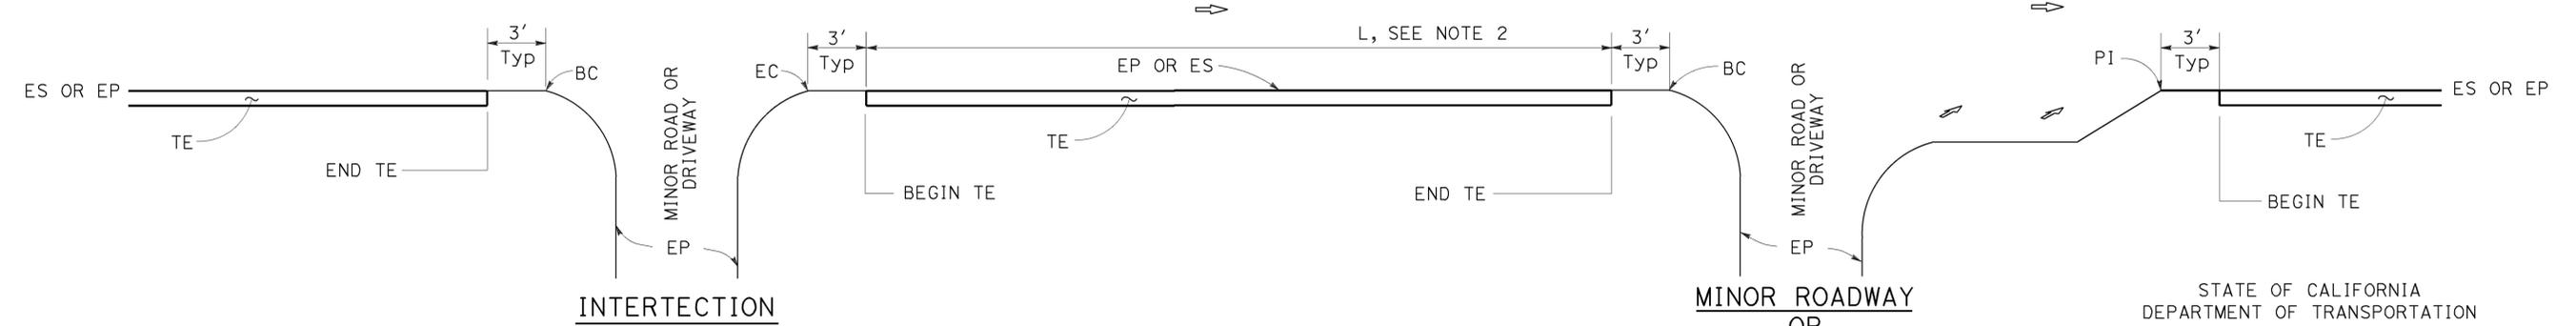

INTERSECTION

DRIVEWAY AND INTERSECTION

MINOR ROADWAY OR DRIVEWAY

STATE OF CALIFORNIA
DEPARTMENT OF TRANSPORTATION
PAVEMENT EDGE TREATMENTS
NO SCALE

NOTES:

1. For details not shown, see Revised Standard Plans RSP P75 and RSP P76.
2. Tapered edge is optional when L is less than 30'.

RSP P74 DATED OCTOBER 30, 2015 SUPERSEDES RSP P74 DATED NOVEMBER 15, 2013 AND RSP P74 DATED JANUARY 20, 2012 THAT SUPPLEMENTS THE STANDARD PLANS BOOK DATED 2010.

REVISED STANDARD PLAN RSP P74

2010 REVISED STANDARD PLAN RSP P74

Dist	COUNTY	ROUTE	POST MILES TOTAL PROJECT	SHEET No.	TOTAL SHEETS
05	SB	101	2.2/3.3	464	786

Srikanth N. Balasubramanian
REGISTERED CIVIL ENGINEER

October 30, 2015
PLANS APPROVAL DATE

Srikanth N. Balasubramanian
No. C56426
Exp. 6-30-17
CIVIL
STATE OF CALIFORNIA

THE STATE OF CALIFORNIA OR ITS OFFICERS OR AGENTS SHALL NOT BE RESPONSIBLE FOR THE ACCURACY OR COMPLETENESS OF SCANNED COPIES OF THIS PLAN SHEET.


LEGEND:

-  HMA PAVEMENT
-  HMA OR CONCRETE PAVEMENT
-  CONCRETE PAVEMENT


ABBREVIATIONS:

- TE TAPERED EDGE
- TT TOTAL THICKNESS OF TE
- HW HINGE WIDTH, DISTANCE FROM ES OR EP TO HP


TO ACCOMPANY PLANS DATED 12-7-15

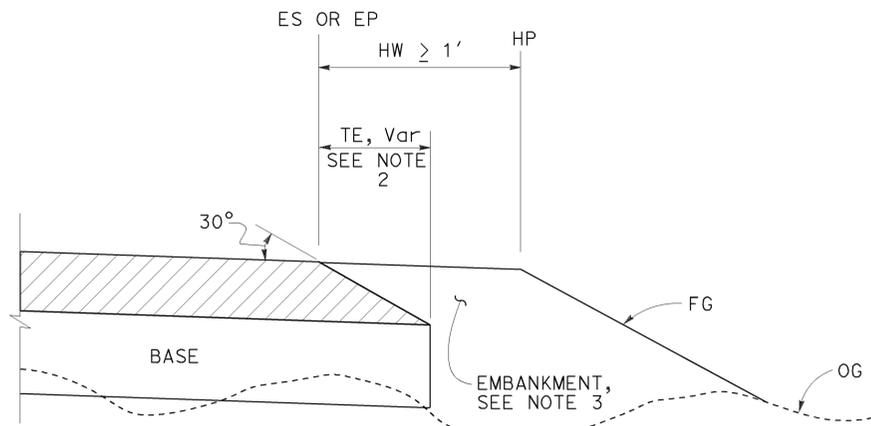


CASE K
Tapered Edge - Fill Section, HW $\geq 1'$

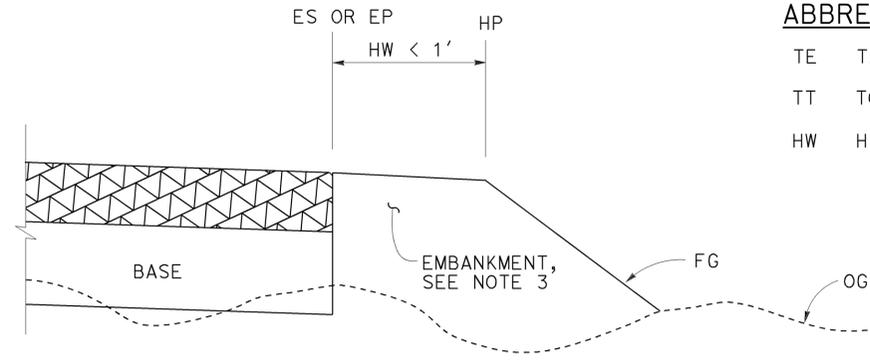


CASE L
Vertical Edge - Fill Section, HW $< 1'$

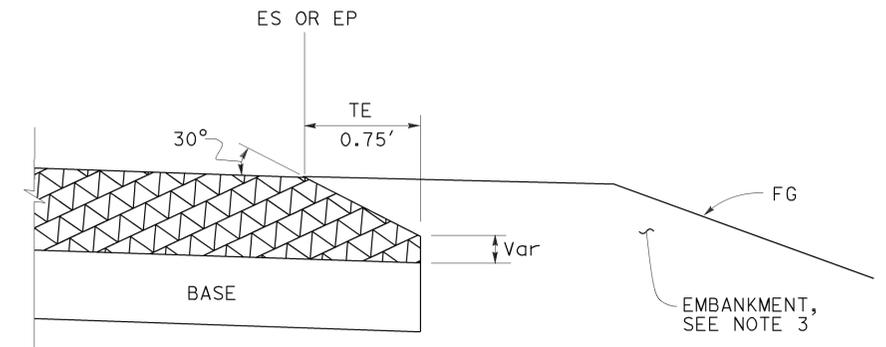


DETAIL "B"
For HMA pavement thickness more than 0.43' or concrete pavement

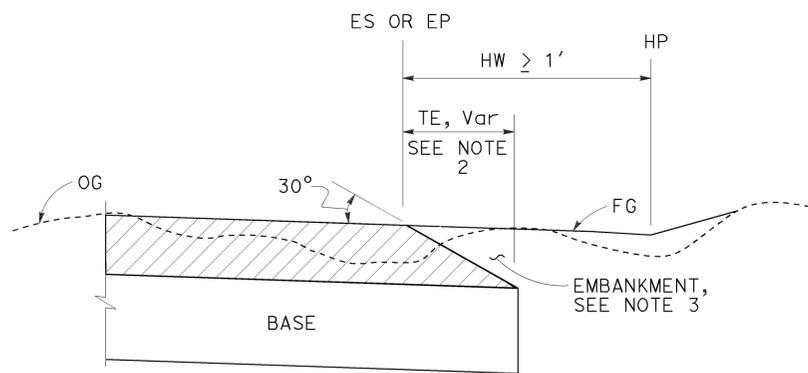

CASE M
Tapered Edge - Cut Section, HW $\geq 1'$

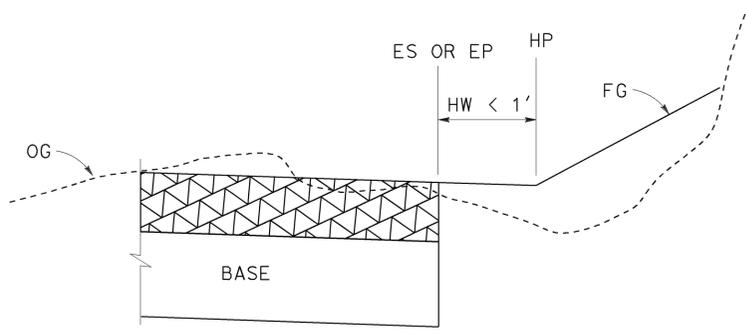

CASE N
Vertical Edge - Cut Section, HW $< 1'$

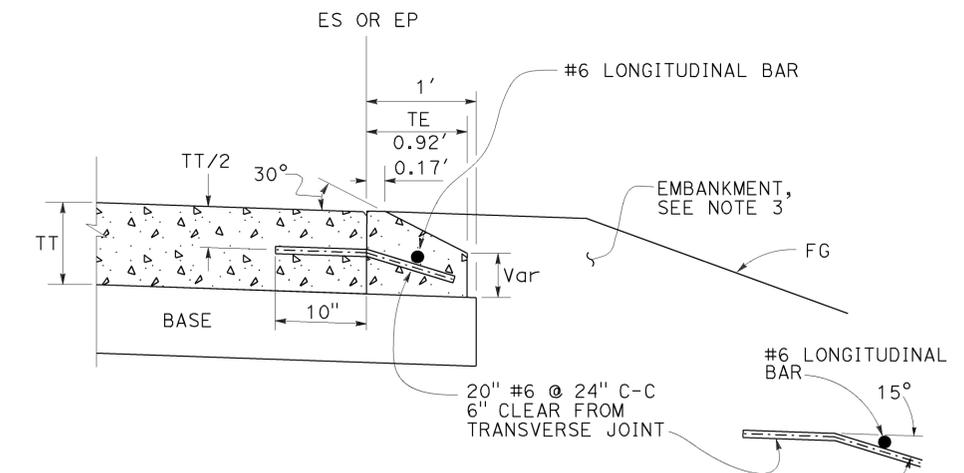

OPTIONAL DETAIL "B"
For concrete pavement
See Note 4

FILL SECTION

CUT SECTION

NOTES:

1. For limits of tapered edge and vertical edge treatments, see Revised Standard Plan RSP P74
2. Details shown for HMA pavement thickness less than 0.43'. See Detail "B" for HMA pavement thickness more than 0.43' or concrete pavement.
3. For locations and limits of embankment see project plans.
4. Tapered edge transverse joint must match pavement transverse joint. End of #6 longitudinal bar must be 2" $\pm 1/2$ " clear from transverse joint.
5. Tapered edge is not needed in the area of MGS, barrier, right turn lane and acceleration lane. See Revised Standard Plan RSP P74.

STATE OF CALIFORNIA
DEPARTMENT OF TRANSPORTATION
**PAVEMENT EDGE TREATMENTS-
NEW CONSTRUCTION**
NO SCALE

RSP P76 DATED OCTOBER 30, 2015 SUPERSEDES RSP P76 DATED NOVEMBER 15, 2013 AND RSP P76 DATED JANUARY 20, 2012 THAT SUPPLEMENTS THE STANDARD PLANS BOOK DATED 2010.

REVISED STANDARD PLAN RSP P76

2010 REVISED STANDARD PLAN RSP P76


Dist	COUNTY	ROUTE	POST MILES TOTAL PROJECT	SHEET No.	TOTAL SHEETS
05	SB	101	2.2/3.3	465	786

Glenn DeCou
REGISTERED CIVIL ENGINEER

October 19, 2012
PLANS APPROVAL DATE

Glenn DeCou
No. C34547
Exp. 9-30-13
CIVIL
STATE OF CALIFORNIA

THE STATE OF CALIFORNIA OR ITS OFFICERS OR AGENTS SHALL NOT BE RESPONSIBLE FOR THE ACCURACY OR COMPLETENESS OF SCANNED COPIES OF THIS PLAN SHEET.

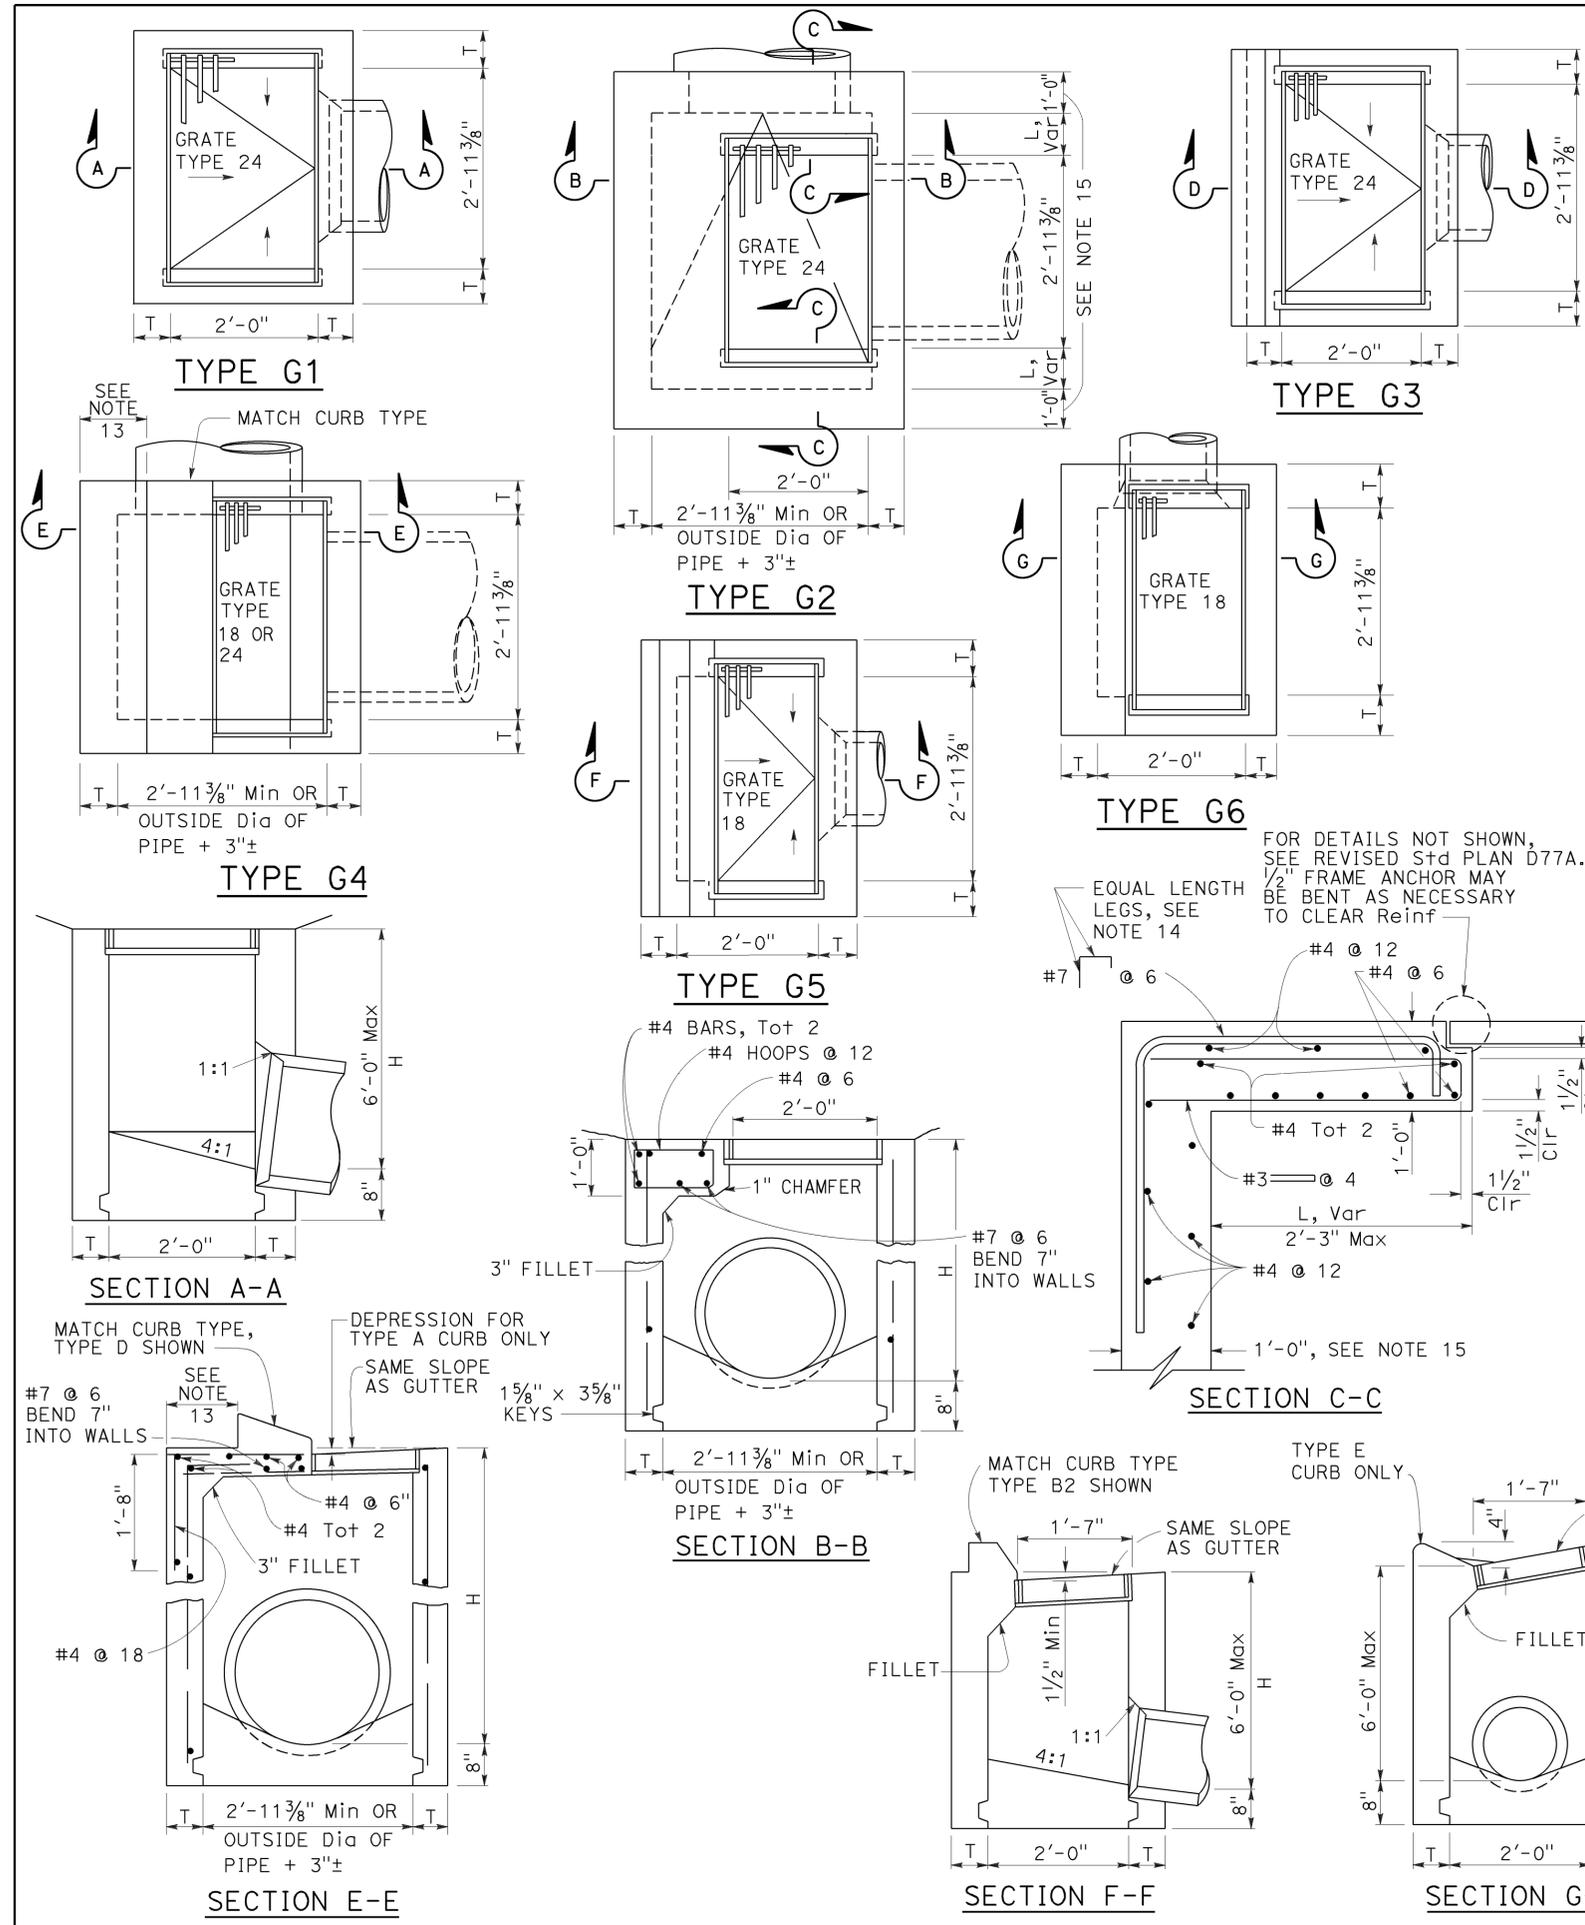

NOTES:

- "H" is the difference in elevation between the outlet pipe flow line and the normal gutter grade line undepressed.
- For "T" wall thickness, see Table A below.
- Wall reinforcing not required when "H" is 8'-0" or less and the unsupported width or length is 7'-0" or less. Walls exceeding these limits shall be reinforced with #4 bars @ 1'-6" ± centers placed 1 1/2" clear to inside of box unless otherwise shown.
- Inlet bottom reinforcing not required. See Standard Plan D74C for alternative reinforced bottom and alternative half round bottom.
- Steps-None required where "H" is less than 2'-6". Where "H" is 2'-6" or more, install steps with lowest rung 1'-0" above the floor and highest rung not more than 6" below top of inlet. The distance between steps shall not exceed 1'-0" and shall be uniform throughout the length of the wall. Place steps in the wall without an opening. Steps inserts may be substituted for the bar steps. Step inserts shall comply with State Industrial Safety requirements. See Standard Plan D74C for step details.
- Details shown apply to both metal and concrete pipe.
- Pipe(s) can be placed in any wall.
- Curb section shall match adjacent curb.
- Basin floors shall have wood trowel finish and a minimum slope of 12:3 from all directions toward outlet pipe.
- Set inlet so that grate bars are parallel to direction of principal surface flow.
- See Revised Standard Plans D77A and D77B for grate and frame details and weights of miscellaneous iron and steel.
- See Standard Plan D78A for gutter depression details.
- This dimension will vary with different grates, curbs types, box width and wall thickness.
- Bar may be rotated as necessary to clear opening. Where "L" is 6" or less, bar may be omitted.
- Where "L" is 6" or less, wall thickness shall be as shown in Table A.
- Cast-in-place inlets to be formed around all pipes/stubs intersecting the inlet, and concrete poured in one continuous operation. Precast inlets shall have mortared connections conforming to details for Type GCP Inlet shown on Standard Plan D75B. See Standard Specifications for mortar composition.

TABLE A

TYPE	CONCRETE QUANTITIES			
	H=3'-0" TO 8'-0" (T=6")	H=8'-1" TO 20'-0" (T=8")	H=8'-1" (CY)	ADDITIONAL PCC PER FOOT (CY)
G-1	0.95	0.220	See Note A	SEE NOTE A
G-2*	1.31	0.255	3.50	0.357
G-3	1.03	0.220	See Note A	SEE NOTE A
G-4* (TYPE 24)	1.27	0.255	3.48	0.357
G-4* (TYPE 18)	1.30	0.255	3.50	0.357
G-5	1.02	0.220	SEE NOTE A	SEE NOTE A
G-6	1.04	0.220	SEE NOTE A	SEE NOTE A

TABLE BASED ON 8" FLOOR SLAB. NO DEDUCTIONS ARE TO BE MADE TO THESE QUANTITIES BECAUSE OF PIPE OPENINGS, DIFFERENT FLOOR ALTERNATIVES OR DIFFERENT CURB TYPES. * QUANTITIES FOR TYPE G-2 AND G-4 INLETS BASED ON THE MINIMUM INTERIOR DIMENSIONS.

NOTE A:

Maximum allowable height 6'-0".

STATE OF CALIFORNIA
DEPARTMENT OF TRANSPORTATION


DRAINAGE INLETS
NO SCALE

RSP D73 DATED OCTOBER 19, 2012 SUPERSEDES STANDARD PLAN D73 DATED MAY 20, 2011 - PAGE 156 OF THE STANDARD PLANS BOOK DATED 2010.


REVISED STANDARD PLAN RSP D73

2010 REVISED STANDARD PLAN RSP D73

TO ACCOMPANY PLANS DATED 12-7-15

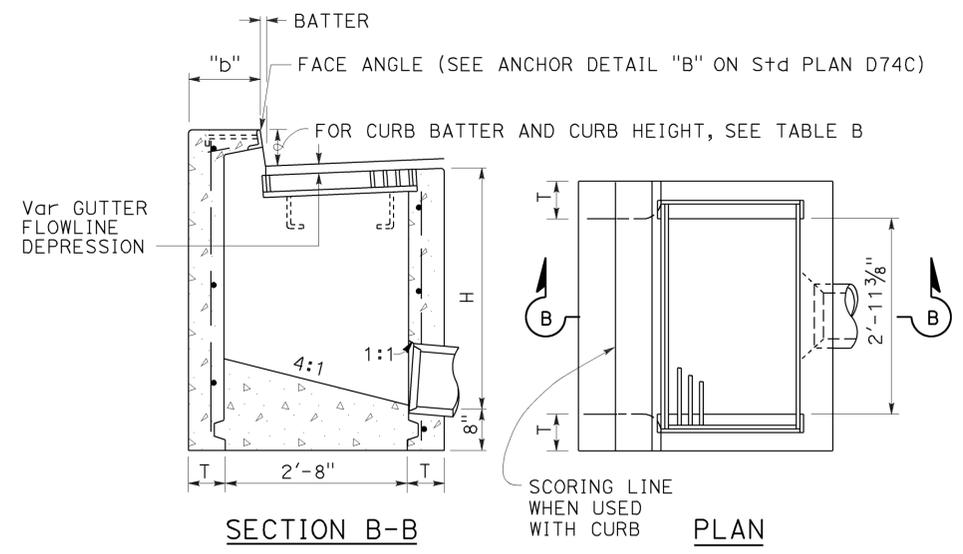


TYPE GO

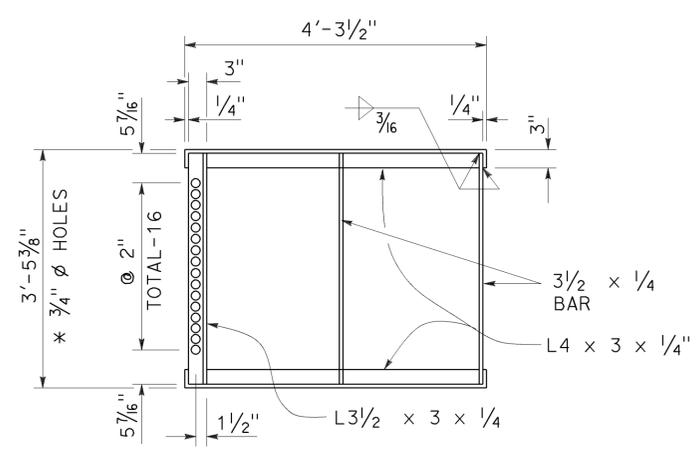


* 3/4" ϕ Holes required only with trash rack


GRATE FRAME FOR TYPE GDO INLET

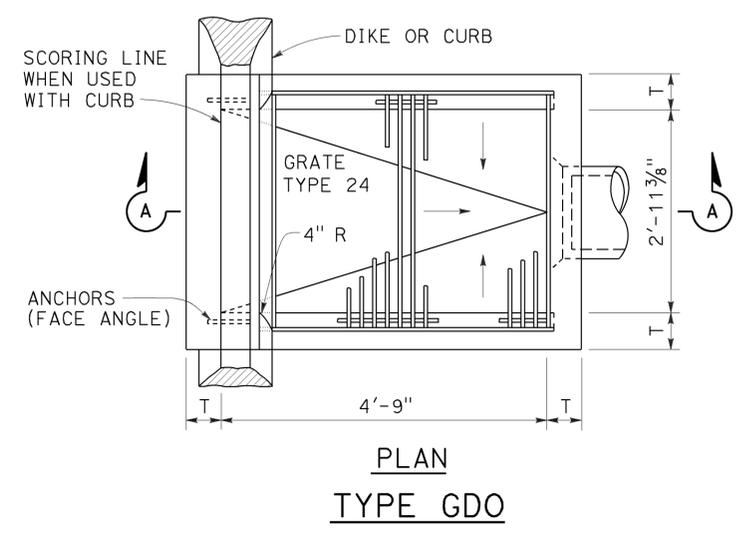

PLAN TYPE GDO

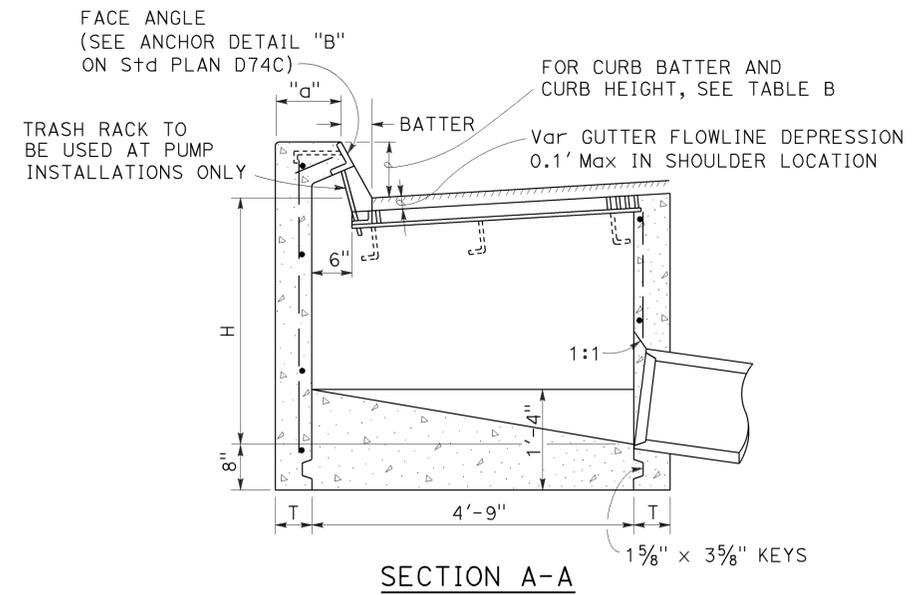

SECTION A-A

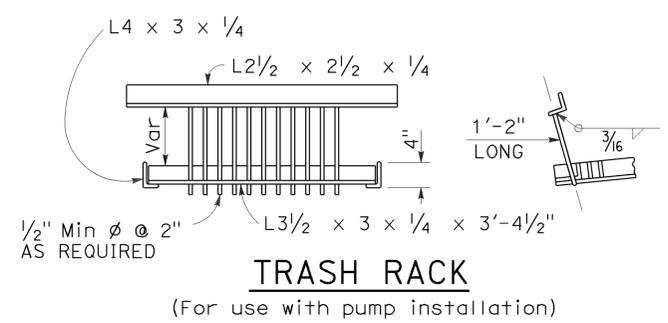

TRASH RACK
(For use with pump installation)

TABLE A
CONCRETE QUANTITIES

TYPE	H=3'-0" TO 8'-0" (T=6")		H=8'-1" TO 20'-0" (T=8")	
	H=3'-0" (CY)	ADDITIONAL PCC PER FOOT (CY)	H=8'-1" (CY)	ADDITIONAL PCC PER FOOT (CY)
GO	1.24	0.245	3.39	0.346
GDO	1.62	0.322	4.36	0.446

Table based on 8" floor slab, and curb type giving highest quantity of concrete. no deductions or adjustments are to be made to these quantities because of pipe openings, different floor alternatives or different curb type.

TABLE B

CURB TYPE	NORMAL CURB HEIGHT	CURB BATTER	"a" DIMENSION	"b" DIMENSION
A1-6	6"	1 1/2"	T+7 1/2"	T+6 1/2"
A1-8	8"	2"	T+7"	T+6"
B1-6	6"	4"	T+5"	T+4"
TYPE A DIKE	6"	3"	T+6"	T+5"

NOTES:

- "H" is the difference in elevation between the outlet pipe flow line and the normal gutter grade line undeepressed.
- For "T" wall thickness, see Table A below.
- Wall reinforcing not required when "H" is 8'-0" or less and the unsupported width or length is 7'-0" or less. Walls exceeding these limits shall be reinforced with #4 @ 18"± centers placed 1/2" clear to inside of box unless otherwise shown.
- Inlet bottom reinforcing not required. See Standard Plan D74C for alternative reinforced bottom.
- Steps - None required where "H" is less than 2'-6". Where "H" is 2'-6" or more, install steps with lowest rung 1'-0" above the floor and highest rung not more than 6" below top of inlet. The distance between steps shall not exceed 1'-0" and shall be uniform throughout the length of the wall. Place steps in the wall without an opening. Step inserts may be substituted for the bar steps. Step inserts shall comply with State Industrial Safety requirements. See Standard Plan D74C for step details.
- When shown on the project plans, place a 3/4" plain round protection bar horizontally across the length of the opening and bend back 4" into the inlet wall on each side.
- Pipe(s) can be placed in any wall.
- Curb section shall match adjacent curb.
- Basin floors shall have wood trowel finish and shall slope toward the outlet pipe as shown.
- See Revised Standard Plans RSP D77A and RSP D77B for grate and frame details and weights of miscellaneous iron and Steel.
- See Standard Plan D78A for gutter depression details.
- Complete joint penetration butt welds may be substituted for the fillet welds on all anchors.
- Standard square, hexagon, round or equivalent headed anchors may be substituted for the right angle hooks on the anchors shown on this plan.
- Cast-in-place inlets to be formed around all pipes/stubs intersecting the inlet and concrete poured in one continuous operation. Precast inlets shall have mortared pipe connections conforming to details for Type GCP inlets on Revised Standard Plan RSP D75B. See Standard Specifications for mortar composition.

STATE OF CALIFORNIA
DEPARTMENT OF TRANSPORTATION
DRAINAGE INLETS
NO SCALE

RSP D74B DATED OCTOBER 30, 2015 SUPERSEDES STANDARD PLAN D74B DATED MAY 20, 2011 - PAGE 159 OF THE STANDARD PLANS BOOK DATED 2010.



2010 REVISED STANDARD PLAN RSP D74B

Dist	COUNTY	ROUTE	POST MILES TOTAL PROJECT	SHEET No.	TOTAL SHEETS
05	SB	101	2.2/3.3	467	786



Raymond Don Tsztoo
 REGISTERED CIVIL ENGINEER
 October 30, 2015
 PLANS APPROVAL DATE
 THE STATE OF CALIFORNIA OR ITS OFFICERS OR AGENTS SHALL NOT BE RESPONSIBLE FOR THE ACCURACY OR COMPLETENESS OF SCANNED COPIES OF THIS PLAN SHEET.

REGISTERED PROFESSIONAL ENGINEER
 Raymond Don Tsztoo
 No. C37332
 Exp. 6-30-16
 CIVIL
 STATE OF CALIFORNIA



TO ACCOMPANY PLANS DATED 12-7-15

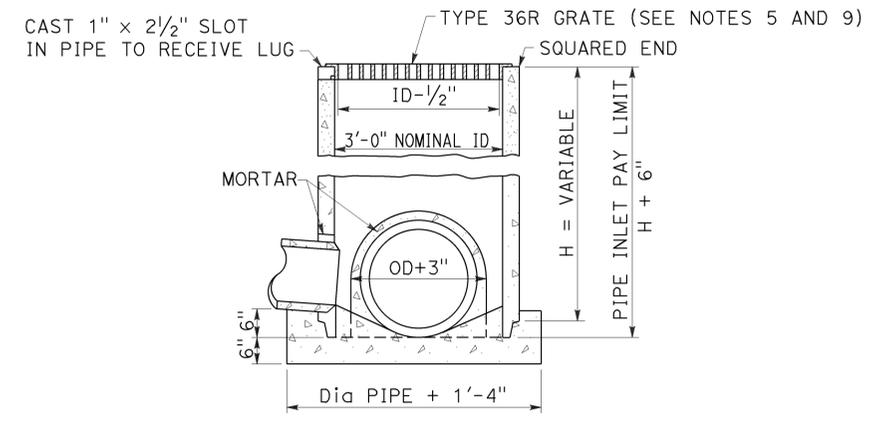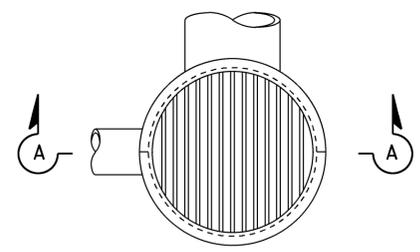


SECTION A-A
TYPE GCP
Concrete pipe inlet with grate

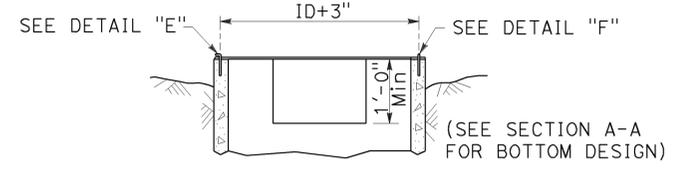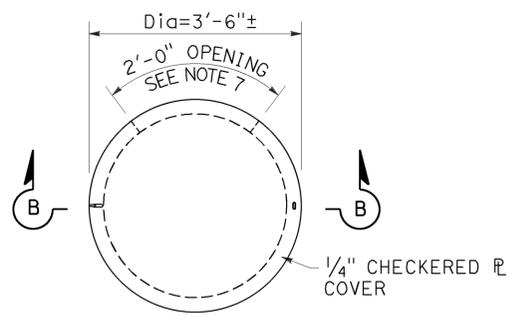


SECTION B-B
TYPE OCP or OCPI
Concrete pipe inlet with steel cover
(See Note 6)

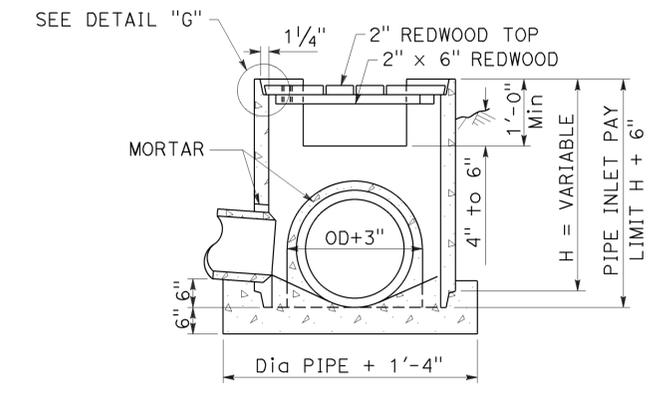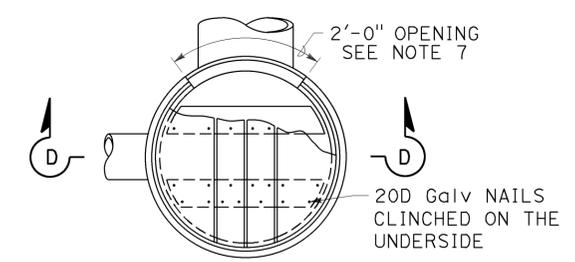

SECTION D-D
TYPE OCP or OCPI
Concrete pipe inlet with redwood cover
(See Notes 6 and 10)

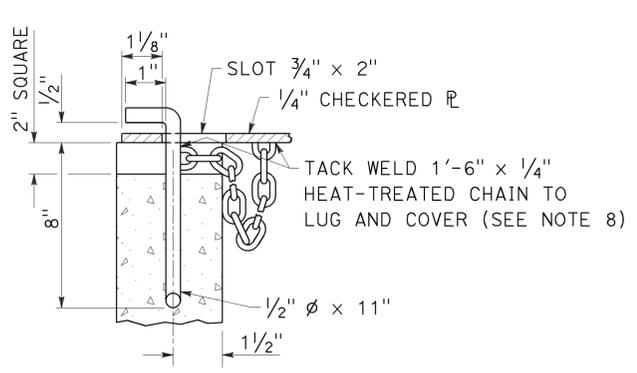


DETAIL "E"

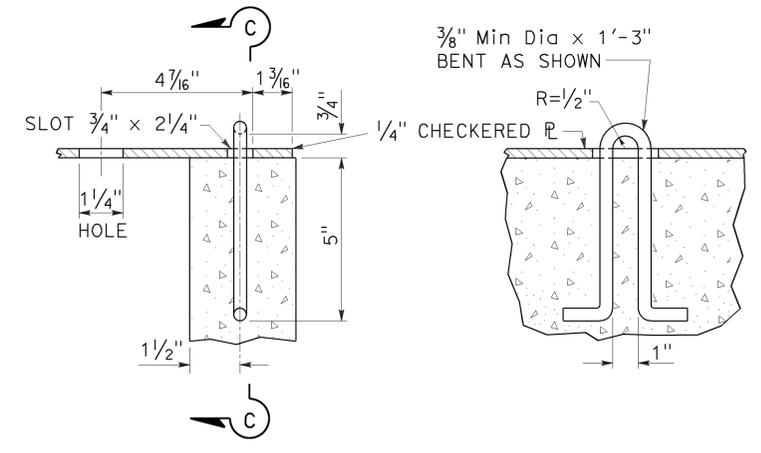

DETAIL "F"

SECTION C-C

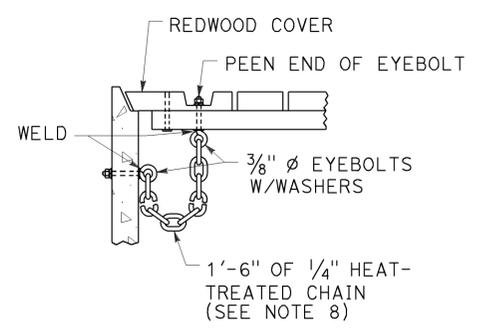

DETAIL "G"

NOTES:

- For details of steel pipe inlets, see Standard Plan D75A.
- For details of ladder and steps and when ladder or steps are required, see Standard Plan D75C.
- Inlet pipes shall not protrude into basin.
- Except for inlets used for junction boxes, basin floors shall have minimum slope of 4:1 from all directions toward outlet pipe, and a wood trowel finish.
- See Revised Standard Plans RSP D77A and RSP D77B for Grate and Frame Details and Weights of Miscellaneous Iron and Steel.
- Designation of Type OCPI pipe inlets on plans indicates trash racks are to be furnished and installed on all side openings. See Standard Plan D75C for Trash Rack details.
- More than one side opening may be required. Location and number as ordered by the Engineer. Opening may be cast in pipe.
- Chain to be provided when specified.
- Place pipe so bars of grate will be parallel with main surface flow.
- Redwood covers shall only be placed at locations designated on the plans.

STATE OF CALIFORNIA
DEPARTMENT OF TRANSPORTATION


CONCRETE PIPE INLETS

NO SCALE


RSP D75B DATED OCTOBER 30, 2015 SUPERSEDES STANDARD PLAN D75B DATED MAY 20, 2011 - PAGE 162 OF THE STANDARD PLANS BOOK DATED 2010.

REVISED STANDARD PLAN RSP D75B


2010 REVISED STANDARD PLAN RSP D75B

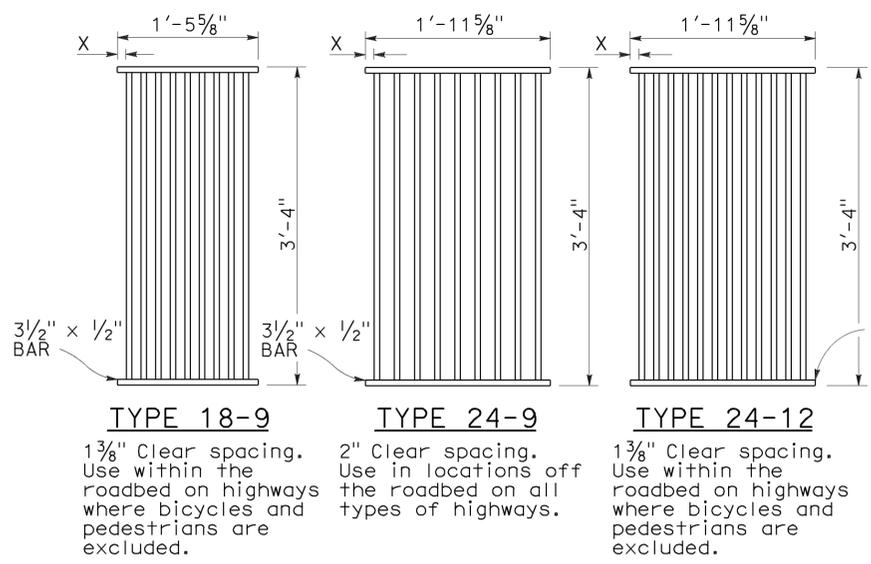

RECTANGULAR GRATE DETAILS
(See table below)

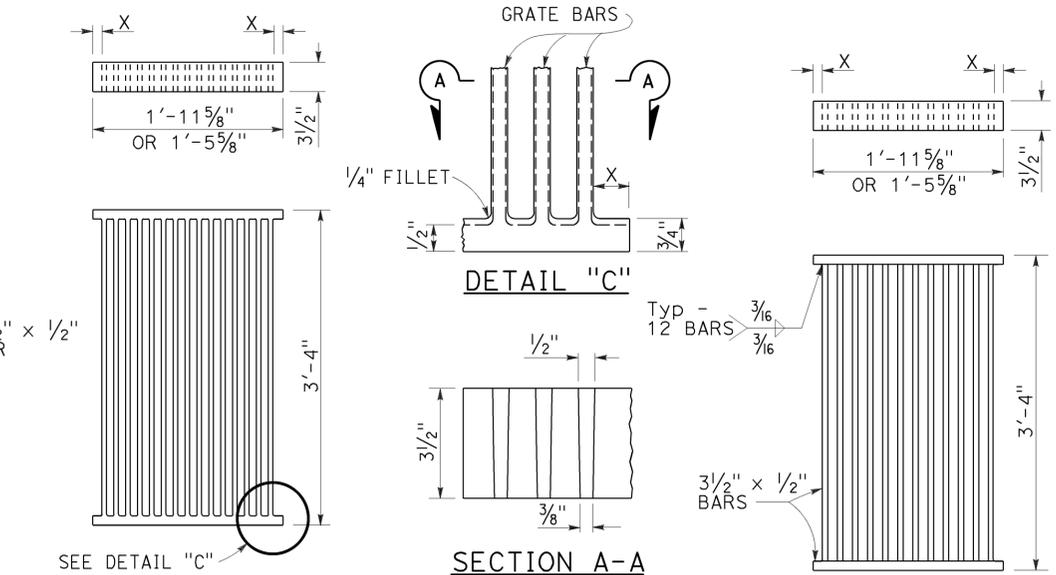


ALTERNATIVE CAST DUCTILE IRON GRATE OR CAST CARBON STEEL GRATE
ALTERNATIVE WELDED GRATE

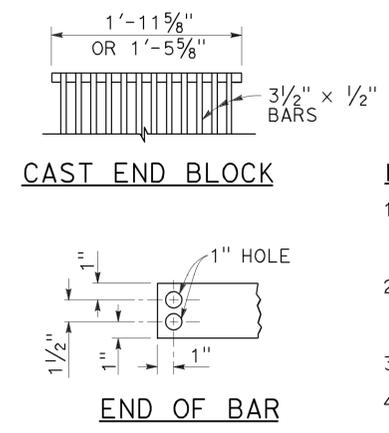


CAST END BLOCK
END OF BAR


- NOTES:**
- Grate type numbers refer to approximate width of grate in inches and number of bars, respectively.
 - Contractor has the option of using cast ductile iron, cast carbon steel, welded, bolted, or cast end block grate.
 - Rounded top of bars optional on all grates.
 - Pipe inlets with a grate shall be placed so that bars parallel direction of principle surface flow.
 - Complete joint penetration butt welds may be substituted for the fillet welds on all anchors.
 - Standard square, hexagon, round or equivalent headed anchors may be substituted for the right angle hooks on the anchors shown on this plan.
 - Grate and frame weights are based on welded grates (weights of face angles, steps, protection bars, etc. are not included).
 - Connect chain to grate and frame only at locations shown on the plans. When chain is required, do not use cast ductile iron grates.

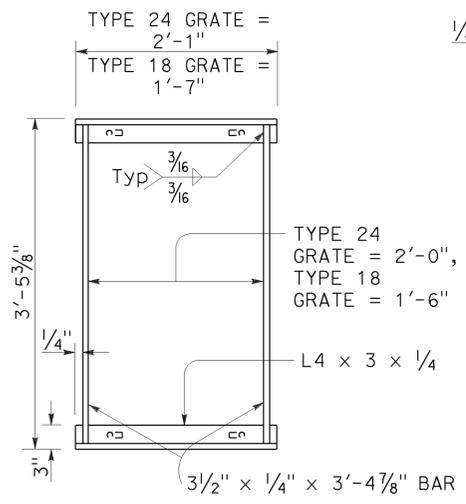


TYPICAL FRAME

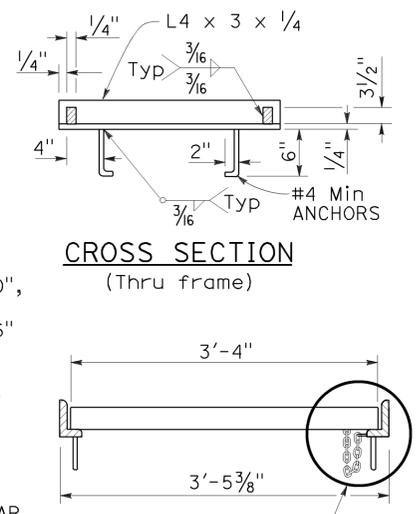


CROSS SECTION (Thru frame)
LONGITUDINAL SECTION (Thru frame and grate)

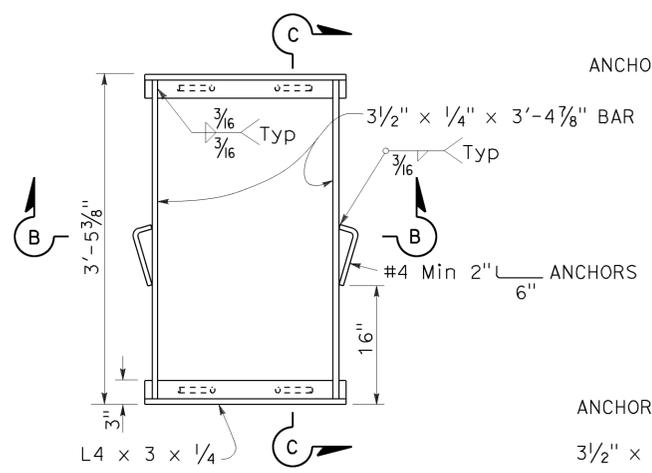

TYPICAL FRAME
ALTERNATIVE ANCHOR FOR RECTANGULAR FRAME
(For details not shown, See Rectangular Frame Details)

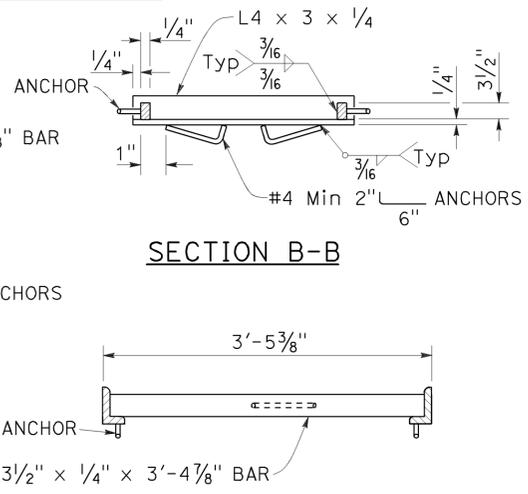

SECTION B-B
SECTION C-C

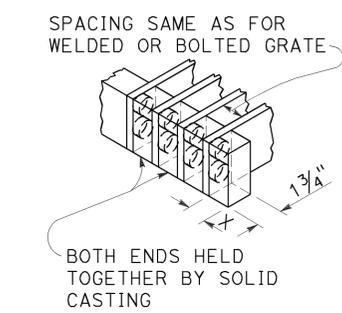

ALTERNATIVE CAST DUCTILE IRON OR CAST CARBON STEEL END BLOCK GRATE


RECTANGULAR FRAME DETAILS
(For all rectangular grates)

GRATE BAR SPACING TABLE


TYPE	NO. OF BARS	CLEAR BAR SPACING	X
18-9	9	1 3/8"	1 1/16"
24-9	9	2"	1 9/16"
24-12	12	1 3/8"	1 1/4"

INLET TYPE	COVER TYPE	WEIGHT LB
OS	PLATE	174
OL-7	PLATE	170
OL-10	PLATE	170
OL-14	PLATE	170
OL-21	PLATE	170
OCPI	PLATE	112
OCPI	PLATE	112
OCPI	REDWOOD	42
OMP	PLATE	177
OMPI	PLATE	177


INLET TYPE	GRATE TYPE	NO. OF GRATES	WEIGHT LB
GDO	24-12	2	634
GOL-7	24-12	1	326
GOL-10	24-12	1	326
G0,G1,G2,G3,G4 (TYPE 24)	24-9	1	263
	24-12	1	326
G4 (TYPE 18),G5,G6	18-9	1	249
GT1	18-9	2	498
GT2	18-9	2	498
GT3	24-12	2	652
GT4	24-12	2	652
TRASH RACK			22
GRATE CHAIN			3

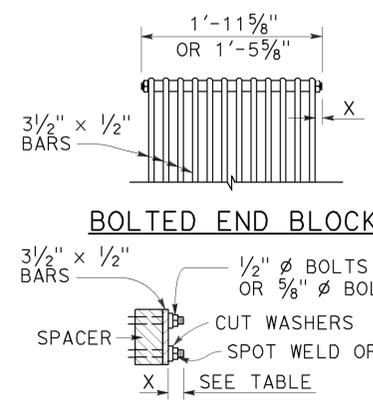

BOLTED END BLOCK
BOLTING DETAIL
ALTERNATIVE BOLTED GRATE

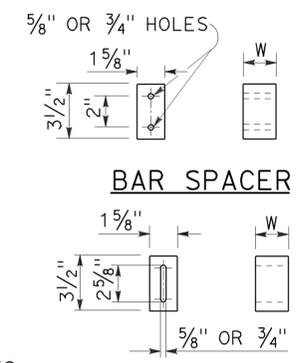

ALTERNATIVE SPACER
W = 1 3/8" or 2"

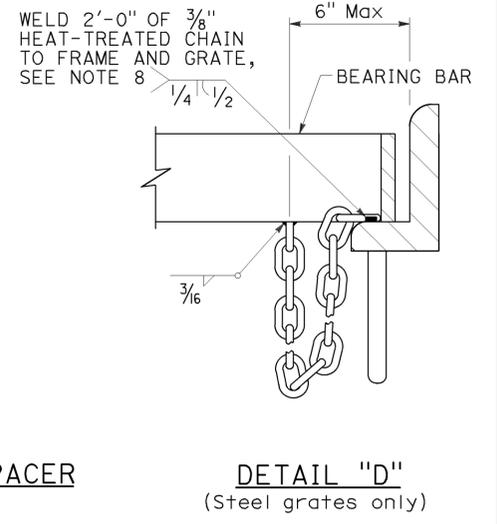

DETAIL "D"
(Steel grates only)

BASIS FOR MISC IRON & STEEL FINAL PAY WEIGHTS FOR DRAINAGE INLETS
(See Note 7)

RSP D77A DATED APRIL 19, 2013 SUPERSEDES RSP D77A DATED JULY 20, 2012 AND STANDARD PLAN D77A DATED MAY 20, 2011 - PAGE 164 OF THE STANDARD PLANS BOOK DATED 2010.

REVISED STANDARD PLAN RSP D77A

2010 REVISED STANDARD PLAN RSP D77A

Dist	COUNTY	ROUTE	POST MILES TOTAL PROJECT	SHEET No.	TOTAL SHEETS
05	SB	101	2.2/3.3	471	786

Gregory A. Balzer
 LICENSED LANDSCAPE ARCHITECT

July 19, 2013
 PLANS APPROVAL DATE

THE STATE OF CALIFORNIA OR ITS OFFICERS OR AGENTS SHALL NOT BE RESPONSIBLE FOR THE ACCURACY OR COMPLETENESS OF SCANNED COPIES OF THIS PLAN SHEET.

TO ACCOMPANY PLANS DATED 12-7-15

A

AB AGGREGATE BASE
 ABS ACRYLONITRILE-BUTADIENE-STYRENE
 AC ASPHALT CONCRETE
 ACC ARMOR-CLAD CONDUCTORS
 Adj ADJACENT/ADJUSTABLE
 AIC AUXILIARY IRRIGATION CONTROLLER
 Alt ALTERNATIVE
 AMEND AMENDMENT
 ARV AIR RELEASE VALVE
 AUTO AUTOMATIC
 AUX AUXILIARY
 AVB ATMOSPHERIC VACUUM BREAKER

B

B&B BALLED AND BURLAPPED
 B/B BRASS/BRONZE
 B/B/PL BRASS/BRONZE/PLASTIC
 B/PL BRASS/PLASTIC
 BFM BONDED FIBER MATRIX
 Bit Ctd BITUMINOUS COATED
 BP BOOSTER PUMP
 BPA BACKFLOW PREVENTER ASSEMBLY
 BPE BACKFLOW PREVENTER ENCLOSURE
 BV BALL VALVE

C

C CONDUIT
 CAP CORRUGATED ALUMINUM PIPE
 CARV COMBINATION AIR RELEASE VALVE
 CB COUPLING BAND
 CCA CAM COUPLER ASSEMBLY
 CEC CONTROLLER ENCLOSURE CABINET
 CHDPE CORRUGATED HIGH DENSITY POLYETHYLENE
 CL CHAIN LINK
 CNC CONTROL AND NEUTRAL CONDUCTORS
 Conc CONCRETE
 CP COPPER PIPE
 CS COMPOST SOCK
 CSP CORRUGATED STEEL PIPE
 CST CENTER STRIP
 CV CHECK VALVE

D

Dia DIAMETER
 DIP DUCTILE IRON PIPE
 DIT DRIP IRRIGATION TUBING
 DG DECOMPOSED GRANITE
 DN DIAMETER NOMINAL
 DVA DRIP VALVE ASSEMBLY

E

EC EROSION CONTROL
 ECTC EROSION CONTROL TECHNOLOGY COUNCIL
 ElecT ELECTRIC/ELECTRICAL
 Elev ELEVATION
 ELL ELBOW
 ENCL ENCLOSURE
 EP EDGE OF PAVEMENT
 ES EDGE OF SHOULDER
 EST END STRIP
 ESTB ESTABLISHMENT
 ETW EDGE OF TRAVELED WAY

F

F FULL CIRCLE
 F/P FULL/PART CIRCLE
 FCV FLOW CONTROL VALVE
 FERT FERTILIZER
 FG FINISHED GRADE
 FH FLEXIBLE HOSE
 FIPT FEMALE IRON PIPE THREAD
 FIS FERTILIZER INJECTOR SYSTEM
 FL FLOW LINE
 FR FIBER ROLL
 FS FLOW SENSOR
 FSC FLOW SENSOR CABLE
 FV FLUSH VALVE

G

Galv GALVANIZED
 GARV GARDEN VALVE
 GARVA GARDEN VALVE ASSEMBLY
 GM GRAVEL MULCH
 GPH GALLONS PER HOUR
 GPM GALLONS PER MINUTE
 GSP GALVANIZED STEEL PIPE
 GV GATE VALVE

H

H HALF CIRCLE
 HDPE HIGH DENSITY POLYETHYLENE
 HP HORSEPOWER/HINGE POINT
 HPL HIGH PRESSURE LINE
 Hwy HIGHWAY

I

IC IRRIGATION CONTROLLER
 ICC IRRIGATION CONTROLLER(S) IN CONTROLLER ENCLOSURE CABINET
 ID INSIDE DIAMETER
 IFS IRRIGATION FILTRATION SYSTEM
 IPS IRON PIPE SIZE
 IPT IRON PIPE THREAD
 Irr IRRIGATION

L

L LENGTH

Max MAXIMUM
 MBGR METAL BEAM GUARD RAILING
 MCV MANUAL CONTROL VALVE
 MIC MASTER IRRIGATION CONTROLLER
 Min MINIMUM
 MIPT MALE IRON PIPE THREAD
 Misc MISCELLANEOUS
 MtI MATERIAL
 MVP MAINTENANCE VEHICLE PULLOUT

N

NCN NO COMMON NAME
 NL NOZZLE LINE
 No. NUMBER
 NPT NATIONAL PIPE THREAD

O

O/C ON CENTER
 OD OUTSIDE DIAMETER
 OL OVERLAP

P

P PART CIRCLE
 PB PULL BOX
 PCC PORTLAND CEMENT CONCRETE
 PE POLYETHYLENE
 Pkt+ PACKET
 PL PLASTIC
 PLS PURE LIVE SEED
 PLT PLANT/PLANTING
 PLT ESTB PLANT ESTABLISHMENT
 PM POST MILE
 PR PRESSURE RATED
 PRLV PRESSURE RELIEF VALVE
 PRV PRESSURE REGULATING VALVE
 PVC POLYVINYL CHLORIDE
 Pvm+ PAVEMENT

Q

Q QUARTER CIRCLE
 QCV QUICK COUPLING VALVE

NOTE:
 For additional abbreviations, see Standard Plans A10A and A10B.

R

R RADIUS
 RCP REINFORCED CONCRETE PIPE
 RCV REMOTE CONTROL VALVE
 RCVM REMOTE CONTROL VALVE (MASTER)
 RCVMF REMOTE CONTROL VALVE (MASTER) W/FLOW SENSOR
 RCVP REMOTE CONTROL VALVE W/PRESSURE REGULATOR
 RCW RECYCLED WATER
 RECP ROLLED EROSION CONTROL PRODUCT
 REQ REQUIRED
 RICS REMOTE IRRIGATION CONTROL SYSTEM
 R/W RIGHT OF WAY

S

S SLIP
 SCH SCHEDULE
 SF STATE-FURNISHED
 Shld SHOULDER
 Sq SQUARE
 SST SIDE STRIP
 Sta STATION
 Std STANDARD
 SW SIDEWALK/SOUND WALL

T

T THIRD CIRCLE/THREAD
 TLS TRUCK LOADING STANDPIPE
 TQ THREE QUARTER CIRCLE
 TRM TURF REINFORCEMENT MAT
 TT TWO-THIRDS CIRCLE
 TWSA TREE WELL SPRINKLER ASSEMBLY
 Typ TYPICAL

U

UG UNDERGROUND

W

W WIDTH
 W/ WITH
 WM WATER METER
 WS WYE STRAINER
 WSA WYE STRAINER ASSEMBLY
 WSP WELDED STEEL PIPE
 WWM WELDED WIRE MESH

STATE OF CALIFORNIA
 DEPARTMENT OF TRANSPORTATION
LANDSCAPE AND EROSION CONTROL ABBREVIATIONS
 NO SCALE


RSP H1 DATED JULY 19, 2013 SUPERSEDES STANDARD PLAN H1 DATED MAY 20, 2011 - PAGE 218 OF THE STANDARD PLANS BOOK DATED 2010.

REVISED STANDARD PLAN RSP H1

2010 REVISED STANDARD PLAN RSP H1

Dist	COUNTY	ROUTE	POST MILES TOTAL PROJECT	SHEET No.	TOTAL SHEETS
05	SB	101	2.2/3.3	472	786



 LICENSED LANDSCAPE ARCHITECT
 November 15, 2013
 PLANS APPROVAL DATE
THE STATE OF CALIFORNIA OR ITS OFFICERS OR AGENTS SHALL NOT BE RESPONSIBLE FOR THE ACCURACY OR COMPLETENESS OF SCANNED COPIES OF THIS PLAN SHEET.

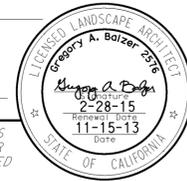

TO ACCOMPANY PLANS DATED 12-7-15

EXISTING	NEW	ITEM DESCRIPTION
		WATER METER (WM)
		BACKFLOW PREVENTER ASSEMBLY (BPA)
		BACKFLOW PREVENTER ENCLOSURE (BPE)
		BOOSTER PUMP (BP)
		TRUCK LOADING STANDPIPE (TLS)
		FLOW SENSOR (FS)
		MASTER IRRIGATION CONTROLLER (MIC)
		AUXILIARY IRRIGATION CONTROLLER (AIC)
		IRRIGATION CONTROLLER (IC) IRRIGATION CONTROLLER (IC) (BATTERY) IRRIGATION CONTROLLER (IC) (SOLAR) IRRIGATION CONTROLLER (IC) (TWO WIRE) IRRIGATION CONTROLLER(S) IN CONTROLLER ENCLOSURE CABINET (ICC)
		ENCLOSURE CABINET (ICC)
		ARMOR-CLAD CONDUCTORS (ACC)
		CONTROL AND NEUTRAL CONDUCTORS (CNC)
		IRRIGATION CONDUIT
		EXTEND IRRIGATION CONDUIT
		DUCTILE IRON PIPE (SUPPLY LINE) (MAIN) (DIP)
		GALVANIZED STEEL PIPE (SUPPLY LINE) (MAIN) (GSP)
		GALVANIZED STEEL PIPE (SUPPLY LINE) (LATERAL) (GSP)
		PLASTIC PIPE (SUPPLY LINE) (MAIN)
		PLASTIC PIPE (SUPPLY LINE) (LATERAL)
		COPPER PIPE (SUPPLY LINE)
		DRIP IRRIGATION TUBING
		REMOTE CONTROL VALVE (RCV) REMOTE CONTROL VALVE (MASTER) (RCVM) REMOTE CONTROL VALVE (MASTER) W/FLOW METER (RCVMF)
		REMOTE CONTROL VALVE W/PRESSURE REGULATOR (RCVP)
		EXISTING MANUAL CONTROL VALVE (MCV)
		DRIP VALVE ASSEMBLY (DVA)
		WYE STRAINER ASSEMBLY (WSA)

EXISTING	NEW	ITEM DESCRIPTION
		GATE VALVE (GV)
		BALL VALVE (BV)
		QUICK COUPLING VALVE (QCV)
		CAM COUPLER ASSEMBLY (CCA)
		GARDEN VALVE ASSEMBLY (GARVA)
		PRESSURE REGULATING VALVE (PRV)
		PRESSURE RELIEF VALVE (PRLV)
		FLOW CONTROL VALVE (FCV)
		COMBINATION AIR RELEASE VALVE (CARV)
		CHECK VALVE (CV)
		FLUSH VALVE (FV)
		EXISTING NOZZLE LINE W/TURNING UNION
		EXISTING IRRIGATION SYSTEM
		EXISTING IRRIGATION SYSTEM TO BE REMOVED
		CHAIN LINK GATE
		QUICK COUPLING VALVE W/SPRINKLER PROTECTOR
		SPRINKLER W/SPRINKLER PROTECTOR
		CONNECT TO EXISTING SYSTEM
		CAP
		CAP EXISTING
		FIBER ROLL
		COMPOST SOCK

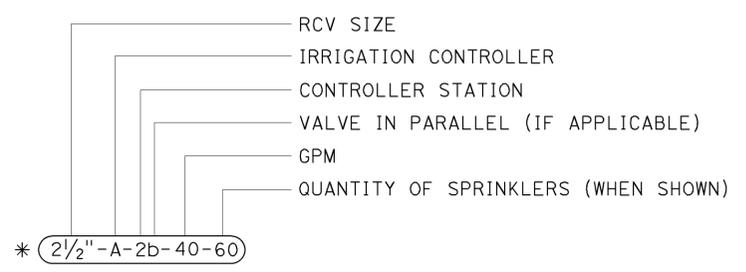

* (2 1/2" - A - 2b - 40 - 60)

VALVE CODE

* VALVE CODES FOR EXISTING VALVES ARE SHOWN IN A DASHED ENCLOSURE.

RSP H2 DATED NOVEMBER 15, 2013 SUPERSEDES RSP H2 DATED JULY 19, 2013 AND STANDARD PLAN H2 DATED MAY 20, 2011 - PAGE 219 OF THE STANDARD PLANS BOOK DATED 2010.


REVISED STANDARD PLAN RSP H2

STATE OF CALIFORNIA
DEPARTMENT OF TRANSPORTATION
LANDSCAPE AND EROSION CONTROL SYMBOLS
NO SCALE


2010 REVISED STANDARD PLAN RSP H2

Dist	COUNTY	ROUTE	POST MILES TOTAL PROJECT	SHEET No.	TOTAL SHEETS
05	SB	101	2.2/3.3	473	786


Gregory A. Balzer
 LICENSED LANDSCAPE ARCHITECT
 July 19, 2013
 PLANS APPROVAL DATE
THE STATE OF CALIFORNIA OR ITS OFFICERS OR AGENTS SHALL NOT BE RESPONSIBLE FOR THE ACCURACY OR COMPLETENESS OF SCANNED COPIES OF THIS PLAN SHEET.

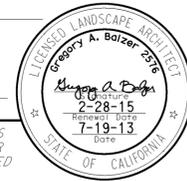


TO ACCOMPANY PLANS DATED 12-7-15

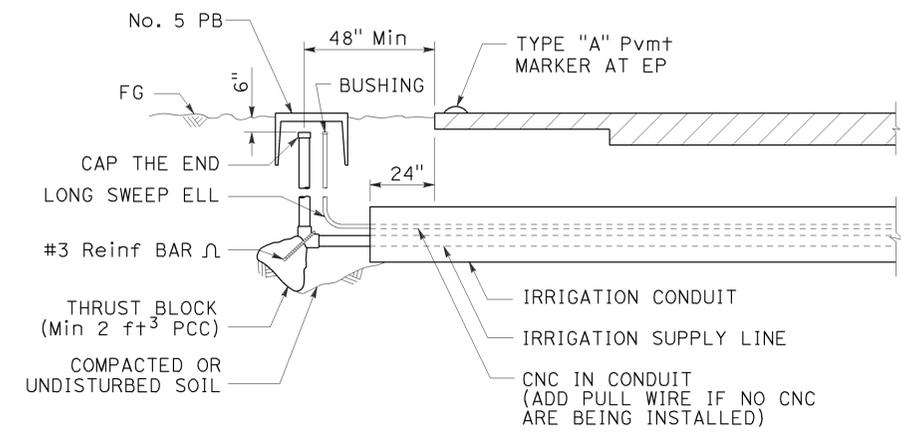

SECTION
IRRIGATION CONDUIT
UNDER TRAVELED WAY

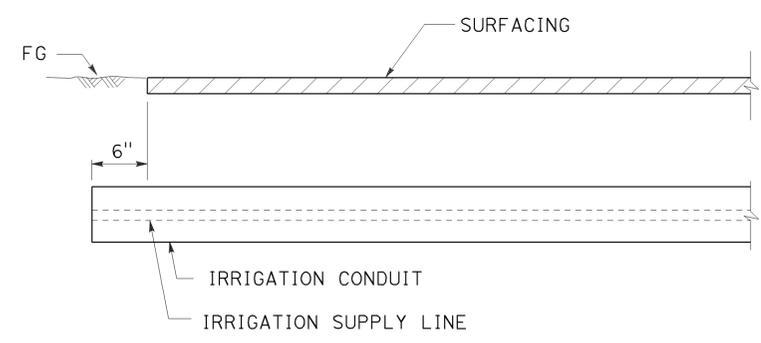

SECTION
IRRIGATION CONDUIT
UNDER SIDEWALKS, DRIVEWAYS AND PATHS

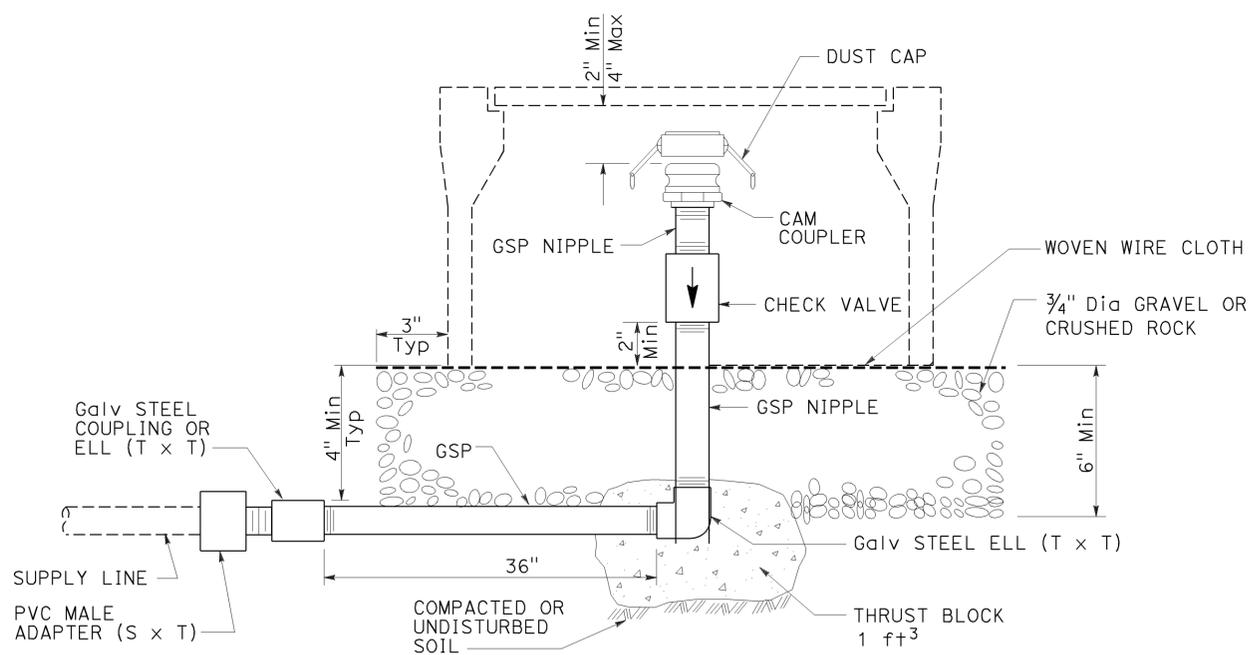

ELEVATION
CAM COUPLER ASSEMBLY

STATE OF CALIFORNIA
DEPARTMENT OF TRANSPORTATION
LANDSCAPE DETAILS
NO SCALE


RSP H9 DATED JULY 19, 2013 SUPERSEDES STANDARD PLAN H9 DATED MAY 20, 2011 - PAGE 226 OF THE STANDARD PLANS BOOK DATED 2010.

REVISED STANDARD PLAN RSP H9


2010 REVISED STANDARD PLAN RSP H9

DIST	COUNTY	ROUTE	POST MILES TOTAL PROJECT	SHEET No.	TOTAL SHEETS
05	SB	101	2.2/3.3	474	786


Gregory A. Balzer
 LICENSED LANDSCAPE ARCHITECT
 July 19, 2013
 PLANS APPROVAL DATE
THE STATE OF CALIFORNIA OR ITS OFFICERS OR AGENTS SHALL NOT BE RESPONSIBLE FOR THE ACCURACY OR COMPLETENESS OF SCANNED COPIES OF THIS PLAN SHEET.

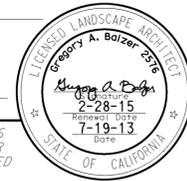


TO ACCOMPANY PLANS DATED 12-7-15

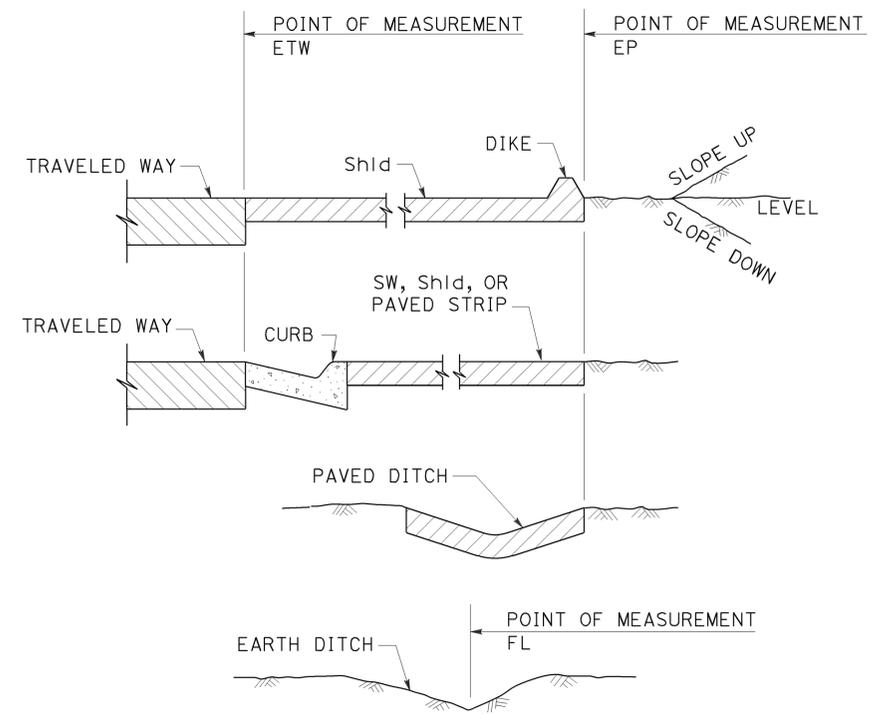


**SECTION
POINTS OF MEASUREMENT**

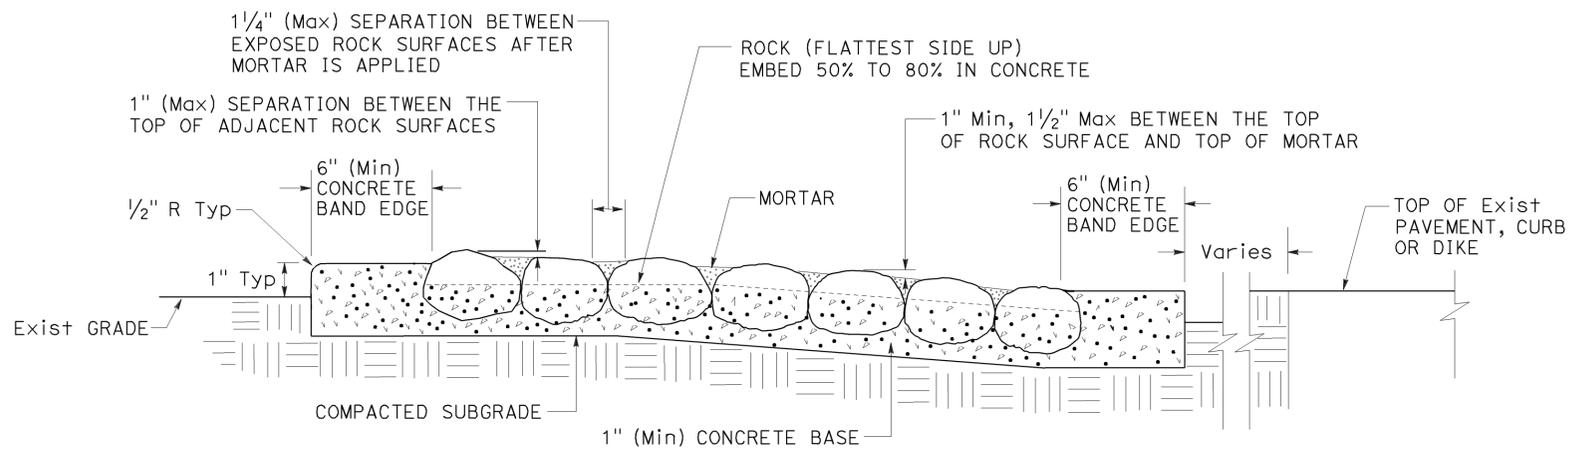

**SECTION
ROCK BLANKET**

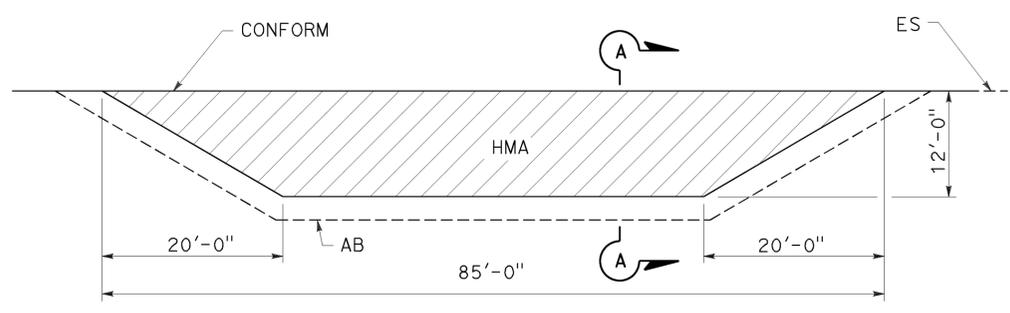

PLAN

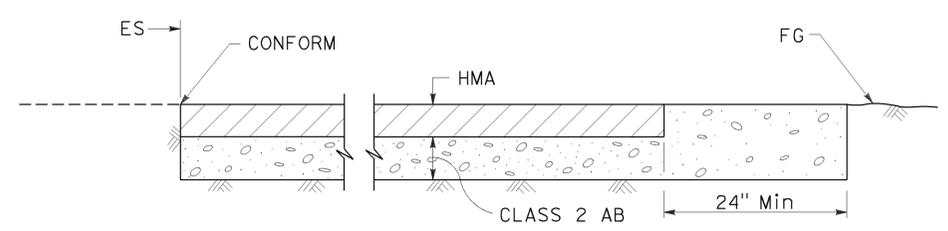

**SECTION A-A
MAINTENANCE VEHICLE PULLOUT**

STATE OF CALIFORNIA
 DEPARTMENT OF TRANSPORTATION
LANDSCAPE DETAILS
 NO SCALE

RSP H9A DATED JULY 19, 2013 SUPPLEMENTS THE STANDARD PLANS BOOK DATED 2010.

REVISED STANDARD PLAN RSP H9A

2010 REVISED STANDARD PLAN RSP H9A

TO ACCOMPANY PLANS DATED 12-7-15

TABLE 1

TAPER LENGTH CRITERIA AND CHANNELIZING DEVICE SPACING							
SPEED (S)	MINIMUM TAPER LENGTH * FOR WIDTH OF OFFSET 12 FEET (W)				MAXIMUM CHANNELIZING DEVICE SPACING		
	TANGENT 2L	MERGING L	SHIFTING L/2	SHOULDER L/3	X	Y	Z **
					TAPER	TANGENT	CONFLICT
mph	ft	ft	ft	ft	ft	ft	ft
20	160	80	40	27	20	40	10
25	250	125	63	42	25	50	12
30	360	180	90	60	30	60	15
35	490	245	123	82	35	70	17
40	640	320	160	107	40	80	20
45	1080	540	270	180	45	90	22
50	1200	600	300	200	50	100	25
55	1320	660	330	220	55	110	27
60	1440	720	360	240	60	120	30
65	1560	780	390	260	65	130	32
70	1680	840	420	280	70	140	35

* - For other offsets, use the following merging taper length formula for L:
 For speed of 40 mph or less, $L = WS^2/60$
 For speed of 45 mph or more, $L = WS$

Where: L = Taper length in feet
 W = Width of offset in feet
 S = Posted speed limit, off-peak 85th-percentile speed prior to work starting, or the anticipated operating speed in mph

** - Use for taper and tangent sections where there are no pavement markings or where there is a conflict between existing pavement markings and channelizers (CA).

TABLE 2

LONGITUDINAL BUFFER SPACE AND FLAGGER STATION SPACING				
SPEED *	Min D **	DOWNGRADE Min D ***		
		-3%	-6%	-9%
		ft	ft	ft
mph	ft	ft	ft	ft
20	115	116	120	126
25	155	158	165	173
30	200	205	215	227
35	250	257	271	287
40	305	315	333	354
45	360	378	400	427
50	425	446	474	507
55	495	520	553	593
60	570	598	638	686
65	645	682	728	785
70	730	771	825	891

* - Speed is posted speed limit, off-peak 85th-percentile speed prior to work starting, or the anticipated operating speed in mph
 ** - Longitudinal buffer space or flagger station spacing
 *** - Use on sustained downgrade steeper than -3 percent and longer than 1 mile.

TABLE 3

ADVANCE WARNING SIGN SPACING			
ROAD TYPE	DISTANCE BETWEEN SIGNS *		
	A	B	C
	ft	ft	ft
URBAN - 25 mph OR LESS	100	100	100
URBAN - MORE THAN 25 mph TO 40 mph	250	250	250
URBAN - MORE THAN 40 mph	350	350	350
RURAL	500	500	500
EXPRESSWAY / FREEWAY	1000	1500	2640

* - The distances are approximate, are intended for guidance purposes only, and should be applied with engineering judgment. These distances should be adjusted by the Engineer for field conditions, if necessary, by increasing or decreasing the recommended distances.

STATE OF CALIFORNIA
 DEPARTMENT OF TRANSPORTATION

TRAFFIC CONTROL SYSTEM TABLES FOR LANE AND RAMP CLOSURES

NO SCALE

RSP T9 DATED JULY 19, 2013 SUPERSEDES RSP T9 DATED APRIL 19, 2013 THAT SUPPLEMENTS THE STANDARD PLANS BOOK DATED 2010.


2010 REVISED STANDARD PLAN RSP T9

DIST	COUNTY	ROUTE	POST MILES TOTAL PROJECT	SHEET No.	TOTAL SHEETS
05	SB	101	2.2/3.3	476	786

REGISTERED CIVIL ENGINEER
 April 19, 2013
 PLANS APPROVAL DATE

THE STATE OF CALIFORNIA OR ITS OFFICERS OR AGENTS SHALL NOT BE RESPONSIBLE FOR THE ACCURACY OR COMPLETENESS OF SCANNED COPIES OF THIS PLAN SHEET.

2010 REVISED STANDARD PLAN RSP T10

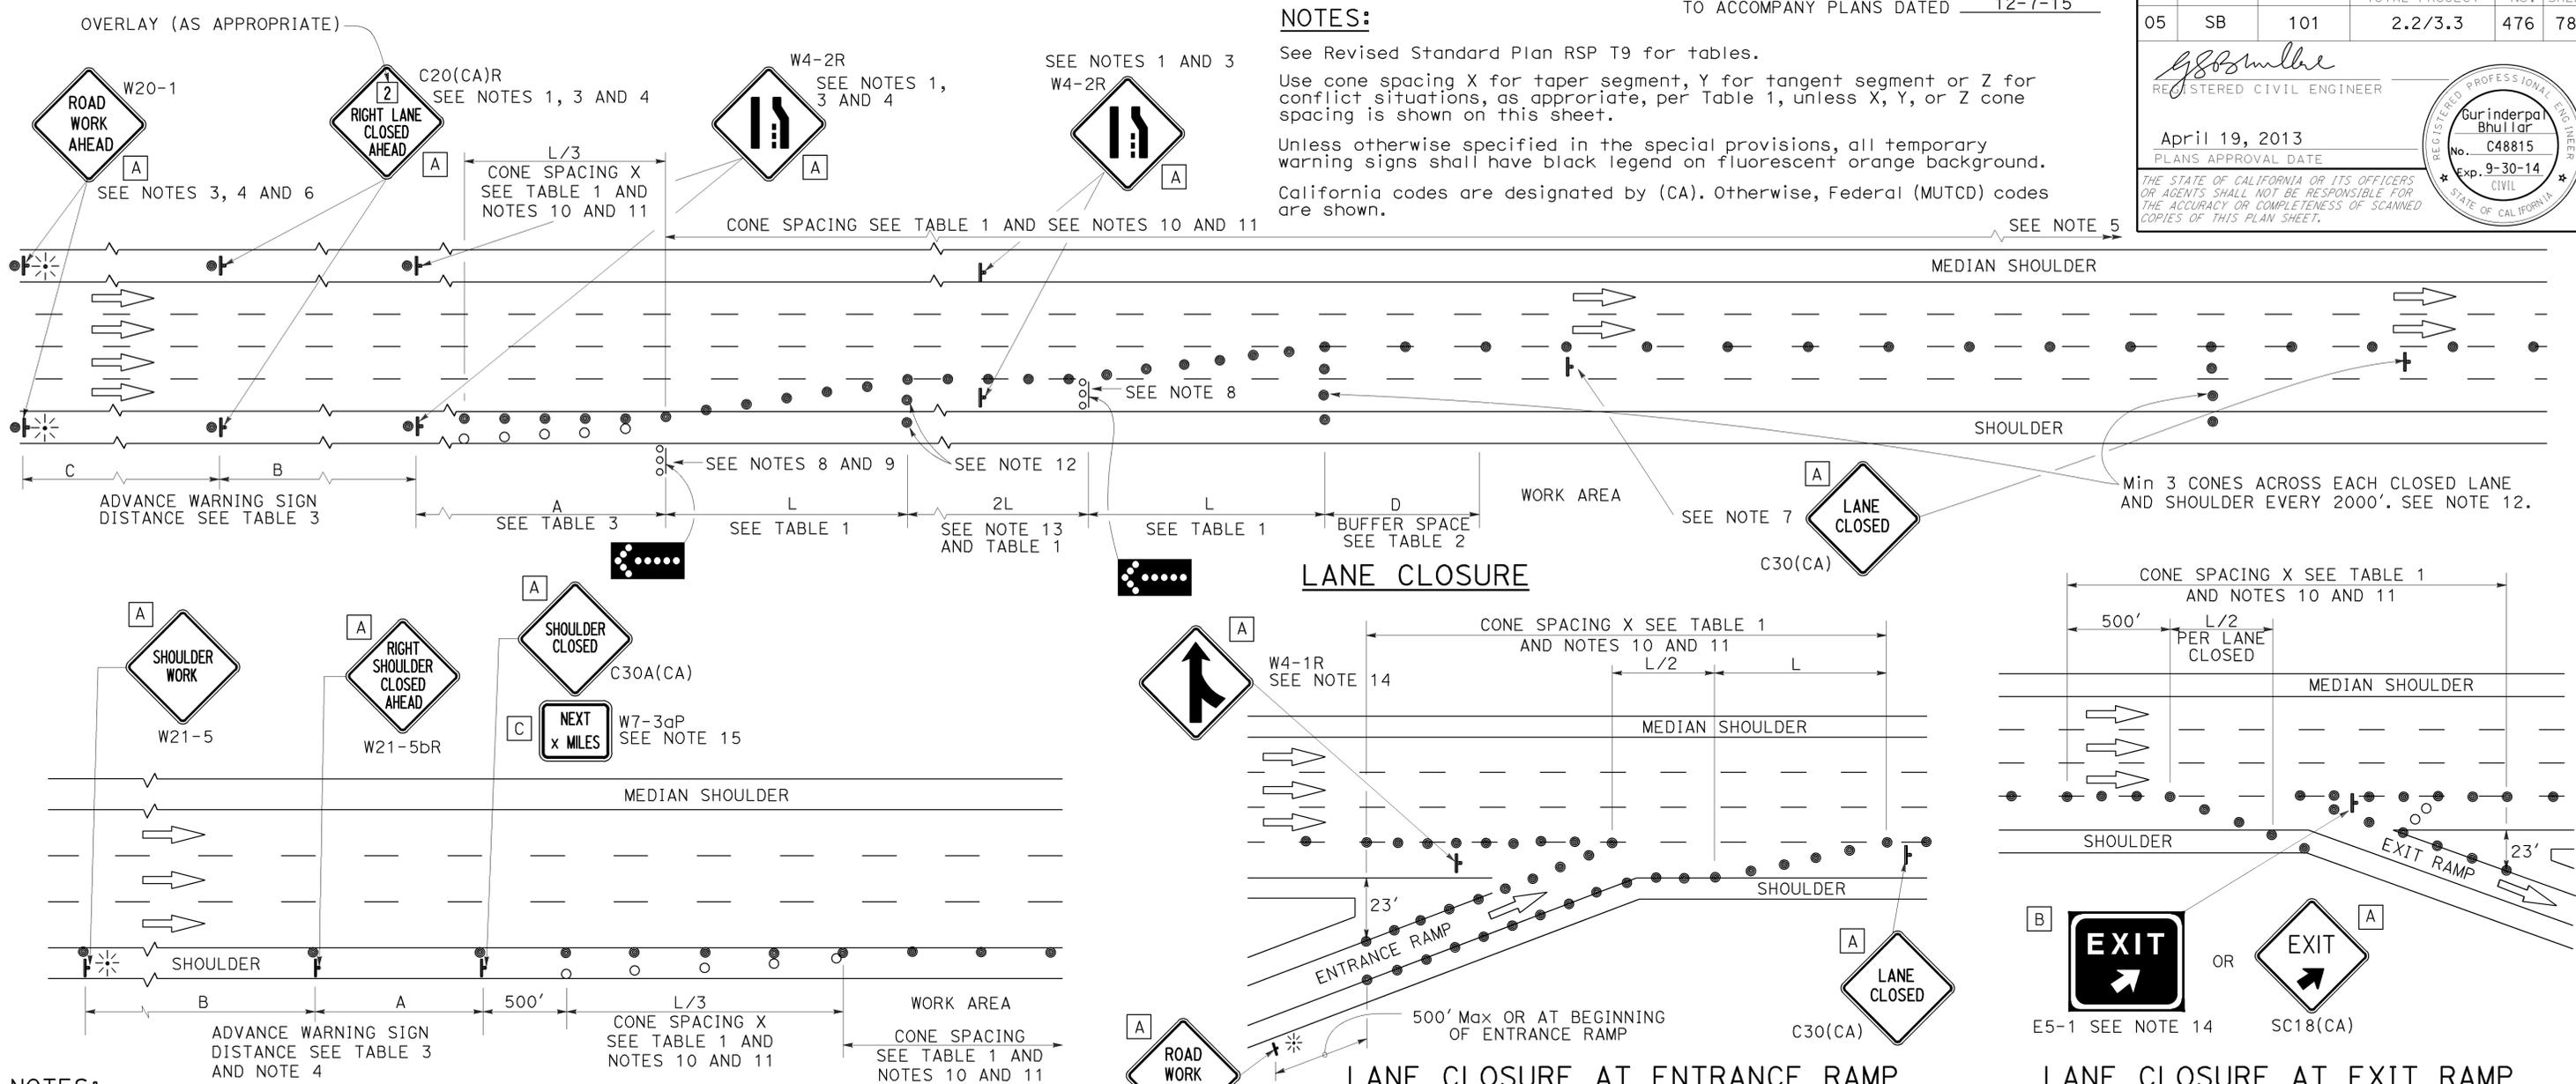

- NOTES:**
- Median lane closures shall conform to the details as shown except that C20(CA)L and W4-2L signs shall be used.
 - At least one person shall be assigned to provide full time maintenance of traffic control devices for lane closures.
 - Duplicate sign installations are not required:
 - On opposite shoulder if at least one-half of the available lanes remain open to traffic.
 - In the median if the width of the median shoulder is less than 8' and the outside lanes are to be closed.
 - Each advance warning sign on each side of the roadway shall be equipped with at least two flags for daytime closure. Each flag shall be at least 16" x 16" in size and shall be orange or fluorescent red-orange in color. Flashing beacons shall be placed at the locations indicated for lane closure during hours of darkness.
 - A G20-2 "END ROAD WORK" sign, with minimum size of 48" x 24" as appropriate, shall be placed at the end of the lane closure unless the end of work area is obvious or ends within a larger project's limits.

- NOTES:**
- If the W20-1 sign would follow within 2000' of a stationary W20-1 or G20-1 "ROAD WORK NEXT _____ MILES", use a C20(CA) sign for the first advance warning sign.
 - Place a C30(CA) sign every 2000' throughout length of lane closure.
 - One flashing arrow sign for each lane closed. The flashing arrow signs shall be Type I.
 - A minimum 1500' of sight distance shall be provided where possible for vehicles approaching the first flashing arrow sign. Lane closures shall not begin at top of crest vertical curve or on a horizontal curve.
 - All cones used for lane closures during the hours of darkness shall be fitted with retroreflective bands (or sleeves) as specified in the specifications.
 - Portable delineators, placed at one-half the spacing indicated for traffic cones may be used instead of cones for daytime closures only.

- Unless otherwise specified in the special provisions, a minimum of 3 cones shall be placed transversely across each closed lane and shoulder at each location where a taper across a traffic lane ends and every 2000' as shown on the "Lane Closure" detail. Two Type II barricades may be used instead of the 3 cones. The transverse alignment of the cones or barricades on the closed shoulder may be shifted from the transverse alignment to provide access to the work.
- Unless otherwise specified in the special provisions, the 2L tangent shown along lane lines shall be used between the L tapers required for each closed traffic lane.
- Unless otherwise specified in the special provisions, the E5-1 or SC18(CA) and W4-1 signs shall be used as shown.
- A W7-3aP "NEXT _____ MILES" plaque must be used if the shoulder closure extends beyond the distance that can be perceived by road users.

LEGEND

- TRAFFIC CONE
- TRAFFIC CONE (OPTIONAL TAPER)
- ⊥ TEMPORARY TRAFFIC CONTROL SIGN
- ⬢ FLASHING ARROW SIGN (FAS)
- ⊞ FAS SUPPORT OR TRAILER
- ⚡ PORTABLE FLASHING BEACON

SIGN PANEL SIZE (Min)

- A 48" x 48"
- B 72" x 60"
- C 36" x 30"

TRAFFIC CONTROL SYSTEM FOR LANE CLOSURE ON FREEWAYS AND EXPRESSWAYS

NO SCALE

RSP T10 DATED APRIL 19, 2013 SUPERSEDES STANDARD PLAN T10 DATED MAY 20, 2011 - PAGE 237 OF THE STANDARD PLANS BOOK DATED 2010.

REVISED STANDARD PLAN RSP T10

Dist	COUNTY	ROUTE	POST MILES TOTAL PROJECT	SHEET No.	TOTAL SHEETS
05	SB	101	2.2/3.3	477	786


REGISTERED CIVIL ENGINEER
 Gurinderpal Bhullar
 No. C48815
 Exp. 9-30-14
 STATE OF CALIFORNIA

April 19, 2013
 PLANS APPROVAL DATE

THE STATE OF CALIFORNIA OR ITS OFFICERS OR AGENTS SHALL NOT BE RESPONSIBLE FOR THE ACCURACY OR COMPLETENESS OF SCANNED COPIES OF THIS PLAN SHEET.


NOTES: See Revised Standard Plan RSP T9 for tables.
 Use cone spacing X for taper segment, Y for tangent segment or Z for conflict situations, as appropriate, per Table 1, unless X, Y, or Z cone spacing is shown on this sheet.
 Unless otherwise specified in the special provisions, all temporary warning signs shall have black legend on fluorescent orange background.
 California codes are designated by (CA). Otherwise, Federal (MUTCD) codes are shown.

SEE NOTES 3 AND 5

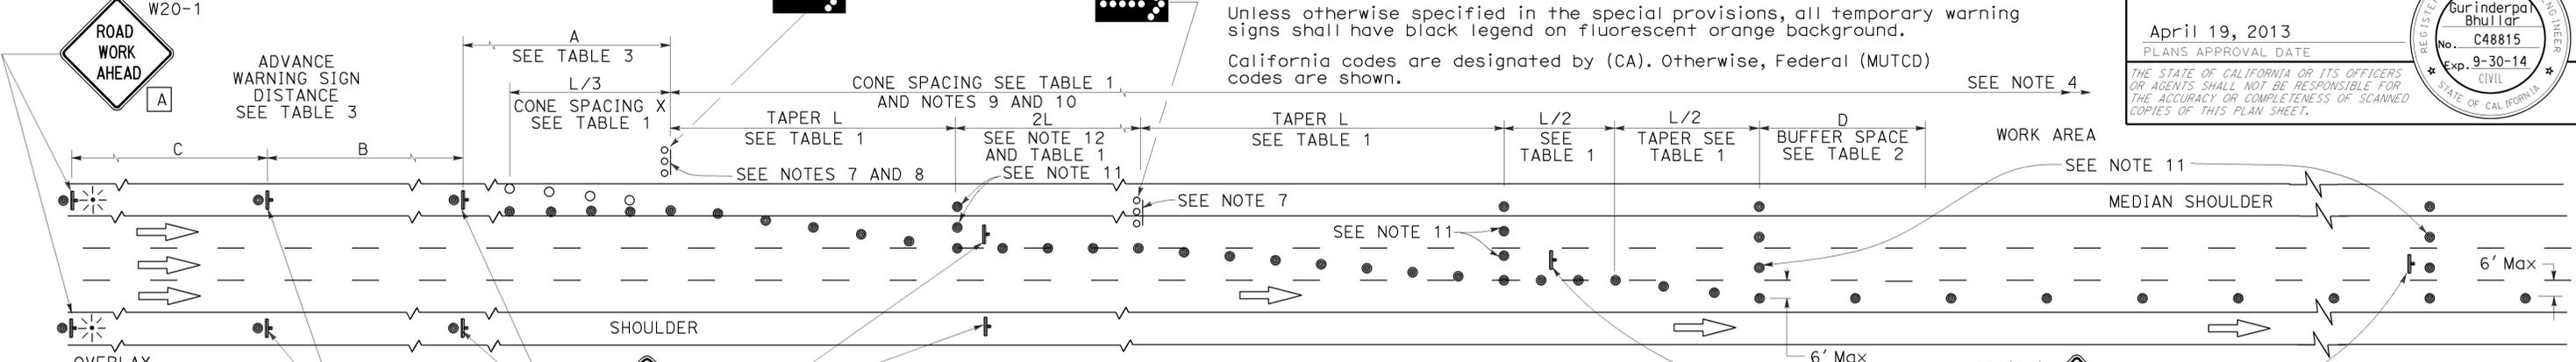

LANE CLOSURE WITH PARTIAL SHOULDER USE

SEE NOTES 3 AND 5

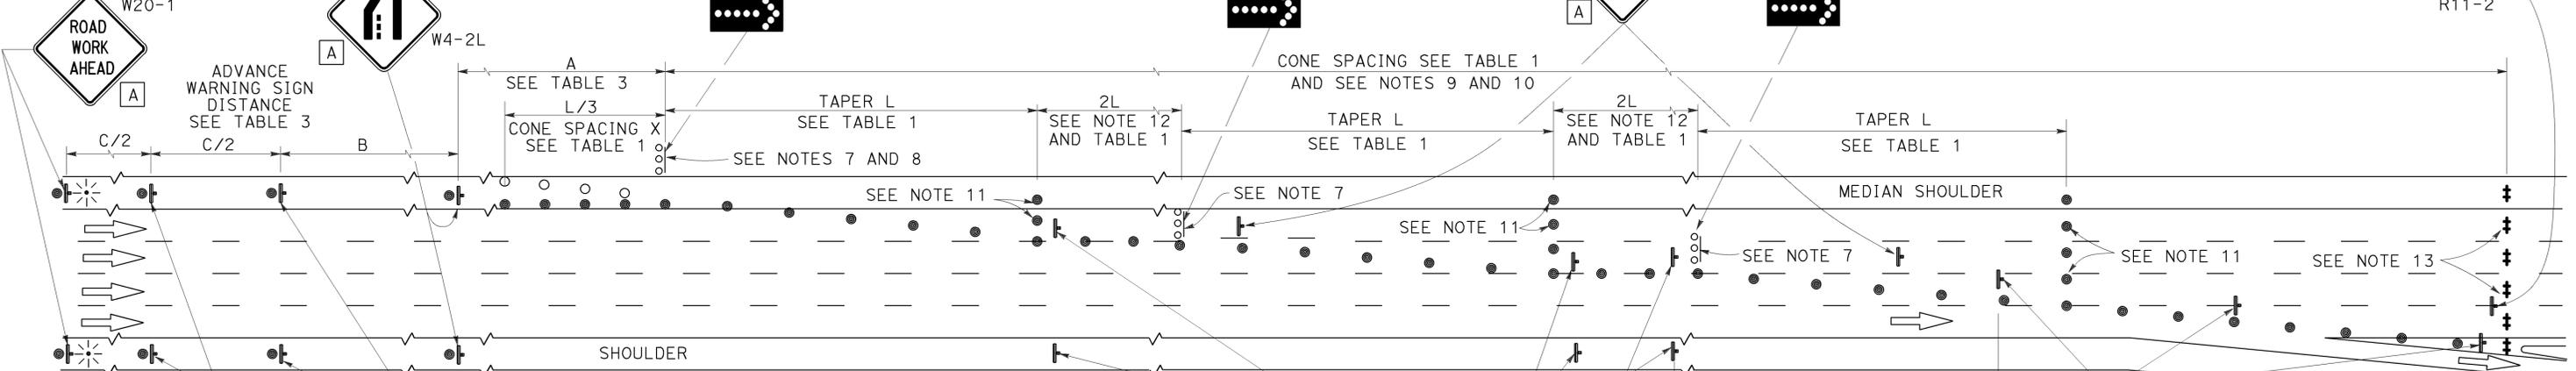

COMPLETE CLOSURE

NOTES:

- Lane closures on the right side using partial median shoulder as a traffic lane shall conform to the details as shown except that C20(CA)R and W4-2R signs shall be used.
- At least one person shall be assigned to provide full time maintenance of traffic control devices for lane closures.
- Each advance warning sign on each side of the roadway shall be equipped with at least two flags for daytime closure. Each flag shall be at least 16" X 16" in size and shall be orange or fluorescent red-orange in color. Flashing beacons shall be placed at the locations indicated for lane closure during hours of darkness.
- A G20-2 "END ROAD WORK" sign, with minimum size of 48" x 24" as appropriate, shall be placed at the end of the lane closure unless the end of work area is obvious or ends within a larger project's limits.
- If the W20-1 sign would follow within 2000' of a stationary W20-1 or G20-1 "ROAD WORK NEXT ___ MILES", use a C20(CA) sign for the first advance warning sign.
- Place a C30(CA) sign every 2000' throughout length of lane closure.
- One flashing arrow sign for each lane closed. The flashing arrow signs shall be Type I.
- A minimum 1500' of sight distance shall be provided where possible for vehicles approaching the first flashing arrow sign. Lane closures shall not begin at the top of crest vertical curve or on a horizontal curve.
- All cones used for lane closures during the hours of darkness shall be fitted with retroreflective bands (or sleeves) as specified in the specifications.
- Portable delineators, placed at one-half the spacing indicated for traffic cones, may be used instead of cones for daytime closures only.
- Unless otherwise specified in the special provisions, a minimum of 3 cones shall be placed transversely across each closed lane and shoulder at each location where a taper across a traffic lane ends and every 2000' as shown on the "Lane Closure With Partial Shoulder Use" detail. Two Type II barricades may be used instead of the 3 cones. The transverse alignment of the cones or barricades on the closed shoulder may be shifted from the transverse alignment to provide access to the work.

- Unless otherwise specified in the special provisions, the 2L tangent shown along lane lines shall be used between the L tapers required for each closed traffic lane.
- A minimum of Two Type II or III barricades shall be placed across each closed lane and shoulder at the location shown and every 2000' within the complete closure area. Within the complete closure area, the transverse alignment of the barricades on the closed shoulder may be shifted from the transverse alignment to provide access to the work.
- When specified in the special provisions, a W20-2 "DETOUR AHEAD" sign is to be used in place of the W20-3 "FREEWAY CLOSED AHEAD" sign.

SIGN PANEL SIZE (Min)

- A 48" x 48"
- B 48" x 18"
- C 48" x 30"

LEGEND

- TRAFFIC CONE
- TRAFFIC CONE (OPTIONAL TAPER)
- † TEMPORARY TRAFFIC CONTROL SIGN
- FLASHING ARROW SIGN (FAS)
- FAS SUPPORT OR TRAILER
- ⊛ PORTABLE FLASHING BEACON

STATE OF CALIFORNIA
 DEPARTMENT OF TRANSPORTATION
**TRAFFIC CONTROL SYSTEM
 FOR LANE CLOSURES ON
 FREEWAYS AND EXPRESSWAYS**
 NO SCALE

RSP T10A DATED APRIL 19, 2013 SUPERSEDES STANDARD PLAN T10A DATED MAY 20, 2011 - PAGE 238 OF THE STANDARD PLANS BOOK DATED 2010.

REVISED STANDARD PLAN RSP T10A

2010 REVISED STANDARD PLAN RSP T10A

NOTES:

See Revised Standard Plan RSP T9 for tables.

Use cone spacing X for taper segment, Y for tangent segment or Z for conflict situations, as appropriate, per Table 1, unless X, Y, or Z cone spacing is shown on this sheet.

Unless otherwise specified in the special provisions, all temporary warning signs shall have black legend on fluorescent orange background.

California codes are designated by (CA). Otherwise, Federal (MUTCD) codes are shown.

Dist	COUNTY	ROUTE	POST MILES TOTAL PROJECT	SHEET No.	TOTAL SHEETS
05	SB	101	2.2/3.3	478	786

Devinder Singh
REGISTERED CIVIL ENGINEER


October 30, 2015
PLANS APPROVAL DATE

Devinder Singh
No. C50470
Exp. 6-30-17
CIVIL
STATE OF CALIFORNIA

THE STATE OF CALIFORNIA OR ITS OFFICERS OR AGENTS SHALL NOT BE RESPONSIBLE FOR THE ACCURACY OR COMPLETENESS OF SCANNED COPIES OF THIS PLAN SHEET.


TYPICAL LANE CLOSURE WITH REVERSIBLE CONTROL

TO ACCOMPANY PLANS DATED 12-7-15

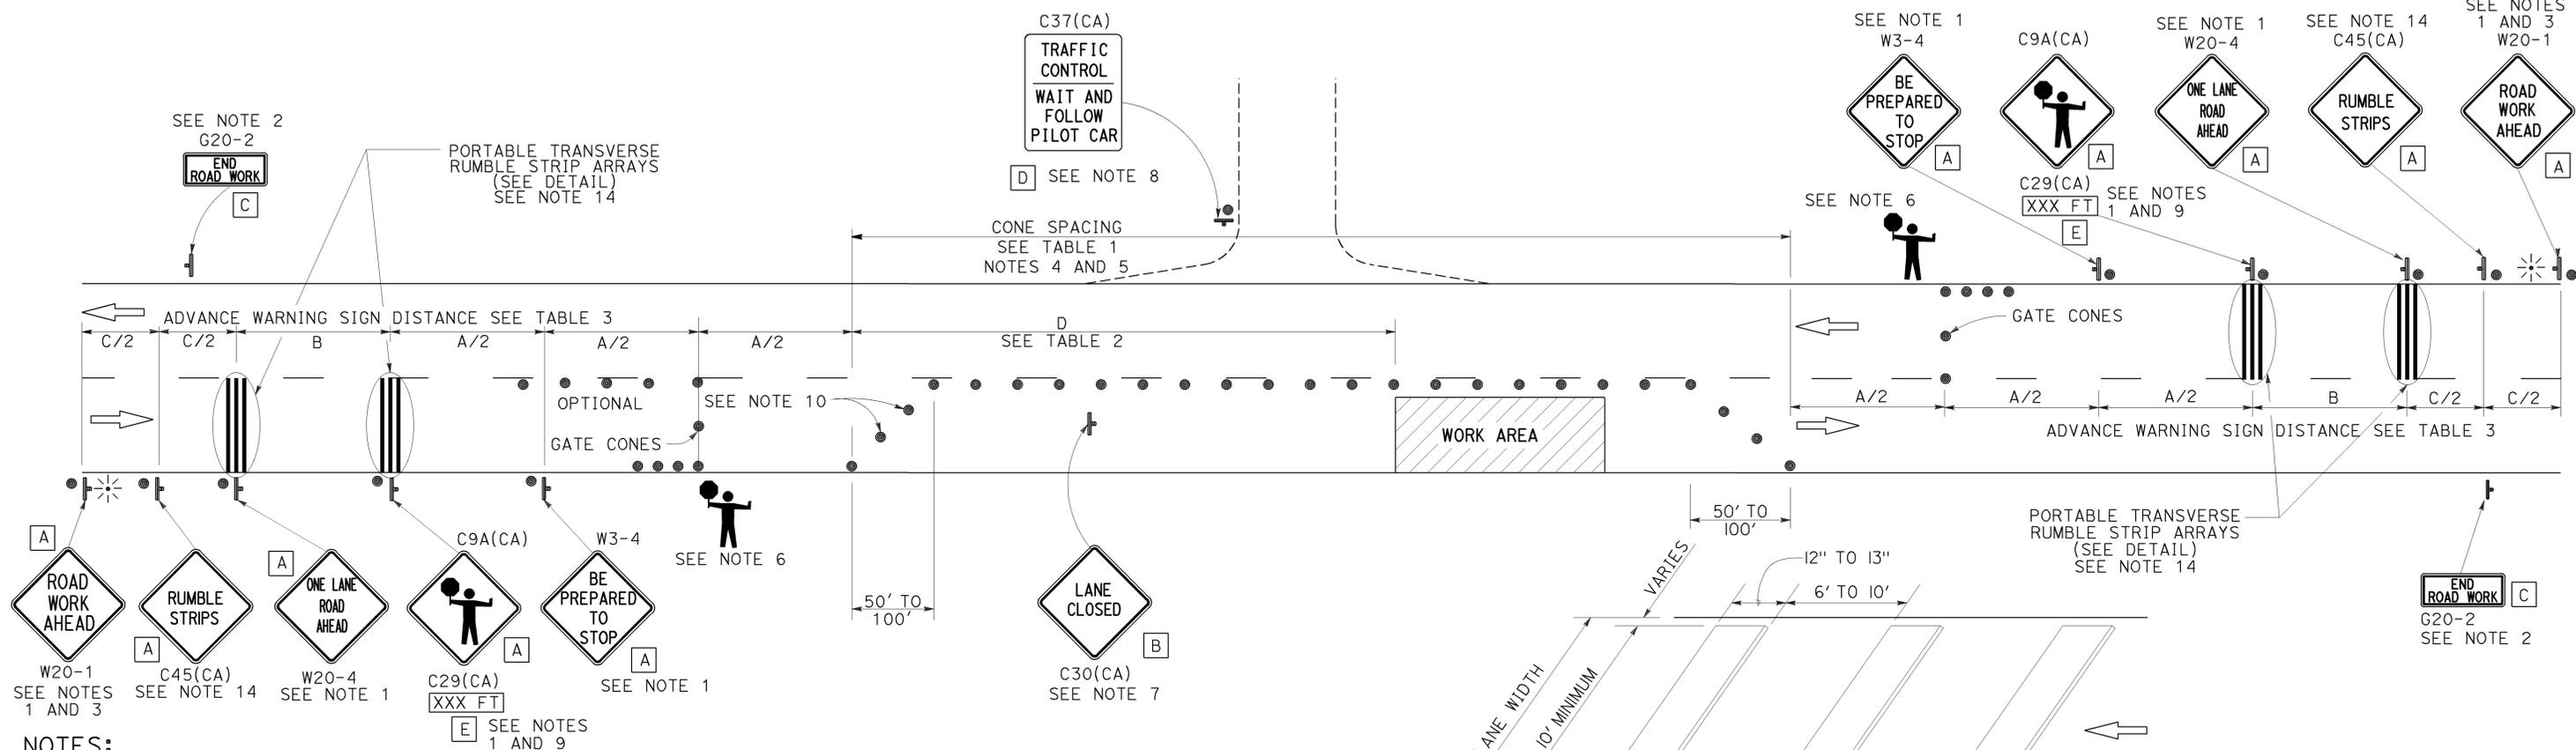

NOTES:

- Each advance warning sign in each direction of travel shall be equipped with at least two flags for daytime closure. Each flag shall be at least 16" x 16" in size and shall be orange or fluorescent red-orange in color. Flashing beacons shall be placed at the locations indicated for lane closure during hours of darkness.
- A G20-2 "END ROAD WORK" sign, as appropriate, shall be placed at the end of the lane control unless the end of work area is obvious, or ends within a larger project's limits.
- If the W20-1 sign would follow within 2000' of a stationary W20-1 or G20-1 "ROAD WORK NEXT _____ MILES", use a W20-4 sign for the first advance warning sign.
- All cones used for lane closures during the hours of darkness shall be fitted with retroreflective bands (or sleeves) as specified in the specifications.
- Portable delineators, placed at one-half the spacing indicated for traffic cones, may be used instead of cones for daytime closures only.
- Additional advance flaggers may be required. Flagger should stand in a conspicuous place, be visible to approaching traffic as well as approaching vehicles after the first vehicle has stopped. During the hours of darkness, the flagging-station and flagger shall be illuminated and clearly visible to approaching traffic. The illumination footprint of the lighting on the ground shall be at least 20' in diameter. Place a minimum of four cones at 50' intervals in advance of flagger station as shown.
- Place C30(CA) "LANE CLOSED" sign at 500' to 1000' intervals throughout extended work areas. They are optional if the work area is visible from the flagger station.
- When a pilot car is used, place a C37(CA) "TRAFFIC CONTROL-WAIT AND FOLLOW PILOT CAR" sign with black legend on white background at all intersections, driveways and alleys without a flagger within traffic control area. Signs shall be clean and visible at all times. Where traffic can not be effectively self-regulated, at least one flagger shall be used at each intersection within traffic control area.
- An optional C29(CA) sign may be placed below the C9A(CA) sign.
- Either traffic cones or barricades shall be placed on the taper. Barricades shall be Type I, II, or III.
- The color of the portable transverse rumble strips shall be black or orange. Use 2 arrays, each array shall consist of 3 rumble strips.
- Portable transverse rumble strips shall not be placed on sharp horizontal or vertical curves nor shall they be placed through pedestrian crossings.
- If the portable transverse rumble strips become out of alignment (skewed) by more than 6 inches, measured from one end to the other, they shall be readjusted to bring the placement back to the original location.
- Portable transverse rumble strips are not required if any one of the following conditions is satisfied:
 - Work duration occupies a location for four hours or less
 - Posted speed limit is below 45 MPH
 - Work is of emergency nature
 - Work zone is in snow or icy weather conditions

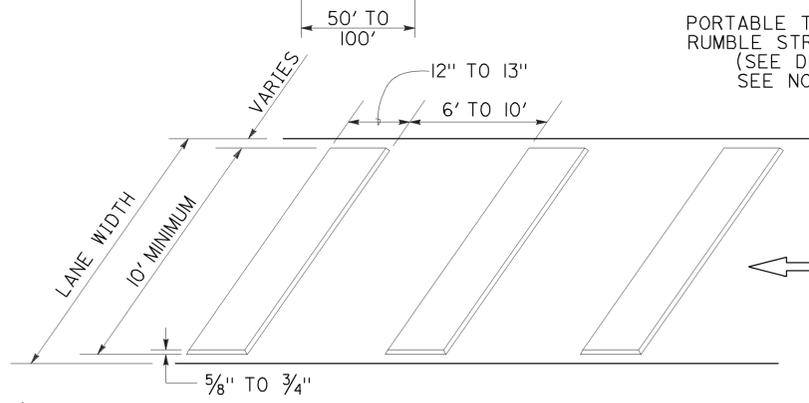

PORTABLE TRANSVERSE RUMBLE STRIP ARRAY DETAIL

SIGN PANEL SIZE (Min)

- A 48" x 48"
- B 30" x 30"
- C 36" x 18"
- D 36" x 42"
- E 20" x 7"

LEGEND

- TRAFFIC CONE
- ⊥ TEMPORARY TRAFFIC CONTROL SIGN
- ⚡ PORTABLE FLASHING BEACON
- 🚧 FLAGGER

STATE OF CALIFORNIA
DEPARTMENT OF TRANSPORTATION

TRAFFIC CONTROL SYSTEM FOR LANE CLOSURE ON TWO LANE CONVENTIONAL HIGHWAYS

NO SCALE

RSP T13 DATED OCTOBER 30, 2015 SUPERSEDES RSP T13 DATED OCTOBER 17, 2014, RSP T13 DATED JULY 18, 2014 AND RSP T13 DATED APRIL 19, 2013 AND STANDARD PLAN T13 DATED MAY 20, 2011 - PAGE 241 OF THE STANDARD PLANS BOOK DATED 2010.

REVISED STANDARD PLAN RSP T13

2010 REVISED STANDARD PLAN RSP T13

TYPICAL RAMP CLOSURES

SIGN PANEL SIZE (Min)

- A 48" x 48"
- B 48" x 30"
- C 36" x 36"
- D 48" x 36"

LEGEND

- TRAFFIC CONE
- † TEMPORARY TRAFFIC CONTROL SIGN
- ‡ BARRICADES
- ⚡ PORTABLE FLASHING BEACON

Dist	COUNTY	ROUTE	POST MILES TOTAL PROJECT	SHEET No.	TOTAL SHEETS
05	SB	101	2.2/3.3	479	786


Gurinderpal Bhullar
 REGISTERED CIVIL ENGINEER
 April 19, 2013
 PLANS APPROVAL DATE
THE STATE OF CALIFORNIA OR ITS OFFICERS OR AGENTS SHALL NOT BE RESPONSIBLE FOR THE ACCURACY OR COMPLETENESS OF SCANNED COPIES OF THIS PLAN SHEET.

REGISTERED PROFESSIONAL ENGINEER
 Gurinderpal Bhullar
 No. C48815
 Exp. 9-30-14
 CIVIL
 STATE OF CALIFORNIA


TO ACCOMPANY PLANS DATED 12-7-15

NOTES:


- Barricades shall be Type I, II, or III for closures lasting one week or less and Type III for closures lasting longer than one week.
- In addition to placing the C19(CA) "RAMP CLOSED AHEAD" and C30(CA) "RAMP CLOSED" signs, black on orange overlay plates with the word "CLOSED" may be mounted, as directed by the Engineer, on all guide signs that refer to the closed ramp. The letter size on the overlay shall be the same as the guide sign.
- Each advance C19(CA) "RAMP CLOSED AHEAD" sign shall be equipped with at least two flags for daytime closure. Each flag shall be at least 16" x 16" in size and shall be orange or fluorescent red-orange in color. A flashing beacon shall be placed on top of the first C19(CA) sign during hours of darkness.
- All cones used for ramp closures during the hours of darkness shall be fitted with retroreflective bands (or sleeves) as specified in the specifications.
- Portable delineators, placed at one-half the spacing indicated for traffic cones, may be used instead of cones for daytime ramp closures only.
- At least one person shall be assigned to provide full time maintenance of traffic control devices, unless otherwise directed by the Engineer.
- The existing "EXIT" signs shall be covered during ramp closures.
- A minimum of 3 cones shall be placed transversely across each closed lane and shoulder.

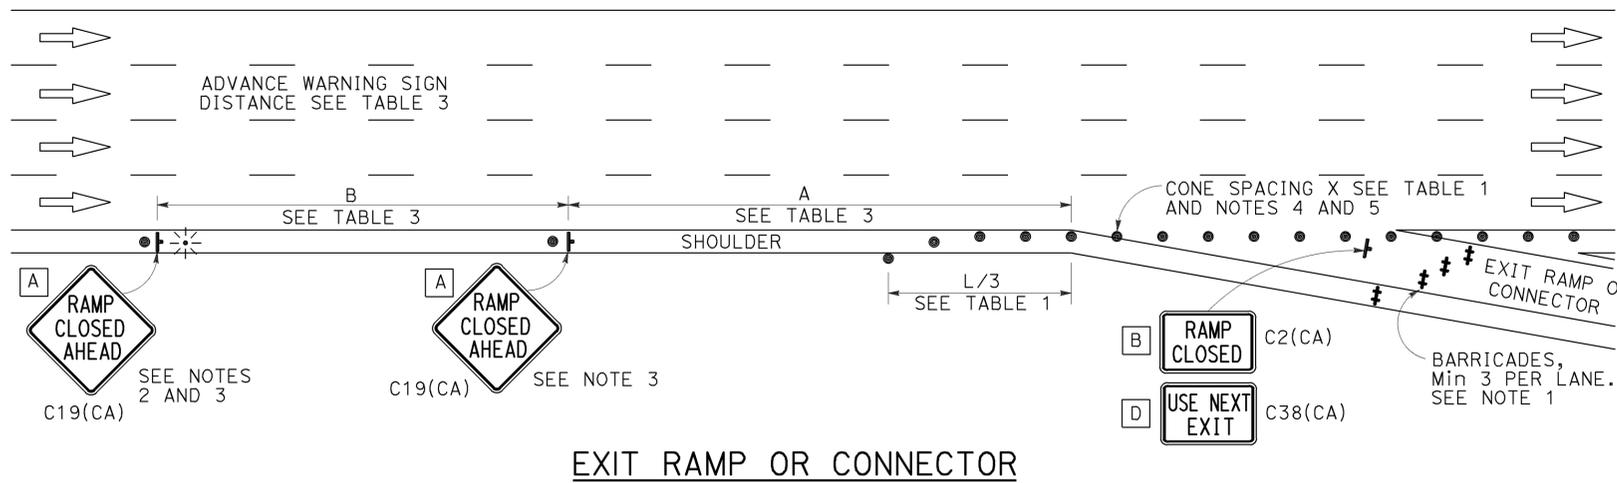


EXIT RAMP OR CONNECTOR

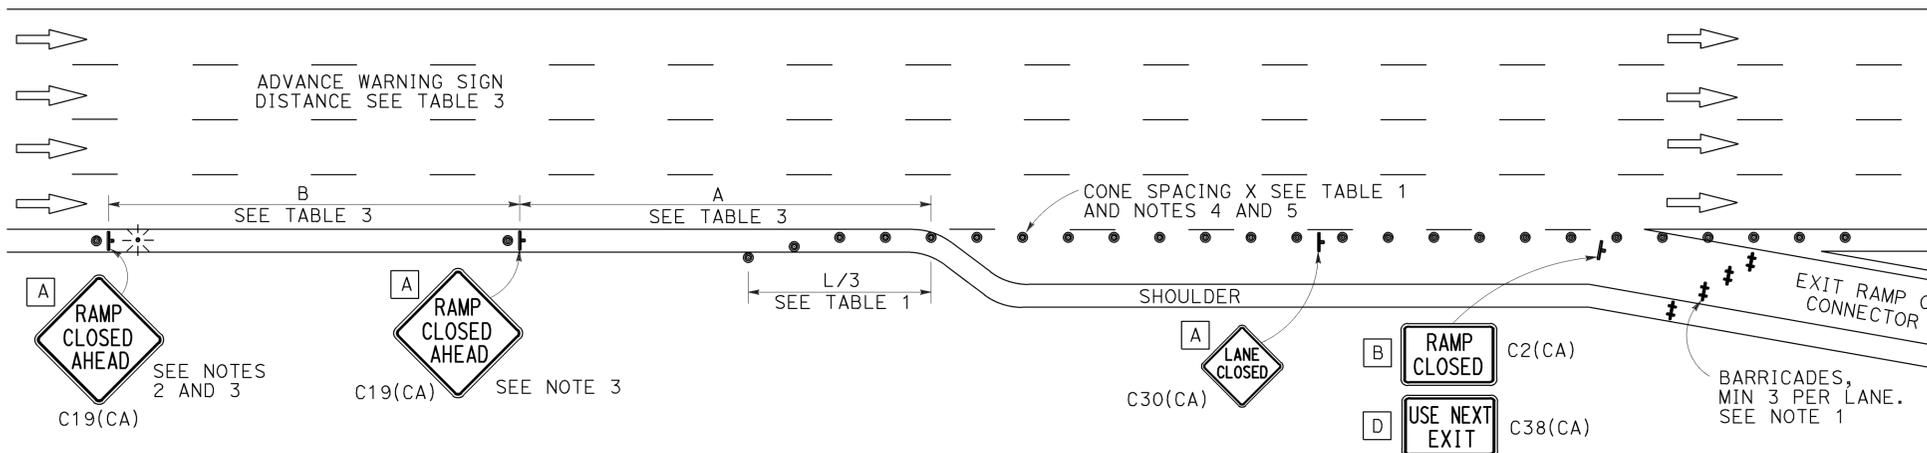

EXIT RAMP OR CONNECTOR WITH ADDITIONAL LANE

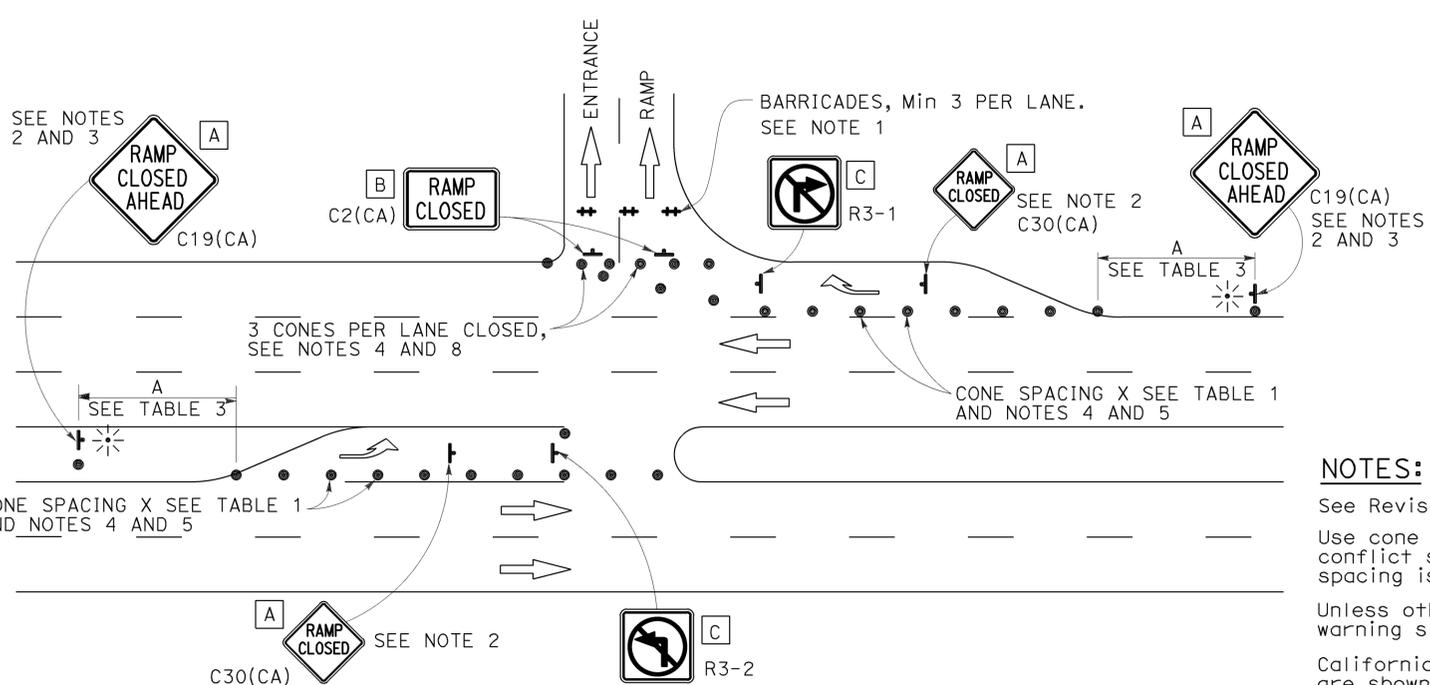

ENTRANCE RAMP WITH TURNING POCKETS

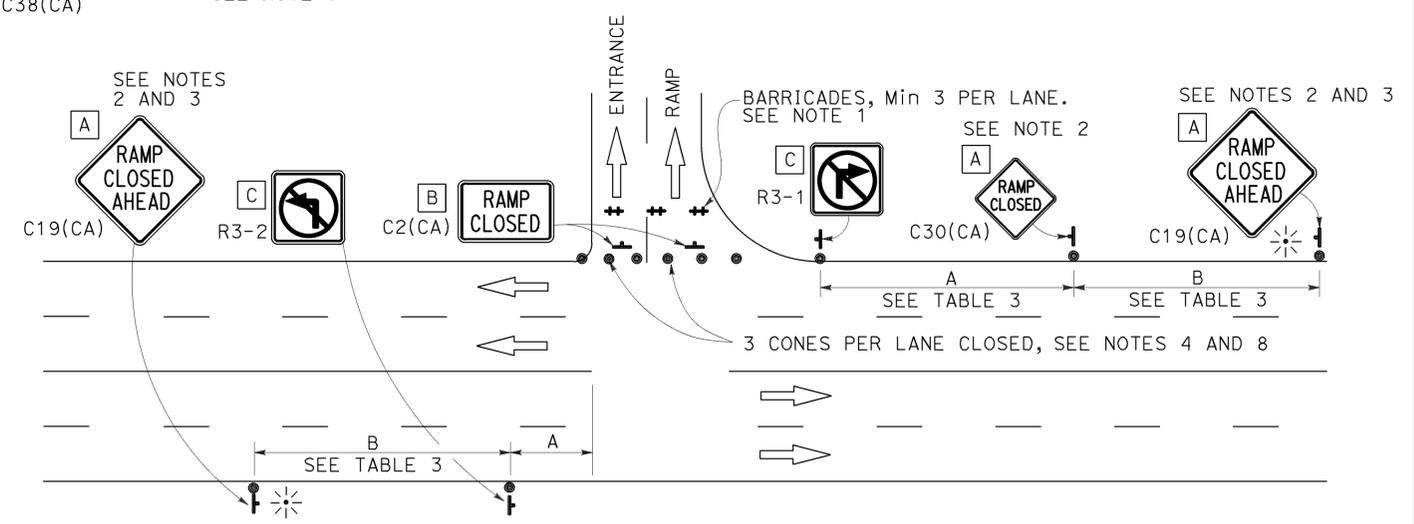

ENTRANCE RAMP WITHOUT TURNING POCKETS

NOTES:

- See Revised Standard Plan RSP T9 for tables.
- Use cone spacing X for taper segment, Y for tangent segment or Z for conflict situations, as appropriate, per Table 1, unless X, Y, or Z cone spacing is shown on this sheet.
- Unless otherwise specified in the special provisions, all temporary warning signs shall have black legend on fluorescent orange background.
- California codes are designated by (CA). Otherwise, Federal (MUTCD) codes are shown.


STATE OF CALIFORNIA
 DEPARTMENT OF TRANSPORTATION
**TRAFFIC CONTROL SYSTEM
 FOR RAMP CLOSURE**
 NO SCALE

RSP T14 DATED APRIL 19, 2013 SUPERSEDES STANDARD PLAN T14
 DATED MAY 20, 2011 - PAGE 242 OF THE STANDARD PLANS BOOK DATED 2010.
REVISED STANDARD PLAN RSP T14

2010 REVISED STANDARD PLAN RSP T14



TO ACCOMPANY PLANS DATED 12-7-15

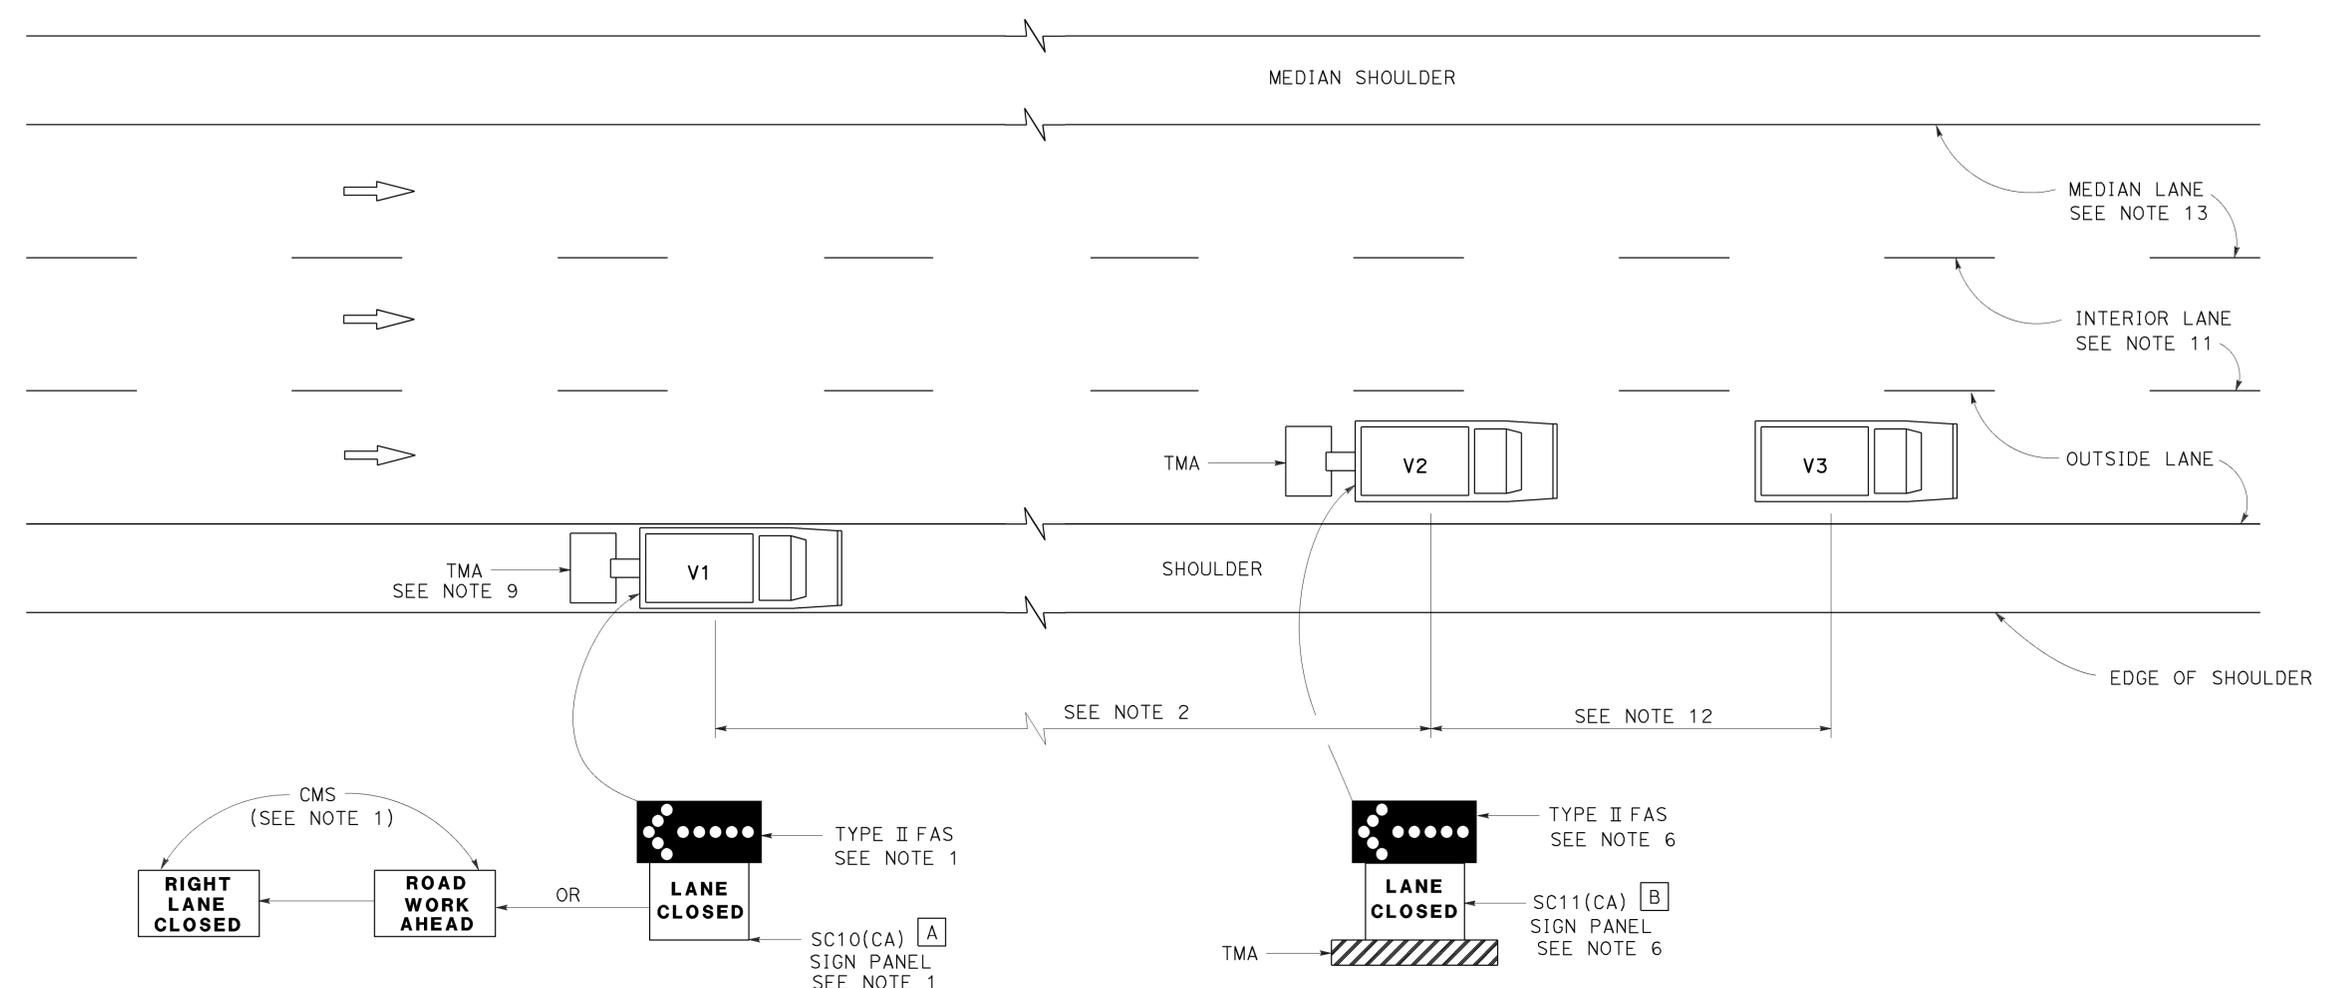

SIGN PANEL SIZE (Min)

- A 66" x 36"
- B 54" x 42"

LEGEND

- V1 SIGN VEHICLE
- V2 SHADOW VEHICLE
- V3 WORK/APPLICATION VEHICLE
- FLASHING ARROW SIGN (FAS)
- CMS CHANGEABLE MESSAGE SIGN
- TMA TRUCK-MOUNTED ATTENUATOR

MOVING LANE CLOSURE ON MEDIAN LANE OR OUTSIDE LANE OF MULTILANE HIGHWAYS

NOTES:

1. Either a changeable message sign or a SC10(CA) sign panel and a Type II flashing arrow sign shall be mounted on the rear of sign vehicle V1. The changeable message sign shall be sequenced to show the "ROAD WORK AHEAD" message first, followed by the "RIGHT LANE CLOSED" message. For median lane closure, the flashing arrow symbol shall be reversed with the arrowhead on the right and the changeable message sign shall show "LEFT LANE CLOSED".
2. If traffic queues develop, sign vehicle V1 should be positioned upstream from the end of queue. Sign vehicle V1 shall be positioned where highly visible when shoulders are not available.
3. A minimum sight distance of 1500' should be provided in advance of sign vehicle V1.
4. Sign vehicle V1 should remain at the beginning of horizontal or vertical curves until the other vehicles (V2 and V3) are far enough beyond the curve to resume the minimum sight distance of 1500'.
5. Vehicle-mounted sign panels shall have Type III or above retroreflective sheeting, black on white, or black on fluorescent orange, with 6" minimum series D letters per Caltrans sign specifications.
6. Shadow vehicle V2 shall be equipped with a truck-mounted attenuator. The sign panel shown and a Type II flashing arrow sign shall be mounted on the rear of shadow vehicle V2. For median lane closure the flashing arrow sign symbol shall be displayed with the arrowhead on the right.
7. All vehicles used for lane closures shall be equipped with two-way radios, and the vehicle operators shall maintain communication during the work or application operation.
8. All vehicles shall be equipped with flashing or rotating amber lights.
9. If sign vehicle V1 encroaches into the traffic lane due to insufficient shoulder width, sign vehicle V1 shall be equipped with a truck-mounted attenuator. Sign vehicle V1 shall stay as close to the edge of shoulder as practicable.
10. Where workers would be on foot in the work area, a stationary type lane closure (Revised Standard Plan T10, T11, etc., as applicable) shall be used instead of this plan.
11. For moving lane closure on interior lane of multilane highways, use Revised Standard Plan T16.
12. The spacing between work vehicle(s) and the shadow vehicles, and between each shadow vehicle should be minimized to deter road users from driving in between.
13. When the work/application vehicle V3 occupies the median lane, sign vehicle V1 should drive in the median shoulder and indicate left lane closed ahead.

STATE OF CALIFORNIA
DEPARTMENT OF TRANSPORTATION


TRAFFIC CONTROL SYSTEM FOR MOVING LANE CLOSURE ON MULTILANE HIGHWAYS
NO SCALE

RSP T15 DATED APRIL 19, 2013 SUPERSEDES STANDARD PLAN T15 DATED MAY 20, 2011 - PAGE 243 OF THE STANDARD PLANS BOOK DATED 2010.

REVISED STANDARD PLAN RSP T15


2010 REVISED STANDARD PLAN RSP T15

Dist	COUNTY	ROUTE	POST MILES TOTAL PROJECT	SHEET No.	TOTAL SHEETS
05	SB	101	2.2/3.3	481	786

 
 REGISTERED CIVIL ENGINEER
 April 19, 2013
 PLANS APPROVAL DATE
THE STATE OF CALIFORNIA OR ITS OFFICERS OR AGENTS SHALL NOT BE RESPONSIBLE FOR THE ACCURACY OR COMPLETENESS OF SCANNED COPIES OF THIS PLAN SHEET.



TO ACCOMPANY PLANS DATED 12-7-15

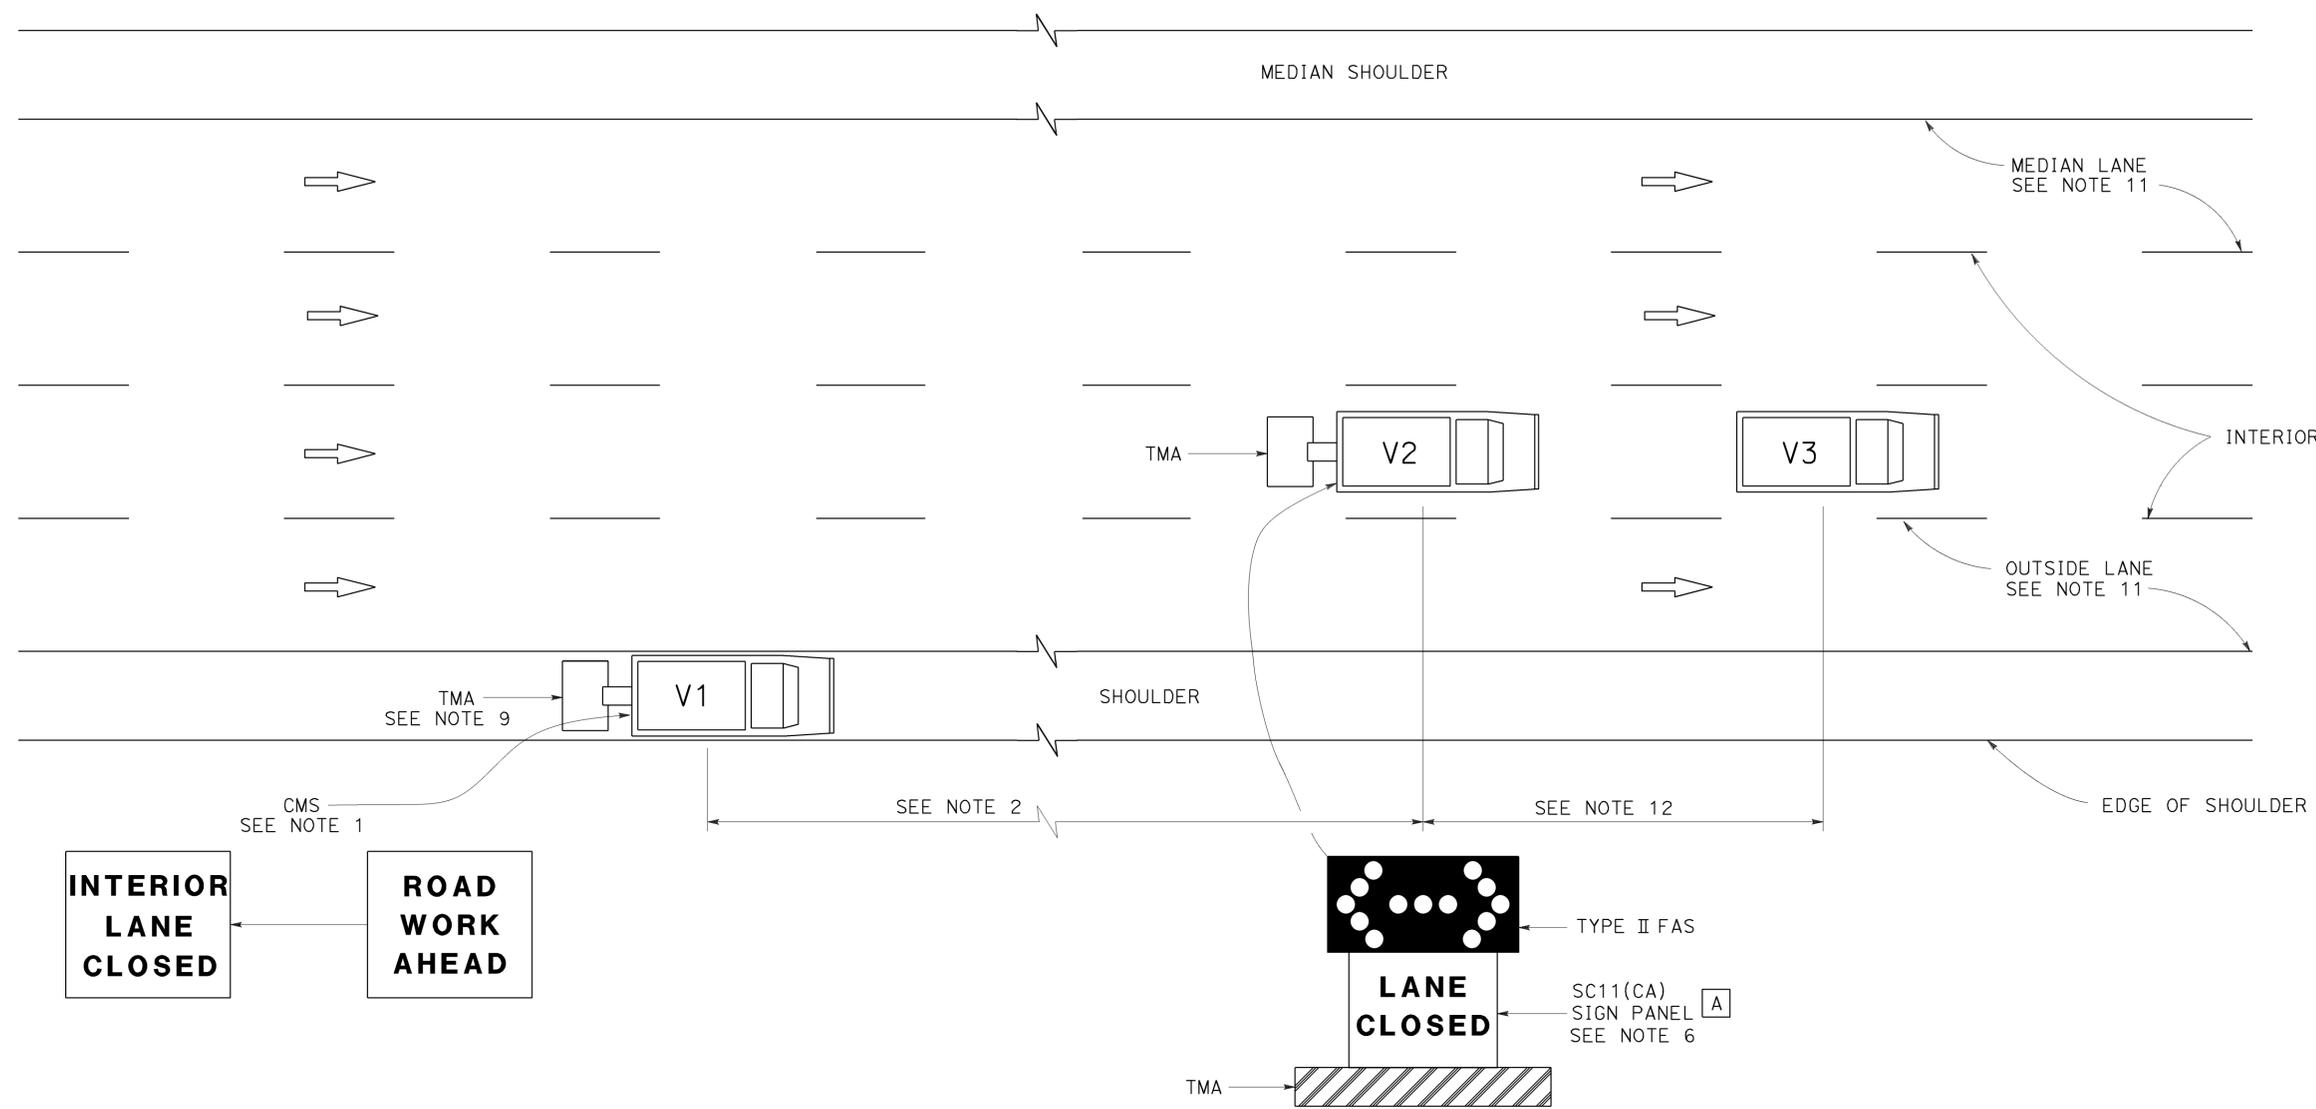

SIGN PANEL SIZE (Min)

A 54" x 42"

LEGEND

- V1 SIGN VEHICLE
- V2 SHADOW VEHICLE
- V3 WORK/APPLICATION VEHICLE
-  FLASHING ARROW SIGN (FAS) IN FLASHING DOUBLE ARROW MODE
- CMS CHANGEABLE MESSAGE SIGN
- TMA TRUCK-MOUNTED ATTENUATOR

MOVING LANE CLOSURE ON INTERIOR LANE OF MULTILANE HIGHWAYS

NOTES:

1. A changeable message sign shall be mounted on the rear of sign vehicle V1. The changeable message sign shall be sequenced to show the "ROAD WORK AHEAD" message first, followed by the "INTERIOR LANE CLOSED" message. The message "CENTER LANE CLOSED" may be used in place of the "INTERIOR LANE CLOSED" message.
2. If traffic queues develop, sign vehicle V1 should be positioned upstream from the end of queue. Sign vehicle V1 shall be positioned where highly visible when shoulders are not available.
3. A minimum sight distance of 1500' should be provided in advance of sign vehicle V1.
4. Sign vehicle V1 should remain at the beginning of horizontal or vertical curves until the other vehicles (V2 and V3) are far enough beyond the curve to resume the minimum sight distance of 1500'.
5. Vehicle-mounted sign panels shall have Type III or above retroreflective sheeting, black on white, or black on fluorescent orange, with 6" minimum series D letters per Caltrans sign specifications.
6. Shadow vehicle V2 shall be equipped with a truck-mounted attenuator. The sign panel shown and a Type II flashing arrow sign shall be mounted on the rear of shadow vehicle V2.
7. All vehicles used for lane closures shall be equipped with two-way radios, and the vehicle operators shall maintain communication during the work or application operation.
8. All vehicles shall be equipped with flashing or rotating amber lights.
9. If sign vehicle V1 encroaches into the traffic lane due to insufficient shoulder width, sign vehicle V1 shall be equipped with a truck-mounted attenuator. Sign vehicle V1 shall stay as close to the edge of shoulder as practicable.
10. Where workers would be on foot in the work area, a stationary type lane closure (Revised Standard Plan T10, T11 etc., as applicable) shall be used instead of this plan.
11. For moving lane closure on median lane or outside lane of multilane highways, use Revised Standard Plan T15.
12. The spacing between work vehicle(s) and the shadow vehicles, and between each shadow vehicle should be minimized to deter road users from driving in between.


STATE OF CALIFORNIA
 DEPARTMENT OF TRANSPORTATION
**TRAFFIC CONTROL SYSTEM
 FOR MOVING LANE CLOSURE
 ON MULTILANE HIGHWAYS**
 NO SCALE

RSP T16 DATED APRIL 19, 2013 SUPERSEDES STANDARD PLAN T16 DATED MAY 20, 2011 - PAGE 244 OF THE STANDARD PLANS BOOK DATED 2010.

REVISED STANDARD PLAN RSP T16

2010 REVISED STANDARD PLAN RSP T16

TO ACCOMPANY PLANS DATED 12-7-15

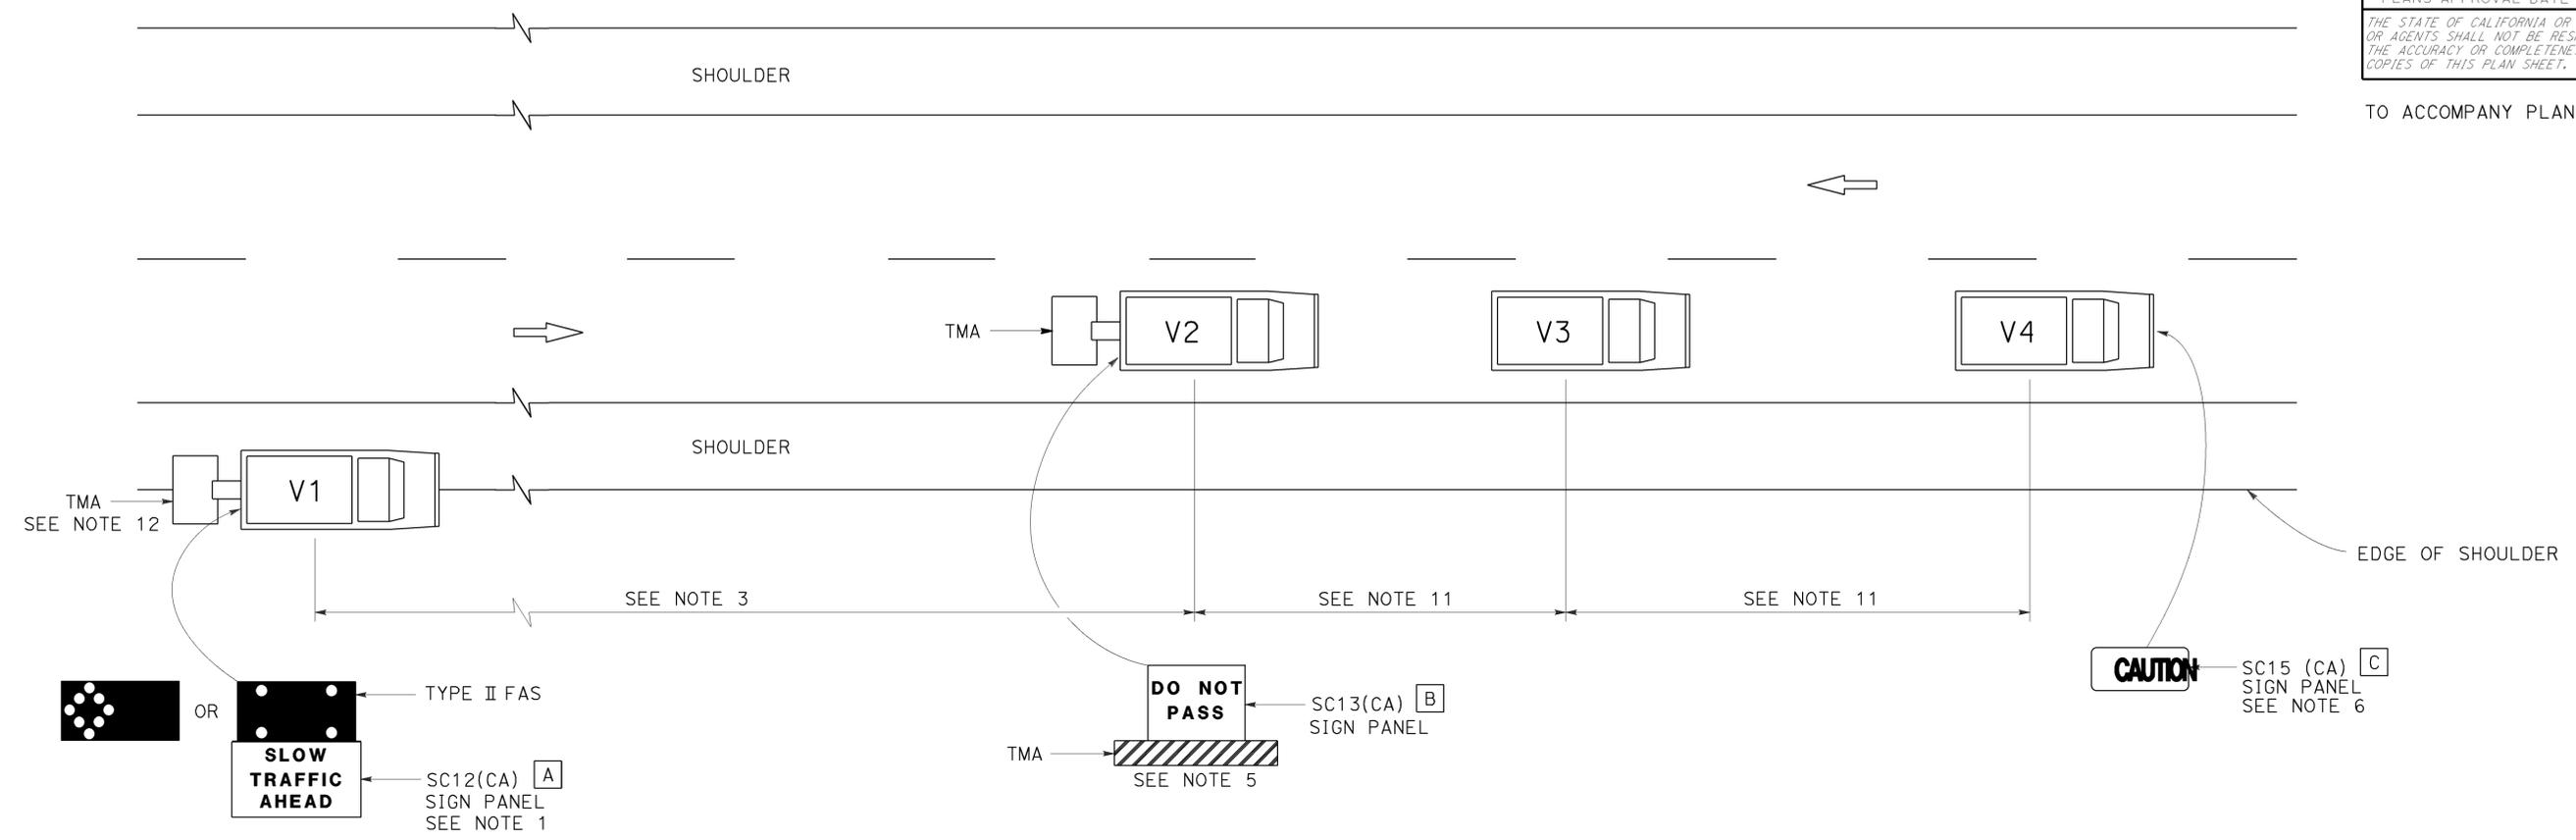

NOTES:

1. Either a changeable message sign or a SC12(CA) "SLOW TRAFFIC AHEAD" sign shall be mounted on the rear of sign vehicle V1. The changeable message sign shall be sequenced to show the "CAUTION" message first, follow by the "SLOW TRAFFIC AHEAD" message. A Type II flashing arrow sign may be used with the SC12(CA) sign panel.
2. Sign vehicle V1 should be positioned where highly visible when shoulders are not available.
3. If traffic queues develop, sign vehicle V1 should be positioned upstream from the end of queue.
4. Vehicle-mounted sign panels shall have Type III or above retroreflective sheeting, black on white, or black on fluorescent orange, with 6" minimum series D letters per Caltrans sign specifications.
5. Shadow vehicle shall be equipped with a truck-mounted attenuator. The sign panel shown shall be mounted on the rear of shadow vehicle V2. The message "LANE CLOSED" may be used in place of the "DO NOT PASS" message.
6. The sign panel shown shall be mounted on the front of sign vehicle V4, facing opposing traffic.

7. All vehicles shall be equipped with flashing or rotating amber lights.
8. Sign vehicle V4 will not be required when the work and vehicles V2 and V3 are 2' or more from the centerline of the highway during the work or application operations.
9. All vehicles used for lane closures shall be equipped with two-way radios and the vehicle operators shall maintain communication during the work or application operation.
10. This plan shall not be used where workers would be on foot in the work area. Use a stationary type lane closure (Revised Standard Plan T13) for this condition.
11. Minimize spacing between vehicles V2 and V3 and vehicles V3 and V4 to deter road users from driving in between them.
12. If sign vehicle V1 encroaches into the traffic lane due to insufficient shoulder width, sign vehicle V1 shall be equipped with a truck-mounted attenuator. Sign vehicle V1 shall stay as close to the edge of shoulder as practicable.

LEGEND

- V1 SIGN VEHICLE
- V2 SHADOW VEHICLE
- V3 WORK/APPLICATION VEHICLE
- V4 SIGN VEHICLE
- TMA TRUCK-MOUNTED ATTENUATOR
- FLASHING ARROW SIGN (FAS) IN FLASHING CAUTION MODE
- FLASHING ARROW SIGN (FAS) IN ALTERNATING DIAMOND CAUTION

SIGN PANEL SIZE (Min)

- A 72" x 42"
- B 54" x 42"
- C 54" x 24"

STATE OF CALIFORNIA
 DEPARTMENT OF TRANSPORTATION
**TRAFFIC CONTROL SYSTEM
 FOR MOVING LANE CLOSURE
 ON TWO LANE HIGHWAYS**
 NO SCALE


RSP T17 DATED APRIL 19, 2013 SUPERSEDES STANDARD PLAN T17 DATED MAY 20, 2011 - PAGE 245 OF THE STANDARD PLANS BOOK DATED 2010.

REVISED STANDARD PLAN RSP T17


2010 REVISED STANDARD PLAN RSP T17

DESIGN CONDITIONS:

Design H may be exceeded by 6" before going to the next size. Special footing design is required where foundation material is incapable of supporting bearing stress listed in the table.

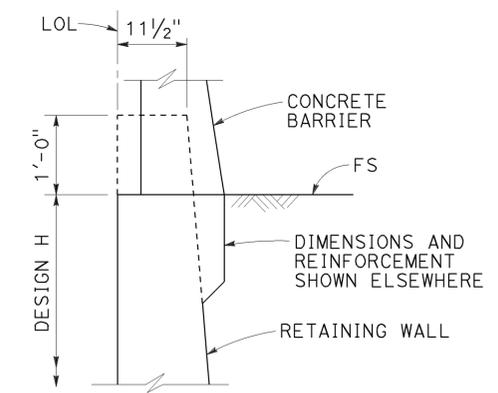


STEM HAUNCH DETAIL

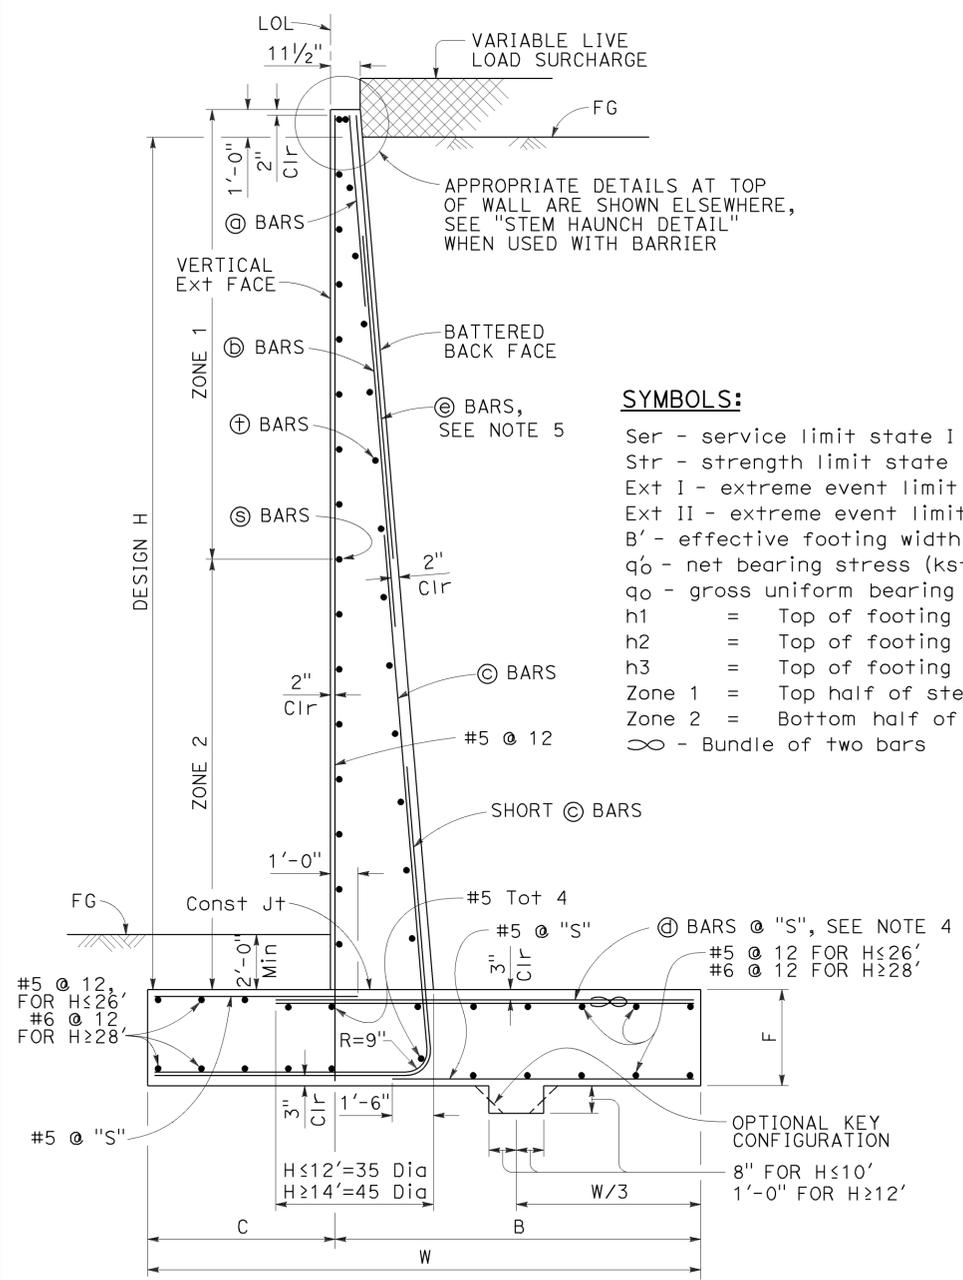

TYPICAL SECTION

NOTES:

- For details not shown and drainage notes see RSP B3-5
- For wall stem joint details see B0-3 3-3 and B0-3 3-4
- At © bars:
 $H \leq 6'$, no splices are allowed within 1'-8" above the top of footing.
 $H > 6'$, no splices are allowed within $H/4$ above the top of footing.
- Bundle © bars for $H = 34'$ & $36'$.
- Provide #6 @ 10" x 15'-0" © bars over a distance of 8'-0" measured from all expansion joints, begin wall and end wall locations. For $H \leq 14'$, hook © bar into footing and reduce bar length as needed to maintain Min Clr cover.

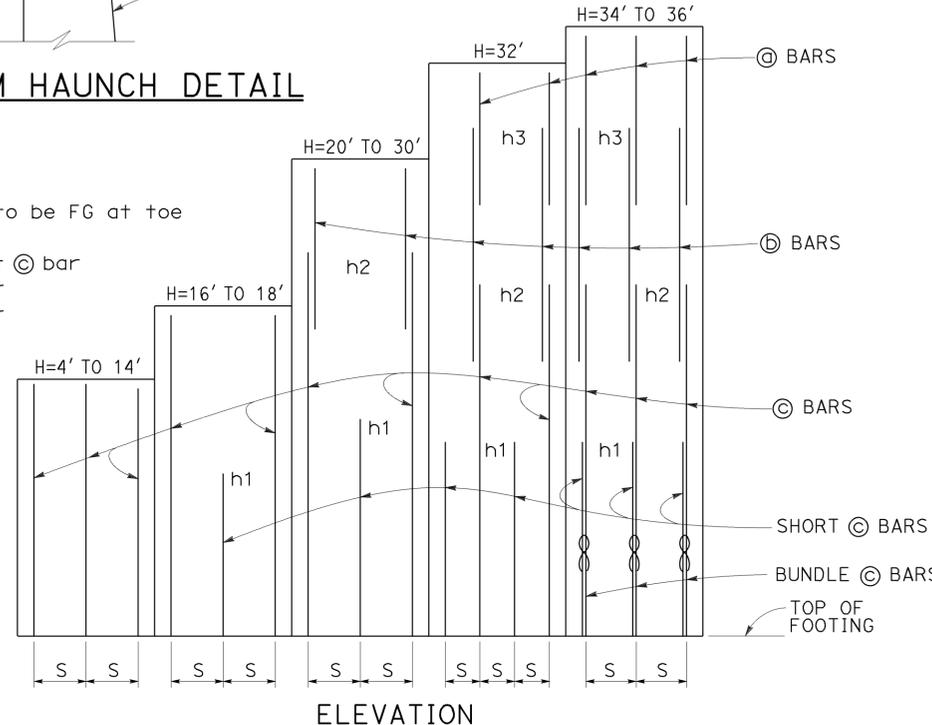

ELEVATION

TABLE OF REINFORCING STEEL, DIMENSIONS AND DATA

DESIGN H	4'	6'	8'	10'	12'	14'	16'	18'	20'	22'	24'	26'	28'	30'	32'	34'	36'
W	6'-10"	7'-0"	7'-3"	7'-7"	8'-4"	9'-7"	10'-9"	12'-0"	13'-3"	14'-6"	15'-9"	17'-1"	18'-5"	19'-10"	21'-2"	22'-7"	24'-0"
C	2'-2"	2'-3"	2'-3"	2'-4"	2'-6"	3'-0"	3'-6"	4'-0"	4'-6"	5'-0"	5'-5"	6'-0"	6'-6"	7'-2"	7'-8"	8'-2"	9'-0"
B	4'-8"	4'-9"	5'-0"	5'-3"	5'-10"	6'-7"	7'-3"	8'-0"	8'-9"	9'-6"	10'-4"	11'-1"	11'-11"	12'-8"	13'-6"	14'-5"	15'-0"
F	1'-4"	1'-4"	1'-4"	1'-4"	1'-6"	1'-8"	1'-8"	1'-9"	1'-9"	1'-11"	2'-2"	2'-5"	2'-10"	3'-3"	3'-6"	4'-0"	4'-3"
BATTER	1/2: 12	1/2: 12	1/2: 12	1/2: 12	1/2: 12	1/2: 12	1/2: 12	1/2: 12	1/2: 12	1/2: 12	5/8: 12	5/8: 12	3/4: 12	7/8: 12	1: 12	1: 12	1: 12
SPACING "S"	9"	9"	9"	9"	9"	7"	6"	5"	6"	6"	6"	6"	6"	6"	6"	10"	8"
© BARS	-	-	-	-	-	-	-	-	-	-	-	-	-	-	-	-	-
B BARS	-	-	-	-	-	-	-	-	#7	#7	#7	#7	#7	#7	#7	#7	#7
© BARS	#6	#6	#6	#6	#6	#6	#7	#7	#8	#9	#9	#10	#10	#10	#11	#11	#11
© BARS	#5	#5	#6	#6	#6	#6	#9	#8	#8	#9	#9	#10	#10	#10	#11	#11	#11
h1	-	-	-	-	-	-	5'-9"	5'-10"	8'-0"	9'-0"	10'-1"	11'-0"	12'-1"	13'-0"	13'-0"	12'-7"	11'-6"
h2	-	-	-	-	-	-	-	-	10'-5"	13'-0"	14'-7"	17'-6"	19'-0"	20'-5"	19'-0"	18'-0"	20'-2"
h3	-	-	-	-	-	-	-	-	-	-	-	-	-	-	21'-2"	21'-10"	24'-0"
ZONE 1 © BARS	#5 @ 18	#5 @ 18	#5 @ 18	#5 @ 18	#5 @ 18	#5 @ 18	#5 @ 18	#5 @ 18	#5 @ 18	#5 @ 18	#5 @ 12	#5 @ 12	#5 @ 12	#5 @ 12	#5 @ 12	#5 @ 12	#5 @ 12
ZONE 2 © BARS	#5 @ 18	#5 @ 18	#5 @ 18	#5 @ 18	#5 @ 18	#5 @ 18	#5 @ 12	#5 @ 12	#5 @ 12	#5 @ 12	#5 @ 12	#5 @ 12	#6 @ 12	#6 @ 12	#6 @ 12	#7 @ 12	#7 @ 12
ZONE 1 B BARS	#4 @ 18	#4 @ 18	#4 @ 18	#4 @ 18	#4 @ 18	#4 @ 18	#4 @ 18	#4 @ 18	#4 @ 18	#4 @ 18	#4 @ 12	#4 @ 12	#4 @ 18	#4 @ 12	#4 @ 12	#4 @ 12	#4 @ 12
ZONE 2 B BARS	#4 @ 18	#4 @ 18	#4 @ 18	#4 @ 18	#4 @ 18	#4 @ 18	#4 @ 18	#4 @ 18	#4 @ 18	#4 @ 18	#4 @ 12	#4 @ 12	#4 @ 12	#4 @ 12	#5 @ 12	#5 @ 12	#5 @ 12
Ser: B', q ₀	6.8, 0.7	6.5, 1.0	6.2, 1.3	6.0, 1.6	6.3, 2.0	7.5, 2.1	8.6, 2.2	9.8, 2.3	11.0, 2.4	12.1, 2.5	13.2, 2.8	14.4, 2.9	15.5, 3.1	16.8, 3.3	18.0, 3.5	19.2, 3.7	20.6, 3.7
Str: B', q ₀	6.6, 1.6	5.0, 1.8	3.6, 2.3	3.0, 3.3	3.2, 4.0	4.3, 3.8	5.3, 3.7	6.4, 3.7	7.4, 3.8	8.2, 4.1	9.0, 4.4	9.9, 4.6	10.7, 4.9	11.7, 5.2	12.6, 5.4	13.6, 5.8	14.6, 5.9
Ext I: B', q ₀	5.2, 1.1	4.7, 1.5	3.9, 2.2	3.1, 3.4	2.8, 4.8	3.2, 5.3	3.6, 5.7	4.1, 6.1	4.6, 6.4	5.0, 6.9	5.3, 7.6	5.8, 8.1	6.1, 8.9	6.7, 9.4	7.1, 10.0	7.5, 10.7	8.2, 10.9
Ext II: B', q ₀	2.6, 2.2	2.7, 2.6	2.8, 3.1	2.9, 3.6	3.7, 3.6	5.2, 3.3	6.7, 3.1	8.3, 3.0	9.8, 3.0	11.2, 3.1	12.5, 3.2	13.9, 3.4	15.2, 3.6	16.7, 3.8	18.0, 4.0	19.3, 4.2	20.8, 4.3

STATE OF CALIFORNIA
 DEPARTMENT OF TRANSPORTATION
RETAINING WALL TYPE 1 (CASE 1)
 NO SCALE

RSP B3-1A DATED APRIL 20, 2012 SUPPLEMENTS THE STANDARD PLANS BOOK DATED 2010.

2010 REVISED STANDARD PLAN RSP B3-1A

2010 REVISED STANDARD PLAN RSP B3-1B

DESIGN CONDITIONS:

Design H may be exceeded by 6" before going to the next size. Special footing design is required where foundation material is incapable of supporting bearing stress listed in the table.

DESIGN NOTES:

- DESIGN: AASHTO LRFD Bridge Design Specifications, 4th Edition with California Amendments
- LS: Varied surcharge on level ground surface
- DC: Stem Architectural Treatment of thickness up to 6" of concrete (75 psf) considered
- SEISMIC: $k_h = 0.2$
 $k_v = 0.0$
- SOIL: $\phi = 34^\circ$
 $\gamma = 120$ pcf
- REINFORCED CONCRETE: $f'_c = 3,600$ psi
 $f_y = 60,000$ psi
- LOAD COMBINATIONS AND LIMIT STATES:
 Service I $Q = 1.00DC + 1.00EV + 1.00EH + 1.00LS$
 Strength I $Q = \alpha DC + \beta EV + \eta EH + 1.75LS$
 Extreme I $Q = 1.00DC + 1.00EV + 1.00EH + 1.00EQD + 1.00EQE$
- Where:
 Q: Force Effects
 α : 1.25 or 0.90, Whichever Controls Design
 β : 1.35 or 1.00, Whichever Controls Design
 η : 1.50 or 0.90, Whichever Controls Design
 DC: Dead Load of Structure Components
 EH: Horizontal Earth Fill Pressure
 EV: Vertical Earth Pressure from Earth Fill Weight
 LS: Live Load Surcharge
 EQE: Seismic Earth Pressure
 EQD: Soil and Structural and Nonstructural Components Inertia

SYMBOLS:

- TO ACCOMPANY PLANS DATED 12-7-15
- Ser - service limit state I
 Str - strength limit state I
 Ext - extreme event limit state I
 B' - effective footing width (ft)
 q_0 - net bearing stress (ksf), OG assumed to be FG at toe
 q_0 - gross uniform bearing stress (ksf)
 h1 = Top of footing to top of short @ bar
 h2 = Top of footing to top of @ bar
 h3 = Top of footing to top of @ bar
 h4 = Top of footing to top of @ bar
 Zone 1 = Top half of stem height
 Zone 2 = Bottom half of stem height
 ∞ - Bundle of two bars

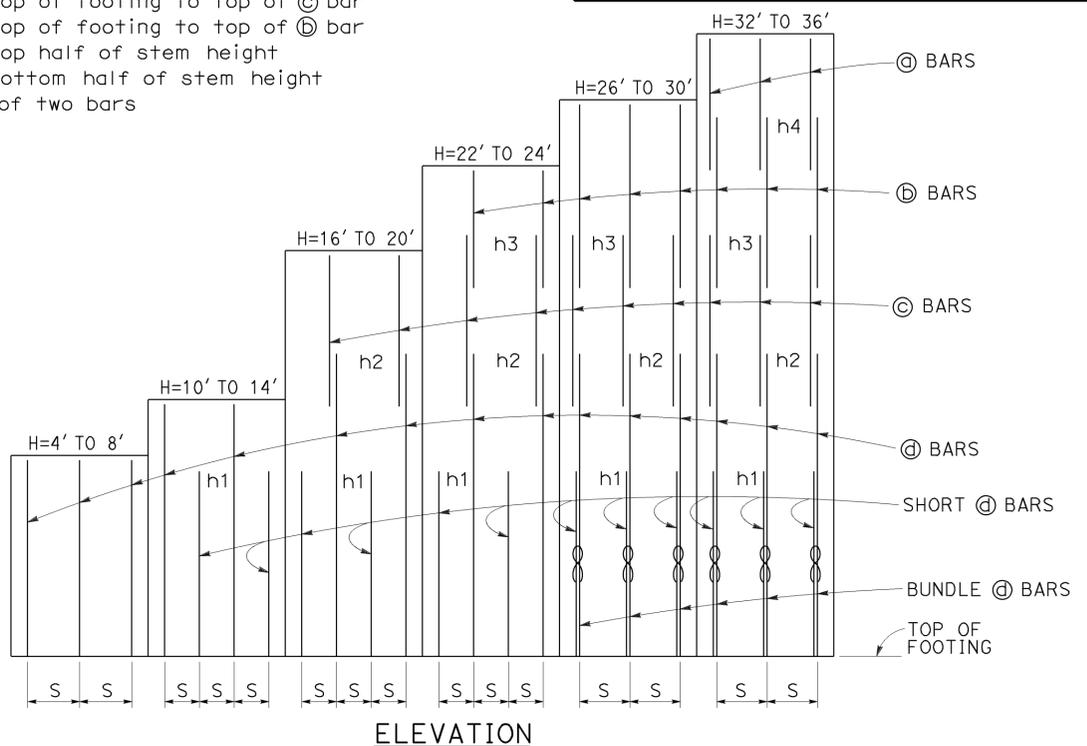
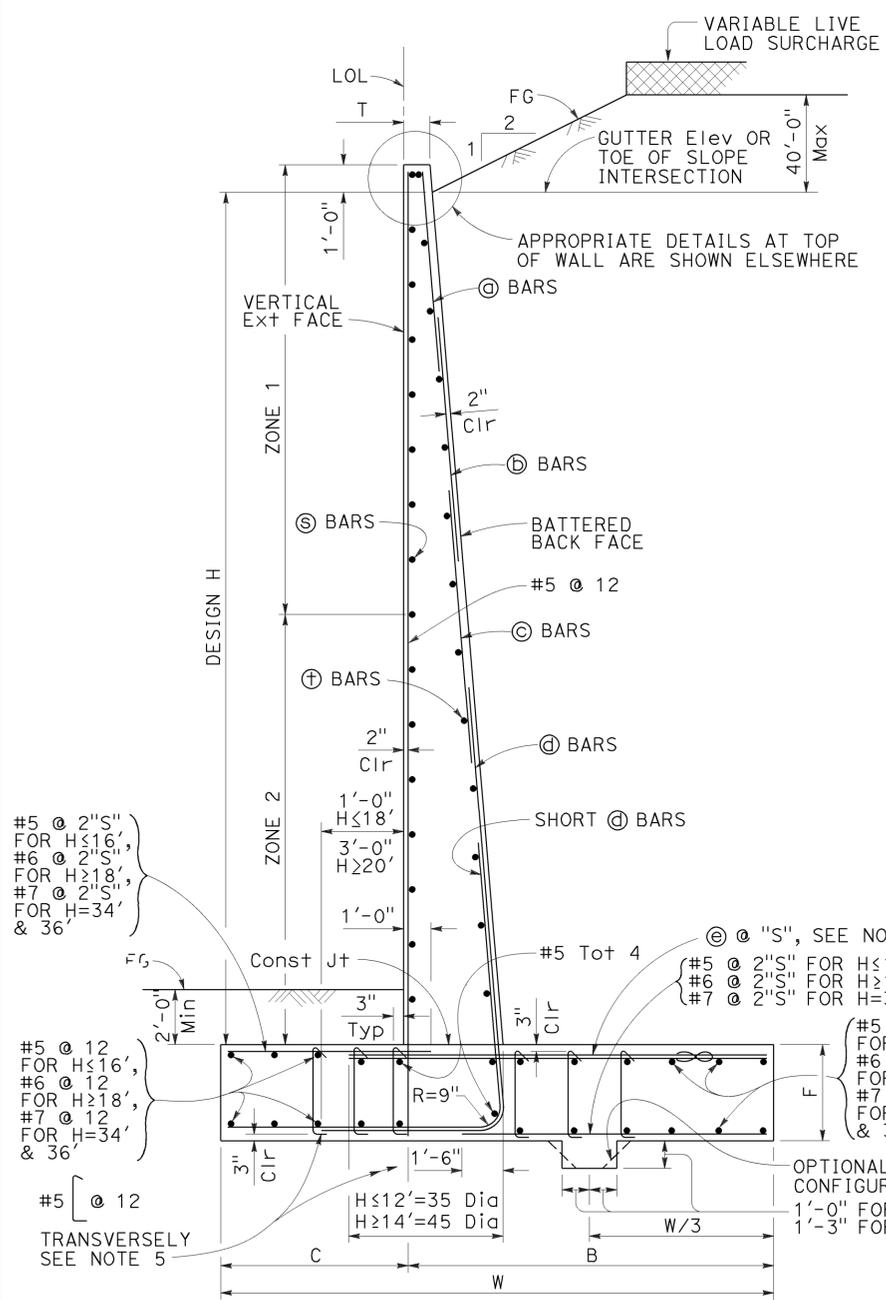


TABLE OF REINFORCING STEEL, DIMENSIONS AND DATA

DESIGN H	4'	6'	8'	10'	12'	14'	16'	18'	20'	22'	24'	26'	28'	30'	32'	34'	36'
W	6'-0"	7'-6"	9'-6"	11'-0"	12'-6"	15'-6"	17'-3"	19'-6"	21'-9"	23'-6"	26'-0"	28'-1"	30'-3"	31'-6"	33'-0"	34'-8"	35'-11"
C	2'-0"	2'-6"	3'-3"	3'-6"	4'-3"	5'-0"	5'-3"	5'-9"	6'-9"	7'-3"	8'-3"	8'-9"	9'-0"	9'-6"	10'-0"	10'-10"	11'-3"
B	4'-0"	5'-0"	6'-3"	7'-6"	8'-3"	10'-6"	12'-0"	13'-9"	15'-0"	16'-3"	17'-9"	19'-4"	21'-3"	22'-0"	23'-0"	23'-10"	24'-8"
T	1'-6"	1'-6"	2'-0"	2'-3"	2'-6"	2'-8"	2'-10"	3'-0"	3'-4"	3'-6"	3'-6"	3'-7"	3'-7"	3'-9"	3'-9"	4'-0"	4'-4"
F	11 1/2"	11 1/2"	11 1/2"	11 1/2"	11 1/2"	11 1/2"	11 1/2"	11 1/2"	11 1/2"	11 1/2"	11 1/2"	11 1/2"	1'-2"	1'-2"	1'-10"	2'-3"	2'-9"
BATTER	1/2: 12	1/2: 12	1/2: 12	1/2: 12	1/2: 12	5/8: 12	5/8: 12	3/4: 12	7/8: 12	1: 12	1 1/8: 12	1 1/8: 12	1 1/8: 12	1 1/8: 12	1 1/8: 12	1 1/8: 12	1 1/8: 12
SPACING "S"	16"	12"	10"	7"	7"	7"	7"	7"	7"	6"	6"	10"	8"	7"	7"	7"	7"
@ BARS	-	-	-	-	-	-	-	-	-	-	-	-	-	-	#5	#5	#5
@ BARS	-	-	-	-	-	-	-	-	-	#5	#5	#5	#5	#5	#7	#7	#7
@ BARS	-	-	-	-	-	-	#6	#6	#6	#7	#8	#8	#8	#8	#9	#9	#9
@ BARS	#5	#5	#6	#6	#7	#8	#9	#10	#10	#10	#11	#11	#11	#11	#11	#11	#11
@ BARS	#5	#5	#6	#6	#7	#8	#9	#10	#10	#10	#11	#11	#11	#11	#11	#11	#11
h1	-	-	-	5'-3"	6'-4"	7'-6"	8'-9"	9'-9"	11'-0"	11'-3"	11'-6"	10'-3"	11'-9"	12'-3"	12'-6"	13'-3"	13'-8"
h2	-	-	-	-	-	-	12'-8"	15'-6"	17'-0"	16'-6"	17'-3"	18'-0"	17'-6"	17'-4"	14'-10"	15'-9"	16'-4"
h3	-	-	-	-	-	-	-	-	-	18'-9"	21'-3"	21'-3"	22'-4"	22'-8"	18'-0"	18'-6"	19'-6"
h4	-	-	-	-	-	-	-	-	-	-	-	-	-	-	26'-3"	27'-4"	28'-6"
No. of Toe Stirrups	0	0	0	0	0	0	0	0	0	0	0	5	5	6	7	8	9
No. of Heel Stirrups	0	0	0	0	0	0	0	0	4	6	7	8	10	10	11	11	11
ZONE 1 @ BARS	#5 @ 18	#5 @ 18	#5 @ 18	#5 @ 18	#5 @ 18	#5 @ 18	#5 @ 18	#5 @ 18	#5 @ 12	#5 @ 12	#5 @ 12	#5 @ 12	#5 @ 12	#7 @ 12	#7 @ 12	#7 @ 10	#7 @ 10
ZONE 2 @ BARS	#5 @ 18	#5 @ 18	#5 @ 18	#5 @ 18	#5 @ 18	#5 @ 12	#5 @ 12	#5 @ 12	#5 @ 12	#5 @ 12	#6 @ 12	#6 @ 12	#7 @ 12	#7 @ 12	#7 @ 12	#7 @ 10	#7 @ 10
ZONE 1 @ BARS	#4 @ 18	#4 @ 18	#4 @ 18	#4 @ 18	#4 @ 18	#4 @ 18	#4 @ 18	#4 @ 18	#4 @ 18	#4 @ 18	#4 @ 18	#4 @ 12	#4 @ 12	#4 @ 12	#5 @ 12	#5 @ 12	#5 @ 12
ZONE 2 @ BARS	#4 @ 18	#4 @ 18	#4 @ 18	#4 @ 18	#4 @ 18	#4 @ 12	#4 @ 12	#4 @ 12	#4 @ 12	#4 @ 12	#4 @ 12	#5 @ 12	#5 @ 12	#5 @ 12	#6 @ 12	#6 @ 12	#6 @ 12
Ser: B', q ₀	4.0, 0.9	5.5, 1.0	9.3, 1.0	10.9, 1.3	12.3, 1.5	14.8, 1.9	16.6, 2.1	18.7, 2.4	20.6, 2.7	22.3, 3.0	24.2, 3.3	26.1, 3.5	28.2, 3.9	29.6, 4.0	31.1, 4.2	32.7, 4.4	34.1, 4.6
Str: B', q ₀	2.2, 2.2	3.5, 2.2	5.1, 2.3	6.3, 2.6	7.6, 2.7	12.9, 3.1	14.3, 3.6	16.5, 3.9	19.4, 4.5	20.7, 4.8	22.5, 5.2	24.3, 5.6	26.2, 6.0	27.5, 6.3	28.8, 6.6	30.3, 6.9	31.8, 7.2
Ext: B', q ₀	2.3, 3.4	2.7, 4.4	3.6, 5.0	3.8, 6.5	4.5, 7.0	7.0, 6.1	7.6, 6.9	9.3, 7.0	11.0, 7.1	11.8, 7.6	14.1, 7.4	15.6, 7.7	17.1, 8.0	17.2, 8.7	18.1, 9.0	19.0, 9.4	19.4, 10.0

NOTES:

- For details not shown and drainage notes see RSP B3-5
- For wall stem joint details see B0-3 3-3 and B0-3 3-4
- At @ and short @ bars:
 $H < 6'$, no splices are allowed within 1'-8" above the top of footing.
 $H > 6'$, no splices are allowed within H/4 above the top of footing.
- Bundle @ bars for $H \geq 26'$.
- Hook stirrups around & space with alternating transverse reinforcement at 2 x "S".

RETAINING WALL TYPE 1 (CASE 2)

NO SCALE

RSP B3-1B DATED APRIL 20, 2012 SUPPLEMENTS THE STANDARD PLANS BOOK DATED 2010.

REVISED STANDARD PLAN RSP B3-1B

DESIGN CONDITIONS:

Design H may be exceeded by 6" before going to the next size. Special footing design is required where foundation material is incapable of supporting bearing stress listed in the table.

DESIGN NOTES:


- DESIGN: AASHTO LRFD Bridge Design Specifications, 4th Edition with California Amendments
- LS: Varied surcharge on level ground surface
- DC: Stem Architectural Treatment of thickness up to 6" of concrete (75 psf) considered
- SEISMIC: $k_h = 0.2$
 $k_v = 0.0$
- SOIL: $\phi = 34^\circ$
 $\gamma = 120$ pcf
- REINFORCED CONCRETE: $f'_c = 3,600$ psi
 $f_y = 60,000$ psi
- LOAD COMBINATIONS AND LIMIT STATES:
 Service I $Q = 1.00DC + 1.00EV + 1.00EH + 1.00LS$
 Strength I $Q = 1.25DC + 1.00EV + 1.00EH + 1.75LS$
 Extreme I $Q = 1.00DC + 1.00EV + 1.00EH + 1.00EQD + 1.00EQE$

- Where:
- Q: Force Effects
 a: 1.25 or 0.90, Whichever Controls Design
 ϕ : 1.35 or 1.00, Whichever Controls Design
 η : 1.50 or 0.90, Whichever Controls Design
 DC: Dead Load of Structure Components
 EH: Horizontal Earth Fill Pressure
 EV: Vertical Earth Pressure from Earth Fill Weight
 LS: Live Load Surcharge
 EQE: Seismic Earth Pressure
 EQD: Soil and Structural and Nonstructural Components Inertia

TO ACCOMPANY PLANS DATED 12-7-15

SYMBOLS:


- Ser - service limit state I
 Str - strength limit state I
 Ext - extreme event limit state I
 B' - effective footing width (ft)
 q_0 - net bearing stress (ksf), OG assumed to be FG at toe
 q_0 - gross uniform bearing stress (ksf)
 h1 = Top of footing to top of short \odot bar
 h2 = Top of footing to top of \oplus bar
 h3 = Top of footing to top of \ominus bar
 Zone 1 = Top half of stem height
 Zone 2 = Bottom half of stem height
 ∞ - Bundle of two bars

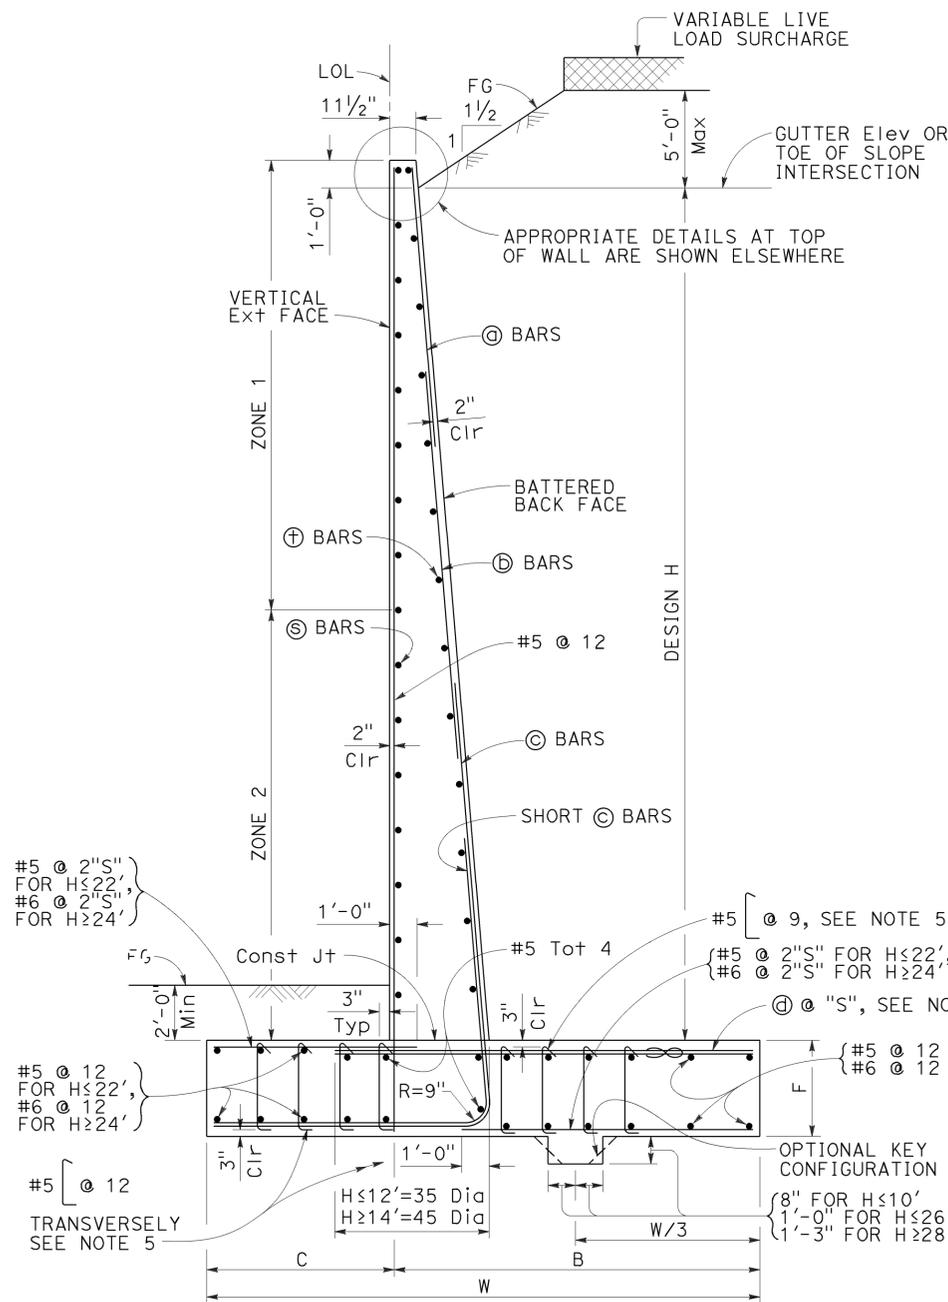

TYPICAL SECTION

NOTES:

- For details not shown and drainage notes see RSP B3-5
- For wall stem joint details see B0-3 3-3 and B0-3 3-4
- At \odot bars:
 $H \leq 6'$, no splices are allowed within 1'-8" above the top of footing.
 $H > 6'$, no splices are allowed within H/4 above the top of footing.
- Bundle \odot bars for $H = 36'$.
- Hook stirrups around & space with alternating transverse reinforcement at $2 \times "S"$.

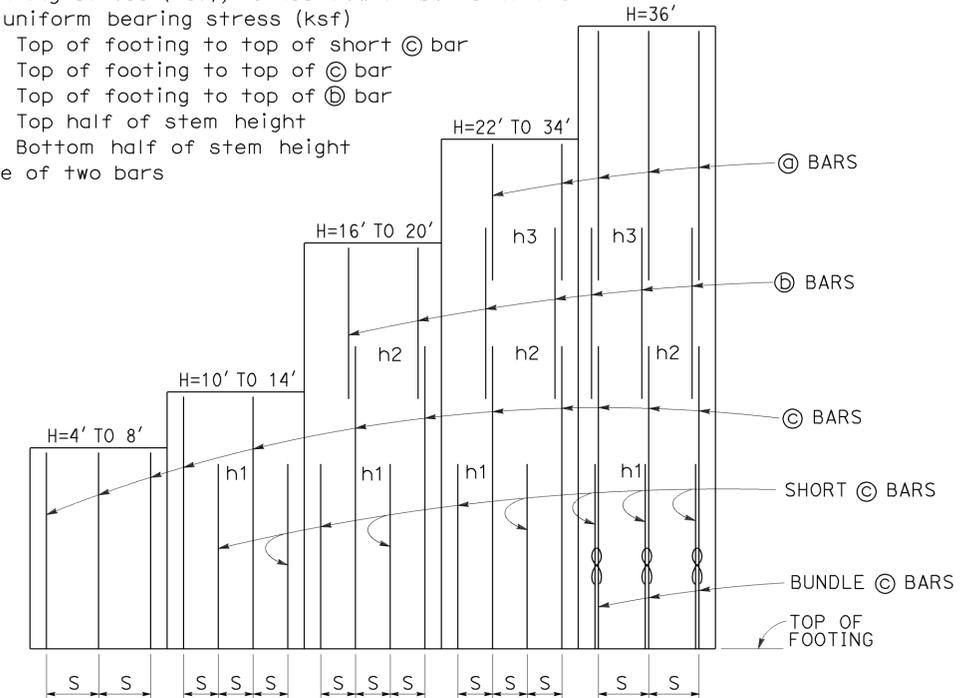

ELEVATION

TABLE OF REINFORCING STEEL, DIMENSIONS AND DATA

DESIGN H	4'	6'	8'	10'	12'	14'	16'	18'	20'	22'	24'	26'	28'	30'	32'	34'	36'
W	6'-5"	7'-3"	8'-3"	9'-3"	10'-8"	12'-6"	13'-9"	15'-1"	16'-6"	17'-10"	19'-3"	20'-4"	21'-5"	22'-8"	23'-11"	25'-1"	26'-4"
C	2'-2"	2'-6"	3'-0"	3'-6"	3'-8"	3'-11"	4'-0"	4'-7"	5'-3"	6'-0"	7'-0"	7'-9"	8'-3"	8'-8"	9'-0"	9'-6"	9'-10"
B	4'-3"	4'-9"	5'-3"	5'-9"	7'-0"	8'-7"	9'-9"	10'-6"	11'-3"	11'-10"	12'-3"	12'-7"	13'-2"	14'-0"	14'-11"	15'-7"	16'-6"
F	1'-4"	1'-4"	1'-4"	1'-6"	1'-6"	1'-6"	1'-8"	2'-0"	2'-4"	2'-9"	3'-2"	3'-0"	3'-0"	3'-3"	3'-3"	3'-3"	3'-3"
BATTER	1/2: 12	1/2: 12	1/2: 12	1/2: 12	1/2: 12	1/2: 12	1/2: 12	1/2: 12	1/2: 12	1/2: 12	5/8: 12	3/4: 12	1: 12	1: 12	1 1/8: 12	1 1/8: 12	1 1/8: 12
SPACING "S"	16"	16"	16"	8"	8"	7"	7"	7"	6"	6"	7"	7"	7"	6"	6"	6"	8"
\oplus BARS	-	-	-	-	-	-	-	-	-	#5	#5	#5	#5	#5	#5	#6	#6
\ominus BARS	-	-	-	-	-	-	#5	#5	#5	#7	#7	#7	#8	#8	#8	#9	#9
\odot BARS	#5	#5	#6	#5	#6	#6	#7	#8	#8	#9	#10	#10	#10	#10	#10	#11	#11
\oplus BARS	#5	#5	#6	#5	#6	#8	#9	#9	#9	#10	#11	#9	#9	#9	#10	#10	#9
h1	-	-	-	4'-2"	4'-7"	6'-2"	7'-3"	8'-6"	8'-8"	9'-8"	11'-0"	12'-2"	14'-0"	13'-0"	15'-10"	14'-6"	12'-0"
h2	-	-	-	-	-	-	10'-6"	12'-9"	14'-2"	13'-8"	17'-0"	18'-6"	17'-10"	18'-9"	20'-3"	21'-0"	17'-0"
h3	-	-	-	-	-	-	-	-	-	15'-6"	17'-9"	19'-6"	21'-8"	23'-0"	24'-8"	25'-6"	24'-8"
No. of Toe Stirrups	0	0	0	0	0	0	0	0	0	0	0	6	6	7	7	7	8
No. of Heel Stirrups	0	0	0	0	0	0	0	0	0	0	0	6	6	6	6	6	6
ZONE 1 \oplus BARS	#5 @ 18	#5 @ 18	#5 @ 18	#5 @ 18	#5 @ 18	#5 @ 18	#5 @ 18	#5 @ 18	#5 @ 18	#5 @ 18	#5 @ 18	#5 @ 12	#5 @ 12	#5 @ 12	#5 @ 12	#5 @ 12	#5 @ 12
ZONE 2 \oplus BARS	#5 @ 18	#5 @ 18	#5 @ 18	#5 @ 18	#5 @ 18	#5 @ 18	#5 @ 12	#5 @ 12	#5 @ 12	#5 @ 12	#5 @ 12	#6 @ 12	#6 @ 12	#6 @ 12	#7 @ 12	#7 @ 12	#7 @ 12
ZONE 1 \oplus BARS	#4 @ 18	#4 @ 18	#4 @ 18	#4 @ 18	#4 @ 18	#4 @ 18	#4 @ 18	#4 @ 18	#4 @ 18	#4 @ 18	#4 @ 18	#4 @ 18	#4 @ 12	#4 @ 12	#4 @ 12	#4 @ 12	#4 @ 12
ZONE 2 \oplus BARS	#4 @ 18	#4 @ 18	#4 @ 18	#4 @ 18	#4 @ 18	#4 @ 18	#4 @ 18	#4 @ 18	#4 @ 18	#4 @ 18	#4 @ 12	#4 @ 12	#5 @ 12	#5 @ 12	#5 @ 12	#5 @ 12	#5 @ 12
Ser: B', q_0	4.3, 0.8	4.9, 1.1	5.6, 1.3	7.1, 1.5	8.0, 1.8	9.3, 2.1	10.6, 2.3	11.9, 2.5	13.3, 2.6	14.6, 2.8	15.9, 2.9	17.0, 3.0	18.0, 3.1	19.3, 3.3	20.4, 3.5	21.5, 3.7	22.7, 3.9
Str: B', q_0	2.4, 2.2	2.4, 2.7	2.7, 3.2	3.0, 3.7	4.3, 3.8	5.9, 3.8	7.0, 4.1	7.9, 4.3	9.0, 4.5	9.9, 4.7	10.8, 4.9	11.6, 5.0	12.3, 5.2	13.3, 5.4	14.2, 5.7	15.0, 5.9	16.0, 6.1
Ext: B', q_0	4.1, 1.5	3.9, 2.1	3.8, 2.8	3.5, 3.9	3.6, 4.9	4.2, 5.5	4.6, 6.3	5.0, 7.0	5.6, 7.4	6.0, 8.0	6.5, 8.4	6.9, 8.6	7.2, 9.2	7.7, 9.6	8.1, 10.4	8.4, 10.9	8.9, 11.3

STATE OF CALIFORNIA
DEPARTMENT OF TRANSPORTATION

RETAINING WALL TYPE 1 (CASE 3)


NO SCALE

RSP B3-1C DATED APRIL 20, 2012 SUPPLEMENTS THE STANDARD PLANS BOOK DATED 2010.


REVISED STANDARD PLAN RSP B3-1C

2010 REVISED STANDARD PLAN RSP B3-1C



2010 REVISED STANDARD PLAN RSP B3-4A

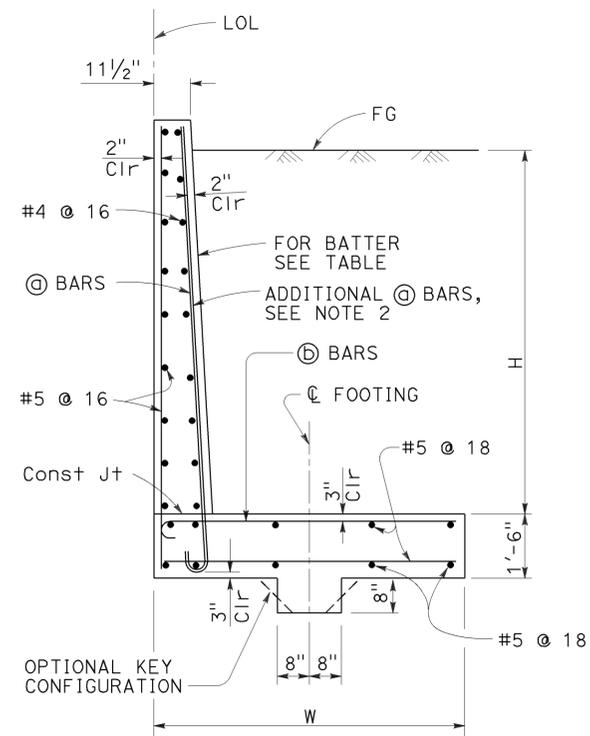


SPREAD FOOTING SECTION

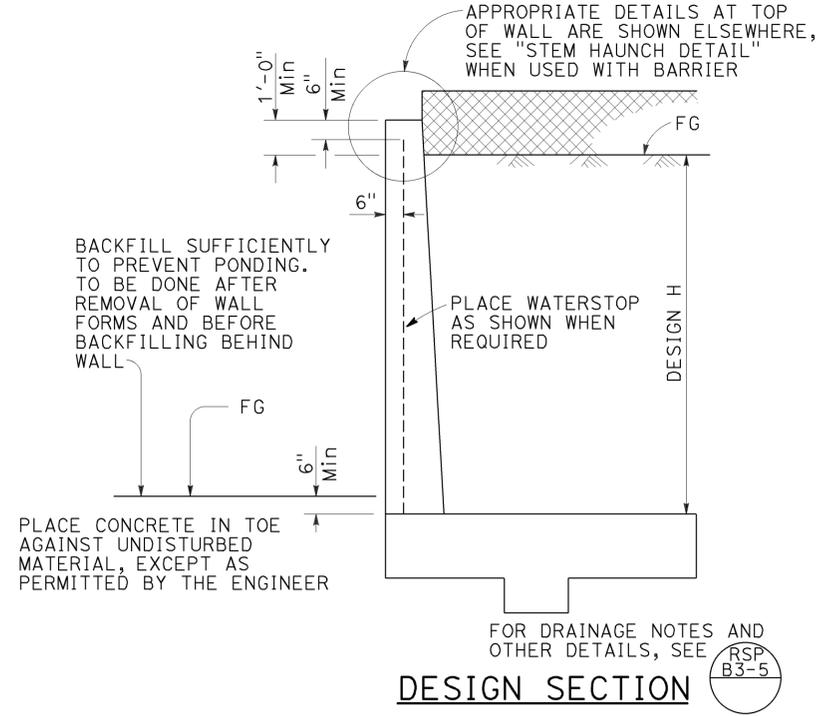

DESIGN SECTION

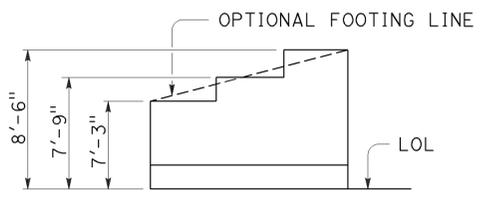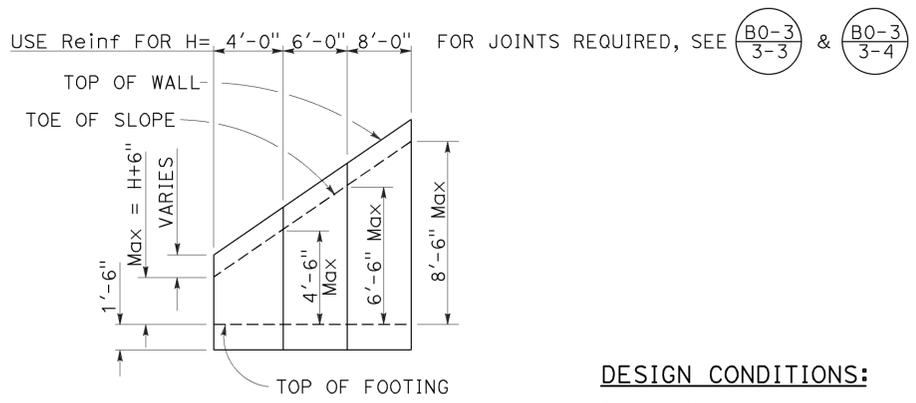

TYPICAL LAYOUT EXAMPLE

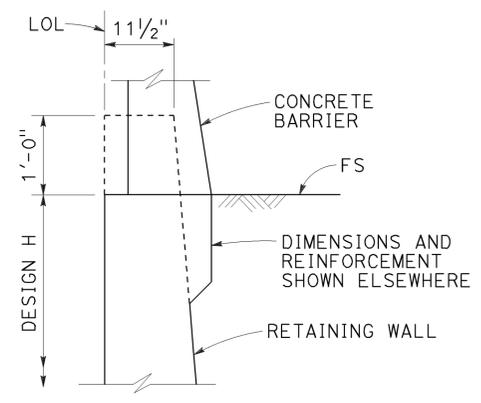

STEM HAUNCH DETAIL

DESIGN CONDITIONS:


Design H may be exceeded by 6" before going to the next size. Special footing design is required where foundation material is incapable of supporting bearing stress listed in the table.

DESIGN NOTES:

- DESIGN: AASHTO LRFD Bridge Design Specifications, 4th Edition with California Amendments
- LS: Varied surcharge on level ground surface
- DC: Stem Architectural Treatment of thickness up to 6" of concrete (75 psf) considered
- CT: 54 kip transverse force applied at $H_e = 32"$, distributed over 10 feet at the top of wall and 1 : 1 distribution down and outward. Distribution below footing taken no less than 40'.
- SEISMIC: $K_h = 0.2$
 $K_v = 0.0$
- SOIL: $\phi = 34^\circ$
 $\gamma = 120$ pcf
- REINFORCED CONCRETE: $f'_c = 3,600$ psi
 $f_y = 60,000$ psi
- LOAD COMBINATIONS AND LIMIT STATES:
 Service I $Q = 1.00DC + 1.00EV + 1.00EH + 1.00LS$
 Strength I $Q = aDC + \beta EV + \eta EH + 1.75LS$
 Extreme I $Q = 1.00DC + 1.00EV + 1.00EH + 1.00EQD + 1.00EQE$
 Extreme II $Q = 1.00DC + 1.00EV + 1.00EH + 1.00CT$
- Where:
 Q: Force Effects
 a: 1.25 or 0.90, Whichever Controls Design
 β : 1.35 or 1.00, Whichever Controls Design
 η : 1.50 or 0.90, Whichever Controls Design
 DC: Dead Load of Structure Components
 EH: Horizontal Earth Fill Pressure
 EV: Vertical Earth Pressure from Earth Fill Weight
 LS: Live Load Surcharge
 EQE: Seismic Earth Pressure
 EQD: Soil and Structural and Nonstructural Components Inertia
 CT: Vehicular Collision Force

NOTES:

- At \textcircled{A} bars:
 $H \leq 6'$, no splices are allowed within 1'-8" above the top of footing.
 $H > 6'$, no splices are allowed within $H/4$ above the top of footing.
- Provide #6 @ 8" \textcircled{A} bars in addition to tabulated \textcircled{A} bars over a distance of 8'-0" measured from all expansion joints, begin wall and end wall locations.

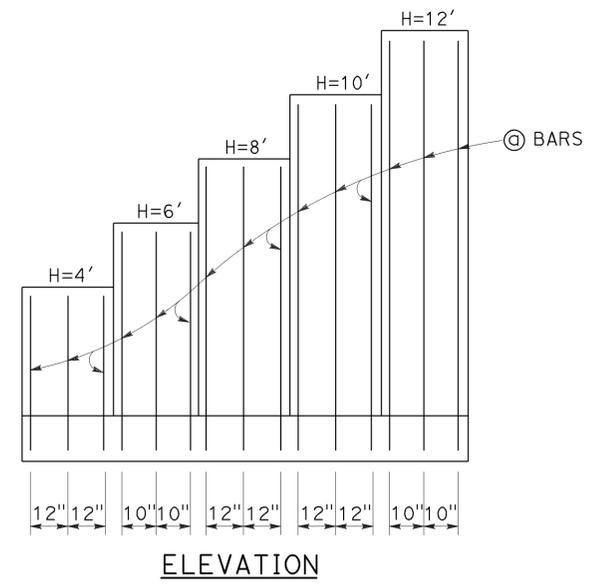

ELEVATION

SYMBOLS:

- Ser - service limit state I
 Str - strength limit state I
 Ext I - extreme event limit state I
 Ext II - extreme event limit state II
 B' - effective footing width (ft)
 q_0 - net bearing stress (ksf), OG assumed to be FG at toe
 q_0 - gross uniform bearing stress (ksf)

DESIGN H	4'	6'	8'	10'	12'
W	7'-3"	7'-9"	8'-6"	9'-6"	10'-6"
BATTER	NONE	NONE	100 : 2	100 : 3	100 : 4
\textcircled{A} BARS	#7 @ 12	#7 @ 10	#7 @ 12	#7 @ 12	#7 @ 10
\textcircled{B} BARS	#7 @ 12	#7 @ 10	#8 @ 12	#9 @ 12	#10 @ 10
Ser: B' , q_0	6.2, 1.4	6.1, 1.8	6.4, 2.1	7.0, 2.5	7.7, 2.8
Str: B' , q_0	6.2, 2.4	6.1, 2.9	5.3, 3.0	6.0, 3.5	6.6, 4.0
Ext I: B' , q_0	4.4, 1.5	4.1, 2.2	4.0, 3.1	4.1, 3.9	4.2, 4.8
Ext II: B' , q_0	2.5, 2.7	3.1, 3.0	3.8, 3.2	4.9, 3.3	5.8, 3.5

STATE OF CALIFORNIA
 DEPARTMENT OF TRANSPORTATION
RETAINING WALL TYPE 5 (CASE 1)
 NO SCALE

RSP B3-4A DATED APRIL 20, 2012 SUPPLEMENTS THE STANDARD PLANS BOOK DATED 2010.

TO ACCOMPANY PLANS DATED 12-7-15

2010 REVISED STANDARD PLAN RSP B3-5


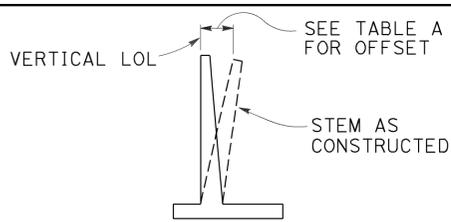


TABLE A

H	OFFSET
4'-12'	H/200
14'-16'	H/160
18'-20'	H/140
22'-24'	H/130
26'-36'	2 1/2"


APPROXIMATE WALL OFFSET VALUES

Values for offsetting forms to be determined by the Engineer.

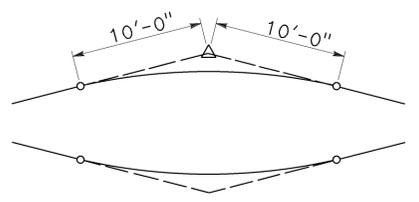

20'-0" VC AT TOP OF WALL SLOPE CHANGE

Where shown on the plans

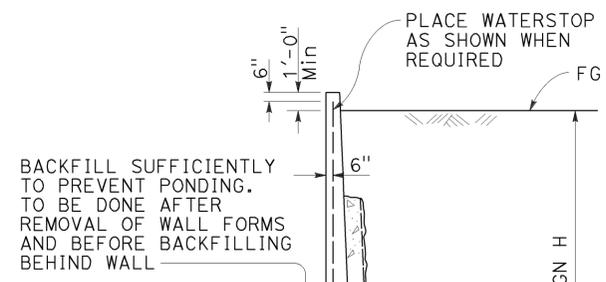

BACKFILL SUFFICIENTLY TO PREVENT PONDING. TO BE DONE AFTER REMOVAL OF WALL FORMS AND BEFORE BACKFILLING BEHIND WALL.


PLACE CONCRETE IN TOE AGAINST UNDISTURBED MATERIAL EXCEPT AS PERMITTED BY THE ENGINEER.

PLACE WATERSTOP AS SHOWN WHEN REQUIRED


DESIGN H

3" Ø HOLES AT 14'-9" CENTERS


DESIGN AND DRAINAGE

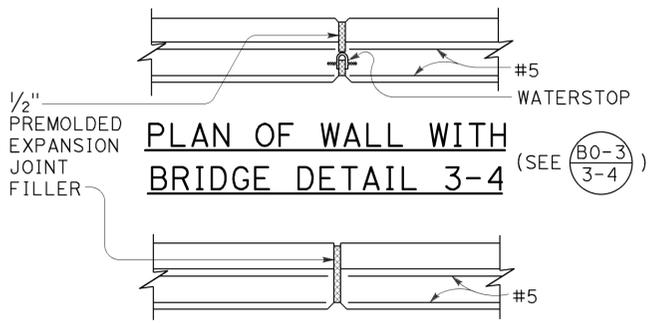


PLAN OF WALL WITH BRIDGE DETAIL 3-4

 

PLAN OF WALL WITH EXPANSION JOINT ONLY

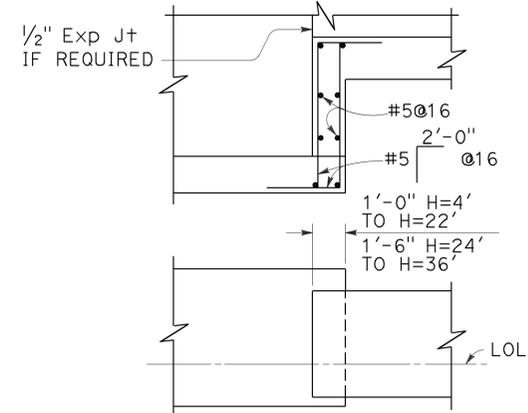


FOOTING STEP

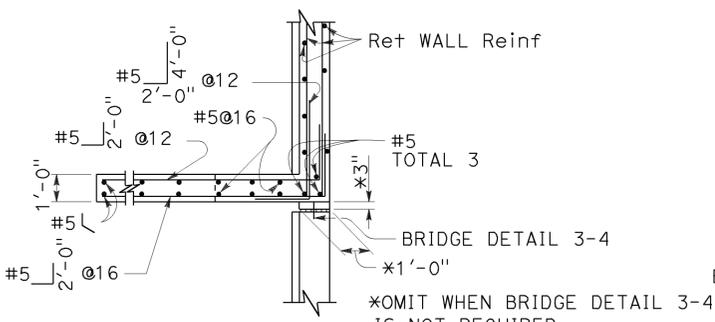


PLAN

(For return wall Type "A")

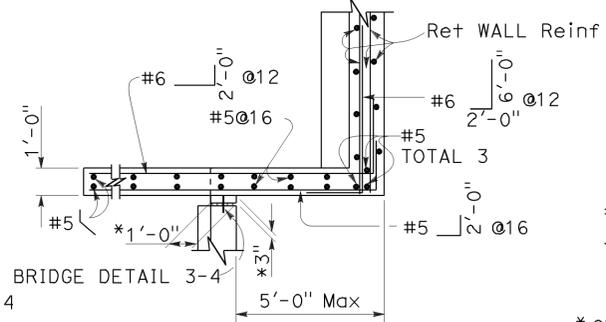


PLAN

(For return wall Type "B")

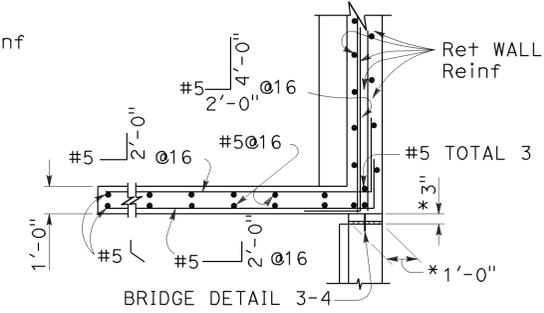


PLAN

(For return wall Type "C")

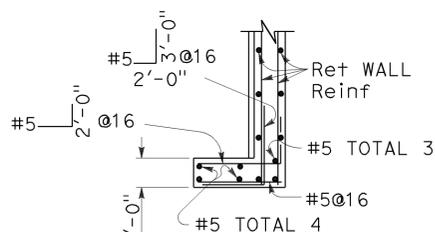

PLAN


(For return wall Type "D")

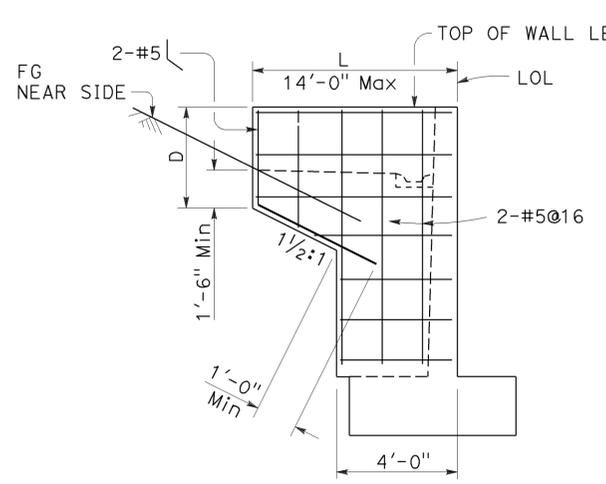

ELEVATION

RETURN WALL TYPE "A"


Use where H=8' or less

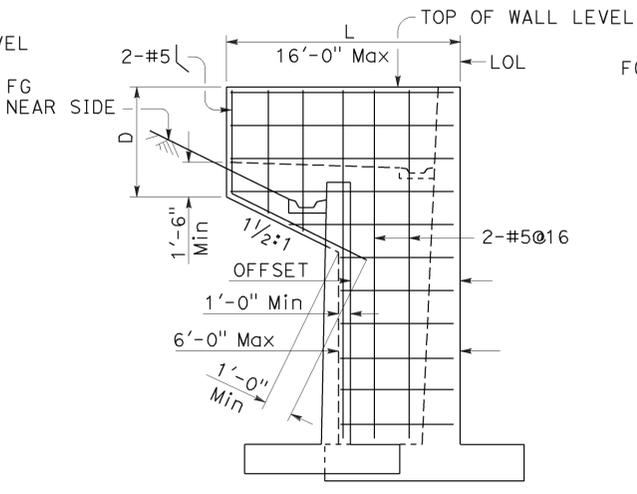

ELEVATION

RETURN WALL TYPE "B"


Use where H=10' or more on offset walls

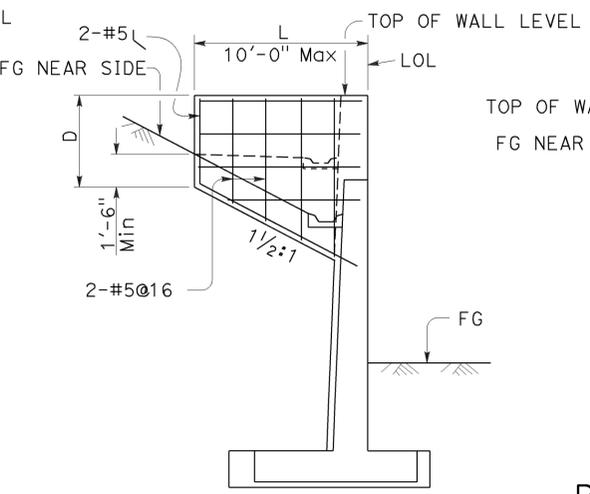

ELEVATION

RETURN WALL TYPE "C"

Use where H=10' or more on straight walls

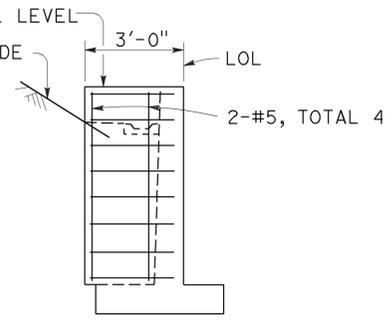

ELEVATION

RETURN WALL TYPE "D"

Use where H=6' or less

DESIGN CONDITIONS:

Design "H" may be exceeded by 6" before going to the next size. Special footing design is required where foundation material is incapable of supporting bearing stress listed in table

Return wall not required unless shown elsewhere

DESIGN NOTES:

DESIGN: AASHTO LRFD Bridge Design Specifications, 4th edition with California Amendments

LIVE LOAD: Surcharge on level ground surface

SOIL: $\phi = 34^\circ$
 $\gamma = 120$ pcf

REINFORCED CONCRETE: $f_y = 60,000$ psi
 $f_c' = 3,600$ psi

STATE OF CALIFORNIA
DEPARTMENT OF TRANSPORTATION

RETAINING WALL DETAILS No. 1


NO SCALE

RSP B3-5 DATED APRIL 20, 2012 SUPERSEDES STANDARD PLAN B3-5 DATED MAY 20, 2011 - PAGE 277 OF THE STANDARD PLANS BOOK DATED 2010.

REVISED STANDARD PLAN RSP B3-5


TO ACCOMPANY PLANS DATED 12-7-15

NOTE:
 The Contractor shall verify all controlling field dimensions before ordering or fabricating any material.

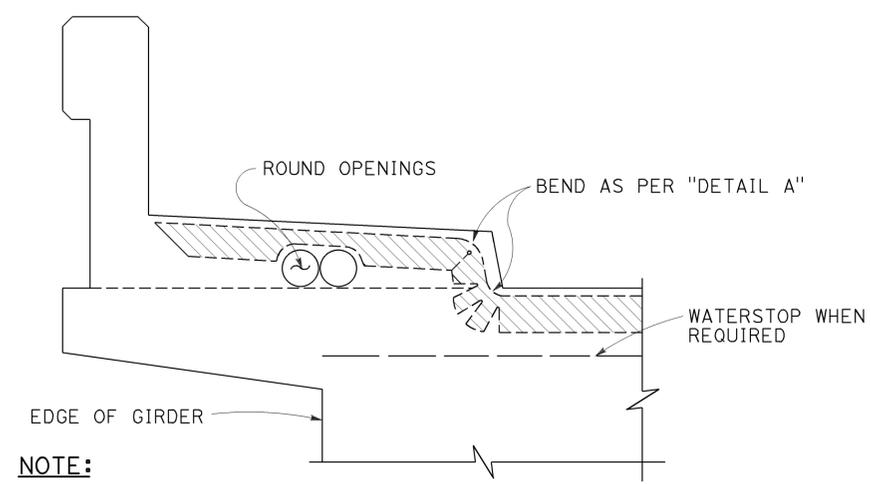


NOTE:
 Type "B" seal shown. Type "A" seals to conform to the general path of seal shown, cuts for bending not required. Bend type "A" seals 3" up into curb or barrier rail on only the low end of the seal.

CONCRETE BARRIER AND SIDEWALK

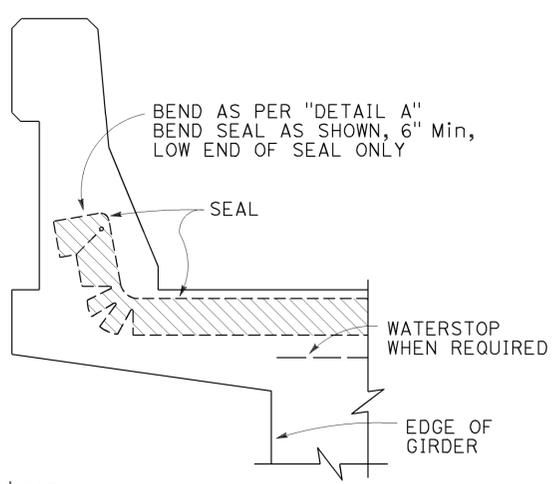


CONCRETE BARRIER

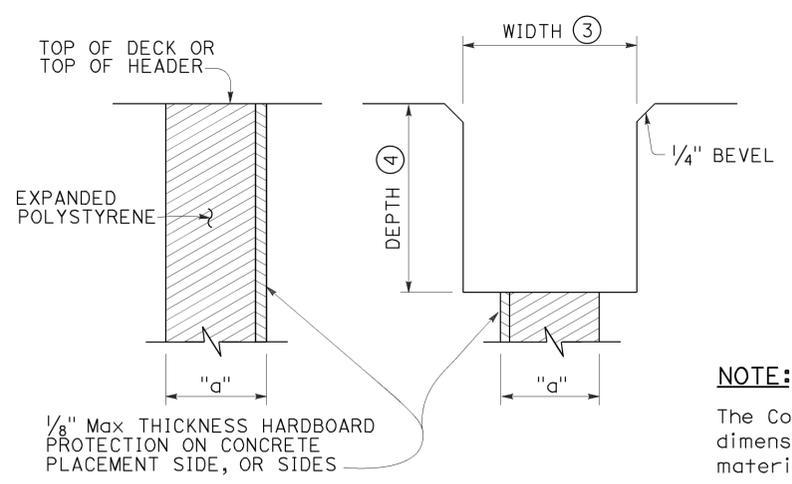


FORMING DETAIL SAWCUT DETAIL

JOINT SEALS DETAILS

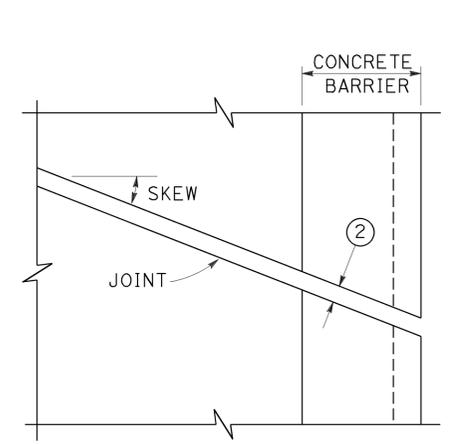


PLAN OF JOINT (SKEW ≤ 20°)

Min ϕ RADIUS TO BE 4 TIMES UNCOMPRESSED WIDTH OF SEAL OR AS RECOMMENDED BY THE MANUFACTURER, WHICHEVER IS GREATER

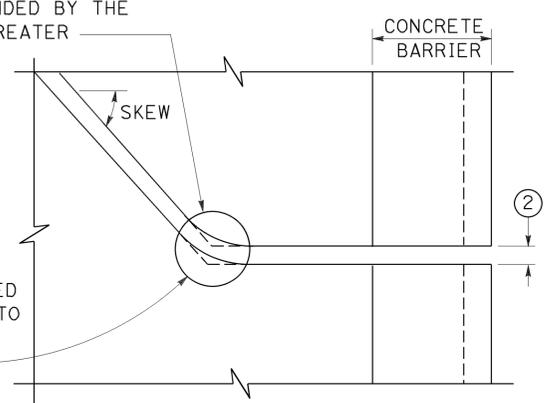

PLAN OF JOINT (SKEW > 20°)

IN LIEU OF SAW CUTTING, THIS AREA MAY BE BLOCKED OUT AND RECONSTRUCTED TO MATCH SAW CUTTING ON BOTH SIDES.

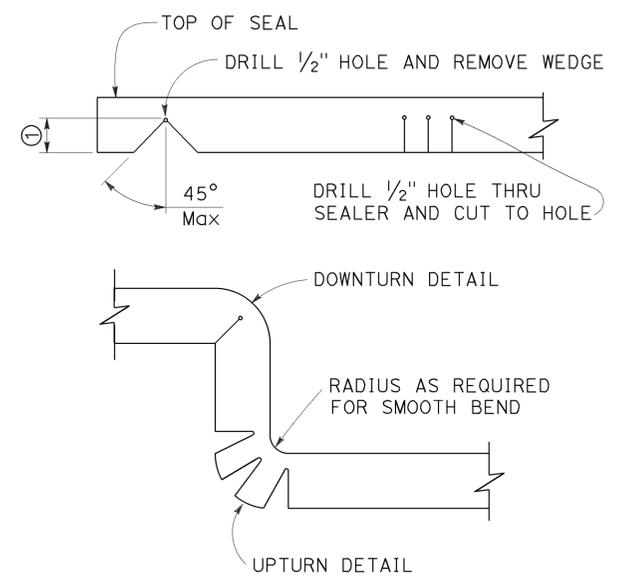


DETAIL A

- NOTES:**
- Make smooth cuts from the bottom of seal to 1/2" clear of top leaving at least one complete cell between the top of the cut and top of the seal. When necessary cut back of seal to clear conduit and round openings.
 - Opening in barrier to match width of sawn deck joint.
 - Sawcut groove widths shall be as ordered by the Engineer.
 - Depth of sawcut: Type A - Depth to be 2" minimum.
Type B - Depth to be equal to or greater than the depth of seal measured along the contact surface, when compressed to minimum width position (W₂) plus dimensions shown.
 - MR (movement rating) as shown on other plan sheets.
 - Other depths must be approved by the Engineer.
 - A sidewalk joint shall be covered by an expansion joint armor.

DIMENSIONS "a" OF JOINT REQUIRED

MOVEMENT RATING (MR) (5)	BRIDGE TYPE	"a" DIMENSION		
		DECK CONCRETE PLACED		
		WINTER	FALL-SPRING	SUMMER
2"	ALL EXCEPT CIP/PS	1 1/2"	1 1/4"	3/4"
	CIP/PS	1 1/4"	1"	1/2"
1 1/2"	ALL EXCEPT CIP/PS	1 1/4"	1"	1/2"
	CIP/PS	1"	3/4"	1/2"
1"	ALL EXCEPT CIP/PS	1"	3/4"	1/2"
	CIP/PS	3/4"	1/2"	1/2"
1/2"	ALL EXCEPT CIP/PS	3/4"	3/4"	1/2"
	CIP/PS	1/2"	1/2"	1/2"

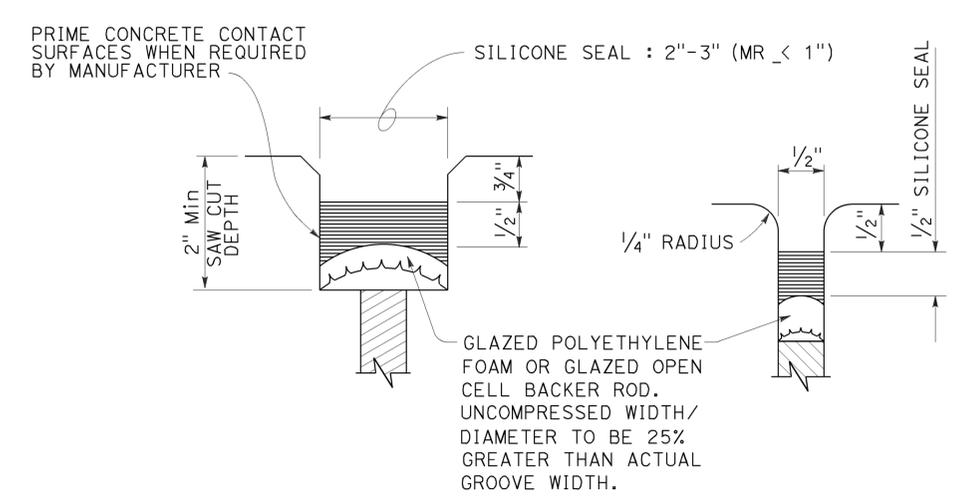


TYPE A SEAL


Movement rating : Silicone = 1" Max

TYPE AL SEAL

Longitudinal joints only

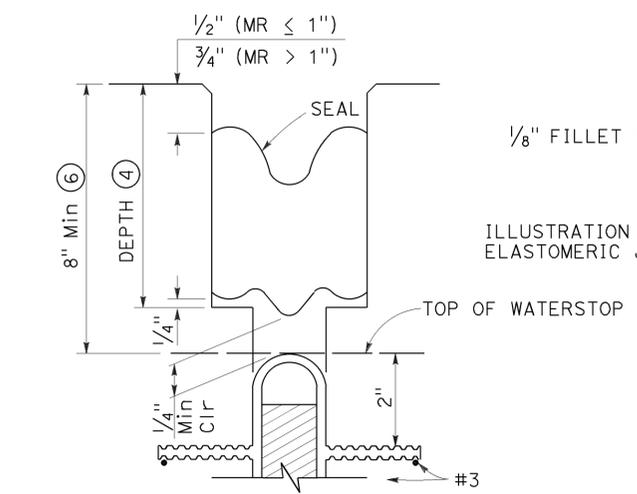

TYPE B JOINT SEAL IN MINIMUM WIDTH POSITION (W₂)

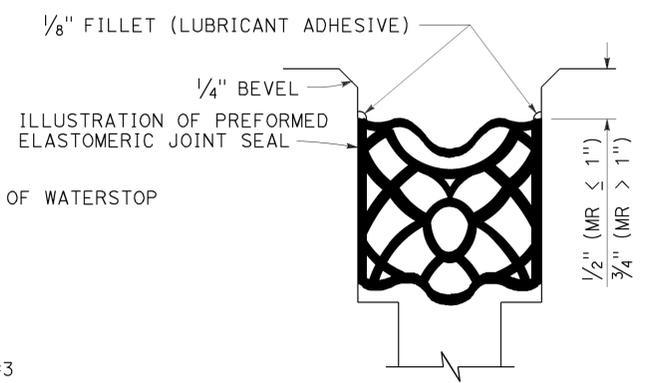

TYPE B SEAL


Movement Rating ≤ 2"

STATE OF CALIFORNIA
 DEPARTMENT OF TRANSPORTATION
JOINT SEALS
(MAXIMUM MOVEMENT RATING = 2")


NO SCALE
 RSP B6-21 DATED OCTOBER 30, 2015 SUPERSEDES STANDARD PLAN B6-21 DATED MAY 20, 2011 - PAGE 283 OF THE STANDARD PLANS BOOK DATED 2010.

Dist	COUNTY	ROUTE	POST MILES TOTAL PROJECT	SHEET No.	TOTAL SHEETS
05	SB	101	2.2/3.3	489	786

REGISTERED CIVIL ENGINEER July 19, 2013 PLANS APPROVAL DATE	
<small>THE STATE OF CALIFORNIA OR ITS OFFICERS OR AGENTS SHALL NOT BE RESPONSIBLE FOR THE ACCURACY OR COMPLETENESS OF SCANNED COPIES OF THIS PLAN SHEET.</small>	

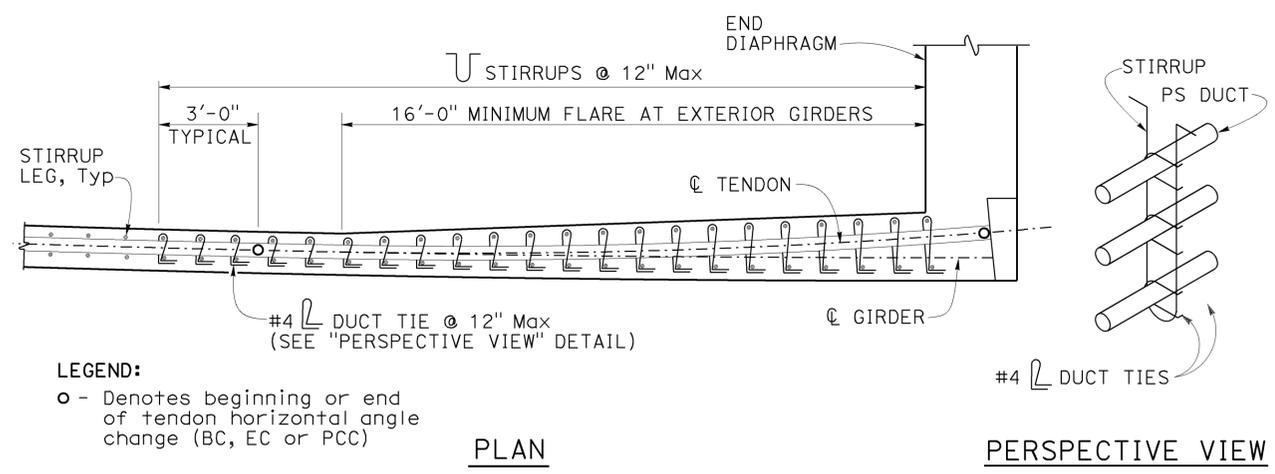


DUCT TIES AT TENDON HORIZONTAL ANGLE CHANGES
DETAIL 5-1

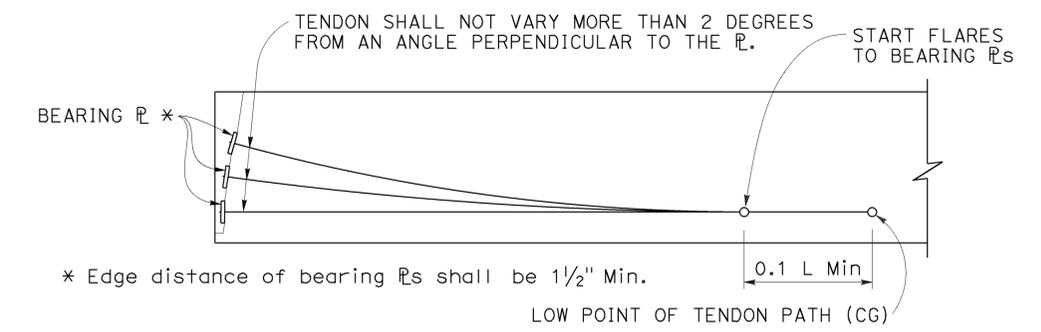


ELEVATION - BEARING PLATE AND PRESTRESSING PATH
DETAIL 5-2

LEGEND:
○ - Denotes beginning or end of tendon horizontal angle change (BC, EC or PCC)

- TO ACCOMPANY PLANS DATED 12-7-15
- NOTES FOR DETAIL 5-1**
1. Tendon horizontal angle change at end diaphragm shown. Duct tie placement similar for other locations where tendon horizontal angle changes occur. For curved girders place duct ties at tendon angle changes where tendon radius is smaller than girder radius.
 2. Adjacent duct ties may be staggered to facilitate placement if stirrup spacing is less than 12 inches.
 3. Place closed end of duct ties toward inside of tendon curve.
 4. Wrap duct ties around both stirrup legs.
 5. Individual duct ties may only be used to anchor one duct.

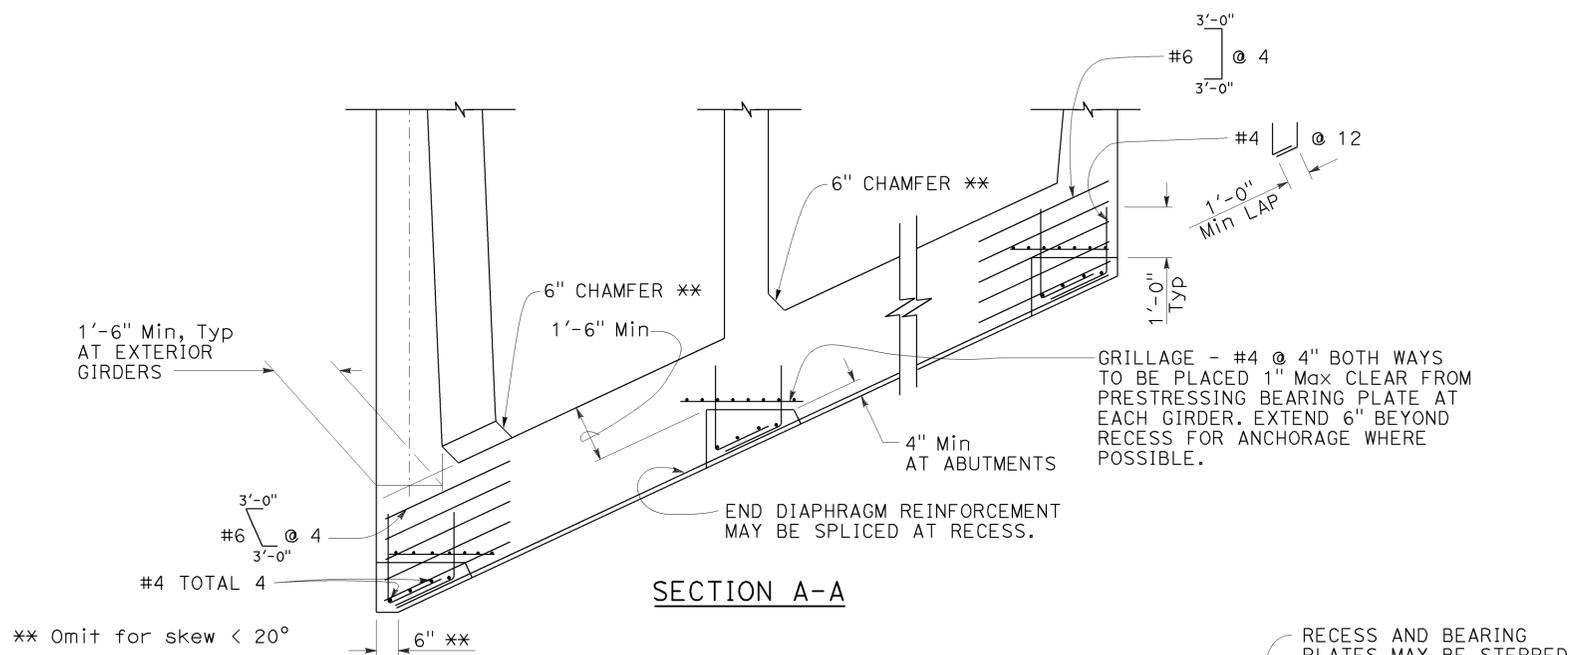


SECTION A-A

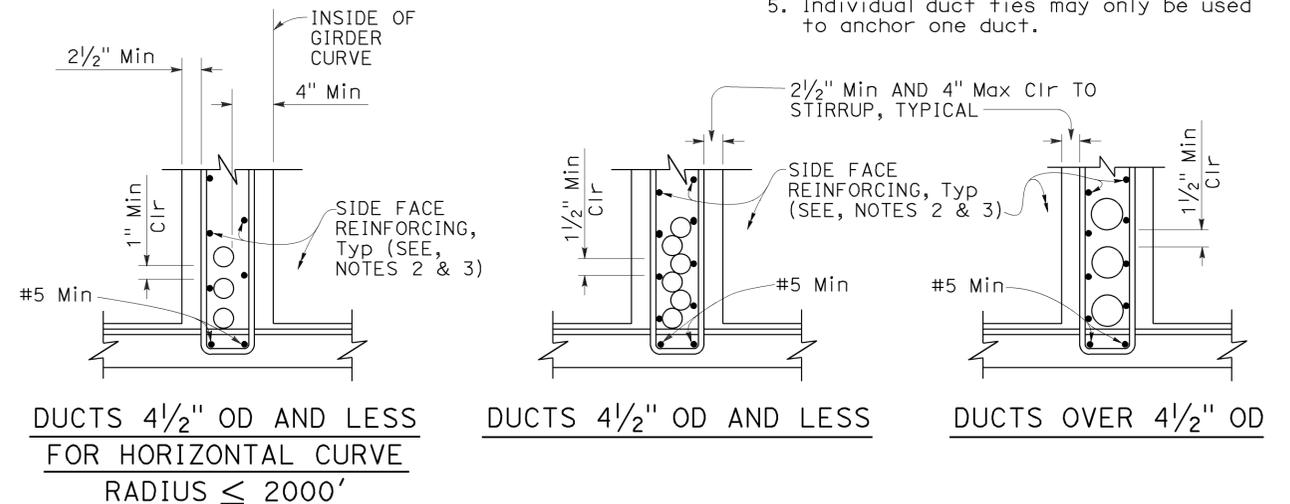

CLEARANCE REQUIREMENTS FOR DUCTS
DETAIL 5-4

- NOTES FOR DETAIL 5-4:**
1. Stirrups may also be used.
 2. For additional details, see Standard Plan B7-1, and Project Plans.
 3. Bar reinforcing which interferes with prestressing ducts may be adjusted as approved by the Engineer.

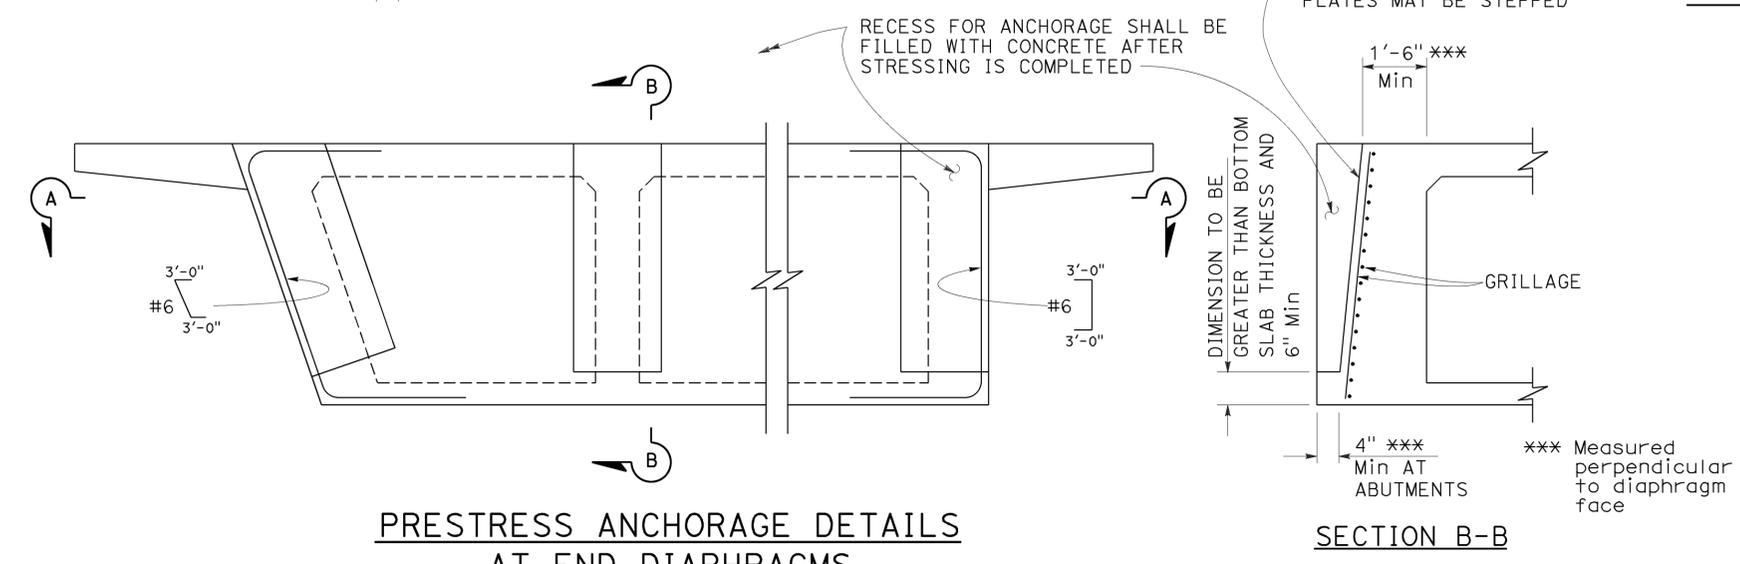

PRESTRESS ANCHORAGE DETAILS
AT END DIAPHRAGMS
DETAIL 5-3


SECTION B-B

STATE OF CALIFORNIA
DEPARTMENT OF TRANSPORTATION
CAST-IN-PLACE POST-TENSIONED GIRDER DETAILS
NO SCALE

2010 REVISED STANDARD PLAN RSP B8-5

Dist	COUNTY	ROUTE	POST MILES TOTAL PROJECT	SHEET No.	TOTAL SHEETS
05	SB	101	2.2/3.3	490	786

REGISTERED CIVIL ENGINEER	
October 21, 2011	
PLANS APPROVAL DATE	
THE STATE OF CALIFORNIA OR ITS OFFICERS OR AGENTS SHALL NOT BE RESPONSIBLE FOR THE ACCURACY OR COMPLETENESS OF SCANNED COPIES OF THIS PLAN SHEET.	

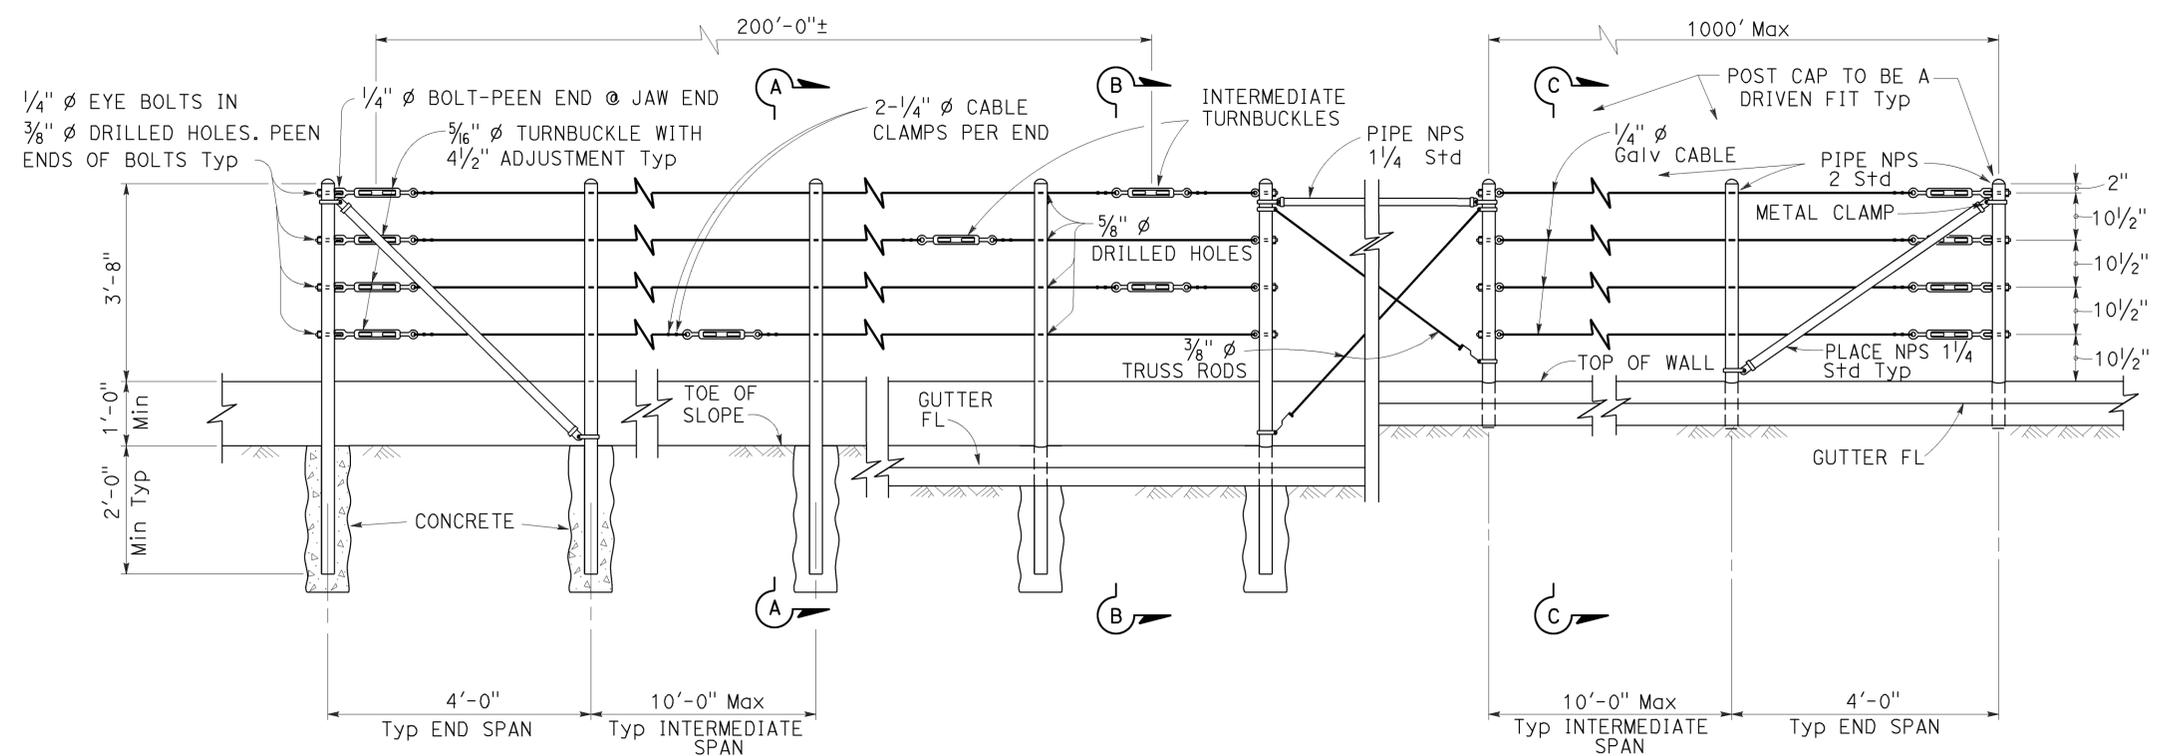


EXISTING WALL (WITHOUT GUTTER) Existing RETAINING WALL (WITH GUTTER) Existing RETAINING WALL (WITH GUTTER) New construction


ELEVATION

NOTES:


1. Maximum distance between turnbuckles shall be 200'-0"±.
2. Intermediate turnbuckles to be placed in adjacent spans.
3. Cable shall not be spliced between intermediate turnbuckles and end posts.
4. Posts to be vertical.
5. Alignment of holes in posts may vary to conform to slope of top of retaining wall.
6. The Contractor shall verify all dependent dimensions in the field before ordering or fabricating any material.
7. Line posts shall be braced horizontally and trussed diagonally in both directions at intervals not to exceed 1000'.
8. Post pockets to be centered in top of wall.
9. Typical end spans, braced in both directions, shall be constructed at changes in line where the angle of deflection is 15° or more.
10. Provide thimbles at all cable loops.

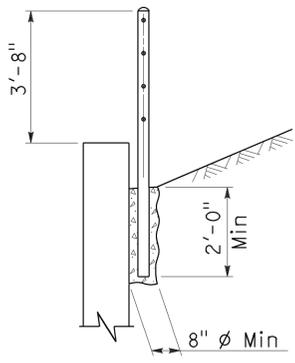


SECTION A-A Existing

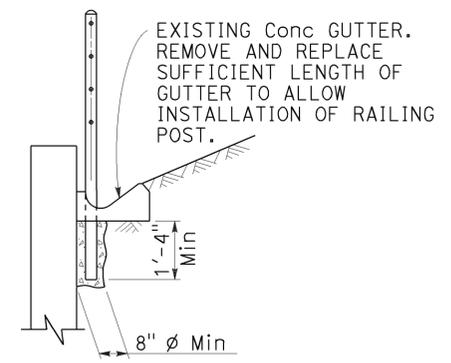


SECTION B-B Existing

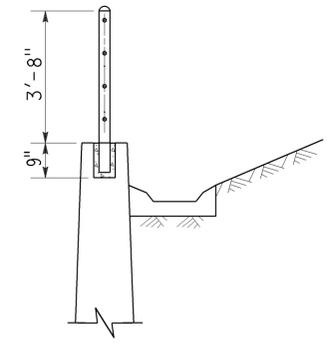


SECTION C-C New construction

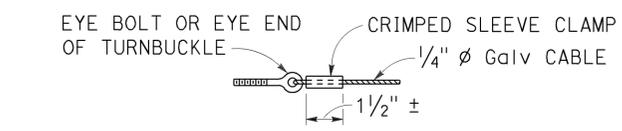

ALTERNATIVE CABLE CONNECTION

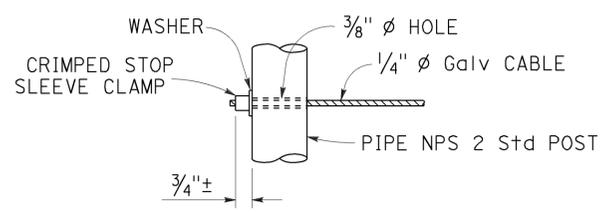

ALTERNATIVE DEAD END ANCHORAGE

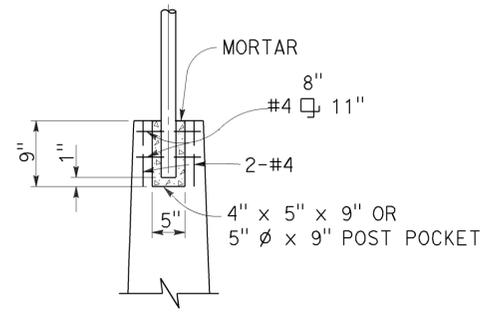

POST POCKET



STATE OF CALIFORNIA
DEPARTMENT OF TRANSPORTATION
CABLE RAILING

NO SCALE






RSP B11-47 DATED OCTOBER 21, 2011 SUPERSEDES STANDARD PLAN B11-47 DATED MAY 20, 2011 - PAGE 293 OF THE STANDARD PLANS BOOK DATED 2010.

REVISED STANDARD PLAN RSP B11-47

2010 REVISED STANDARD PLAN RSP B11-47

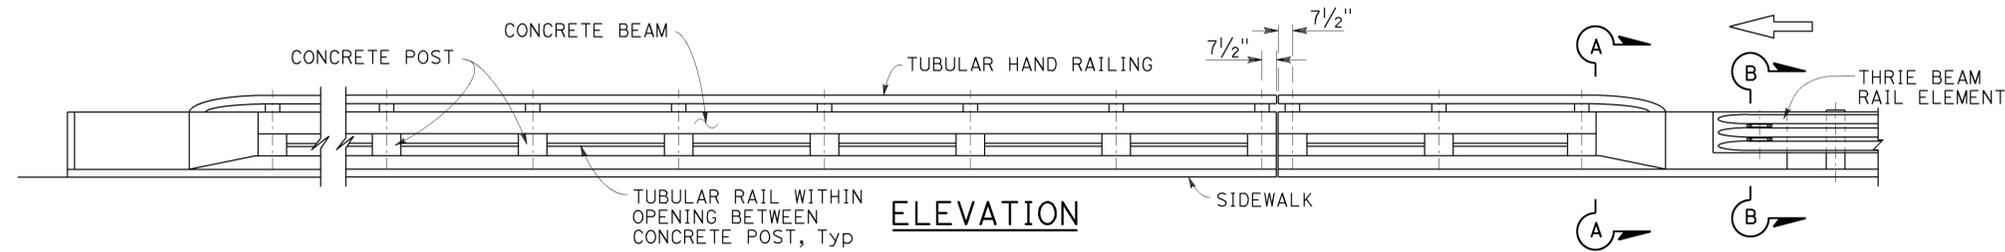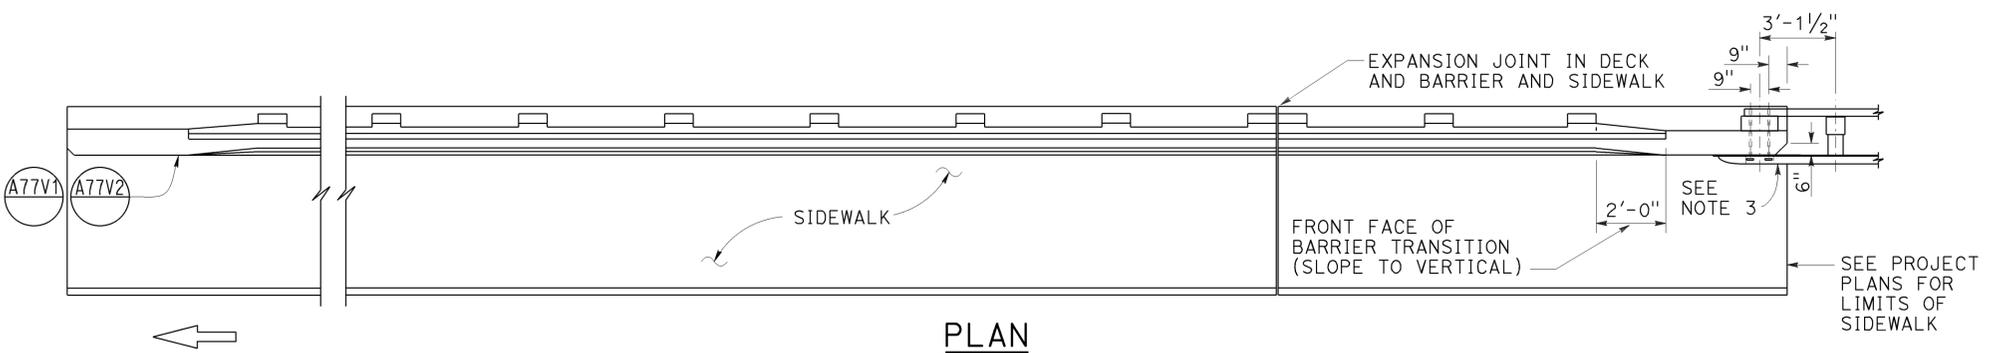

- NOTES:**
- No lap splicing allowed on the longitudinal rail reinforcing. Splicing shall be staggered.
 - For electrical details, see Standard Plans ES-9A, ES-9B, ES-9C, ES-9D and ES-9E. See Project Plans for electrical layout.
 - For typical metal railing connection details not shown, see Revised Standard Plans RSP A77V1 and A77V2.
 - A maximum of five - 4" and a minimum of two - 4" round openings for future utilities. Openings are to be sealed at ends and extended 8" minimum past end of sidewalk if not used. Duct forms are to be tied down. Minimum of 6" from face of rail to utility opening.
 - Chain link railing is not allowed on Type 80SW Barrier.
 - Walls are to be backfilled before railing is placed.
 - Terminate all longitudinal curb, sidewalk, and deck reinforcement in standard 90° hooks.
 - Dimensions will vary with cross slope and with certain thickness of surfacing.
 - Expansion joint to match deck joint, see Standard Plan B11-63 for expansion joint details.
 - This barrier is to be used only for speeds of 45 MPH or less. For speeds greater than 45 MPH, pedestrians should be protected by a separation traffic barrier.

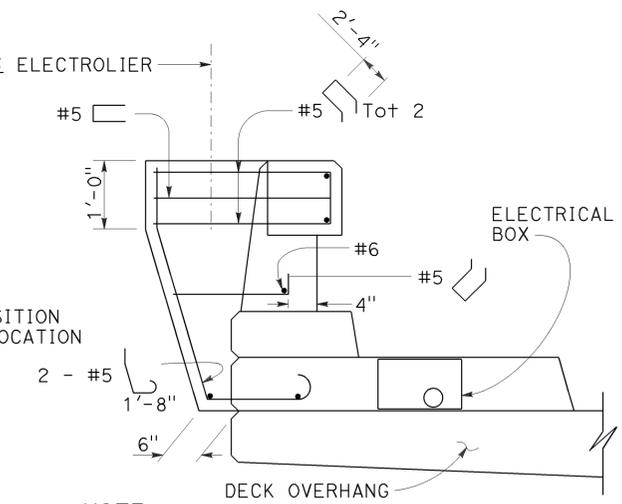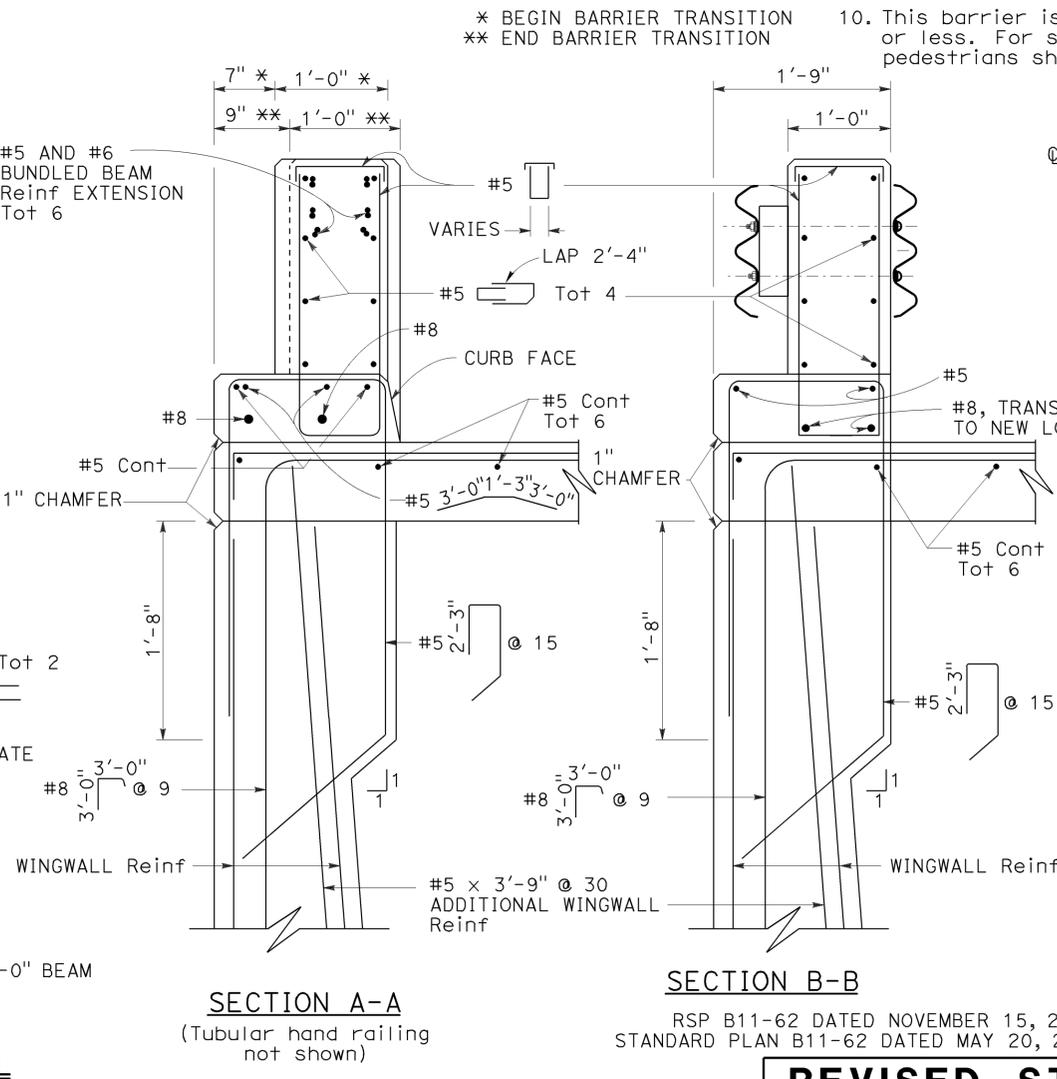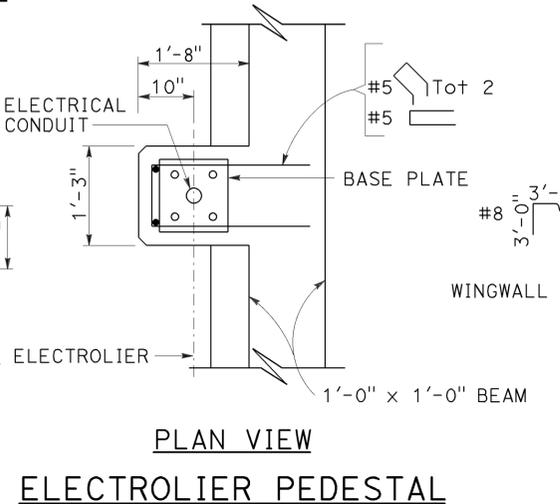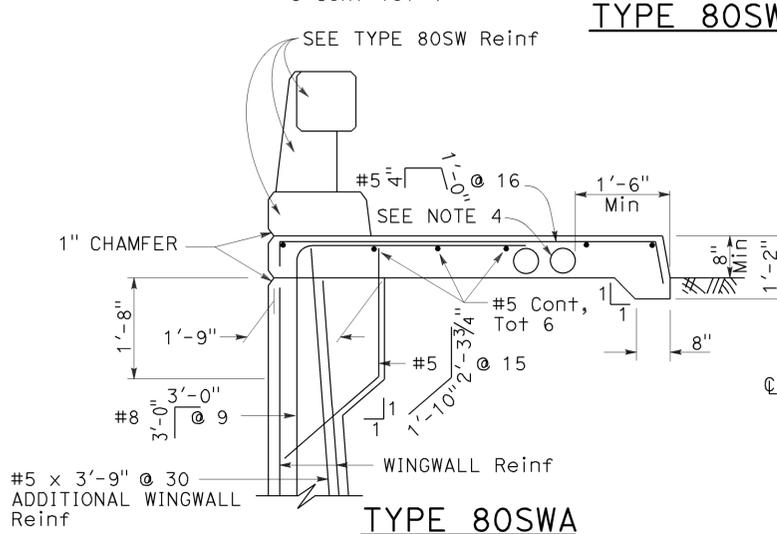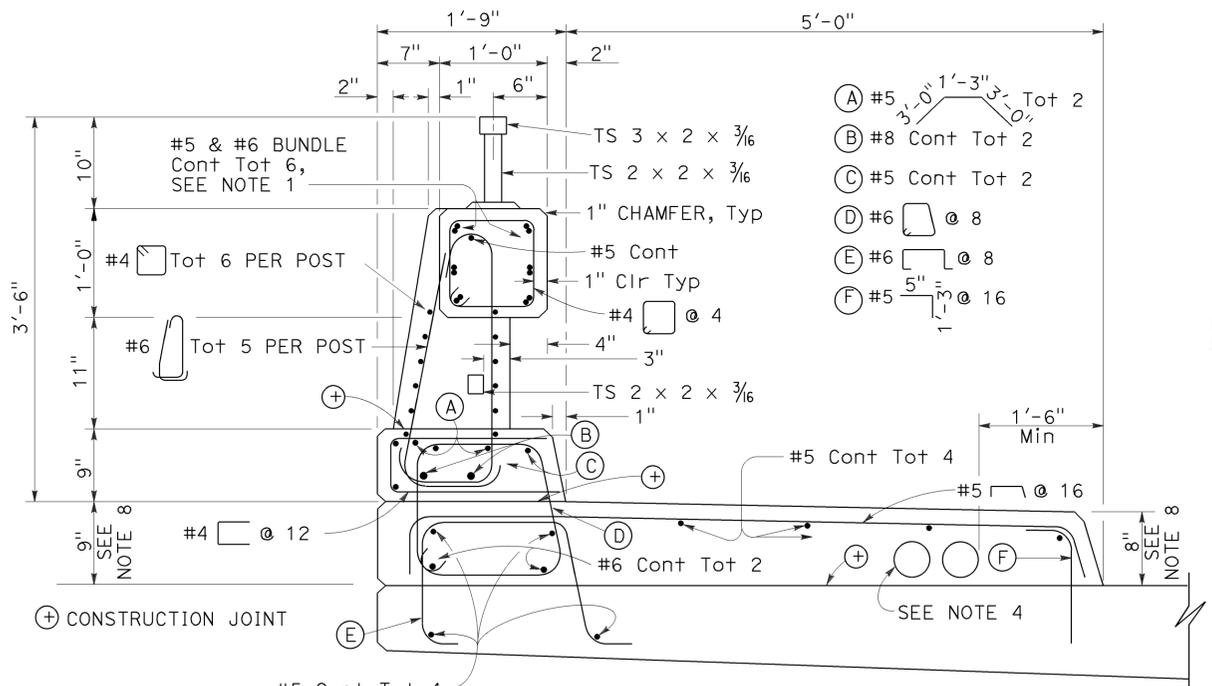

BARRIER MODIFICATION FOR ELECTROLIER


STATE OF CALIFORNIA
 DEPARTMENT OF TRANSPORTATION

CONCRETE BARRIER TYPE 80SW (SHEET 1 OF 3)

NO SCALE

RSP B11-62 DATED NOVEMBER 15, 2013 SUPERSEDES RSP B11-62 DATED JULY 19, 2013 AND STANDARD PLAN B11-62 DATED MAY 20, 2011 - PAGE 302 OF THE STANDARD PLANS BOOK DATED 2010.

2010 REVISED STANDARD PLAN RSP B11-62

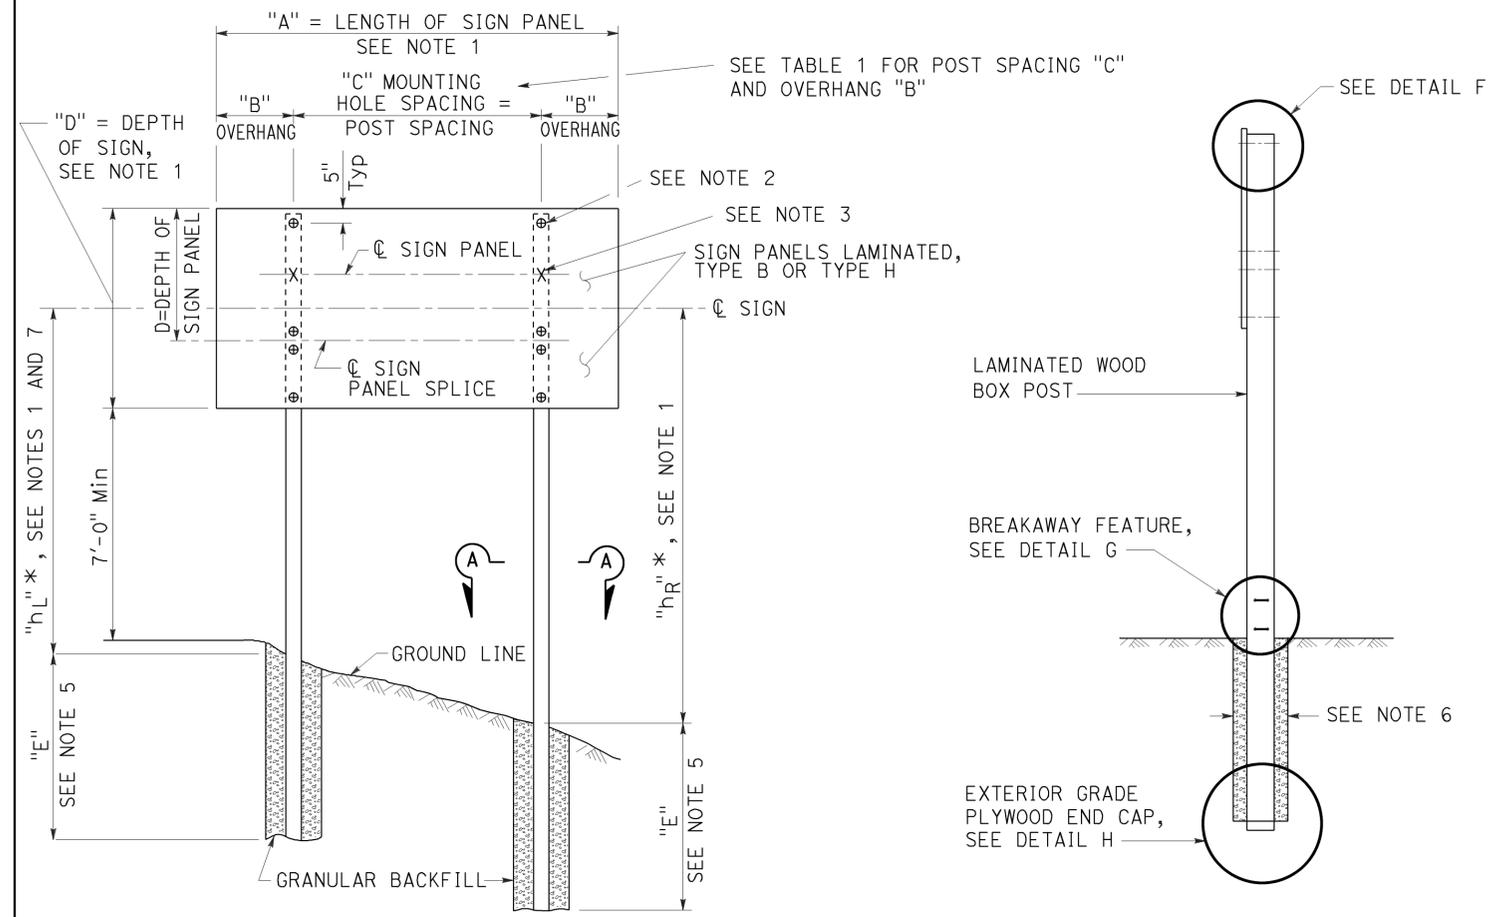

SIGN PANEL LENGTH (SEE NOTE 1)	SIGN PANEL OVERHANG	MOUNTING HOLE SPACING
"A"	"B"	"C"
8'-0"	1'-6"	5'-0"
9'-0"	1'-10"	5'-4"
10'-0"	2'-0"	6'-0"
11'-0"	2'-0"	7'-0"
12'-0"	2'-6"	7'-0"
13'-0"	2'-6"	8'-0"
14'-0"	2'-6"	9'-0"
15'-0"	3'-0"	9'-0"
16'-0"	3'-3"	9'-6"
17'-0"	3'-3"	10'-6"
18'-0"	3'-6"	11'-0"
19'-0"	3'-9"	11'-6"
20'-0"	4'-0"	12'-0"
21'-0"	4'-3"	12'-6"
22'-0"	4'-3"	13'-6"
23'-0"	4'-6"	14'-0"
24'-0"	4'-9"	14'-6"

TABLE 1

"h _L " OR "h _R " (IN FEET)	TOTAL SIGN AREA SQFT				
	40 TO 90	90+ TO 140	140+ TO 190	190+ TO 240	240+ TO 290
9'-0" TO 13'-0"	6'	6.5'	7.5'	8.5'	9'
13'-0"+ TO 17'-0"	6'	7'	8'	9'	10'
17'-0"+ TO 21'-0"	6'	7.5'	9'	9'	
21'-0"+ TO 26'-0"	7'	8'	9'		


TABLE 2

See Note 8


NOTES:

- See Project Plans for:
 Location of each sign.
 Length of sign panel "A".
 Depth of sign "D".
 Height "h_L" and "h_R" of centerline of sign above ground line at each post.
 Type of post, L and M.
 See Standard Plan RS1 for other details.
- "e" Indicates location of 1/2" lag screws and existing holes in panels. Lag screws are to be embedded at least 1" into post using 5/16" diameter pilot holes.
- "x" Indicates location of additional 1/2" lag screws required when the depth of sign panel (d) and the length of sign panel (A) are as follows:


A	d
17'-0" to 24'-0"	5'-0"
19'-0" to 24'-0"	4'-6"
21'-0" to 24'-0"	4'-0"
24'-0"	3'-6"
- Type B laminated sign panels are 1" nominal thick for sign lengths of 15'-0" and less. Panels over 15'-0" in length and Type H laminated sign panels are 2 1/2" nominal thick.
- Embedment "E" for Type L post shall conform to the requirements in Table 2. Embedment for Type M posts shall be 6'-0" minimum.
- Diameter of post holes for Type L posts shall be at least 2'-6". Diameter of post holes for Type M posts shall be at least 2'-0".
- Dimensions shown on project plans are for fabrication. During installation adjust these dimensions to provide A level sign approximately 7'-0" above roadway shoulder.
- Minimum post embedment "E" for Type L post.

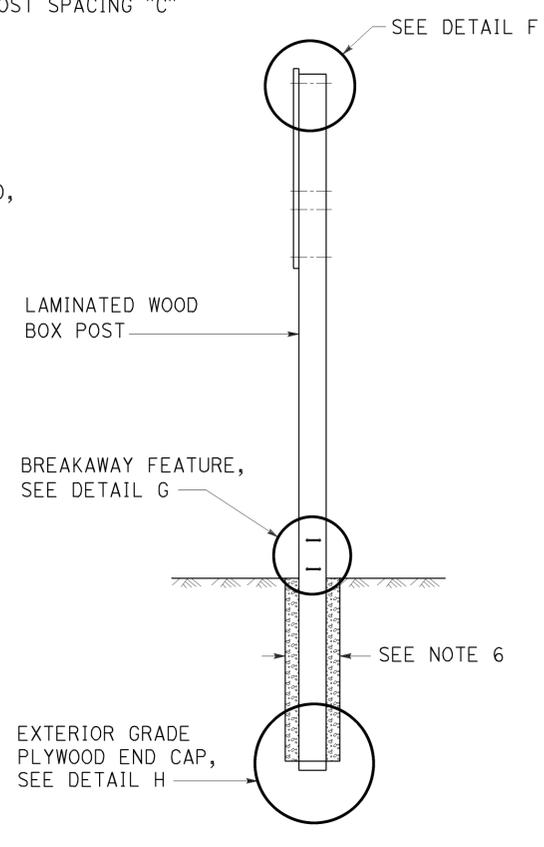


SIDE VIEW

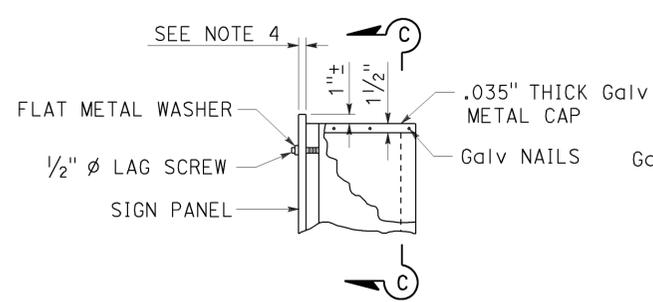


DETAIL F

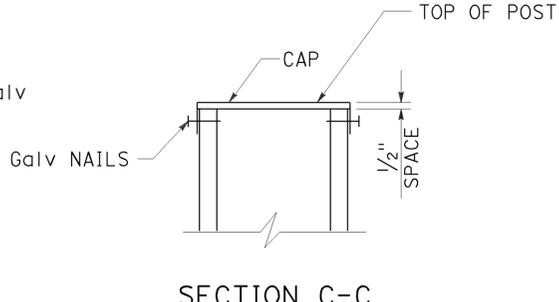


SECTION C-C

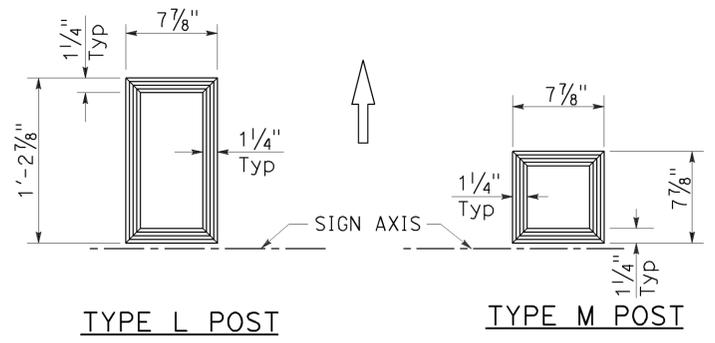


SECTION A-A

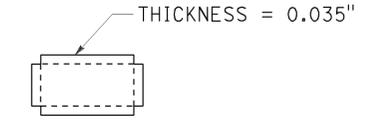


GALV METAL CAP

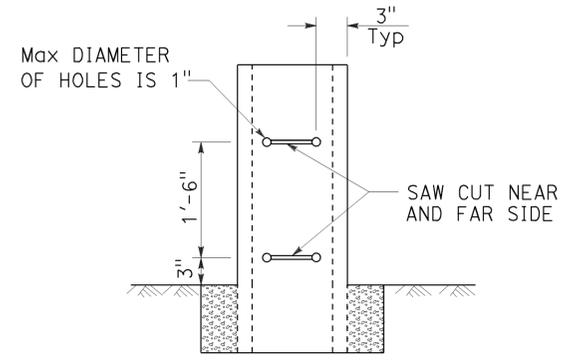


DETAIL G

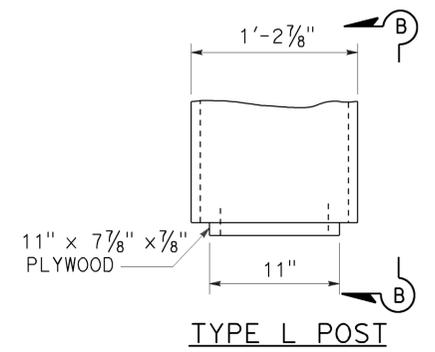

TYPE L POST

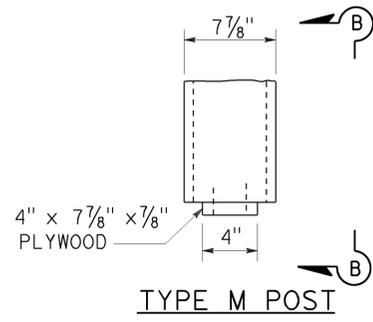

TYPE M POST

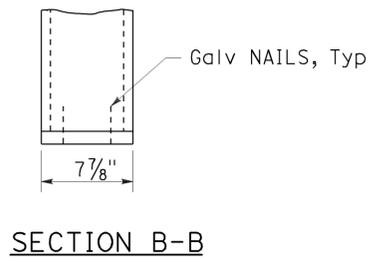

SECTION B-B

DETAIL H

STATE OF CALIFORNIA
 DEPARTMENT OF TRANSPORTATION
**ROADSIDE SIGNS
 LAMINATED WOOD BOX POST
 TYPICAL INSTALLATION
 DETAILS No. 3**

NO SCALE

RSP RS3 DATED OCTOBER 30, 2015 SUPERSEDES STANDARD PLAN RS3 DATED MAY 20, 2011 - PAGE 332 OF THE STANDARD PLANS BOOK DATED 2010.

2010 REVISED STANDARD PLAN RSP RS3

INSTRUCTIONS TO FABRICATOR

PROJECT PLANS SHOW:

1. Sign structure location.
2. Length of structure frame.
3. Panel size and locations on structure.
4. Walkway length for two post signs.
5. Post type and height to bottom of frame.
6. Base plate elevation.
7. Footing elevation or location of pile foundation.
8. Photoelectric unit location if required.

REFER TO THE FOLLOWING STANDARD PLANS FOR DETAILS NOT SHOWN ON PROJECT PLANS:

Sheet No. SHEET NAME

- S1 Overhead Signs-Truss, Instructions and Examples
- S2 Overhead Signs-Truss, Single Post Type, Post Types II to IX
- S3 Overhead Signs-Truss, Single Post Type, Base Plate and Anchorage Details
- S4 Overhead Signs-Truss, Single Post Type, Structural Frame Members Details No. 1
- S5 Overhead Signs-Truss, Single Post Type, Structural Frame Members Details No. 2
- S6 Overhead Signs-Truss, Gusset Plate Details
- S8 Overhead Signs-Truss, Single Post Type, Round Pedestal Pile Foundation
- S9 Overhead Signs-Truss, Two Post Type, Post Types I-S through VII-S
- S10 Overhead Signs-Truss, Two Post Type, Base Plate and Anchorage Details
- S11 Overhead Signs-Truss, Two Post Type, Structural Frame Members
- S12 Overhead Signs-Truss, Structural Frame Details
- S13 Overhead Signs-Truss, Frame Juncture Details
- S15 Overhead Signs-Truss, Two Post Type, Round Pedestal Pile Foundation
- S16 Overhead Signs, Walkway Details No. 1
- S17 Overhead Signs, Walkway Details No. 2
- S17A Overhead Signs, Walkway Details No. 3
- S18 Overhead Signs, Walkway Safety Railing Details
- S19 Overhead Signs-Truss, Sign Mounting Details, Laminated Panel-Type A
- S20 Overhead Signs, Steel Frames, Removable Sign Panel Frames
- S21 Overhead Signs, Removable Sign Panel Frames, Mounting Details
- S22 Overhead Signs-Truss, Removable Sign Panel Frames, 9'-2" and 10'-0" Sign Panels

WALKWAY BRACKETS:

Space all walkway brackets maintaining uniform spacing where possible. Maximum spacing shall not exceed 5'-6".

LIGHTING FIXTURE SUPPORTS:

Where distance from walkway bracket to end of sign panel exceeds 1'-4", extend lighting fixture supports to next walkway bracket. See Example No. 2.

WALKWAY AND SAFETY RAILING:

Walkway to be continuous for entire length of frame for single post signs. For two post signs, see Project Plans. Safety railing to protect entire walkway, but continuous for no more than 11'-0" in one unit.



NOTES:

1. Signs are shown and dimensioned looking in the direction of traffic. Double faced signs are shown and dimensioned looking ahead along stationing.
2. Mandatory dimension limit.

GENERAL NOTES:

LOADING:

WIND LOADING:

Normal to face of sign: 40.3 psf on 100% Truss surface area (i.e. 100% panel coverage).
 Transverse to face of sign: 20% of normal force.

WALKWAY LOADING:

Dead load +500 LB concentrated live load.

UNIT STRESSES:



STRUCTURAL STEEL: $f_y = 36,000$ psi
 REINFORCED CONCRETE: $f_y = 60,000$ psi
 $f'_c = 3600$ psi
 FOOTING SOIL PRESSURE: 2.5 ksf (spread footing)

MINIMUM CLEARANCE

Vertical roadway clearance 18'-0" (bottom of walkway system)


WELDING:

All welding continuous unless otherwise noted on the plans.

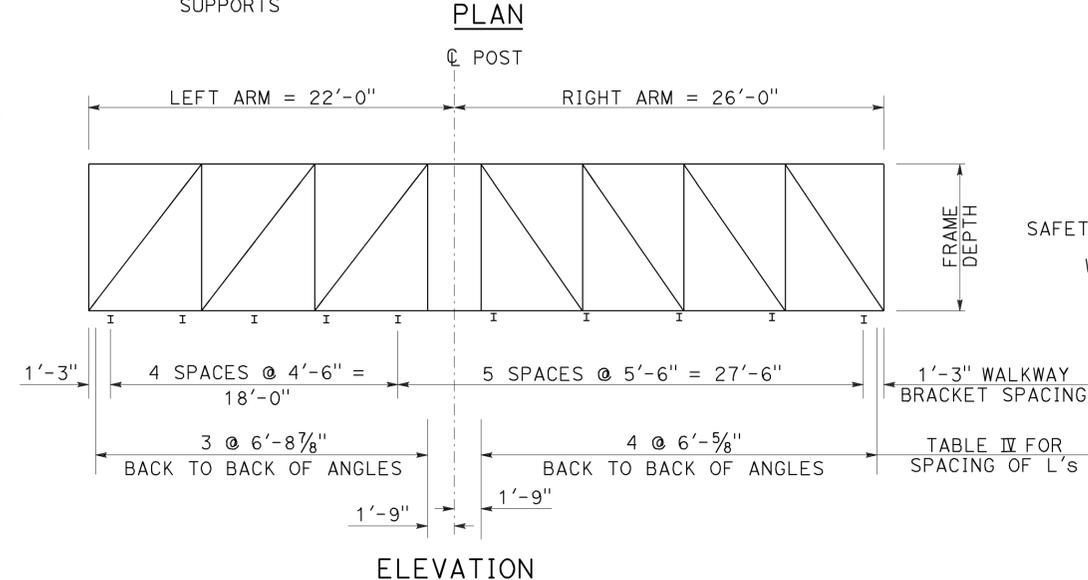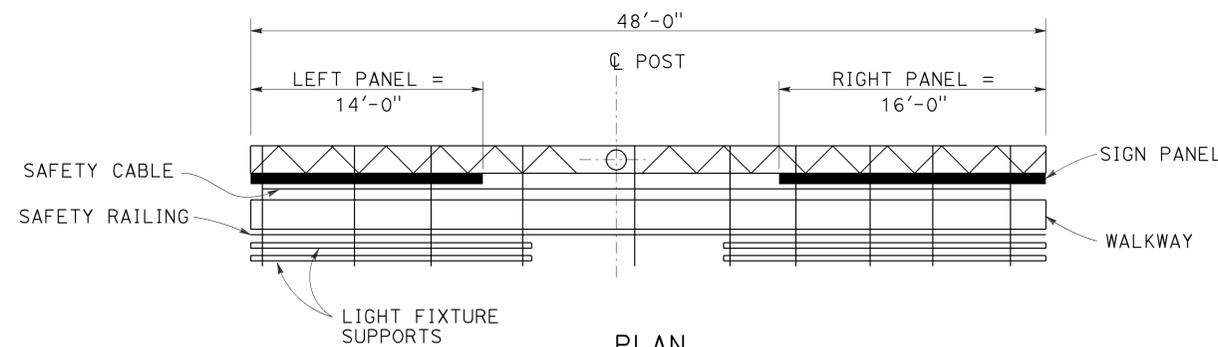


UNBALANCED SINGLE POST TYPE

Example No. 1

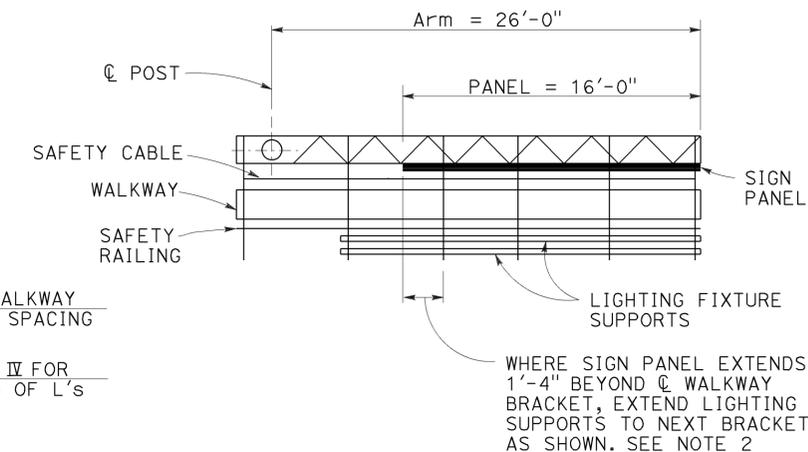

CANTILEVER SINGLE POST TYPE

Example No. 2

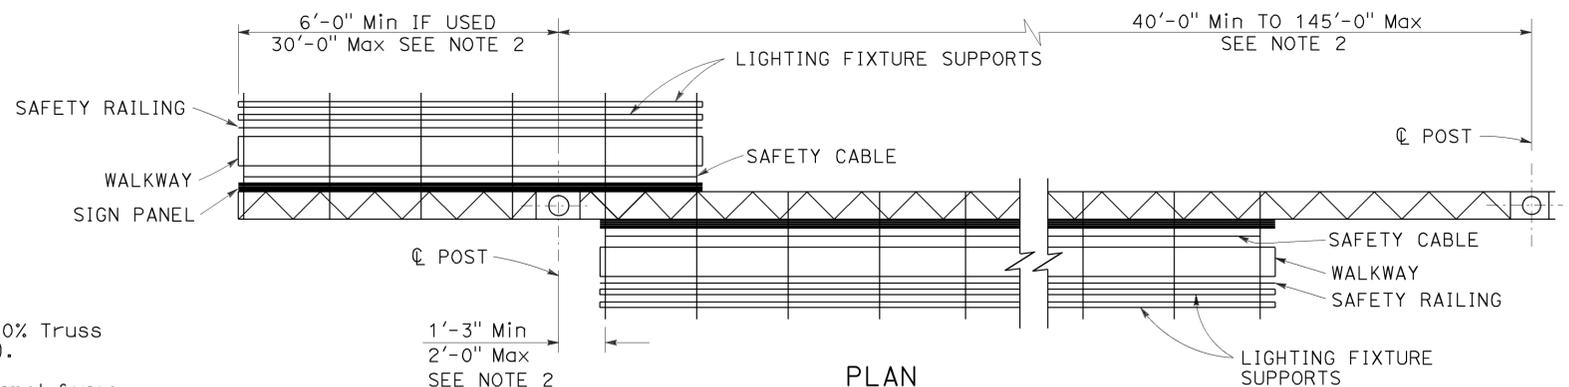

TWO POST TYPE WITH CANTILEVER (PART DOUBLE-FACED)

Example No. 3

STATE OF CALIFORNIA
 DEPARTMENT OF TRANSPORTATION

OVERHEAD SIGNS-TRUSS INSTRUCTIONS AND EXAMPLES

NO SCALE

RSP S1 DATED JULY 19, 2013 SUPERSEDES STANDARD PLAN S1 DATED MAY 20, 2011 - PAGE 334 OF THE STANDARD PLANS BOOK DATED 2010.

REVISED STANDARD PLAN RSP S1

Dist	COUNTY	ROUTE	POST MILES TOTAL PROJECT	SHEET No.	TOTAL SHEETS
05	SB	101	2.2/3.3	494	786

Stanley P. Johnson
 REGISTERED CIVIL ENGINEER

July 19, 2013
 PLANS APPROVAL DATE

Stanley P. Johnson
 No. C57793
 Exp. 3-31-14
 CIVIL
 STATE OF CALIFORNIA

TO ACCOMPANY PLANS DATED 12-7-15

2010 REVISED STANDARD PLAN RSP S1

TABLE XV

POST TYPE	PIPE		CAP PLATE SIZE FOR CHORD L's 5 x 5	CAP PLATE SIZE FOR CHORD L's 6 x 6	ROUND PEDESTAL					SQUARE PEDESTAL					SPREAD FOOTING						
	NPS	THICKNESS			PEDESTAL SIZE Dia	VERTICAL EQUALLY SPACED TOTAL	J-BARS BAR SIZE	SPIRAL BAR SIZE	PITCH	PEDESTAL SIZE SQUARE	VERTICAL EQUALLY SPACED TOTAL	J-BARS BAR SIZE	# OF BARS EA FACE	HOOP BAR SIZE	SPACING	(SEE NOTE 2)					
	REINFORCEMENT		WIDTH													LONGITUDINAL		FOOTING STIRRUPS			
II	14	1/2"	2'-0" x 2'-0" x 1"	2'-2" x 2'-2" x 1"	5'-3"	16	#10	#5	3 1/2"	5'-3"	16	#10	5	#5	3 1/2"	12'-0" x 14'-0" x 2'-6"	14-#6		14-#7	13-#9	13-#9
III	16		2'-2" x 2'-2" x 1"	2'-4" x 2'-4" x 1"												12'-0" x 14'-0" x 2'-6"	15-#6	15-#7			
IV	18		2'-4" x 2'-4" x 1"	2'-6" x 2'-6" x 1"												12'-0" x 14'-0" x 2'-6"	15-#6	15-#7			
V	20		2'-6" x 2'-6" x 1"	2'-8" x 2'-8" x 1"												13'-0" x 14'-0" x 2'-6"	15-#6	15-#7	14-#9	14-#9	
VI	24		2'-10" x 2'-10" x 1"	3'-0" x 3'-0" x 1"	5'-9"		#11			5'-9"		#11				13'-0" x 16'-0" x 2'-6"	17-#7	17-#7		14-#11	
VII	24	3/4"														13'-0" x 17'-0" x 2'-6"	18-#7	18-#7			
VIII	24	3/32"														13'-0" x 18'-0" x 2'-6"	19-#7	19-#7			
IX	24	3/32"														13'-0" x 18'-0" x 2'-6"	19-#7	19-#7			

Dist	COUNTY	ROUTE	POST MILES TOTAL PROJECT	SHEET No.	TOTAL SHEETS
05	SB	101	2.2/3.3	495	786



Stanley P. Johnson
REGISTERED CIVIL ENGINEER

July 19, 2013
PLANS APPROVAL DATE

THE STATE OF CALIFORNIA OR ITS OFFICERS OR AGENTS SHALL NOT BE RESPONSIBLE FOR THE ACCURACY OR COMPLETENESS OF SCANNED COPIES OF THIS PLAN SHEET.



Stanley P. Johnson
REGISTERED PROFESSIONAL ENGINEER
No. C57793
Exp. 3-31-14
CIVIL
STATE OF CALIFORNIA

TO ACCOMPANY PLANS DATED 12-7-15

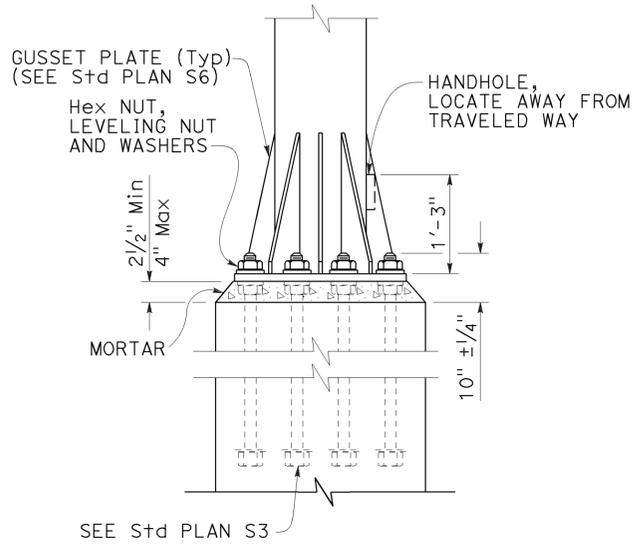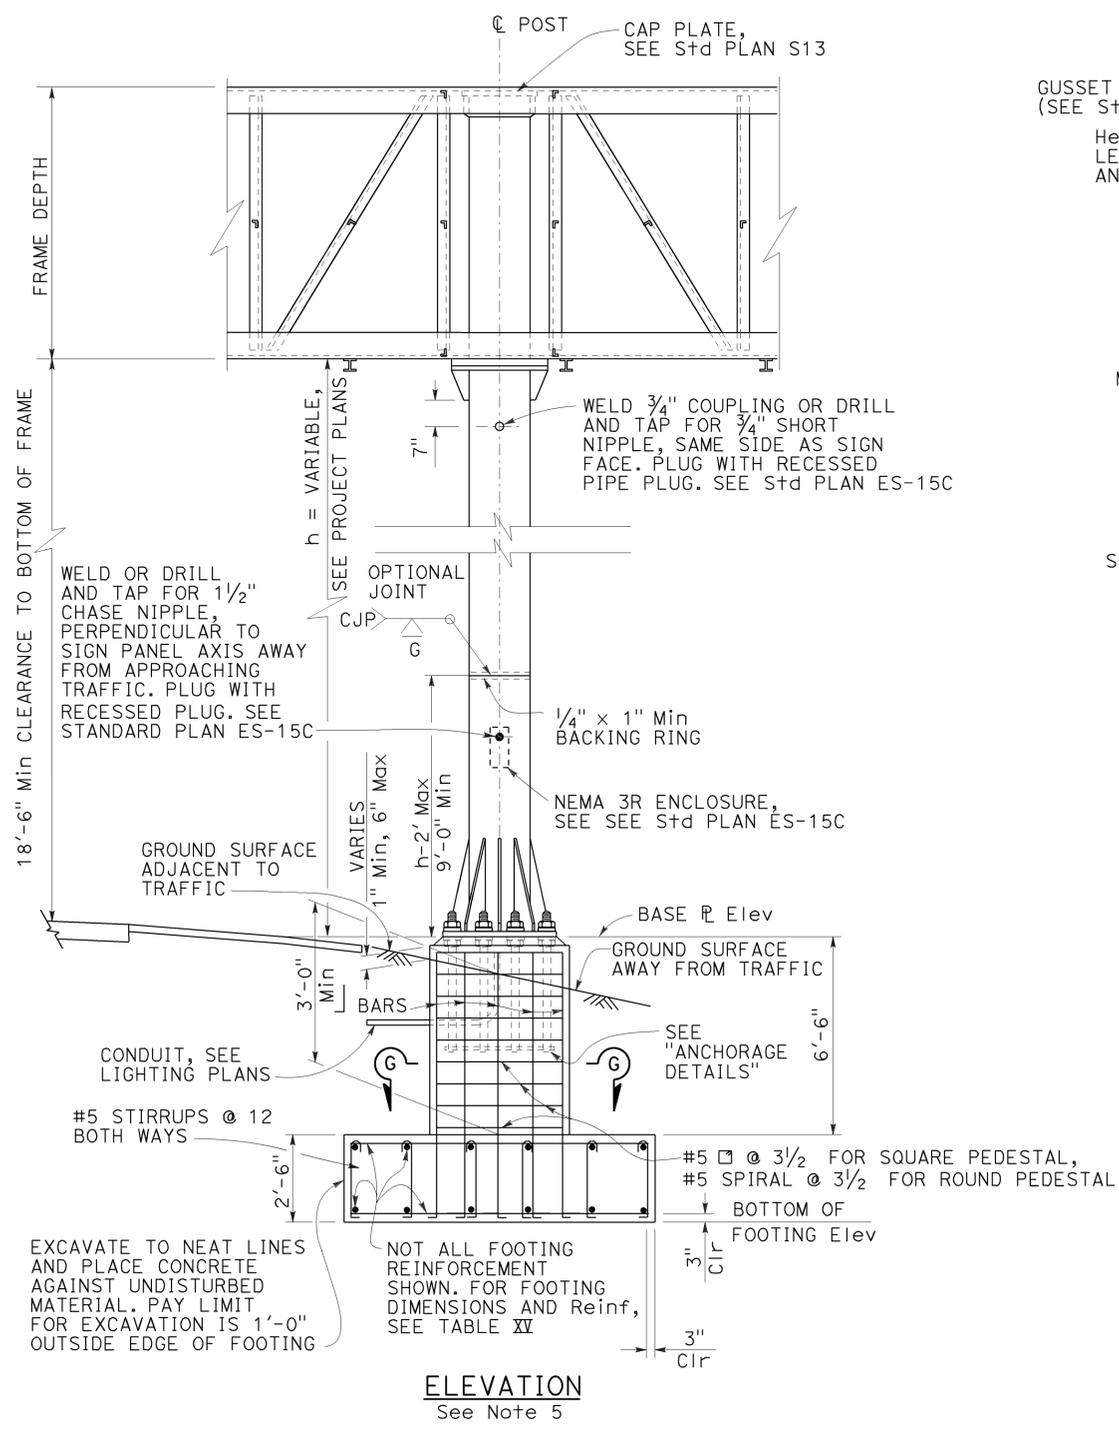

ELEVATION ANCHORAGE DETAILS


GRIND EDGES SMOOTH, ROUGHNESS OF EDGES NO GREATER THAN 1000 MICROINCHES

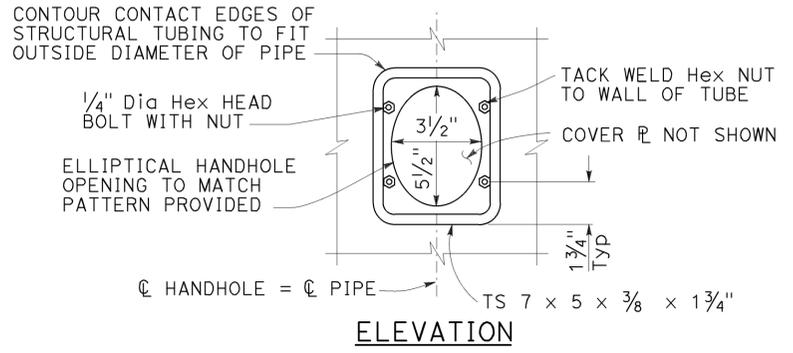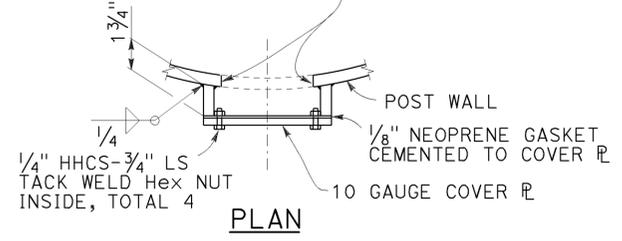

ELEVATION TYPICAL DETAILS OF HANDHOLE AND COVER

NOTES:

- For "General Notes", see Revised Standard Plan RSP S1.
- Longer side of footing (longitudinal) shall be normal to axis of sign.
- Backfill shall be in place prior to erection of post.
- Thread upper 10" of anchor bolts and galvanize upper 1'-0".
- Spread footing with square pedestal foundation shown, use Pile Foundation when shown on the Project Plans. For pile foundation details, see Standard Plan S8.
- Anchor plates may be retained with hexagon nut or formed head as alternatives to details shown.
- On single post sign structures, the post shall be raked out of plumb, with the use of the leveling nuts to make the bottom of the sign frame level.
- At final position of post all top and bottom nuts shall be tightened against base plate.
- When foundation is located on a steep slope with exposed face of concrete adjacent to traffic, see "Detail C" on Standard Plan S8, as applicable.
- Slope protection required when indicated on the Project Plans.

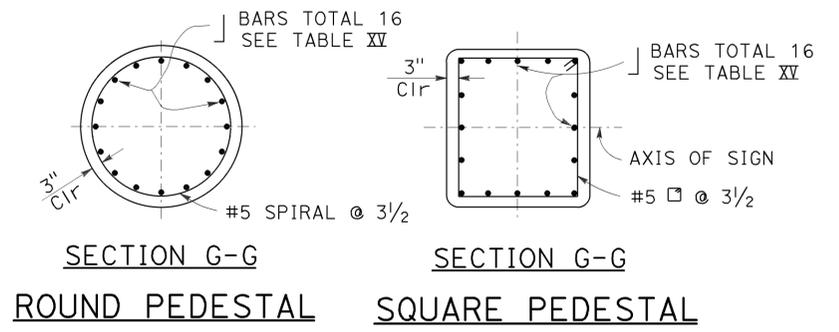

SECTION G-G ROUND PEDESTAL SECTION G-G SQUARE PEDESTAL

STATE OF CALIFORNIA
DEPARTMENT OF TRANSPORTATION
**OVERHEAD SIGNS-TRUSS
SINGLE POST TYPE
POST TYPES II THROUGH IX**
NO SCALE

RSP S2 DATED JULY 19, 2013 SUPERSEDES STANDARD PLAN S2 DATED MAY 20, 2011 - PAGE 335 OF THE STANDARD PLANS BOOK DATED 2010.

REVISED STANDARD PLAN RSP S2


2010 REVISED STANDARD PLAN RSP S2

LEGEND:

AB	ABANDON. IF APPLIED TO CONDUIT, REMOVE CONDUCTORS
BC	INSTALL PULL BOX IN EXISTING CONDUIT RUN
BP	PEDESTRIAN BARRICADE, TYPE AS INDICATED ON PLAN
CB	INSTALL CONDUIT INTO EXISTING PULL BOX
CC	CONNECT NEW AND EXISTING CONDUIT. REMOVE EXISTING CONDUCTORS AND INSTALL CONDUCTORS AS INDICATED
CF	CONDUIT TO REMAIN FOR FUTURE USE. REMOVE CONDUCTORS. INSTALL PULL TAPE
DH	DETECTOR HANDHOLE
FA	FOUNDATION TO BE ABANDONED
IS	INSTALL SIGN ON SIGNAL MAST ARM
NS	NO SLIP BASE ON STANDARD
PEC	PHOTOELECTRIC CONTROL
PEU	PHOTOELECTRIC UNIT
RC	EQUIPMENT OR MATERIAL TO BE REMOVED AND BECOME THE PROPERTY OF THE CONTRACTOR
RE	REMOVE ELECTROLIER, FUSES AND BALLAST. TAPE ENDS OF CONDUCTORS
RL	RELOCATE EQUIPMENT
RR	REMOVE AND REUSE EQUIPMENT
RS	REMOVE AND SALVAGE EQUIPMENT
SC	SPLICE NEW TO EXISTING CONDUCTORS
SD	SERVICE DISCONNECT
TSP	TELEPHONE SERVICE POINT

ABBREVIATIONS

AC+	UNDERGROUNDED CONDUCTOR	MAT	MAST ARM MOUNTING TOP ATTACHMENT
APS	ACCESSIBLE PEDESTRIAN SIGNAL	MAS	MAST ARM MOUNTING SIDE ATTACHMENT
Batt+	BATTERY	MBPS	MANUAL BYPASS SWITCH
BBS	BATTERY BACKUP SYSTEM	M/M	MULTIPLE TO MULTIPLE TRANSFORMER
BC	BOLT CIRCLE	Mtg	MOUNTING
BIK	BLACK	MV	MERCURY VAPOR LIGHTING FIXTURE
BP	BYPASS	MVDS	MICROWAVE VEHICLE DETECTION SYSTEM
BPB	BICYCLE PUSH BUTTON	N	NEUTRAL (GROUNDED CONDUCTOR)
C	CONDUIT	NB	NEUTRAL BUS
CB	CIRCUIT BREAKER	NC	NORMALLY CLOSE
CCTV	CLOSED CIRCUIT TELEVISION	NO	NORMALLY OPEN
Ckt	CIRCUIT	P	CIRCUIT BREAKER'S POLE
CMS	CHANGEABLE MESSAGE SIGN	PB	PULL BOX
Ctid	CALTRANS IDENTIFICATION	PBA	PUSH BUTTON ASSEMBLY
Comm	COMMUNICATION	PEC	PHOTOELECTRIC CONTROL
Cn+l	CONTROL	Ped	PEDESTRIAN
DF	DEPARTMENT-FURNISHED	PEU	PHOTOELECTRIC UNIT
DLC	LOOP DETECTOR LEAD-IN CABLE	PT	CONDUIT WITH PULL TAPE
EMS	EXTINGUISHABLE MESSAGE SIGN	PTR	POWER TRANSFER RELAY
EVUC	EMERGENCY VEHICLE UNIT CABLE	RE	RELOCATED EQUIPMENT
EVUD	EMERGENCY VEHICLE UNIT DETECTOR	RM	RAMP METERING
FB	FLASHING BEACON	RWIS	ROADSIDE WEATHER INFORMATION SYSTEM
FBCA	FLASHING BEACON CONTROL ASSEMBLY	SB	SLIP BASE
FBS	FLASHING BEACON WITH SLIP BASE	SIC	SIGNAL INTERCONNECT CABLE
FO	FIBER OPTIC	Sig	SIGNAL
G	EQUIPMENT GROUNDING CONDUCTOR	SMA	SIGNAL MAST ARM
GB	GROUND BUS	SNS	STREET NAME SIGN
GFCI	GROUND FAULT CIRCUIT INTERRUPTER	SP	SERVICE POINT
Grn	GREEN	TB	TERMINAL BOARD
HAR	HIGHWAY ADVISORY RADIO	TDC	TELEPHONE DEMARCATION CABINET
Hex	HEXAGONAL	Temp	TEMPERATURE
HPS	HIGH PRESSURE SODIUM	TMS	TRAFFIC MONITORING STATION
IISNS	INTERNALLY ILLUMINATED STREET NAME SIGN	TOS	TRAFFIC OPERATIONS SYSTEM
ISL	INDUCTION SIGN LIGHTING	UPS	UNINTERRUPTABLE POWER SUPPLY
LED	LIGHT EMITTING DIODE	UPSC	UNINTERRUPTABLE POWER SUPPLY CONTROLLER
LMA	LUMINAIRE MAST ARM	Veh	VEHICLE
LPS	LOW PRESSURE SODIUM	VIVDS	VIDEO IMAGE VEHICLE DETECTION SYSTEM
Ltg	LIGHTING	Wht	WHITE
Lum	LUMINAIRE	WIM	WEIGH-IN-MOTION
M	METERED	Xfmr	TRANSFORMER

 Dist	COUNTY	ROUTE	POST MILES TOTAL PROJECT	SHEET No.	TOTAL SHEETS
05	SB	101	2.2/3.3	496	786
 REGISTERED ELECTRICAL ENGINEER					
October 30, 2015 PLANS APPROVAL DATE					
					
<small>THE STATE OF CALIFORNIA OR ITS OFFICERS OR AGENTS SHALL NOT BE RESPONSIBLE FOR THE ACCURACY OR COMPLETENESS OF SCANNED COPIES OF THIS PLAN SHEET.</small>					

TO ACCOMPANY PLANS DATED 12-7-15

SOFFIT AND WALL-MOUNTED LUMINAIRES

-  PENDANT SOFFIT LUMINAIRE, 70 W HPS UNLESS OTHERWISE SPECIFIED
-  FLUSH-MOUNTED SOFFIT LUMINAIRE, 70 W HPS UNLESS OTHERWISE SPECIFIED
-  WALL-MOUNTED LUMINAIRE, 70 W HPS UNLESS OTHERWISE SPECIFIED
-  EXISTING SOFFIT OR WALL-MOUNTED LUMINAIRE TO REMAIN UNMODIFIED
-  EXISTING SOFFIT OR WALL-MOUNTED LUMINAIRE TO BE MODIFIED AS SPECIFIED

NOTE:
Arrow indicates "street side" of luminaire.

COMMONLY USED SYMBOLS FOR UNITED STATES CUSTOMARY UNITS OF MEASUREMENT:

SYMBOL	DEFINITIONS
Ω	OHMS
min	MINUTE
s	SECOND
bps	BITS PER SECOND
Bps	BYTES PER SECOND
A	AMPERE
V	VOLT
V(dc)	VOLT (DIRECT CURRENT)
V(ac)	VOLT (ALTERNATING CURRENT)
FC	FOOT - CANDLE
W	WATTS
VA	VOLT-AMPERE
M	MEGA
k	KILO
m	MILLI
μ	MICRO
P	PICO
Hz	HERTZ

STATE OF CALIFORNIA
DEPARTMENT OF TRANSPORTATION

ELECTRICAL SYSTEMS (LEGEND AND ABBREVIATIONS)

NO SCALE

RSP ES-1A DATED OCTOBER 30, 2015 SUPERSEDES RSP ES-1A DATED JULY 19, 2013 AND STANDARD PLAN ES-1A DATED MAY 20, 2011 - PAGE 425 OF THE STANDARD PLANS BOOK DATED 2010.

REVISED STANDARD PLAN RSP ES-1A







MISCELLANEOUS ELECTROLIERS

NEW	EXISTING	
		LUMINAIRE ON WOOD POLE
		NON-STANDARD ELECTROLIER (SEE PROJECT LEGEND)
		CITY ELECTROLIER
		ELECTROLIER FOUNDATION (FUTURE INSTALLATION)

NOTES:

- LED luminaires shall be 235 W when installed on Type 21, 21D, 30, 31 and 32 Standards, unless otherwise specified. LED luminaires shall be 165 W when installed on other type standards or poles, unless otherwise specified.
- Luminaires shall be the cutoff type, ANSI Type III medium cutoff lighting distribution, unless otherwise specified.

      STANDARD ELECTROLIER

NEW	EXISTING	STANDARD TYPE
		15
		15D
		15 STRUCTURE
		15D STRUCTURE
		21
		21D
		21 STRUCTURE
		21D STRUCTURE
		30
		31
		32

2010 REVISED STANDARD PLAN RSP ES-1A

Dist	COUNTY	ROUTE	POST MILES TOTAL PROJECT	SHEET No.	TOTAL SHEETS
05	SB	101	2.2/3.3	497	786

Theresa Gabriel
REGISTERED ELECTRICAL ENGINEER

October 30, 2015
PLANS APPROVAL DATE

Theresa Aziz Gabriel
No. E15129
Exp. 6-30-16
ELECTRICAL
STATE OF CALIFORNIA

THE STATE OF CALIFORNIA OR ITS OFFICERS OR AGENTS SHALL NOT BE RESPONSIBLE FOR THE ACCURACY OR COMPLETENESS OF SCANNED COPIES OF THIS PLAN SHEET.

TO ACCOMPANY PLANS DATED 12-7-15

CONDUIT

NEW	EXISTING	
		LIGHTING CONDUIT, UNLESS OTHERWISE INDICATED OR NOTED
		TRAFFIC SIGNAL CONDUIT
		COMMUNICATION CONDUIT
		TELEPHONE CONDUIT
		FIRE ALARM CONDUIT
		FIBER OPTIC CONDUIT
		CONDUIT TERMINATION
		CONDUIT RISER ATTACHED TO THE STRUCTURE OR SERVICE POLE


SIGNAL EQUIPMENT

NEW	EXISTING	
		PEDESTRIAN SIGNAL HEAD
		PUSH BUTTON ASSEMBLY POST
		PEDESTRIAN BARRICADE
		VEHICLE SIGNAL HEAD (WITH BACKPLATE AND 3-SECTIONS: RED, YELLOW AND GREEN)
		VEHICLE SIGNAL HEAD WITH ANGLE VISOR
		MODIFICATIONS OF BASIC SYMBOL: "L" INDICATES ALL NON-ARROW SECTIONS LOUVERED "LG" INDICATES LOUVERED GREEN SECTION ONLY "PV" INDICATES ALL 12" SECTIONS PROGRAMMED VISIBILITY "8" INDICATES ALL 8" SECTIONS (ONLY WHEN SPECIFIED)
		VEHICLE SIGNAL HEAD CONSISTING OF RED, YELLOW AND GREEN LEFT ARROW SECTIONS
		VEHICLE SIGNAL HEAD CONSISTING OF RED AND YELLOW SECTIONS WITH AN UP GREEN ARROW SECTION
		VEHICLE SIGNAL HEAD (5 SECTION) CONSISTING OF RED, YELLOW AND GREEN SECTIONS WITH YELLOW AND GREEN RIGHT ARROW SECTIONS
		TYPE 15TS STANDARD WITH VEHICLE SIGNAL HEAD AND LUMINAIRE
		TYPE 21TS STANDARD WITH VEHICLE SIGNAL HEAD AND LUMINAIRE
		STANDARD WITH LUMINAIRE AND SIGNAL MAST ARMS AND ATTACHED VEHICLE SIGNAL HEADS
		TYPE 1 STANDARD WITH ATTACHED VEHICLE SIGNAL HEADS
		STANDARD WITH A SIGNAL MAST ARM, ATTACHED VEHICLE SIGNAL HEADS AND INTERNALLY ILLUMINATED STREET NAME SIGN
		CONTROLLER ASSEMBLY. DOOR INDICATES FRONT OF CABINET

SERVICE EQUIPMENT

NEW	EXISTING	
		OVERHEAD LINES
		WOOD POLE, "U" INDICATES UTILITY OWNED
		POLE GUY WITH ANCHOR
		UTILITY TRANSFORMER - GROUND MOUNTED
		SERVICE EQUIPMENT ENCLOSURE TYPE. DOOR INDICATES FRONT OF ENCLOSURE
		TELEPHONE DEMARCATION CABINET

 POLE-MOUNTED SERVICE DESIGNATION



FLASHING BEACON

NEW	EXISTING	
		FLASHING BEACON (ONE VEHICLE SIGNAL HEAD WITH BACKPLATE AND VISOR) "R" INDICATES RED INDICATION, "Y" INDICATES YELLOW INDICATION
		FLASHING BEACON WITH TYPE 15-FBS STANDARD AND A SIGN.
		FLASHING BEACON WITH TYPES 9, 9A OR 9B SIGN UNLESS OTHERWISE SPECIFIED OR INDICATED

SIGNAL EQUIPMENT Cont

NEW	EXISTING	
		GUARD POST
		TYPE 1 STANDARD WITH RAMP METERING SIGN
		OPTICAL DETECTOR FOR THE EMERGENCY VEHICLE DETECTION

NOTES:

- All signal sections shall be 12" unless shown otherwise.
- Signal heads shall be provided with backplates unless shown otherwise.

ILLUMINATED OVERHEAD SIGN

NEW	EXISTING	
		SINGLE POST, SINGLE ILLUMINATED SIGN, BALANCED BUTTERFLY
		SINGLE POST, DOUBLE ILLUMINATED SIGN, BALANCED BUTTERFLY
		SINGLE POST, SINGLE ILLUMINATED SIGN, FULL CANTILEVER
		DOUBLE POST, SINGLE ILLUMINATED SIGN
		SINGLE ILLUMINATED SIGN MOUNTED ON STRUCTURE
		DOUBLE POST, SINGLE ILLUMINATED SIGN WITH ELECTROLIER

STATE OF CALIFORNIA
DEPARTMENT OF TRANSPORTATION

**ELECTRICAL SYSTEMS
(LEGEND AND ABBREVIATIONS)**

NO SCALE


RSP ES-1B DATED OCTOBER 30, 2015 SUPERSEDES RSP ES-1B DATED JULY 19, 2013 AND STANDARD PLAN ES-1B DATED MAY 20, 2011 - PAGE 426 OF THE STANDARD PLANS BOOK DATED 2010.

REVISED STANDARD PLAN RSP ES-1B


2010 REVISED STANDARD PLAN RSP ES-1B

EQUIPMENT IDENTIFICATION


ILLUMINATED SIGN IDENTIFICATION NUMBER:

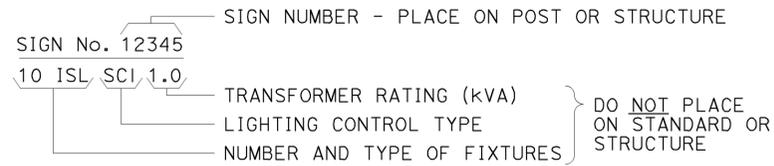


ELECTROLIER OR EQUIPMENT IDENTIFICATION NUMBER:

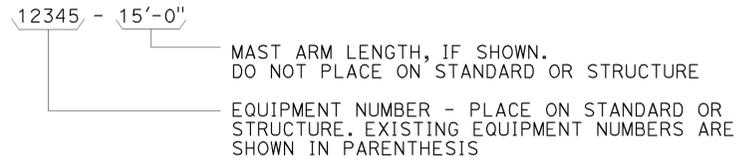


CONDUIT AND CONDUCTOR IDENTIFICATION:

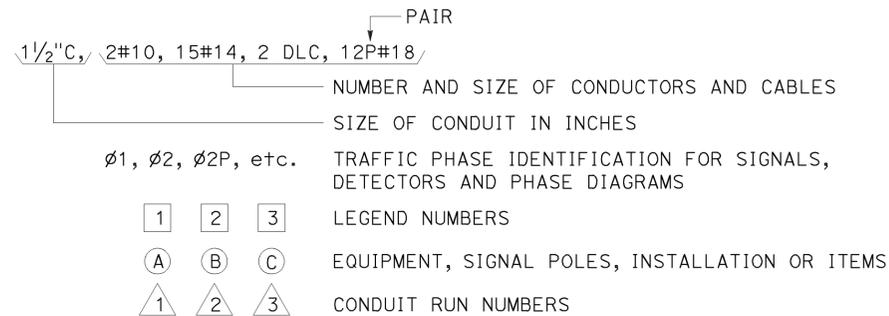


SIGNAL AND LIGHTING STANDARD (TYPICAL DESIGNATION):

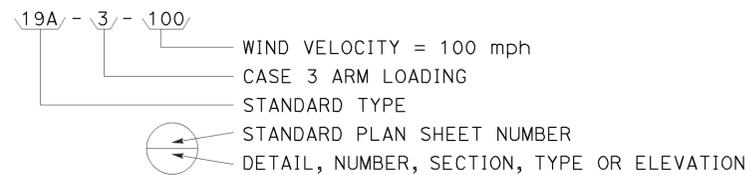


MISCELLANEOUS EQUIPMENT

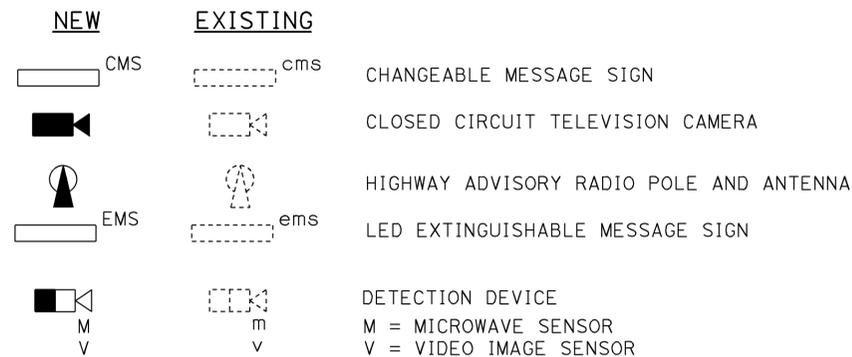



WIRING DIAGRAM LEGEND

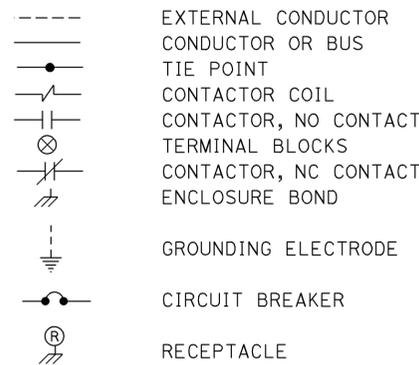

PULL BOXES

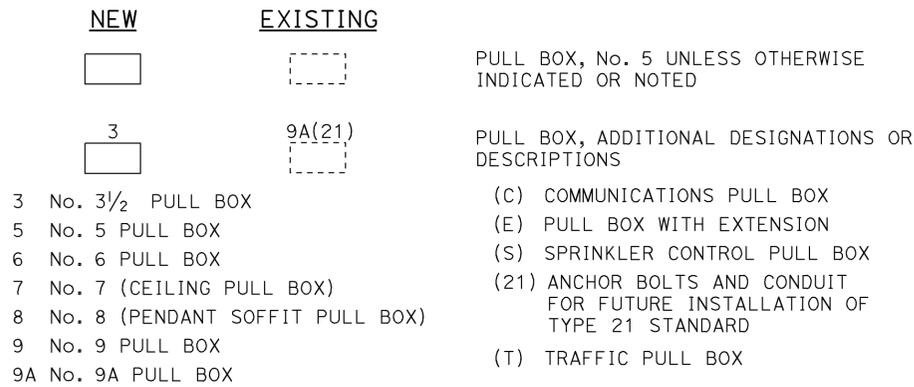

VEHICLE DETECTORS

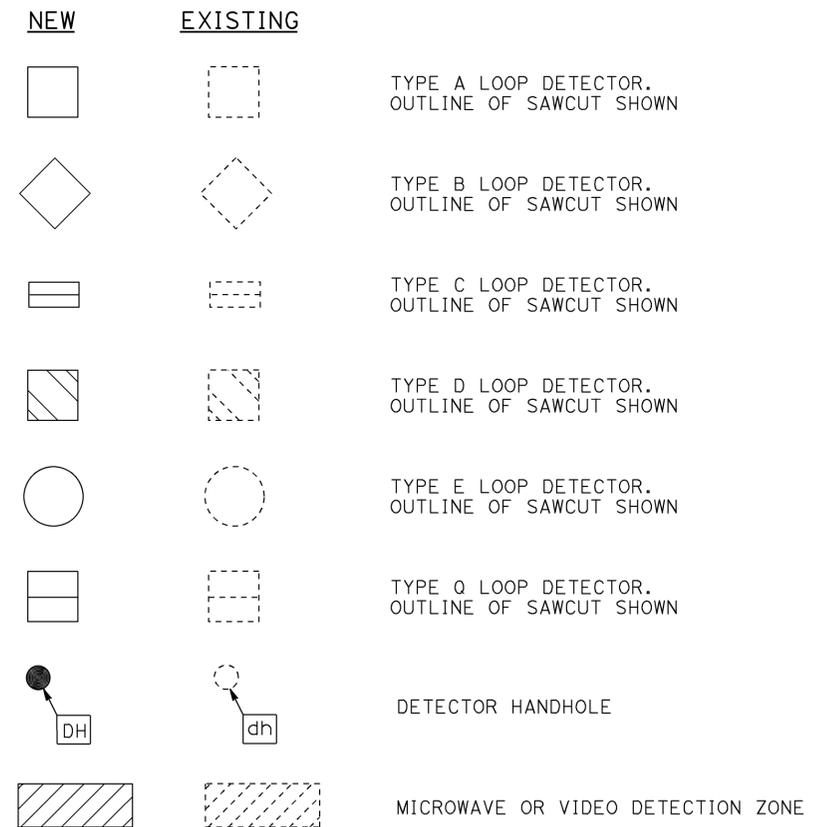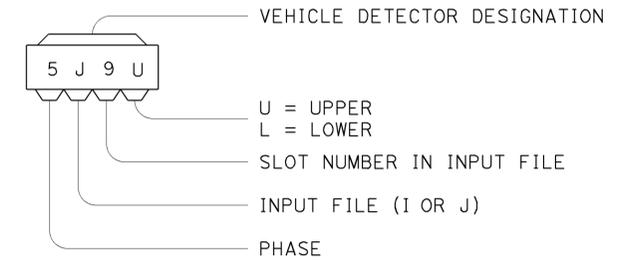

STATE OF CALIFORNIA
DEPARTMENT OF TRANSPORTATION

ELECTRICAL SYSTEMS (LEGEND AND ABBREVIATIONS)

NO SCALE

RSP ES-1C DATED OCTOBER 30, 2015 SUPERSEDES RSP ES-1C DATED JULY 19, 2013 AND STANDARD PLAN ES-1C DATED MAY 20, 2011 - PAGE 427 OF THE STANDARD PLANS BOOK DATED 2010.

REVISED STANDARD PLAN RSP ES-1C


2010 REVISED STANDARD PLAN RSP ES-1C

Dist	COUNTY	ROUTE	POST MILES TOTAL PROJECT	SHEET No.	TOTAL SHEETS
05	SB	101	2.2/3.3	499	786


Theresa Gabriel
 REGISTERED ELECTRICAL ENGINEER
 October 30, 2015
 PLANS APPROVAL DATE
 THE STATE OF CALIFORNIA OR ITS OFFICERS OR AGENTS SHALL NOT BE RESPONSIBLE FOR THE ACCURACY OR COMPLETENESS OF SCANNED COPIES OF THIS PLAN SHEET.





TO ACCOMPANY PLANS DATED 12-7-15

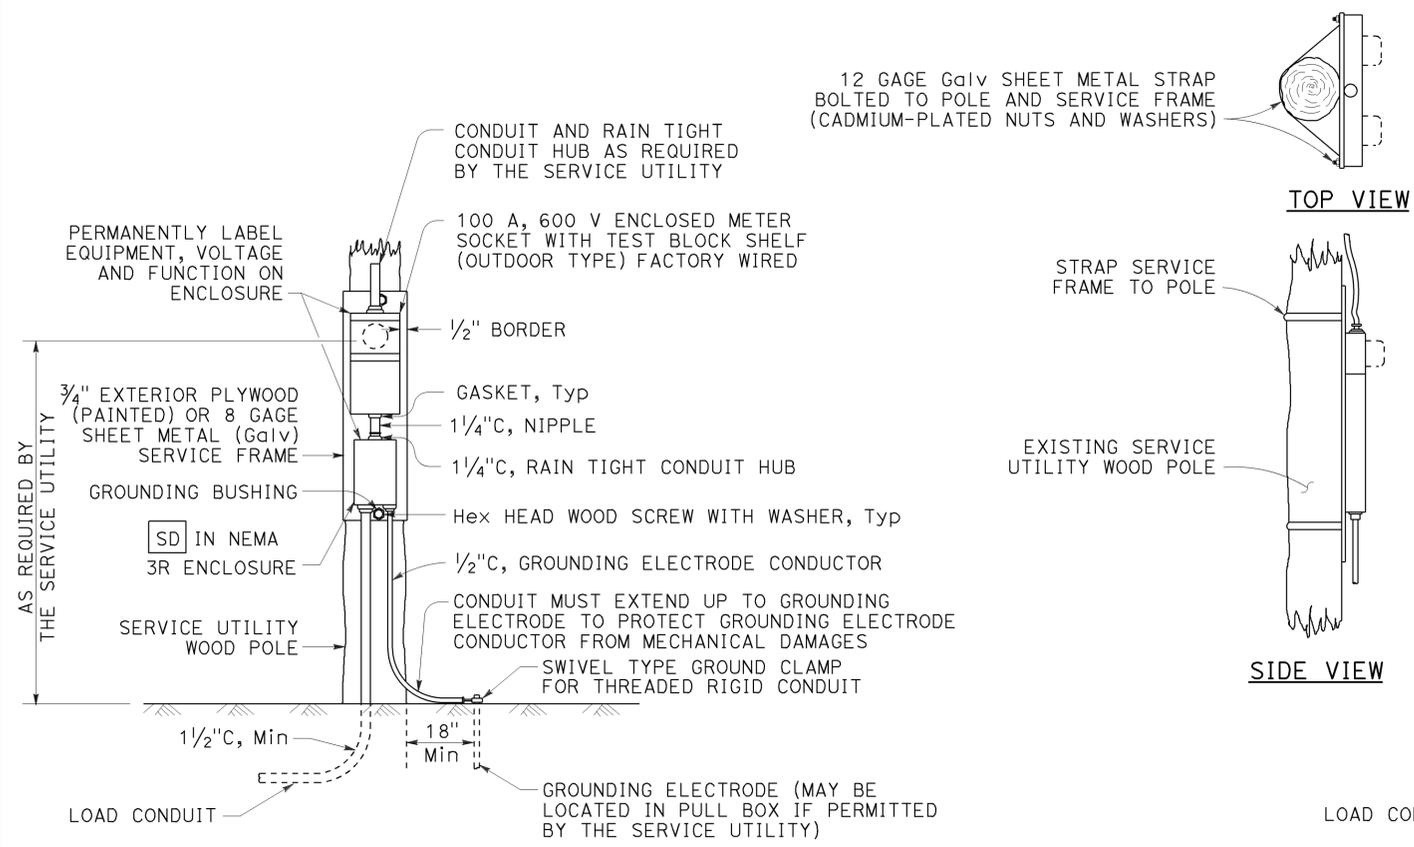

TYPE SCE-1
DETAIL A

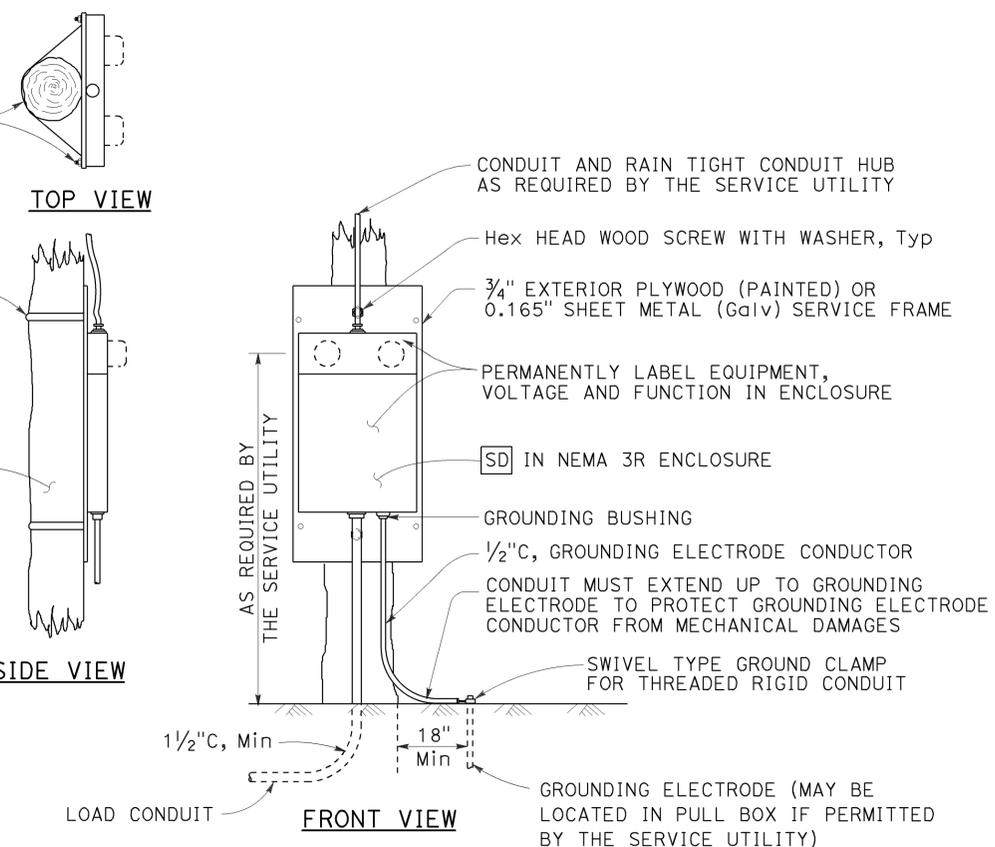


TYPE SCE-2
DETAIL B

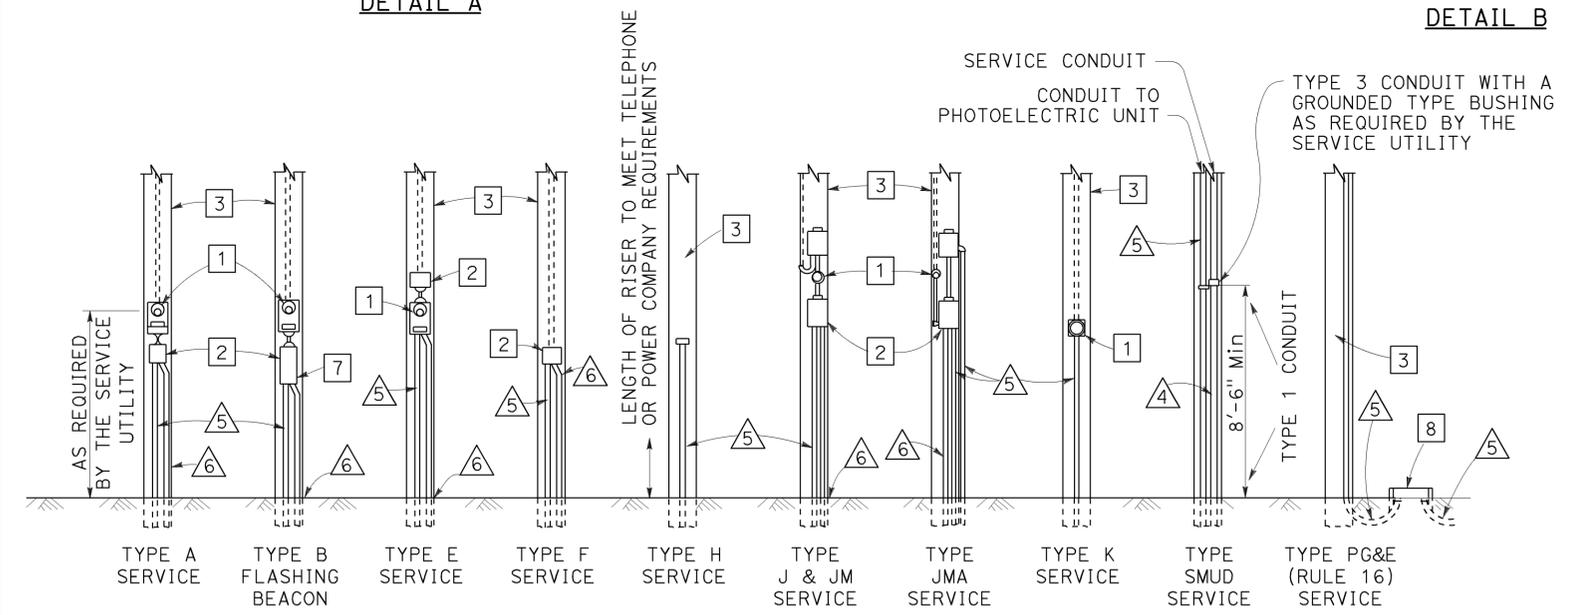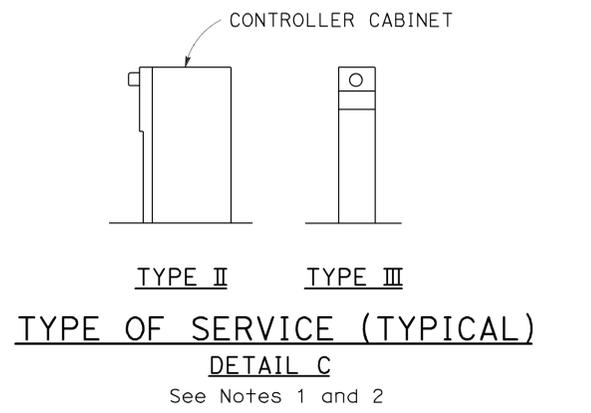

- LEGEND:**
- 1 METER SOCKET.
 - 2 SERVICE ENCLOSURE WITH A MINIMUM 60 A RATED MAIN CIRCUIT BREAKER, UNLESS OTHERWISE SHOWN.
 - 3 A. UTILITY OWNED POLE. THE SERVICE UTILITY WILL FURNISH AND INSTALL REQUIRED SERVICE RISER, PEU WITH CONDUCTORS AND OTHER EQUIPMENT AS NEEDED.
B. STATE OWNED POLE. THE CONTRACTOR SHALL FURNISH AND INSTALL REQUIRED SERVICE RISER AND EQUIPMENT.
 - 4 2" C, SERVICE CONDUIT MUST HAVE A GROUNDED TYPE BUSHING INSTALLED AT UPPER END OF THE METALLIC POLE RISER CONDUIT. A GROUNDING CONDUCTOR MUST BE ATTACHED TO THE BUSHING, CARRIED THROUGH THE CONDUIT RUN AND ATTACHED TO THE SERVICE EQUIPMENT ENCLOSURE'S GROUNDING ELECTRODE.
 - 5 CONDUIT, LENGTH AND SIZE AS REQUIRED.
 - 6 1/2" C, 1#6. SEE DETAIL E.
 - 7 FLASHING BEACON CONTROL ASSEMBLY.
 - 8 SERVICE PULL BOX, No. 5 UNLESS OTHERWISE NOTED, FURNISHED AND INSTALLED BY THE CONTRACTOR. SERVICE UTILITY SHALL DETERMINE THE EXACT LOCATION.

POLE MOUNTED SERVICE INSTALLATIONS
DETAIL D

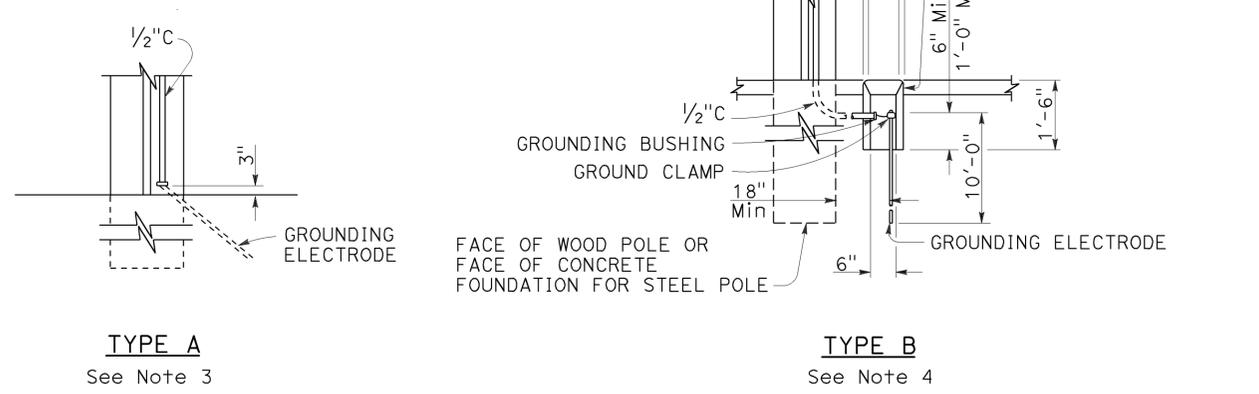

- NOTES:**
- Type II service equipment enclosure mounted on the side of a controller cabinet.
 - Type III complete free-standing service equipment enclosure.
 - Ground clamp and required fittings must be accessible. Conduit must extend to protect grounding electrode conductor from mechanical damage.
 - Use where service utility requires 18" clearance between grounding electrode and the pole or service equipment enclosure. Installation shown is for sidewalk or paved areas. In unpaved areas, omit special service pull box and locate ground clamp above ground or locate ground clamp in nearest pull box.

SERVICE GROUNDING
DETAIL E

STATE OF CALIFORNIA
 DEPARTMENT OF TRANSPORTATION
ELECTRICAL SYSTEMS
(SERVICE EQUIPMENT)
 NO SCALE

RSP ES-2A DATED OCTOBER 30, 2015 SUPERSEDES STANDARD PLAN ES-2A DATED MAY 20, 2011 - PAGE 428 OF THE STANDARD PLANS BOOK DATED 2010.

2010 REVISED STANDARD PLAN RSP ES-2A

Dist	COUNTY	ROUTE	POST MILES TOTAL PROJECT	SHEET No.	TOTAL SHEETS
05	SB	101	2.2/3.3	500	786

Theresa Gabriel
REGISTERED ELECTRICAL ENGINEER

October 30, 2015
PLANS APPROVAL DATE



THE STATE OF CALIFORNIA OR ITS OFFICERS OR AGENTS SHALL NOT BE RESPONSIBLE FOR THE ACCURACY OR COMPLETENESS OF SCANNED COPIES OF THIS PLAN SHEET.

TO ACCOMPANY PLANS DATED 12-7-15

NOTES:

1. The plan shows the approximate location of devices within the enclosure. Components may be rearranged, however, the "working" clearances within the service equipment enclosure shall be maintained.
2. In unpaved areas a raised portland cement concrete pad 2'-0" x 4" x width of foundation shall be constructed in front of new service equipment enclosure installation. Pad shall be set to elevation of foundation.
3. Plug-in circuit breakers may be mounted in the vertical or horizontal position. Cable-in/cable-out circuit breakers shall be mounted in the vertical position.
4. Type III-AF and Type III-BF service equipment enclosures shall have the meter viewing windows located on the front side of the service equipment enclosures.
5. Type III-AR and Type III-BR service equipment enclosure shall be similarly constructed as Type III-AF and Type III-BF respectively, except the meter viewing windows shall be located on the back side of the service equipment enclosures.

STATE OF CALIFORNIA
DEPARTMENT OF TRANSPORTATION

**ELECTRICAL SYSTEMS
(SERVICE EQUIPMENT ENCLOSURE
NOTES TYPE III SERIES)**

NO SCALE

RSP ES-2C DATED OCTOBER 30, 2015 SUPERSEDES STANDARD PLAN ES-2C DATED MAY 20, 2011 - PAGE 430 OF THE STANDARD PLANS BOOK DATED 2010.

REVISED STANDARD PLAN RSP ES-2C

2010 REVISED STANDARD PLAN RSP ES-2C