

Dist	COUNTY	ROUTE	POST MILES TOTAL PROJECT	SHEET No.	TOTAL SHEETS
11	SD	8,15,163	Var	101	131


Randell D. Hiatt
REGISTERED CIVIL ENGINEER

November 15, 2013
PLANS APPROVAL DATE


THE STATE OF CALIFORNIA OR ITS OFFICERS OR AGENTS SHALL NOT BE RESPONSIBLE FOR THE ACCURACY OR COMPLETENESS OF SCANNED COPIES OF THIS PLAN SHEET.




TO ACCOMPANY PLANS DATED 04-25-16

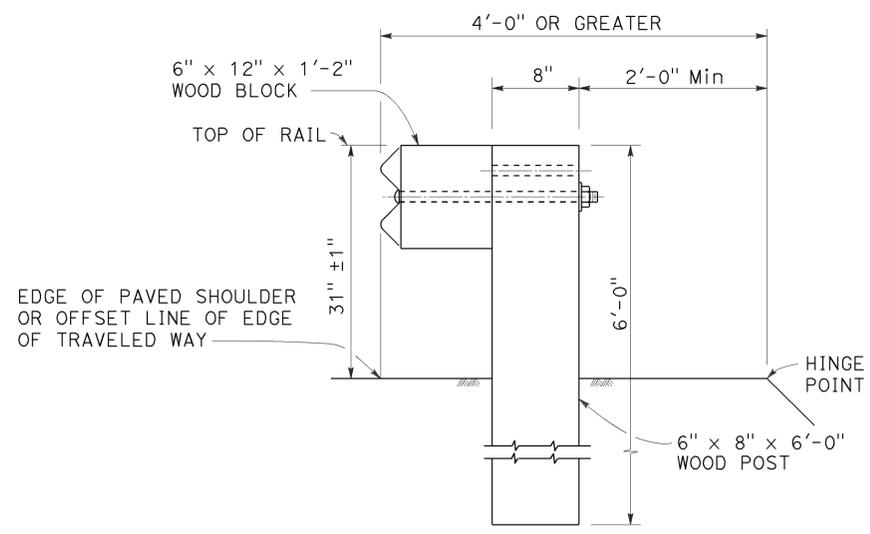


DETAIL A
TYPICAL ROADWAY
INSTALLATION
See Note 1

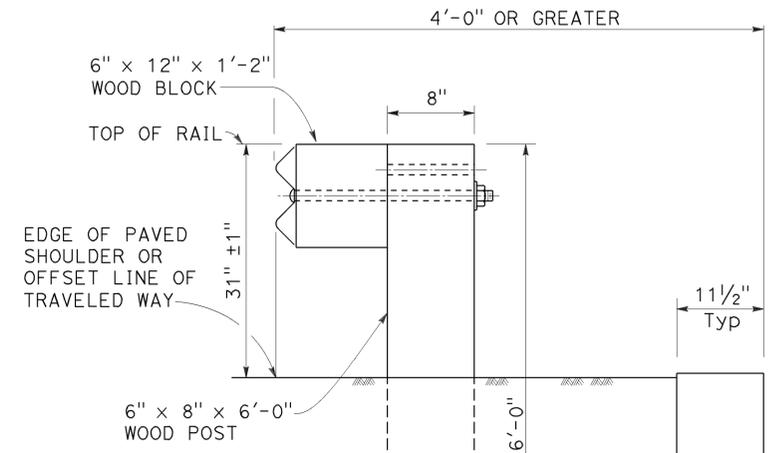

DETAIL C

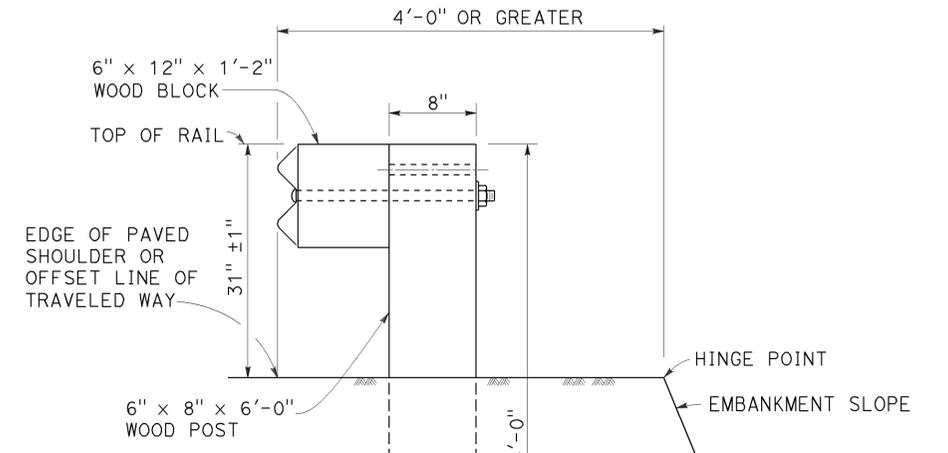

DETAIL D

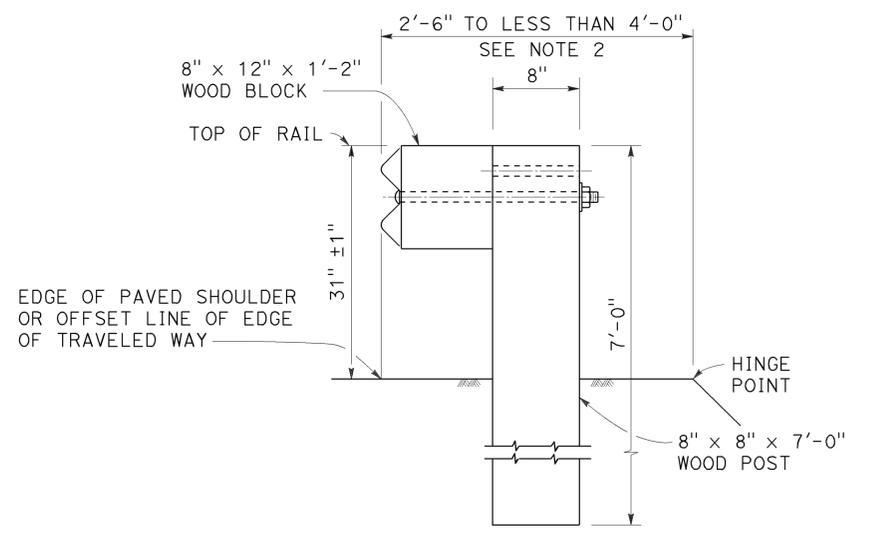

DETAIL B
NARROW ROADWAY
INSTALLATION
See Note 1

POST EMBEDMENT

INSTALLATION AT EARTH RETAINING WALLS

NOTES:

1. These installation details also applicable to steel line post installations. For Detail A, C, and D, where steel line post installations are constructed, W6 x 8.5 or W6 x 9 steel post, 6'-0" in length, with 6" x 12" x 1'-2" notched wood blocks or notched recycled plastic blocks are to be used in place of the size of wood post and wood block shown. For Detail B, where steel line post installations are constructed, W6 x 15 steel post, 8'-0" in length, with 8" x 12" x 1'-2" notched wood blocks or notched recycled plastic blocks are to be used in place of the size of wood post and wood block shown. For additional installation details, see Revised Standard Plan RSP A77L1 and RSP A77L2.
2. Where the distance between the face of the rail and the hinge point is less than 2'-6", see the Project Plans for special details.
3. For dike positioning with MGS installations, see Revised Standard Plan RSP A77N4.

STATE OF CALIFORNIA
DEPARTMENT OF TRANSPORTATION

MIDWEST GUARDRAIL SYSTEM
TYPICAL LINE POST
EMBEDMENT AND
HINGE POINT OFFSET DETAILS

NO SCALE

RSP A77N3 DATED NOVEMBER 15, 2013 SUPERSEDES RSP A77N3
DATED JULY 19, 2013 THAT SUPPLEMENTS THE STANDARD PLANS BOOK DATED 2010.

REVISED STANDARD PLAN RSP A77N3


2010 REVISED STANDARD PLAN RSP A77N3

Dist	COUNTY	ROUTE	POST MILES TOTAL PROJECT	SHEET No.	TOTAL SHEETS
11	SD	8,15,163	Var	102	131

Randell D. Hiatt
REGISTERED CIVIL ENGINEER

July 19, 2013
PLANS APPROVAL DATE


THE STATE OF CALIFORNIA OR ITS OFFICERS OR AGENTS SHALL NOT BE RESPONSIBLE FOR THE ACCURACY OR COMPLETENESS OF SCANNED COPIES OF THIS PLAN SHEET.

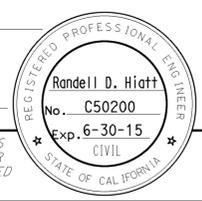


TO ACCOMPANY PLANS DATED 04-25-16

NOTES:

1. When necessary to place dike more than 7" in front of face of MGS, only Type C dike may be used. For dike details, see Revised Standard Plan RSP A87B.
2. For standard railing post embedment, see Revised Standard Plan RSP A77N3.
3. MGS delineation to be used where shown on the Project Plans.
4. When dike or curb is placed under MGS, the maximum height of the dike or curb shall be 6". Mountable dike should not be used. For dike and curb details, see Revised Standard Plans RSP A87A and RSP A87B.
5. For details of typical distance between the face of rail and hinge point, see Revised Standard Plan RSP A77N3.
6. For steel line posts, use 1/4" - 20 self-tapping screws in 0.22" diameter holes or 1/4" bolts in 3/32" diameter holes.

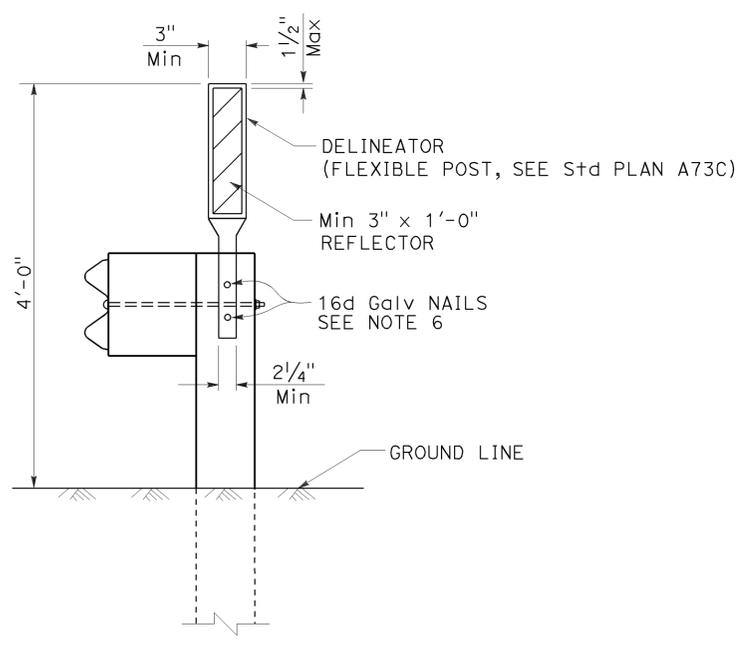

MGS DELINEATION
See Note 3

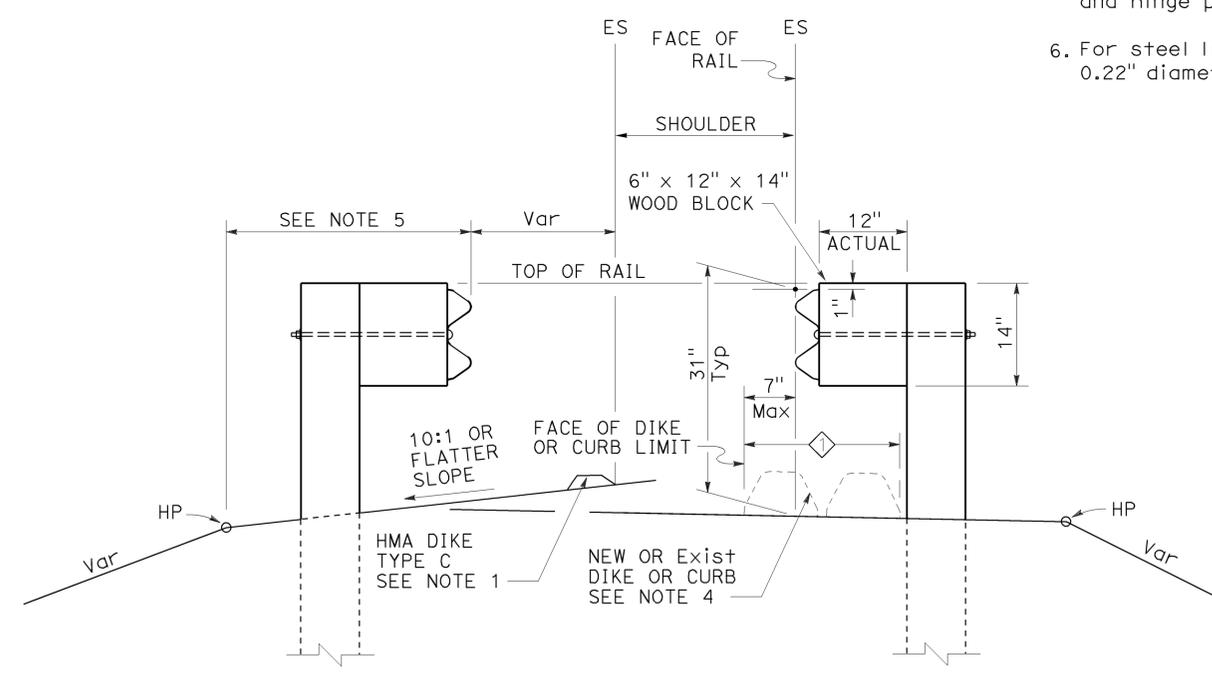

DIKE POSITIONING
See Note 1

◇ PERMISSIBLE DIKE OR CURB PLACEMENT AREA

STATE OF CALIFORNIA
DEPARTMENT OF TRANSPORTATION

**MIDWEST GUARDRAIL SYSTEM
TYPICAL RAILING DELINEATION
AND DIKE POSITIONING DETAILS**
NO SCALE

RSP A77N4 DATED JULY 19, 2013 SUPPLEMENTS THE STANDARD PLANS BOOK DATED 2010.

REVISED STANDARD PLAN RSP A77N4


2010 REVISED STANDARD PLAN RSP A77N4

Dist	COUNTY	ROUTE	POST MILES TOTAL PROJECT	SHEET No.	TOTAL SHEETS
11	SD	8,15,163	Var	103	131


Randell D. Hiatt
REGISTERED CIVIL ENGINEER

August 14, 2015
PLANS APPROVAL DATE

THE STATE OF CALIFORNIA OR ITS OFFICERS OR AGENTS SHALL NOT BE RESPONSIBLE FOR THE ACCURACY OR COMPLETENESS OF SCANNED COPIES OF THIS PLAN SHEET.

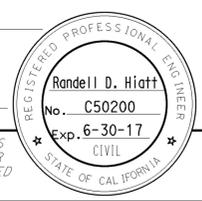


TO ACCOMPANY PLANS DATED 04-25-16

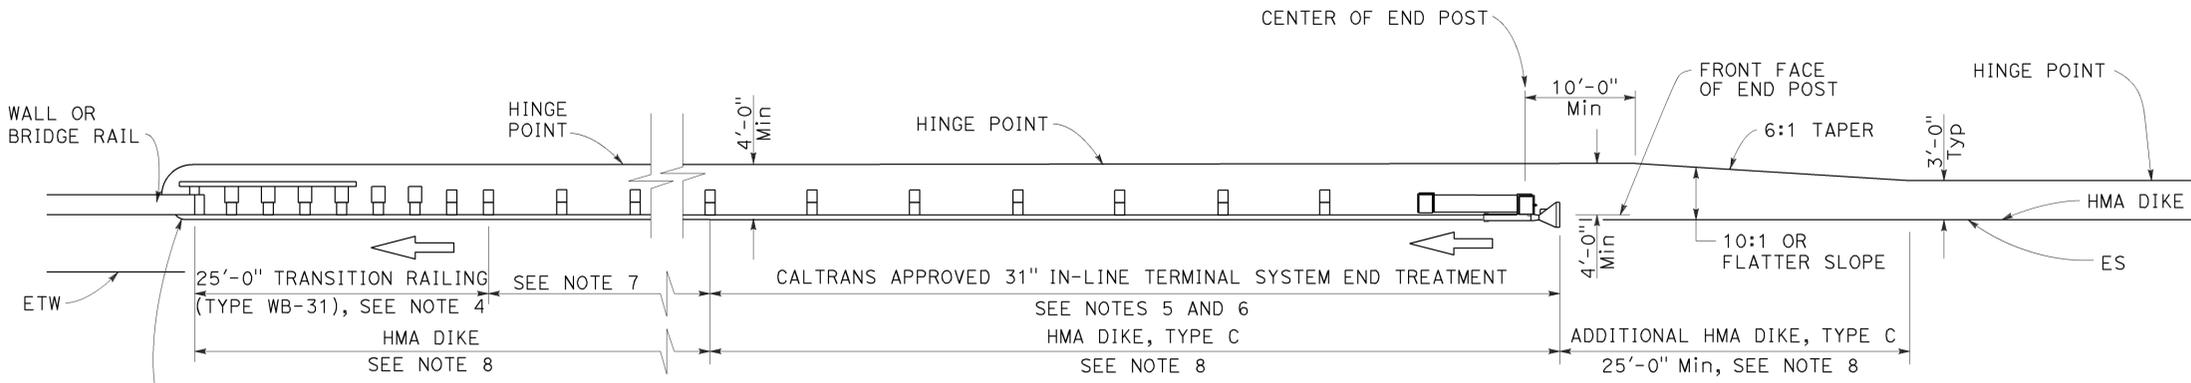

TYPE 12A LAYOUT

(MGS installation at structure approach with 31" in-line end treatment at traffic approach end of railing) See Note 9

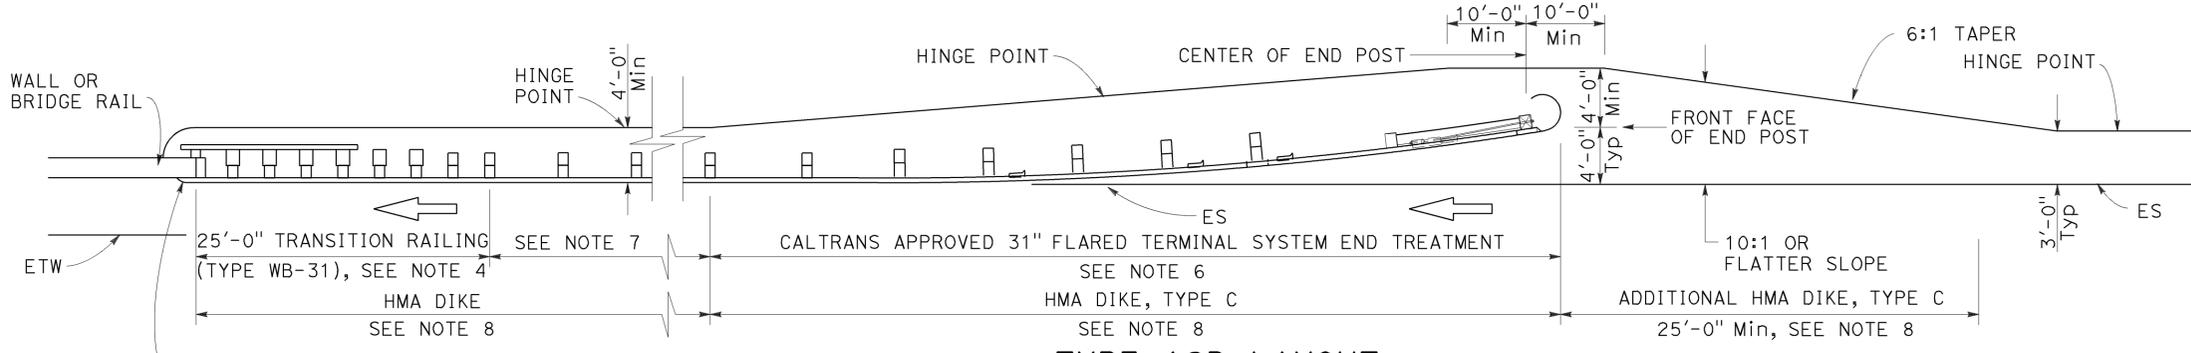

TYPE 12B LAYOUT

(MGS installation at structure approach with 31" Flared end treatment at traffic approach end of railing) See Note 9

NOTES:

- Line post, blocks and hardware to be used are shown on Revised Standard Plans RSP A77L1, RSP A77L2, RSP A77M1, RSP A77N1 and RSP A77N2.
- MGS post spacing to be 6'-3" center to center, except as otherwise noted.
- Except as noted, line posts are 6" x 8" x 6'-0" wood with 6" x 12" x 1'-2" wood blocks. W6 x 8.5 or W6 x 9 steel posts, 6'-0" in length, with 6" x 12" x 1'-2" notched wood blocks or plastic blocks may be used for 6" x 8" x 6'-0" wood posts with 6" x 12" x 1'-2" wood blocks where applicable and when specified.
- For Transition Railing (Type WB-31) details for Types 12A and 12B Layouts, see Revised Standard Plan RSP A77U4.
- 31" in-line terminal system end treatments are used where site conditions will not accommodate a 31" flared end treatment.
- The type of 31" terminal system end treatment to be used will be shown on the Project Plans.
- Dependent on site conditions (embankment height, side slopes, or other fixed objects), it may be advisable to construct additional guard railing (a length equal to multiples of 12'-6" with 6'-3" post spacing) between the transition railing and end treatment. A 12.5 degree angle of departure can be drawn on the Project Plans from the edge of traveled way through the outer most point of the fixed object to determine the additional length of railing needed.
- Where placement of dike is required with guard railing installations, see Revised Standard Plan RSP A77N4 for dike positioning details.
- Type 12A or Type 12B Layouts are typically used:
 - To the right of approaching traffic, at the end of a structure, on two-lane conventional highway where the roadbed width across the structure is less than 40 feet.
 - To the left of approaching traffic, at the end of a structure, on two-lane conventional highway where the roadbed width across the structure is less than 40 feet.
 - To the right of approaching traffic at the end of each structure on multilane freeways or expressways with separate adjacent or parallel bridges.
 - To the right of approaching traffic at the end of the structure on multilane freeways or expressways with decked median on the bridge.
- See Revised Standard Plan RSP A77Q3 for typical layout used left of approaching traffic at the ends of each structure on multilane freeways or expressways with separate adjacent or parallel bridges.
- For additional details of typical connections to bridge rail, see Connection Detail AA on Revised Standard Plans RSP A77U1 and RSP A77U2 and Connection Detail FF on Revised Standard Plans RSP A77V1 and RSP A77V2.
- For additional details of a typical connection to walls or abutments, see Revised Standard Plan RSP A77U3.

STATE OF CALIFORNIA
DEPARTMENT OF TRANSPORTATION

**MIDWEST GUARDRAIL SYSTEM
TYPICAL LAYOUTS FOR
STRUCTURE APPROACH**

NO SCALE

RSP A77Q1 DATED AUGUST 14, 2015 SUPERSEDES RSP A77Q1 DATED JULY 19, 2013 THAT SUPPLEMENTS THE STANDARD PLANS BOOK DATED 2010.

REVISED STANDARD PLAN RSP A77Q1

2010 REVISED STANDARD PLAN RSP A77Q1


DIST	COUNTY	ROUTE	POST MILES TOTAL PROJECT	SHEET No.	TOTAL SHEETS
11	SD	8,15,163	Var	104	131

Randell D. Hiatt
REGISTERED CIVIL ENGINEER


November 15, 2013
PLANS APPROVAL DATE

THE STATE OF CALIFORNIA OR ITS OFFICERS OR AGENTS SHALL NOT BE RESPONSIBLE FOR THE ACCURACY OR COMPLETENESS OF SCANNED COPIES OF THIS PLAN SHEET.


TO ACCOMPANY PLANS DATED 04-25-16

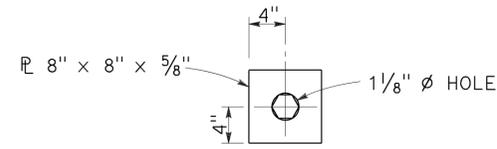


DETAIL "A"
CABLE CONNECTION
END PLATE

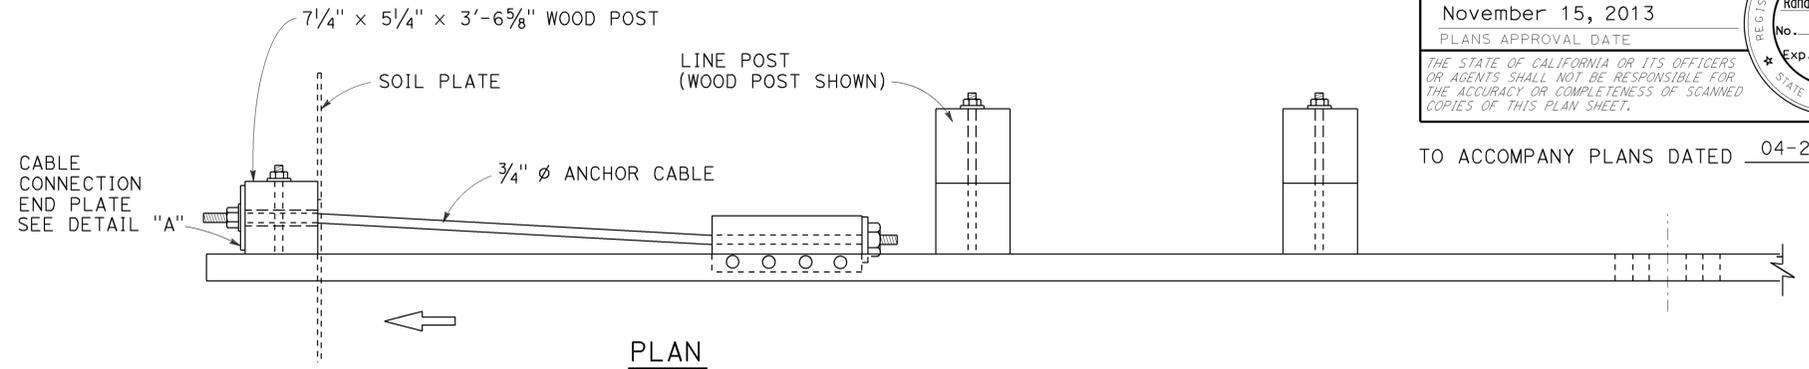

PLAN

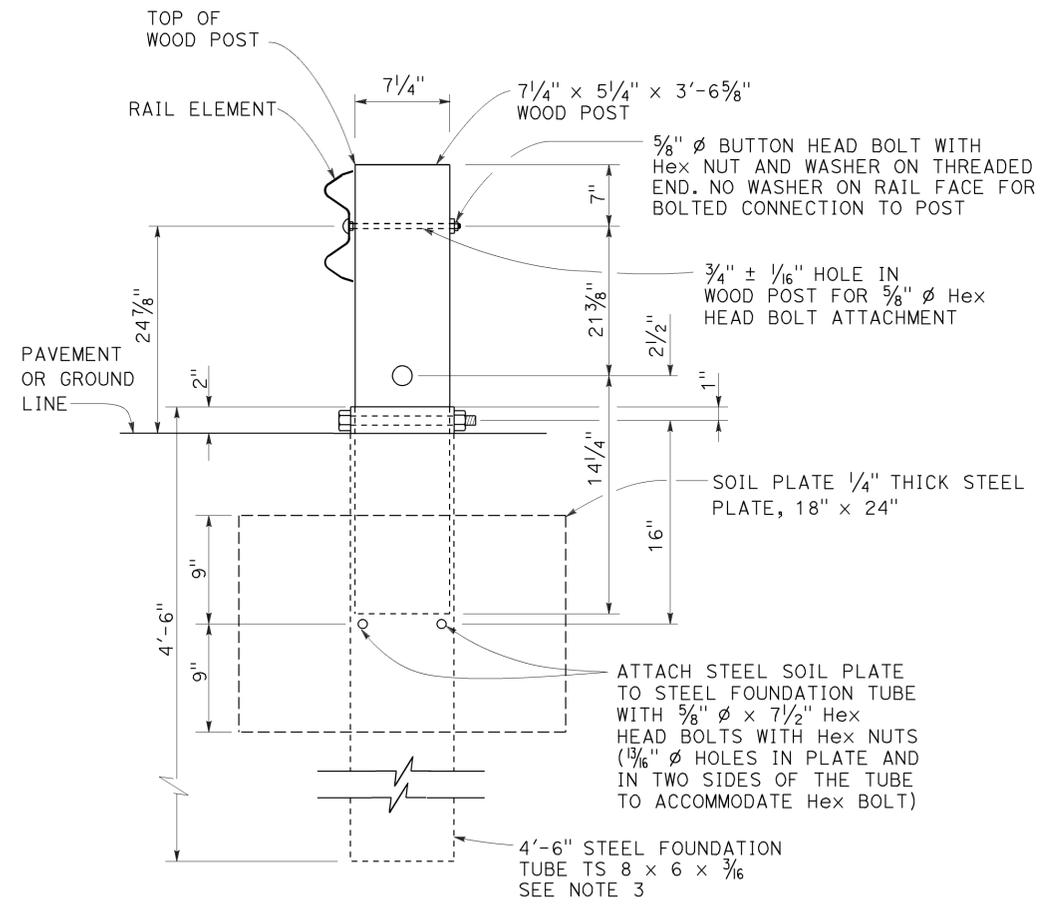

SECTION A-A

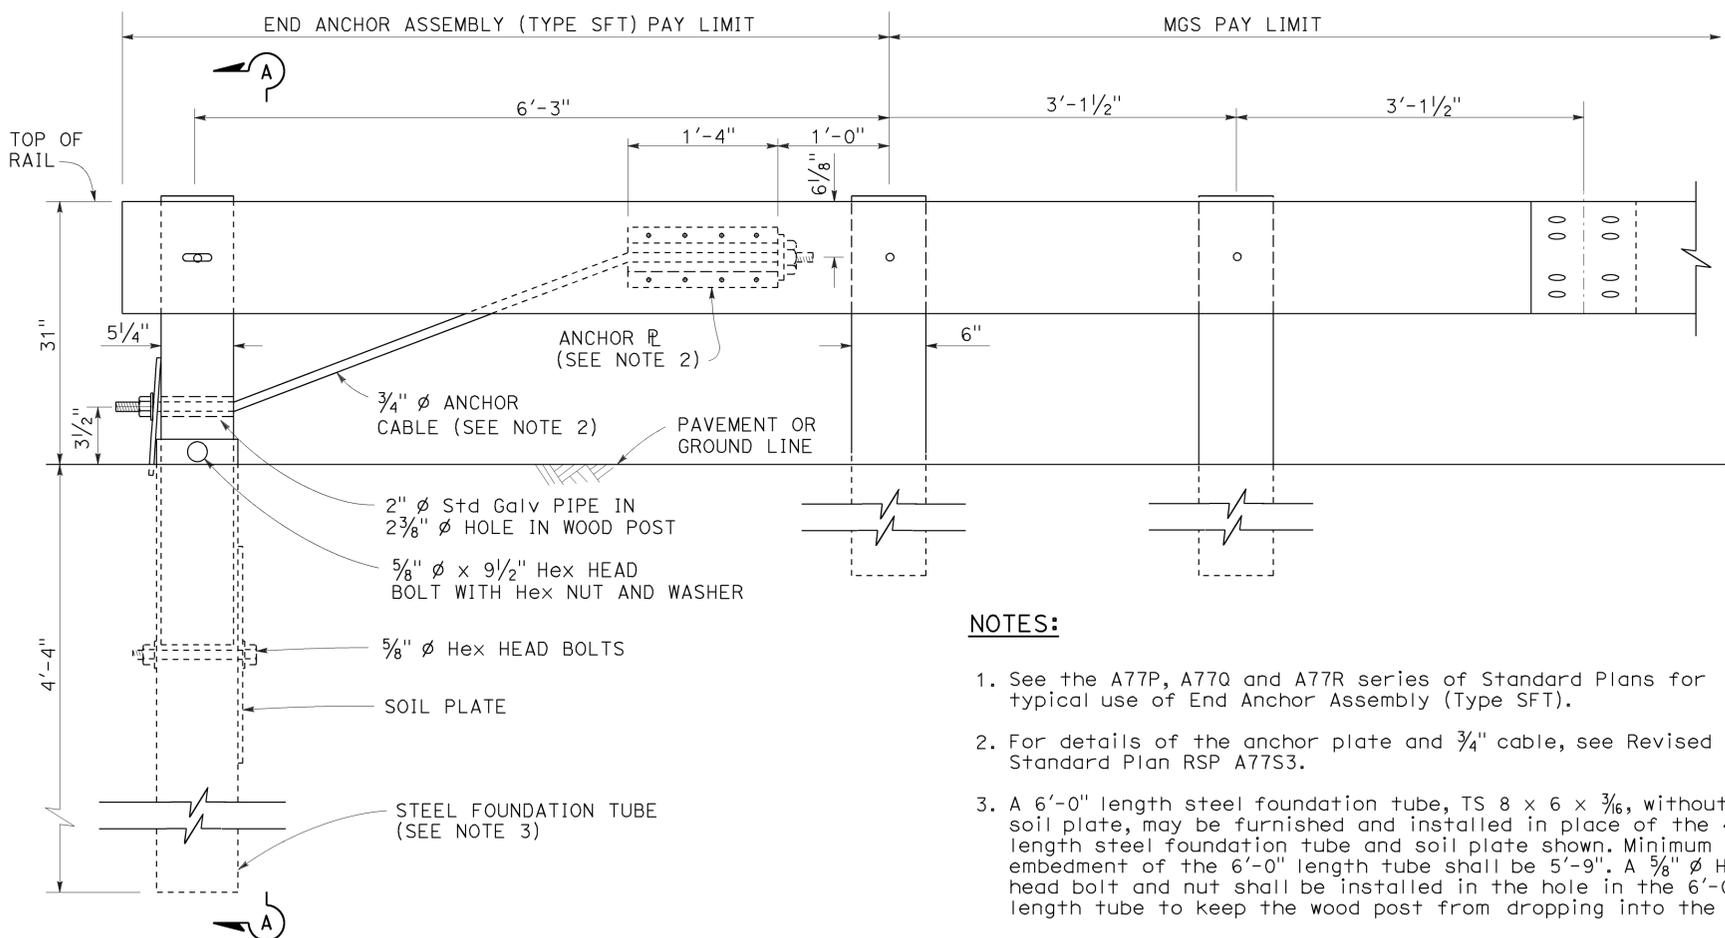

ELEVATION

END ANCHOR
ASSEMBLY (TYPE SFT)
See Note 1

NOTES:

1. See the A77P, A77Q and A77R series of Standard Plans for typical use of End Anchor Assembly (Type SFT).
2. For details of the anchor plate and 3/4" cable, see Revised Standard Plan RSP A77S3.
3. A 6'-0" length steel foundation tube, TS 8 x 6 x 3/16, without a soil plate, may be furnished and installed in place of the 4'-6" length steel foundation tube and soil plate shown. Minimum embedment of the 6'-0" length tube shall be 5'-9". A 5/8" diameter Hex head bolt and nut shall be installed in the hole in the 6'-0" length tube to keep the wood post from dropping into the tube.
4. Install line post, steel foundation tube and soil plate in soil.

STATE OF CALIFORNIA
DEPARTMENT OF TRANSPORTATION
MIDWEST GUARDRAIL SYSTEM
END ANCHOR ASSEMBLY
(TYPE SFT)

NO SCALE

RSP A77S1 DATED NOVEMBER 15, 2013 SUPERSEDES RSP A77S1
DATED JULY 19, 2013 THAT SUPPLEMENTS THE STANDARD PLANS BOOK DATED 2010.


REVISED STANDARD PLAN RSP A77S1

2010 REVISED STANDARD PLAN RSP A77S1

Dist	COUNTY	ROUTE	POST MILES TOTAL PROJECT	SHEET No.	TOTAL SHEETS
11	SD	8,15,163	Var	105	131




RANDALL D. HIATT
 REGISTERED CIVIL ENGINEER
 July 19, 2013
 PLANS APPROVAL DATE
 THE STATE OF CALIFORNIA OR ITS OFFICERS OR AGENTS SHALL NOT BE RESPONSIBLE FOR THE ACCURACY OR COMPLETENESS OF SCANNED COPIES OF THIS PLAN SHEET.

TO ACCOMPANY PLANS DATED 04-25-16

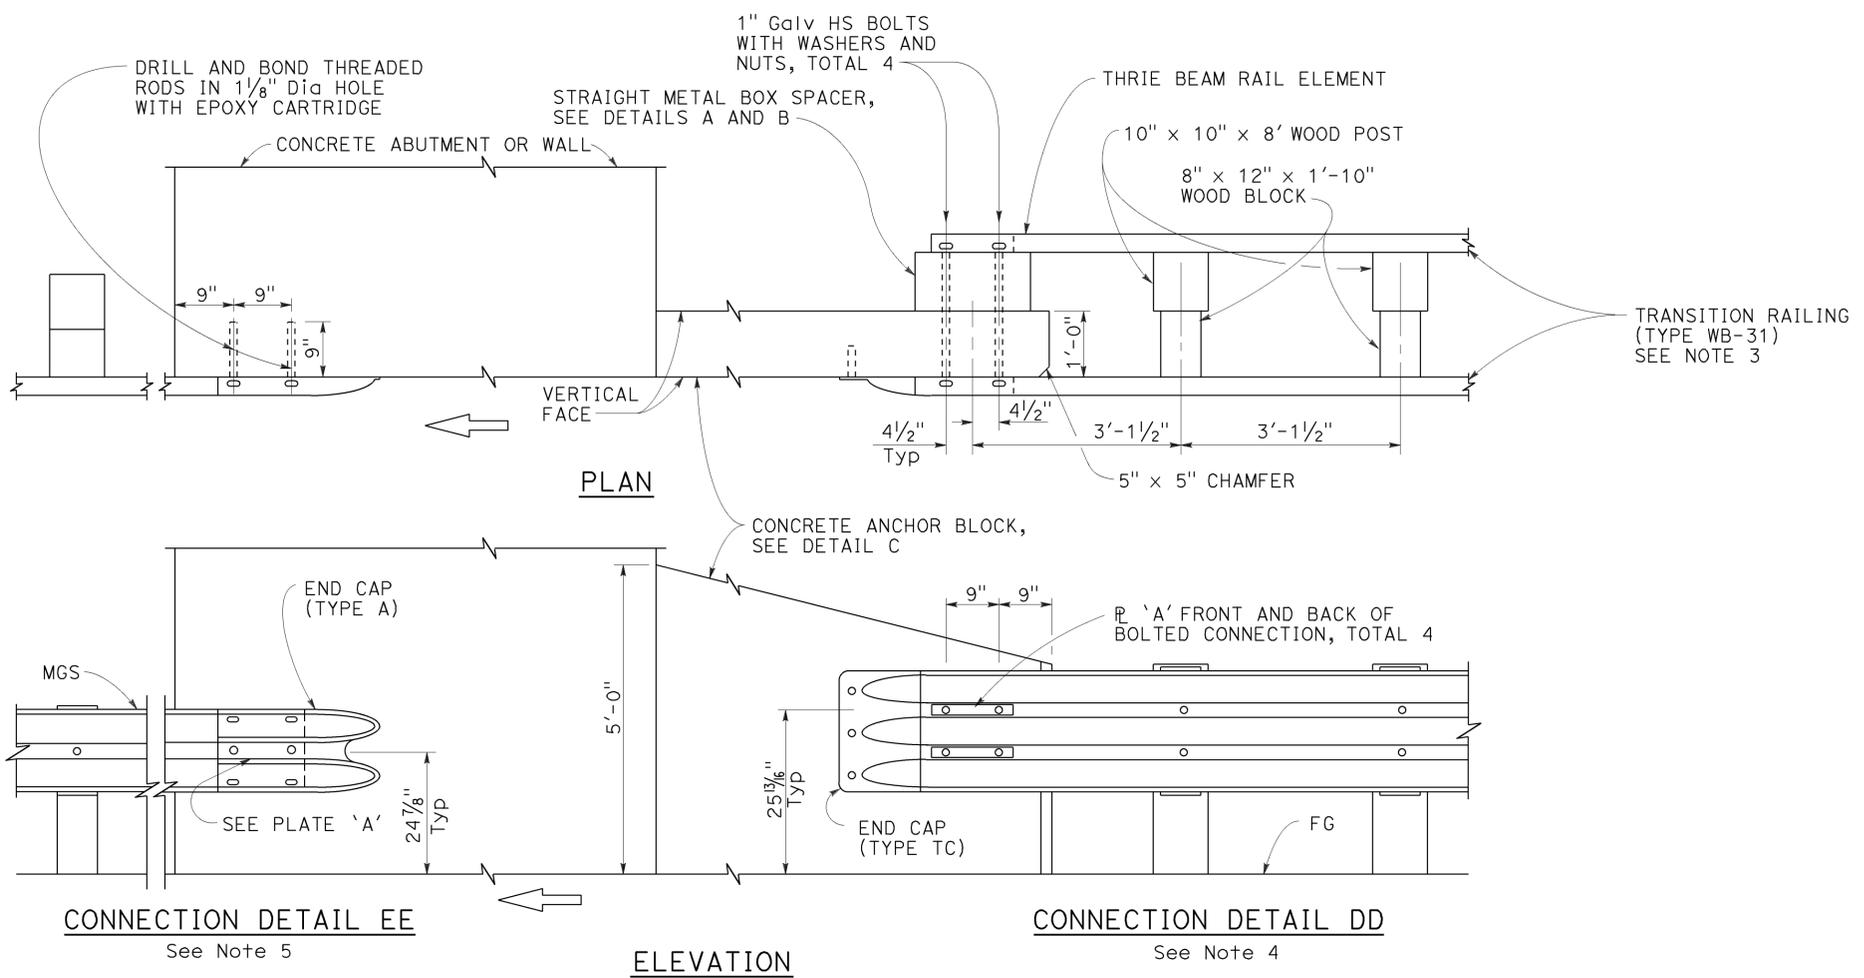

NOTES:

1. These connection details apply to abutments and walls.
2. Additional details of posts, blocks and hardware are shown on Revised Standard Plans RSP A77M1, RSP A77N1 and RSP A77N2.
3. For additional details of Transition Railing (Type WB-31), see Revised Standard Plan RSP A77U4. Transition Railing (Type WB-31) transitions the 12 gauge MGS railing section to a heavier gage nested thrie beam railing section which is connected to the concrete anchor block.
4. For typical use of Connection Details DD, see Layout Types 12A and 12B on Revised Standard Plan RSP A77Q1 and Layout Types 12C and 12D on Revised Standard Plan RSP A77Q2.
5. For typical use of Connection Detail EE, see Layout Type 12D on Revised Standard Plan RSP A77Q2 and Layout Type 12DD on Revised Standard Plan RSP A77Q5.

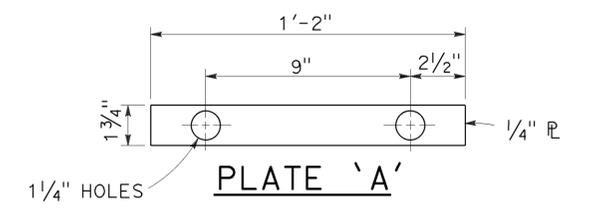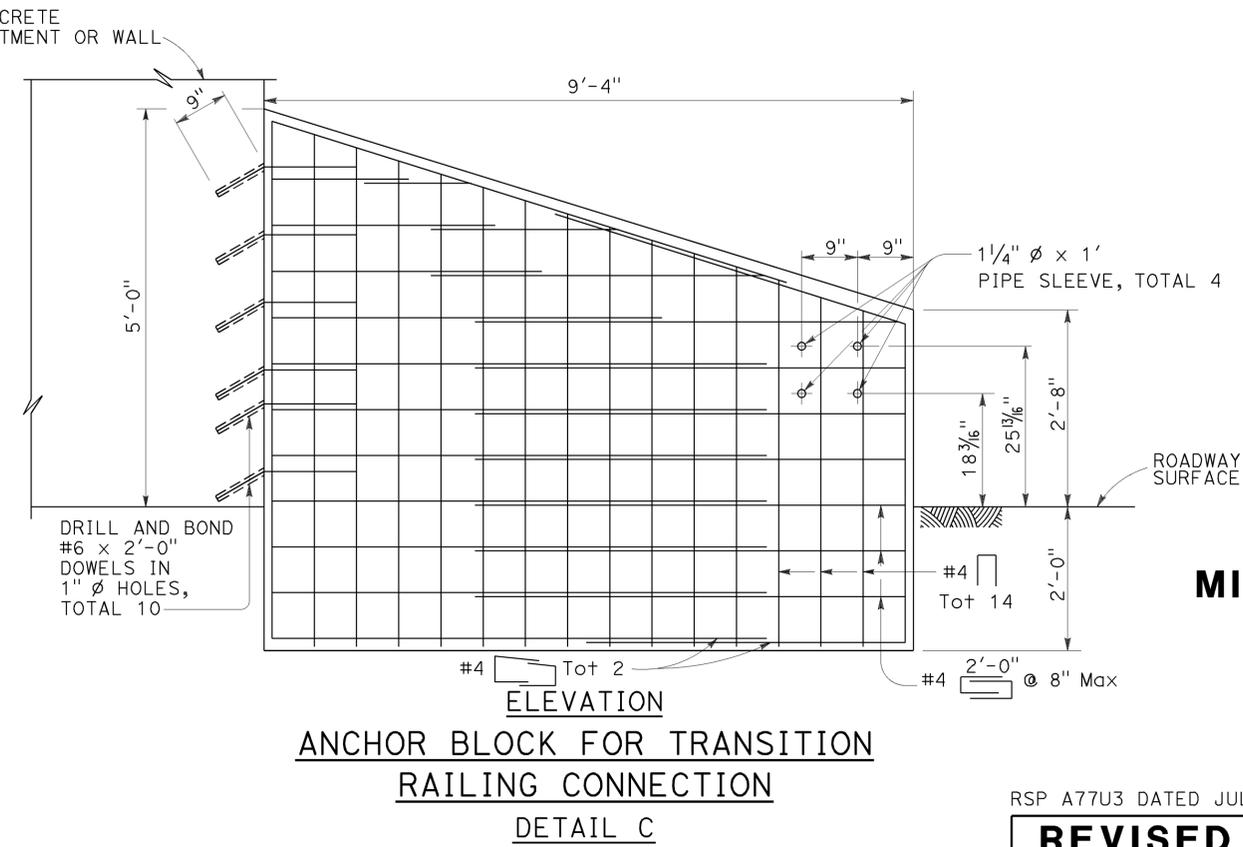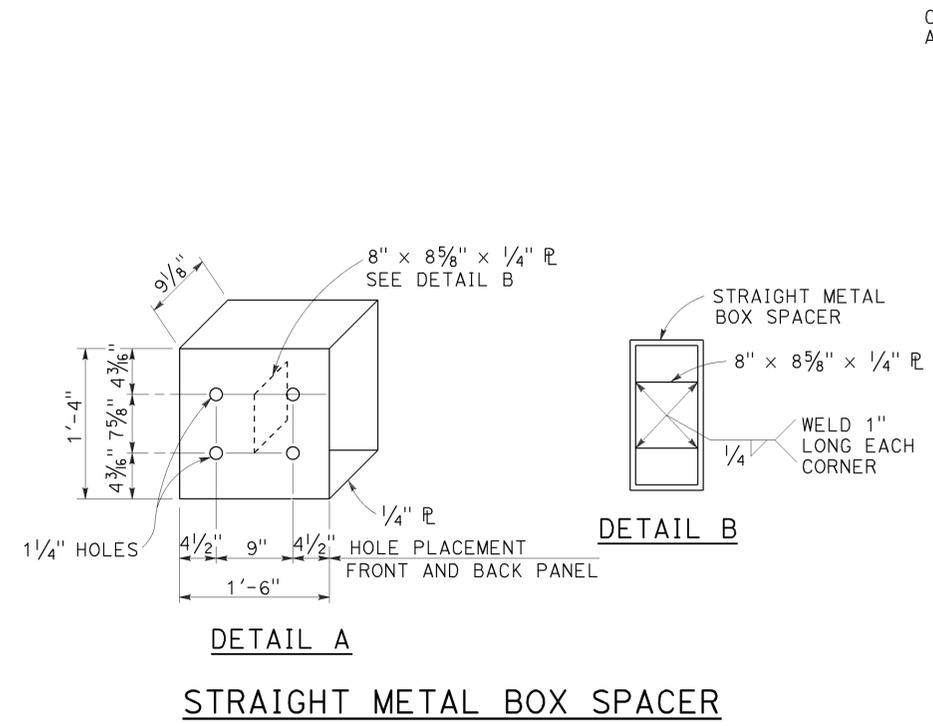

STATE OF CALIFORNIA
DEPARTMENT OF TRANSPORTATION
MIDWEST GUARDRAIL SYSTEM CONNECTIONS TO ABUTMENTS AND WALLS
NO SCALE

RSP A77U3 DATED JULY 19, 2013 SUPPLEMENTS THE STANDARD PLANS BOOK DATED 2010.

REVISED STANDARD PLAN RSP A77U3

2010 REVISED STANDARD PLAN RSP A77U3






Dist	COUNTY	ROUTE	POST MILES TOTAL PROJECT	SHEET No.	TOTAL SHEETS
11	SD	8,15,163	Var	106	131

Randell D. Hiatt
REGISTERED CIVIL ENGINEER



January 23, 2015
PLANS APPROVAL DATE

THE STATE OF CALIFORNIA OR ITS OFFICERS OR AGENTS SHALL NOT BE RESPONSIBLE FOR THE ACCURACY OR COMPLETENESS OF SCANNED COPIES OF THIS PLAN SHEET.

REGISTERED PROFESSIONAL ENGINEER
No. C50200
Exp. 6-30-15
CIVIL
STATE OF CALIFORNIA

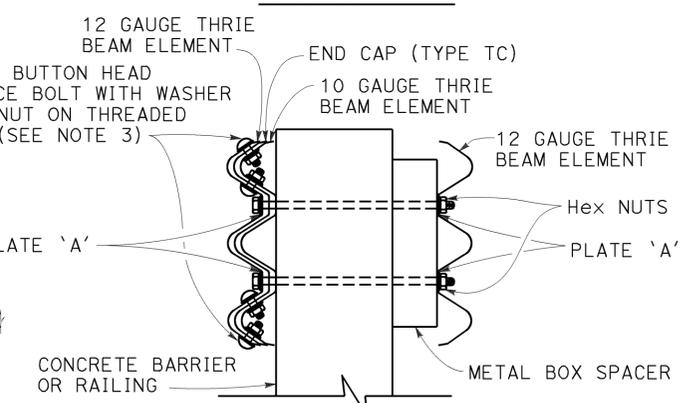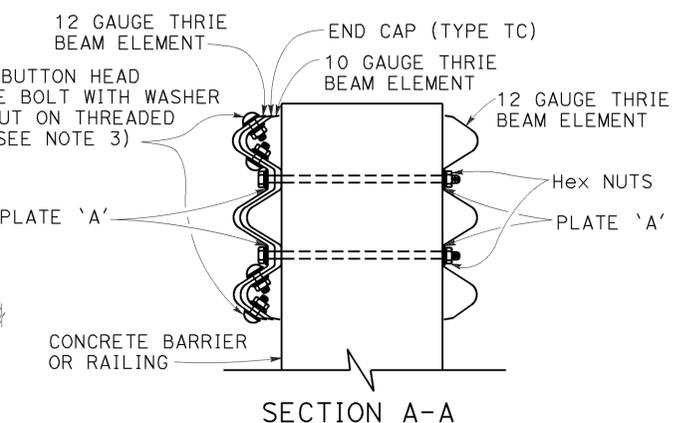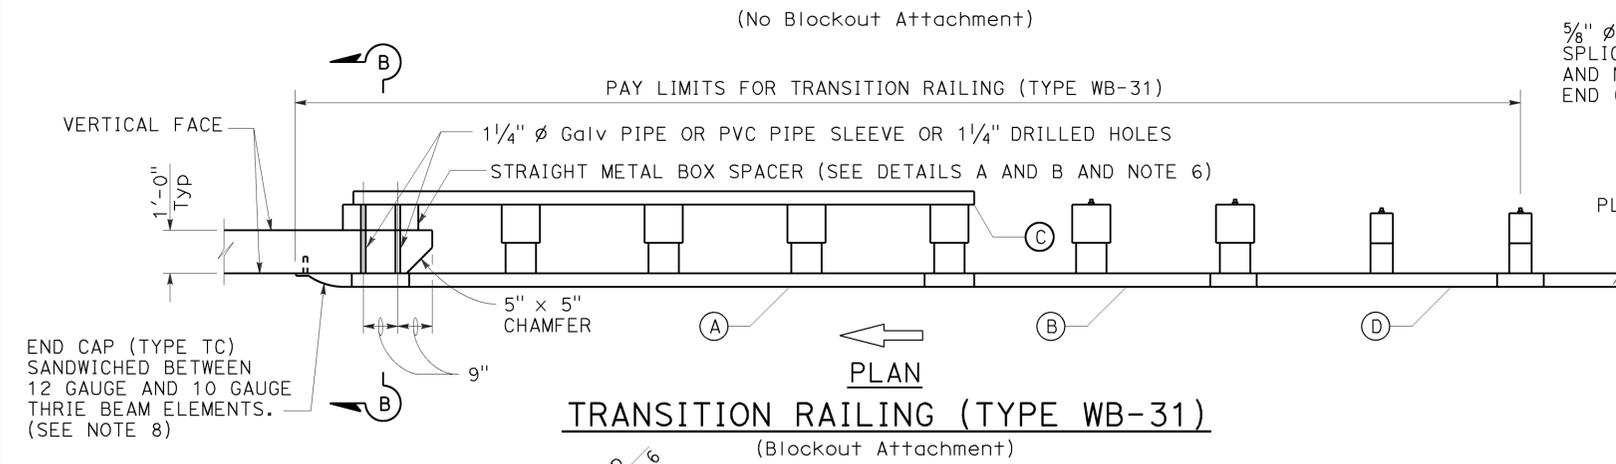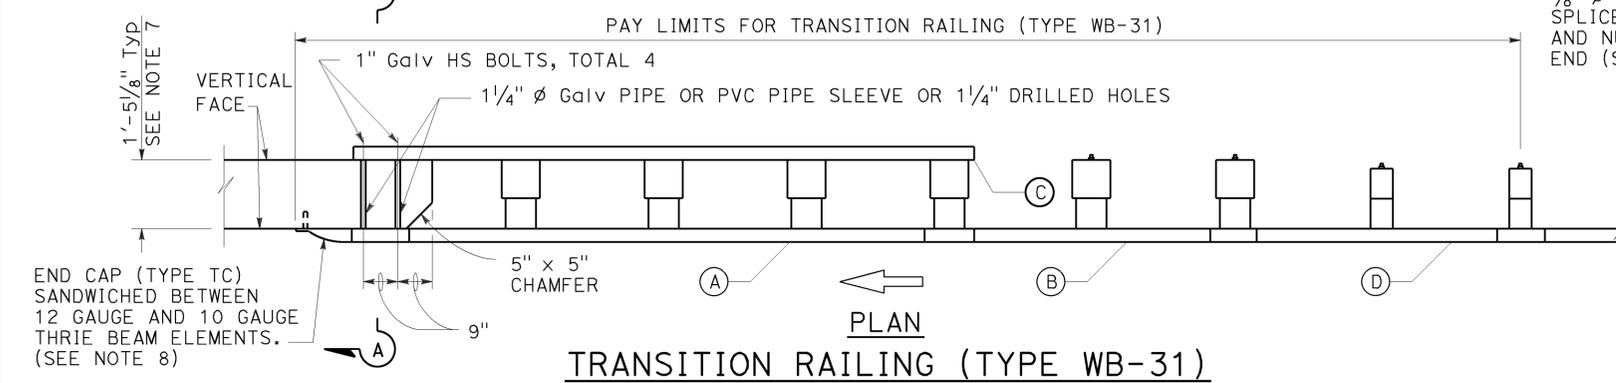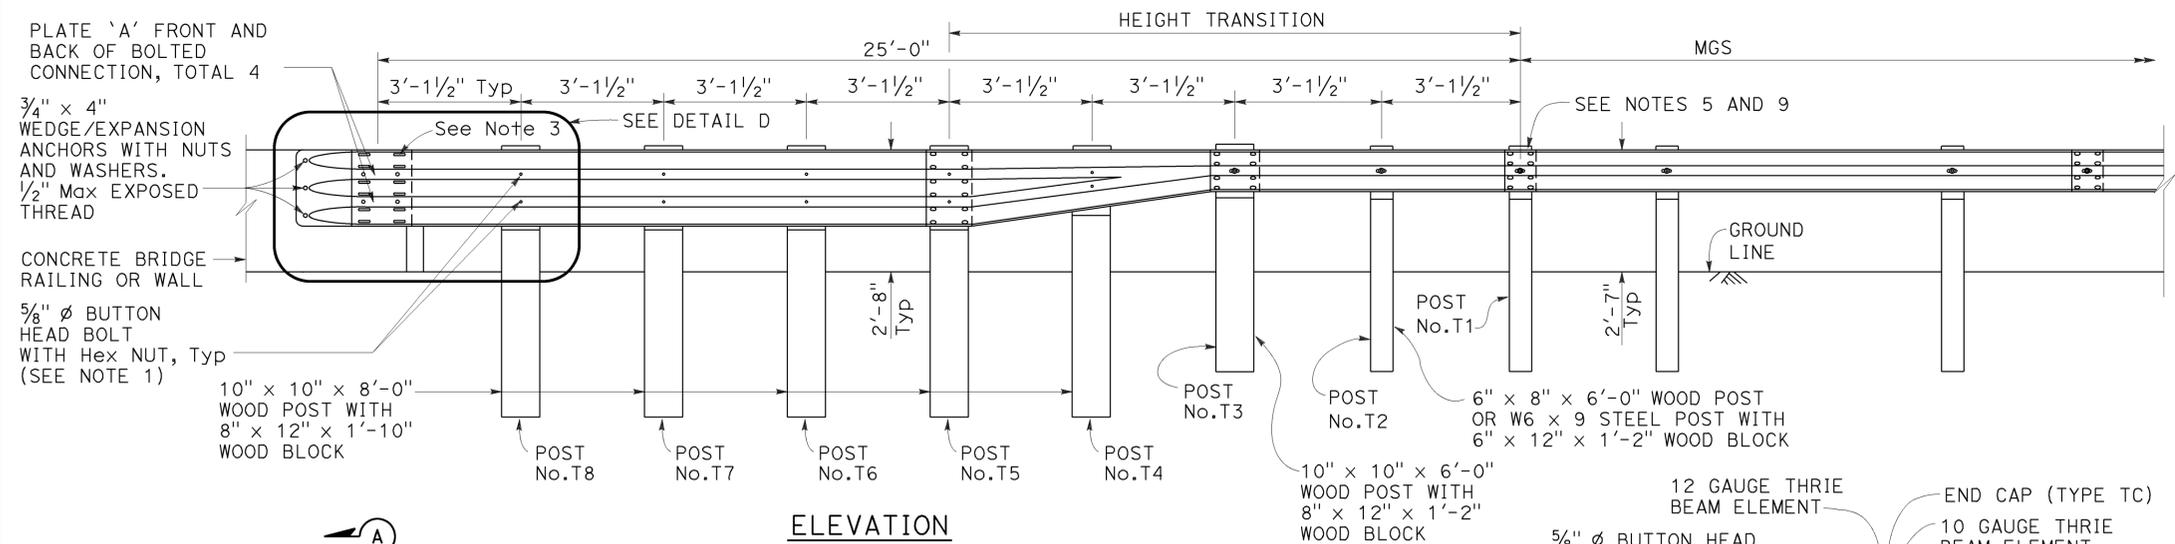

- LEGEND:**
- (A) NESTED THRIE BEAM ELEMENTS (ONE 12 GAUGE ELEMENT NESTED OVER ONE 10 GAUGE ELEMENT).
 - (B) ONE ASYMMETRICAL 10 GAUGE "W" BEAM TO THRIE BEAM ELEMENT.
 - (C) ONE 12 GAUGE THRIE BEAM ELEMENT.
 - (D) ONE 10 GAUGE "W" BEAM RAIL ELEMENT (7'-3/2" LENGTH)
- 10 GAUGE = 0.138" THICK
12 GAUGE = 0.108" THICK

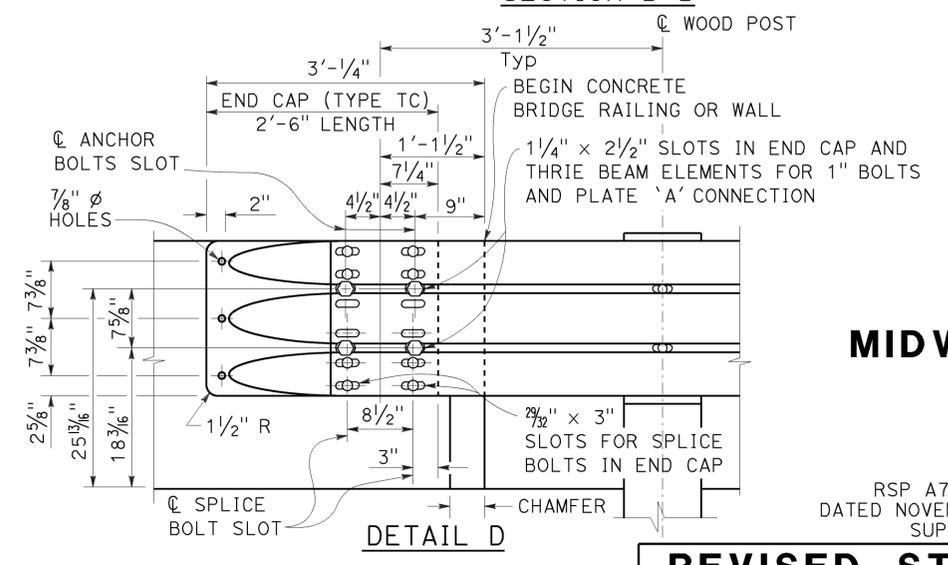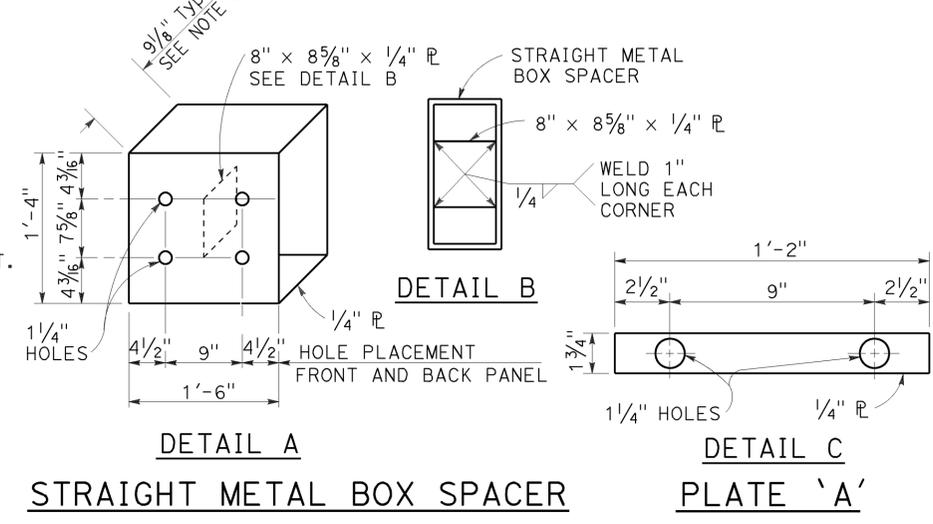

- NOTES:** TO ACCOMPANY PLANS DATED 04-25-16
1. Use 5/8" Ø Button head bolts and hex nuts for connections to posts. No washer on rail face for bolted connections to post.
 2. The nested rail elements, end cap, and "W" beam to thrie beam element may be spliced together prior to bolting the elements to the wood post and concrete barrier or railing.
 3. Exterior splice bolt holes for rail element splices at Post No. T5 and the connection to the concrete barrier or railing shall be the standard 29/32" x 1 1/8" slot size. Interior splice bolt holes at these locations may be increased up to 1 1/4" Ø. Only the top 4 and the bottom 4 splice bolts with washers and nuts are required for rail splices at Post No. T5 and the connection to the concrete barrier or railing.
 4. The top elevation of Posts No. T2 through No. T7 shall not project more than 1" above the top elevation of the rail element.
 5. Typically, the railing connected to Transition Railing (Type WB-31) will be either standard railing section of MGS with height transition ratio of 150:1 or a Caltrans approved 31" end treatment attached to Post No. T1.
 6. The depth of the metal box spacer varies from the 9/8" to 1 1/2" and is dependent on the width of the concrete railing or wall. The combined dimension for the depth of the metal box spacer plus the width of railing or wall is typically 21 1/8". Where the space between the backside of the concrete railing or wall and the rear thrie beam element is less than 1 1/2", metal plates similar to Plate 'A' are to be used as spacers.
 7. Where the width of the concrete railing or wall is greater than 17 1/8", wood blocks are to be used to fill the space created between the backside of Posts No. T5 through No. T8 and the rear thrie beam element. These wood blocks shall be 8" in width and 1'-2" in length. The dimension between the front thrie beam element and the rear thrie beam element is to match the width of the concrete railing or wall.
 8. End cap may be installed over 12 gauge and 10 gauge thrie beam elements where transition railing is installed on the departure end of bridge railing.
 9. Conform standard railing section height to 31" at Post No. T1 using height transition ratio of 150:1.

STATE OF CALIFORNIA
DEPARTMENT OF TRANSPORTATION

**MIDWEST GUARDRAIL SYSTEM
TRANSITION RAILING
(TYPE WB-31)**


NO SCALE

RSP A77U4 DATED JANUARY 23, 2015 SUPERSEDES RSP A77U4 DATED NOVEMBER 15, 2013 AND RSP A77U4 DATED JULY 19, 2013 THAT SUPPLEMENTS THE STANDARD PLANS BOOK DATED 2010.


REVISED STANDARD PLAN RSP A77U4

2010 REVISED STANDARD PLAN RSP A77U4


TO ACCOMPANY PLANS DATED 04-25-16

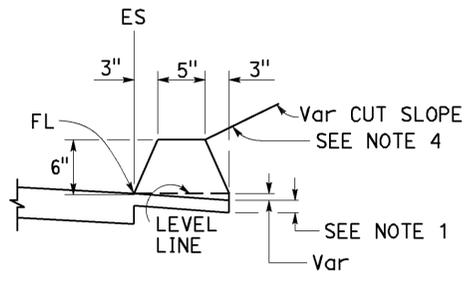


TYPE A
See Notes 3 and 5

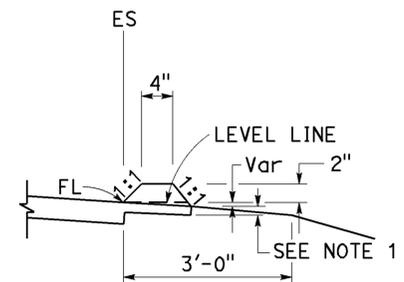


TYPE C

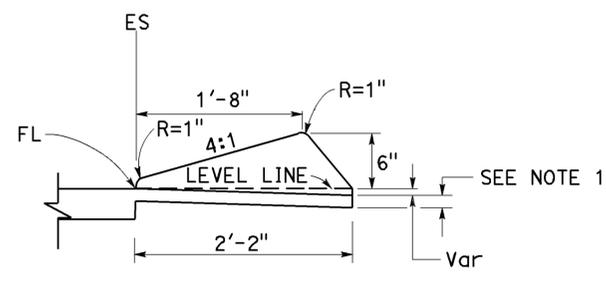

TYPE D

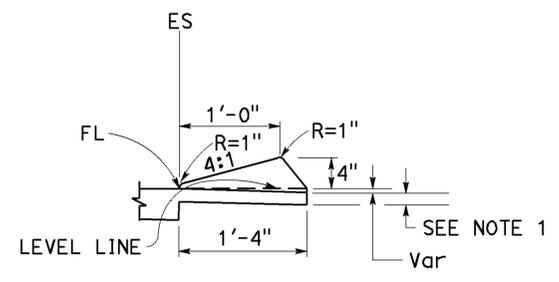


TYPE E

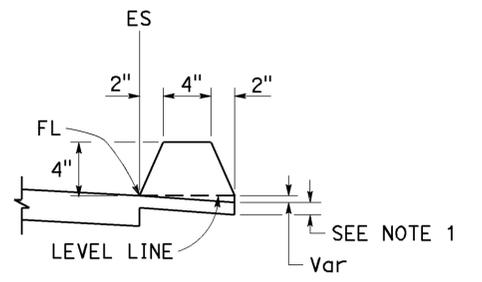


TYPE F
See Note 5


DIKES

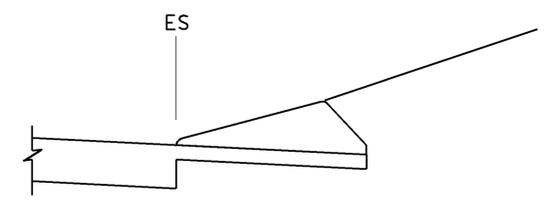


CASE C-1
Cut Slope

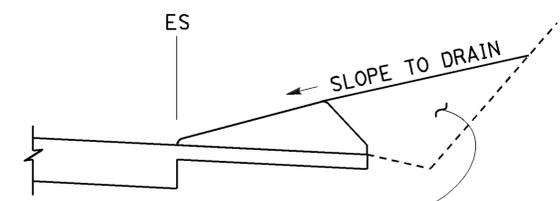

CASE C-2
Cut Slope

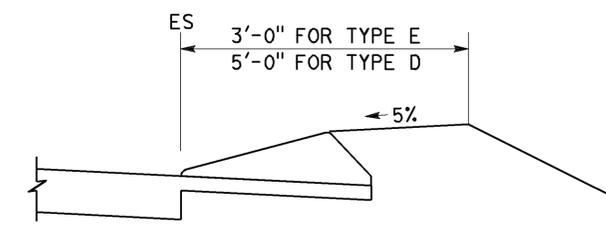

CASE F

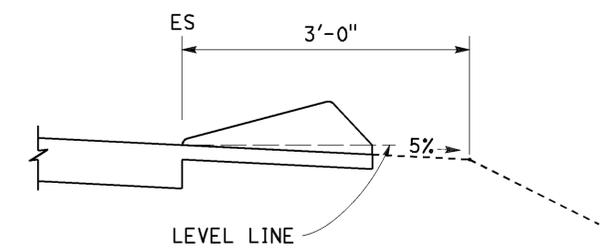

CASE R
See Note 2

TYPE D AND E BACKFILL DETAILS

NOTES:

- For HMA shoulders only, extend top layer of HMA placed on the shoulder under dike with no joint at the ES. For projects with OGFC shoulders, do not extend OGFC under dike. See project plans for modified dike detail.
- Case R applies to retrofit only projects where restrictive conditions do not provide enough width for Case F backfill.
- Type A dike only to be used where restrictive slope conditions do not provide enough width to use Type D or Type E dike.
- Fill and compact with excavated material to top of dike.
- Use Type A or F dike, where dike is required with guardrail installations. See Revised Standard Plan RSP A77N4 for dike positioning details. See Revised Standard Plan RSP A77N3 for hinge point offsets with guardrail.

DIKE QUANTITIES

TYPE	CUBIC YARDS PER LINEAR FOOT
A	0.0135
C	0.0038
D	0.0293
E	0.0130
F	0.0066

Quantities based on 5% cross slope.

STATE OF CALIFORNIA
DEPARTMENT OF TRANSPORTATION

HOT MIX ASPHALT DIKES

NO SCALE


RSP A87B DATED JANUARY 15, 2016 SUPERSEDES RSP A87B DATED JULY 19, 2013 AND STANDARD PLAN A87B DATED MAY 20, 2011 - PAGE 120 OF THE STANDARD PLANS BOOK DATED 2010.

REVISED STANDARD PLAN RSP A87B



2010 REVISED STANDARD PLAN RSP A87B

Dist	COUNTY	ROUTE	POST MILES TOTAL PROJECT	SHEET No.	TOTAL SHEETS
11	SD	8,15,163	Var	108	131

Raymond Don Tsztoo
 REGISTERED CIVIL ENGINEER
 October 30, 2015
 PLANS APPROVAL DATE
THE STATE OF CALIFORNIA OR ITS OFFICERS OR AGENTS SHALL NOT BE RESPONSIBLE FOR THE ACCURACY OR COMPLETENESS OF SCANNED COPIES OF THIS PLAN SHEET.



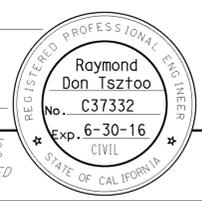


TO ACCOMPANY PLANS DATED 04-25-16

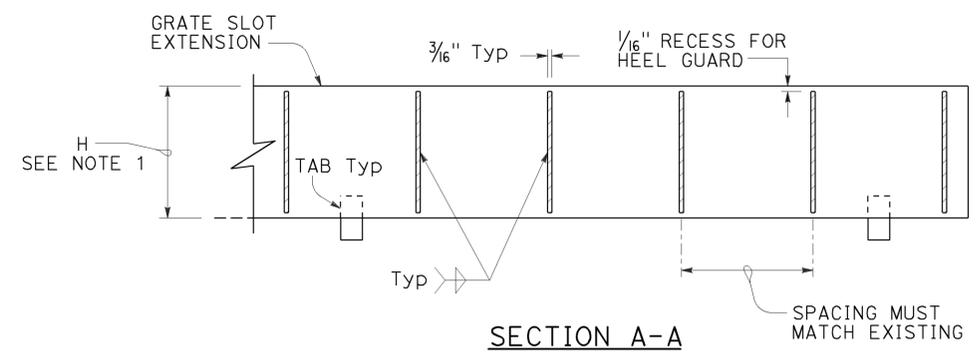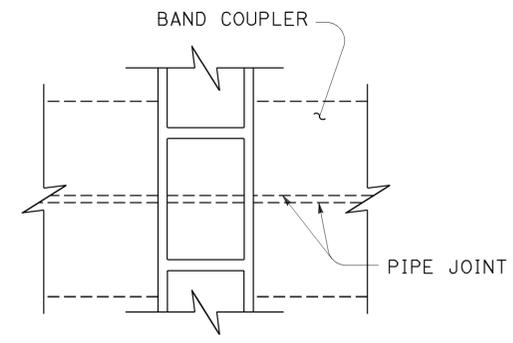

NOTES:

- H must be a minimum of 2 1/2", or otherwise shown on the plans.
- For Slotted Corrugated Steel Pipe Drain Details, see Standard Plans D98A and D98B.
- Use heel guard when shown. See Standard Plan D98B for heel guard details.
- Minimum grate slot extension length is 80".
- The top corners of the grate slot extension's bearing bars must not vary from a straight line more than 1/2" in 20'-0".
- Cross bar spacers must be welded to the grate slot extension's bearing bars to achieve a minimum tensile strength of 12,000 LB normal to the longitudinal axis of the bearing bars.

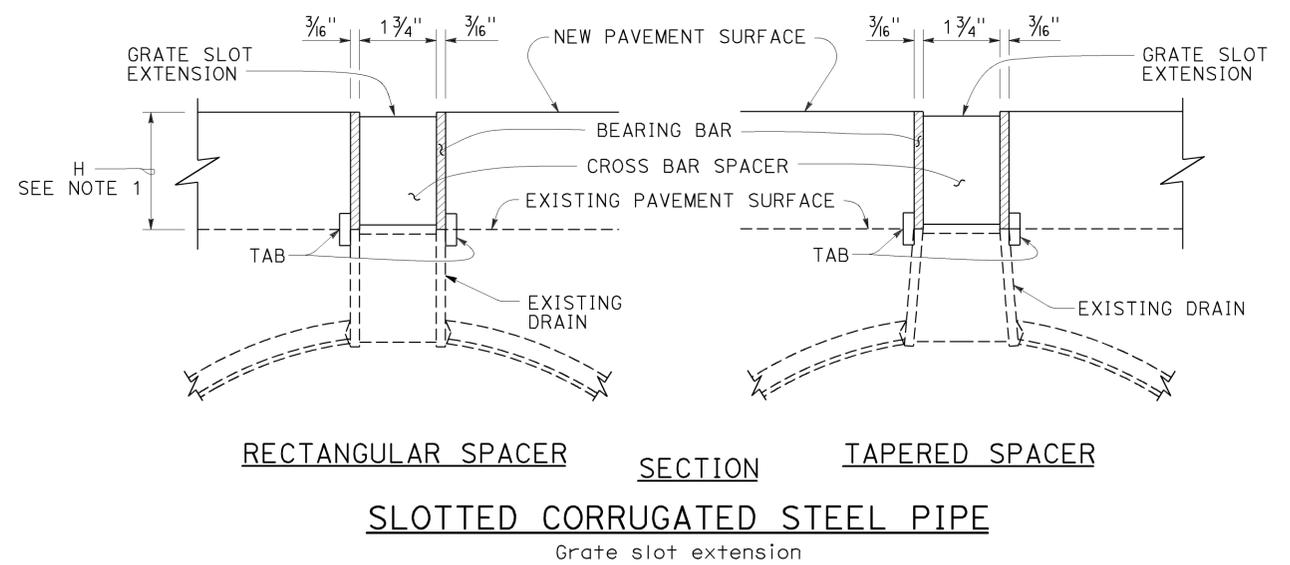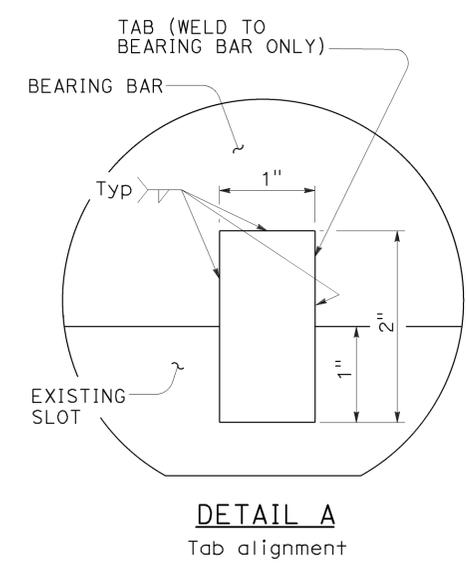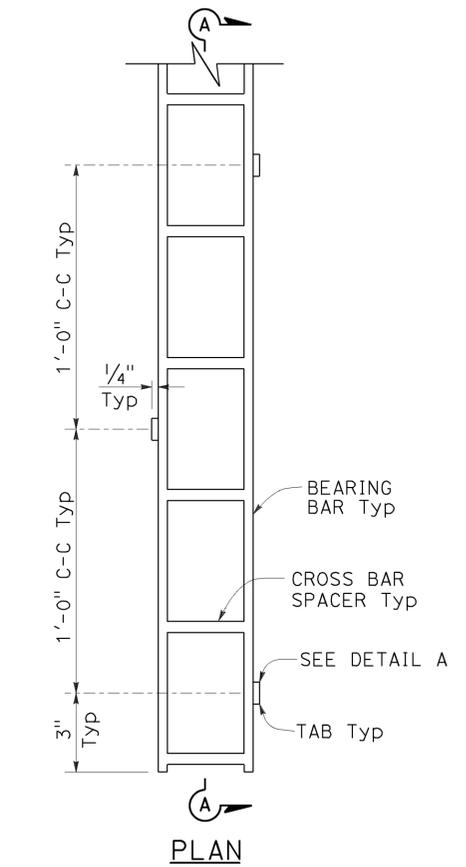

SLOTTED CORRUGATED STEEL PIPE
Grate slot extension

SLOTTED CORRUGATED STEEL PIPE
Grate slot extension

STATE OF CALIFORNIA
DEPARTMENT OF TRANSPORTATION
SLOTTED STEEL PIPE GRATE EXTENSION DETAILS
NO SCALE

RSP D98F DATED OCTOBER 30, 2015 SUPERSEDES RSP D98F DATED JULY 19, 2013 THAT SUPPLEMENTS THE STANDARD PLANS BOOK DATED 2010.

REVISED STANDARD PLAN RSP D98F

2010 REVISED STANDARD PLAN RSP D98F

Dist	COUNTY	ROUTE	POST MILES TOTAL PROJECT	SHEET No.	TOTAL SHEETS
11	SD	8,15,163	Var	109	131

Gregory A. Balzer
 LICENSED LANDSCAPE ARCHITECT

July 19, 2013
 PLANS APPROVAL DATE

THE STATE OF CALIFORNIA OR ITS OFFICERS OR AGENTS SHALL NOT BE RESPONSIBLE FOR THE ACCURACY OR COMPLETENESS OF SCANNED COPIES OF THIS PLAN SHEET.

TO ACCOMPANY PLANS DATED 04-25-16

A

AB AGGREGATE BASE
 ABS ACRYLONITRILE-BUTADIENE-STYRENE
 AC ASPHALT CONCRETE
 ACC ARMOR-CLAD CONDUCTORS
 Adj ADJACENT/ADJUSTABLE
 AIC AUXILIARY IRRIGATION CONTROLLER
 Alt ALTERNATIVE
 AMEND AMENDMENT
 ARV AIR RELEASE VALVE
 AUTO AUTOMATIC
 AUX AUXILIARY
 AVB ATMOSPHERIC VACUUM BREAKER

B

B&B BALLED AND BURLAPPED
 B/B BRASS/BRONZE
 B/B/PL BRASS/BRONZE/PLASTIC
 B/PL BRASS/PLASTIC
 BFM BONDED FIBER MATRIX
 Bit Ctd BITUMINOUS COATED
 BP BOOSTER PUMP
 BPA BACKFLOW PREVENTER ASSEMBLY
 BPE BACKFLOW PREVENTER ENCLOSURE
 BV BALL VALVE

C

C CONDUIT
 CAP CORRUGATED ALUMINUM PIPE
 CARV COMBINATION AIR RELEASE VALVE
 CB COUPLING BAND
 CCA CAM COUPLER ASSEMBLY
 CEC CONTROLLER ENCLOSURE CABINET
 CHDPE CORRUGATED HIGH DENSITY POLYETHYLENE
 CL CHAIN LINK
 CNC CONTROL AND NEUTRAL CONDUCTORS
 Conc CONCRETE
 CP COPPER PIPE
 CS COMPOST SOCK
 CSP CORRUGATED STEEL PIPE
 CST CENTER STRIP
 CV CHECK VALVE

D

Dia DIAMETER
 DIP DUCTILE IRON PIPE
 DIT DRIP IRRIGATION TUBING
 DG DECOMPOSED GRANITE
 DN DIAMETER NOMINAL
 DVA DRIP VALVE ASSEMBLY

E

EC EROSION CONTROL
 ECTC EROSION CONTROL TECHNOLOGY COUNCIL
 ElecT ELECTRIC/ELECTRICAL
 Elev ELEVATION
 ELL ELBOW
 ENCL ENCLOSURE
 EP EDGE OF PAVEMENT
 ES EDGE OF SHOULDER
 EST END STRIP
 ESTB ESTABLISHMENT
 ETW EDGE OF TRAVELED WAY

F

F FULL CIRCLE
 F/P FULL/PART CIRCLE
 FCV FLOW CONTROL VALVE
 FERT FERTILIZER
 FG FINISHED GRADE
 FH FLEXIBLE HOSE
 FIPT FEMALE IRON PIPE THREAD
 FIS FERTILIZER INJECTOR SYSTEM
 FL FLOW LINE
 FR FIBER ROLL
 FS FLOW SENSOR
 FSC FLOW SENSOR CABLE
 FV FLUSH VALVE

G

Galv GALVANIZED
 GARV GARDEN VALVE
 GARVA GARDEN VALVE ASSEMBLY
 GM GRAVEL MULCH
 GPH GALLONS PER HOUR
 GPM GALLONS PER MINUTE
 GSP GALVANIZED STEEL PIPE
 GV GATE VALVE

H

H HALF CIRCLE
 HDPE HIGH DENSITY POLYETHYLENE
 HP HORSEPOWER/HINGE POINT
 HPL HIGH PRESSURE LINE
 Hwy HIGHWAY

I

IC IRRIGATION CONTROLLER
 ICC IRRIGATION CONTROLLER(S) IN CONTROLLER ENCLOSURE CABINET
 ID INSIDE DIAMETER
 IFS IRRIGATION FILTRATION SYSTEM
 IPS IRON PIPE SIZE
 IPT IRON PIPE THREAD
 Irr IRRIGATION

L

L LENGTH

M

Max MAXIMUM
 MBGR METAL BEAM GUARD RAILING
 MCV MANUAL CONTROL VALVE
 MIC MASTER IRRIGATION CONTROLLER
 Min MINIMUM
 MIPT MALE IRON PIPE THREAD
 Misc MISCELLANEOUS
 MtI MATERIAL
 MVP MAINTENANCE VEHICLE PULLOUT

N

NCN NO COMMON NAME
 NL NOZZLE LINE
 No. NUMBER
 NPT NATIONAL PIPE THREAD

O

O/C ON CENTER
 OD OUTSIDE DIAMETER
 OL OVERLAP

P

P PART CIRCLE
 PB PULL BOX
 PCC PORTLAND CEMENT CONCRETE
 PE POLYETHYLENE
 Pkt+ PACKET
 PL PLASTIC
 PLS PURE LIVE SEED
 PLT PLANT/PLANTING
 PLT ESTB PLANT ESTABLISHMENT
 PM POST MILE
 PR PRESSURE RATED
 PRLV PRESSURE RELIEF VALVE
 PRV PRESSURE REGULATING VALVE
 PVC POLYVINYL CHLORIDE
 Pvm+ PAVEMENT

Q

Q QUARTER CIRCLE
 QCV QUICK COUPLING VALVE

NOTE:
 For additional abbreviations, see Standard Plans A10A and A10B.

R

R RADIUS
 RCP REINFORCED CONCRETE PIPE
 RCV REMOTE CONTROL VALVE
 RCVM REMOTE CONTROL VALVE (MASTER)
 RCVMF REMOTE CONTROL VALVE (MASTER) W/FLOW SENSOR
 RCVP REMOTE CONTROL VALVE W/PRESSURE REGULATOR
 RCW RECYCLED WATER
 RECP ROLLED EROSION CONTROL PRODUCT
 REQ REQUIRED
 RICS REMOTE IRRIGATION CONTROL SYSTEM
 R/W RIGHT OF WAY

S

S SLIP
 SCH SCHEDULE
 SF STATE-FURNISHED
 Shld SHOULDER
 Sq SQUARE
 SST SIDE STRIP
 Sta STATION
 Std STANDARD
 SW SIDEWALK/SOUND WALL

T

T THIRD CIRCLE/THREAD
 TLS TRUCK LOADING STANDPIPE
 TQ THREE QUARTER CIRCLE
 TRM TURF REINFORCEMENT MAT
 TT TWO-THIRDS CIRCLE
 TWSA TREE WELL SPRINKLER ASSEMBLY
 Typ TYPICAL

U

UG UNDERGROUND

W

W WIDTH
 W/ WITH
 WM WATER METER
 WS WYE STRAINER
 WSA WYE STRAINER ASSEMBLY
 WSP WELDED STEEL PIPE
 WWM WELDED WIRE MESH

STATE OF CALIFORNIA
 DEPARTMENT OF TRANSPORTATION
LANDSCAPE AND EROSION CONTROL ABBREVIATIONS
 NO SCALE


RSP H1 DATED JULY 19, 2013 SUPERSEDES STANDARD PLAN H1 DATED MAY 20, 2011 - PAGE 218 OF THE STANDARD PLANS BOOK DATED 2010.

REVISED STANDARD PLAN RSP H1
















2010 REVISED STANDARD PLAN RSP H1








Dist	COUNTY	ROUTE	POST MILES TOTAL PROJECT	SHEET No.	TOTAL SHEETS
11	SD	8,15,163	Var	110	131



 LICENSED LANDSCAPE ARCHITECT
 November 15, 2013
 PLANS APPROVAL DATE
THE STATE OF CALIFORNIA OR ITS OFFICERS OR AGENTS SHALL NOT BE RESPONSIBLE FOR THE ACCURACY OR COMPLETENESS OF SCANNED COPIES OF THIS PLAN SHEET.

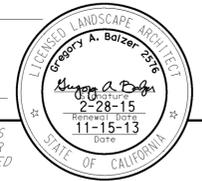

TO ACCOMPANY PLANS DATED 04-25-16

               EXISTING	NEW	ITEM DESCRIPTION
		WATER METER (WM)
		BACKFLOW PREVENTER ASSEMBLY (BPA)
		BACKFLOW PREVENTER ENCLOSURE (BPE)
		BOOSTER PUMP (BP)
		TRUCK LOADING STANDPIPE (TLS)
		FLOW SENSOR (FS)
		MASTER IRRIGATION CONTROLLER (MIC)
		AUXILIARY IRRIGATION CONTROLLER (AIC)
		IRRIGATION CONTROLLER (IC) IRRIGATION CONTROLLER (IC) (BATTERY) IRRIGATION CONTROLLER (IC) (SOLAR) IRRIGATION CONTROLLER (IC) (TWO WIRE) IRRIGATION CONTROLLER(S) IN CONTROLLER ENCLOSURE CABINET (ICC)
		ARMOR-CLAD CONDUCTORS (ACC)
		CONTROL AND NEUTRAL CONDUCTORS (CNC)
		IRRIGATION CONDUIT
		EXTEND IRRIGATION CONDUIT
		DUCTILE IRON PIPE (SUPPLY LINE) (MAIN) (DIP)
		GALVANIZED STEEL PIPE (SUPPLY LINE) (MAIN) (GSP)
		GALVANIZED STEEL PIPE (SUPPLY LINE) (LATERAL) (GSP)
		PLASTIC PIPE (SUPPLY LINE) (MAIN)
		PLASTIC PIPE (SUPPLY LINE) (LATERAL)
		COPPER PIPE (SUPPLY LINE)
		DRIP IRRIGATION TUBING
		REMOTE CONTROL VALVE (RCV) REMOTE CONTROL VALVE (MASTER) (RCVM) REMOTE CONTROL VALVE (MASTER) W/FLOW METER (RCVMF)
		REMOTE CONTROL VALVE W/PRESSURE REGULATOR (RCVP)
		EXISTING MANUAL CONTROL VALVE (MCV)
		DRIP VALVE ASSEMBLY (DVA)
		WYE STRAINER ASSEMBLY (WSA)

       EXISTING	NEW	ITEM DESCRIPTION
		GATE VALVE (GV)
		BALL VALVE (BV)
		QUICK COUPLING VALVE (QCV)
		CAM COUPLER ASSEMBLY (CCA)
		GARDEN VALVE ASSEMBLY (GARVA)
		PRESSURE REGULATING VALVE (PRV)
		PRESSURE RELIEF VALVE (PRLV)
		FLOW CONTROL VALVE (FCV)
		COMBINATION AIR RELEASE VALVE (CARV)
		CHECK VALVE (CV)
		FLUSH VALVE (FV)
		EXISTING NOZZLE LINE W/TURNING UNION
		EXISTING IRRIGATION SYSTEM
		EXISTING IRRIGATION SYSTEM TO BE REMOVED
		CHAIN LINK GATE
		QUICK COUPLING VALVE W/SPRINKLER PROTECTOR
		SPRINKLER W/SPRINKLER PROTECTOR
		CONNECT TO EXISTING SYSTEM
		CAP
		CAP EXISTING
		FIBER ROLL
		COMPOST SOCK

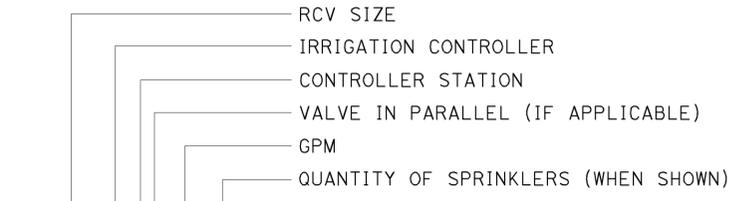

VALVE CODE

* VALVE CODES FOR EXISTING VALVES ARE SHOWN IN A DASHED ENCLOSURE.

RSP H2 DATED NOVEMBER 15, 2013 SUPERSEDES RSP H2 DATED JULY 19, 2013 AND STANDARD PLAN H2 DATED MAY 20, 2011 - PAGE 219 OF THE STANDARD PLANS BOOK DATED 2010.

REVISED STANDARD PLAN RSP H2

STATE OF CALIFORNIA
DEPARTMENT OF TRANSPORTATION
LANDSCAPE AND EROSION CONTROL SYMBOLS
NO SCALE


2010 REVISED STANDARD PLAN RSP H2

Dist	COUNTY	ROUTE	POST MILES TOTAL PROJECT	SHEET No.	TOTAL SHEETS
11	SD	8,15,163	Var	111	131


Gregory A. Balzer
 LICENSED LANDSCAPE ARCHITECT
 July 19, 2013
 PLANS APPROVAL DATE
THE STATE OF CALIFORNIA OR ITS OFFICERS OR AGENTS SHALL NOT BE RESPONSIBLE FOR THE ACCURACY OR COMPLETENESS OF SCANNED COPIES OF THIS PLAN SHEET.




TO ACCOMPANY PLANS DATED 04-25-16

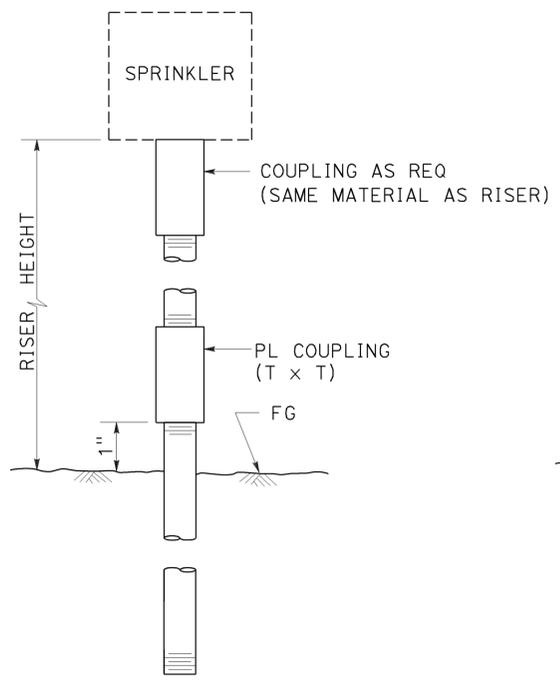


ELEVATION
RISER SPRINKLER ASSEMBLY TYPE I

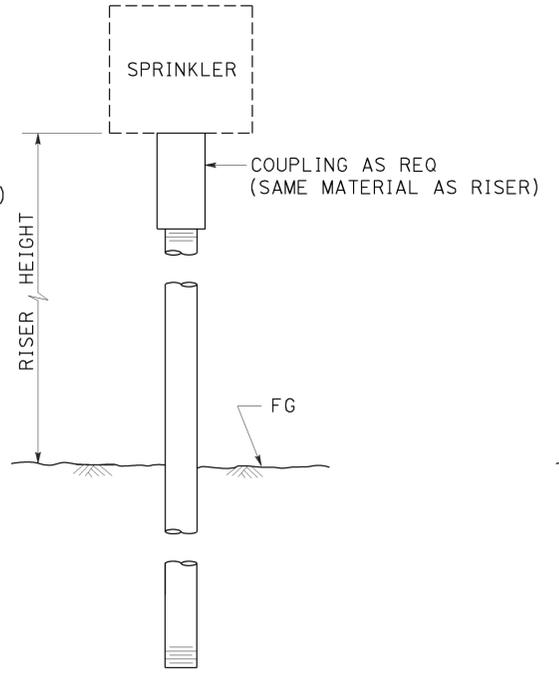

ELEVATION
RISER SPRINKLER ASSEMBLY TYPE II

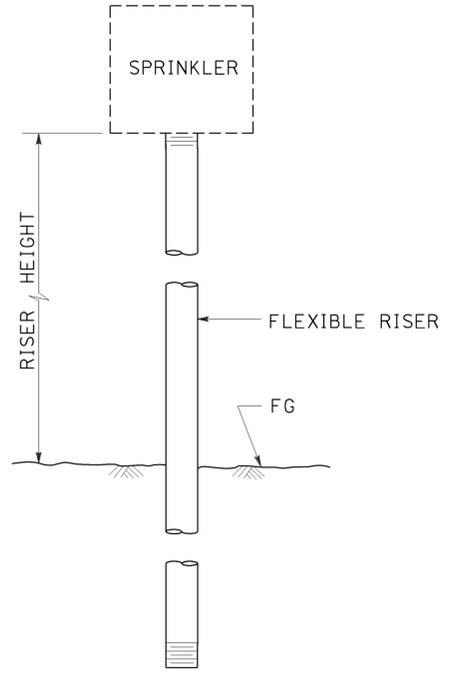


ELEVATION
RISER SPRINKLER ASSEMBLY TYPE III

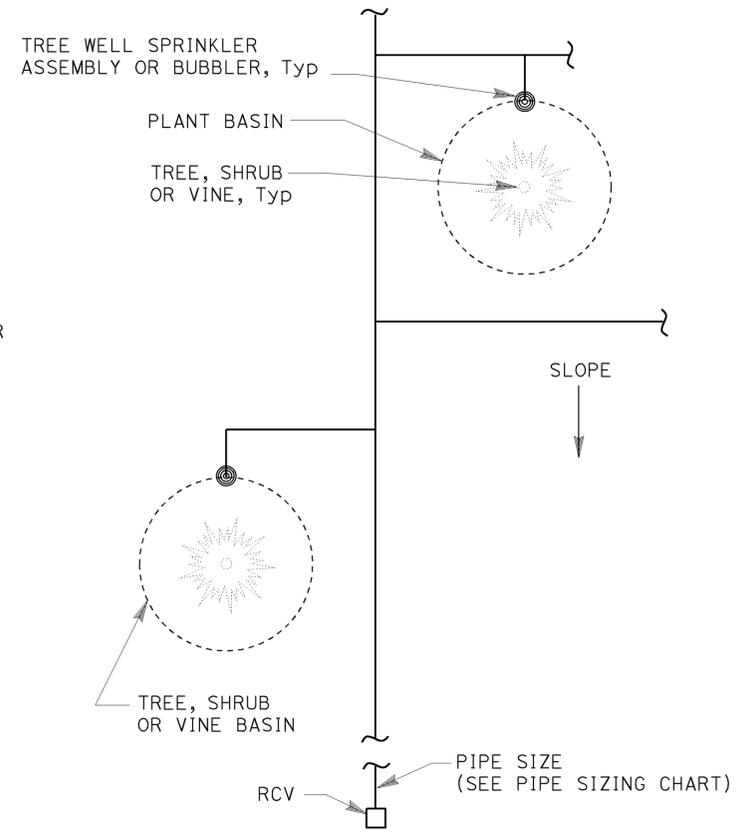


PLAN

NOTES:


1. Install tree well sprinkler assembly on up-hill side of plant when on slope.
2. Install bubbler within basin.

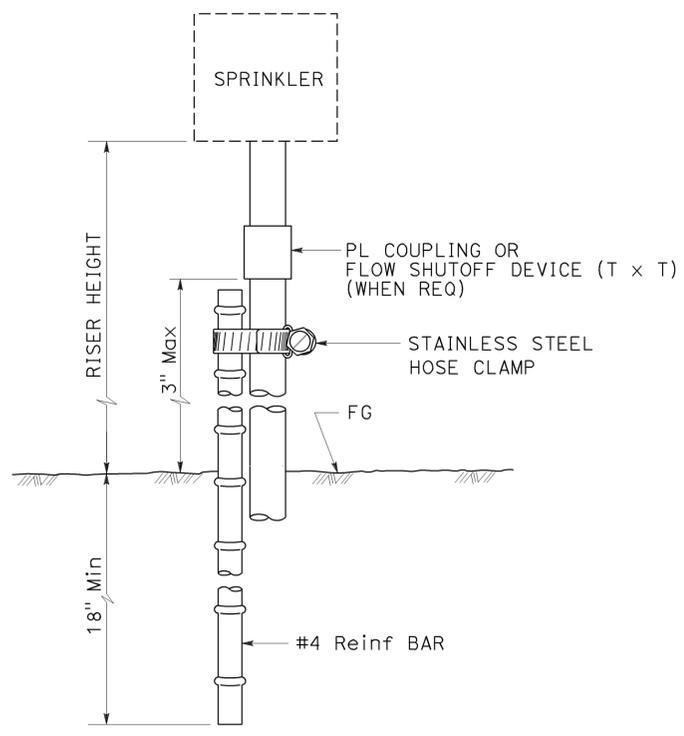

ELEVATION
RISER SPRINKLER ASSEMBLY TYPE IV

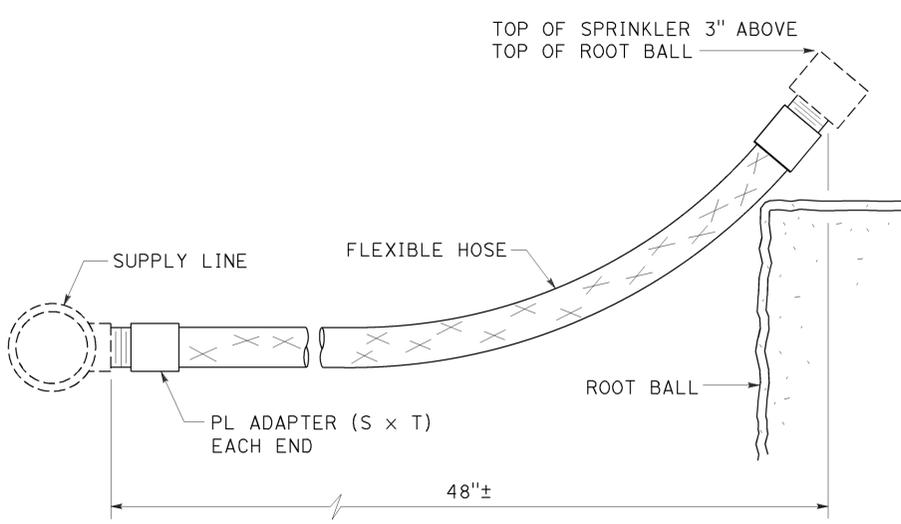

ELEVATION
RISER SPRINKLER ASSEMBLY TYPE V

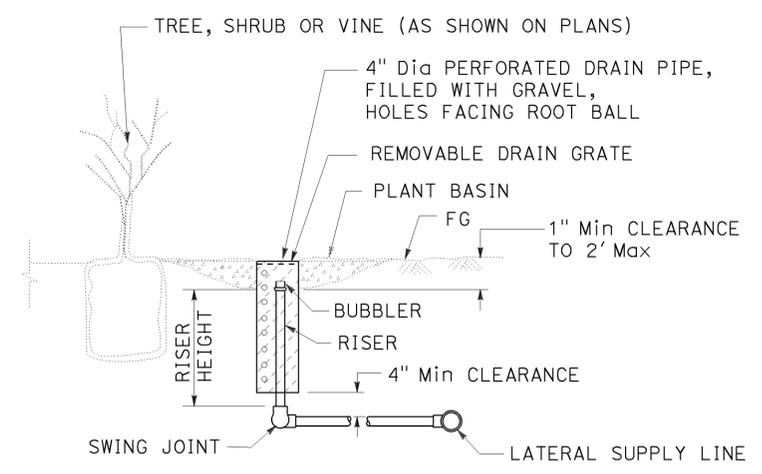

SECTION
TREE WELL SPRINKLER ASSEMBLY

STATE OF CALIFORNIA
DEPARTMENT OF TRANSPORTATION
LANDSCAPE DETAILS
NO SCALE

RSP H5 DATED JULY 19, 2013 SUPERSEDES STANDARD PLAN H5 DATED MAY 20, 2011 - PAGE 222 OF THE STANDARD PLANS BOOK DATED 2010.

REVISED STANDARD PLAN RSP H5


2010 REVISED STANDARD PLAN RSP H5

Dist	COUNTY	ROUTE	POST MILES TOTAL PROJECT	SHEET No.	TOTAL SHEETS
11	SD	8,15,163	Var	112	131

Gregory A. Balzer
 LICENSED LANDSCAPE ARCHITECT
 July 19, 2013
 PLANS APPROVAL DATE
THE STATE OF CALIFORNIA OR ITS OFFICERS OR AGENTS SHALL NOT BE RESPONSIBLE FOR THE ACCURACY OR COMPLETENESS OF SCANNED COPIES OF THIS PLAN SHEET.


TO ACCOMPANY PLANS DATED 04-25-16

2010 REVISED STANDARD PLAN RSP H6

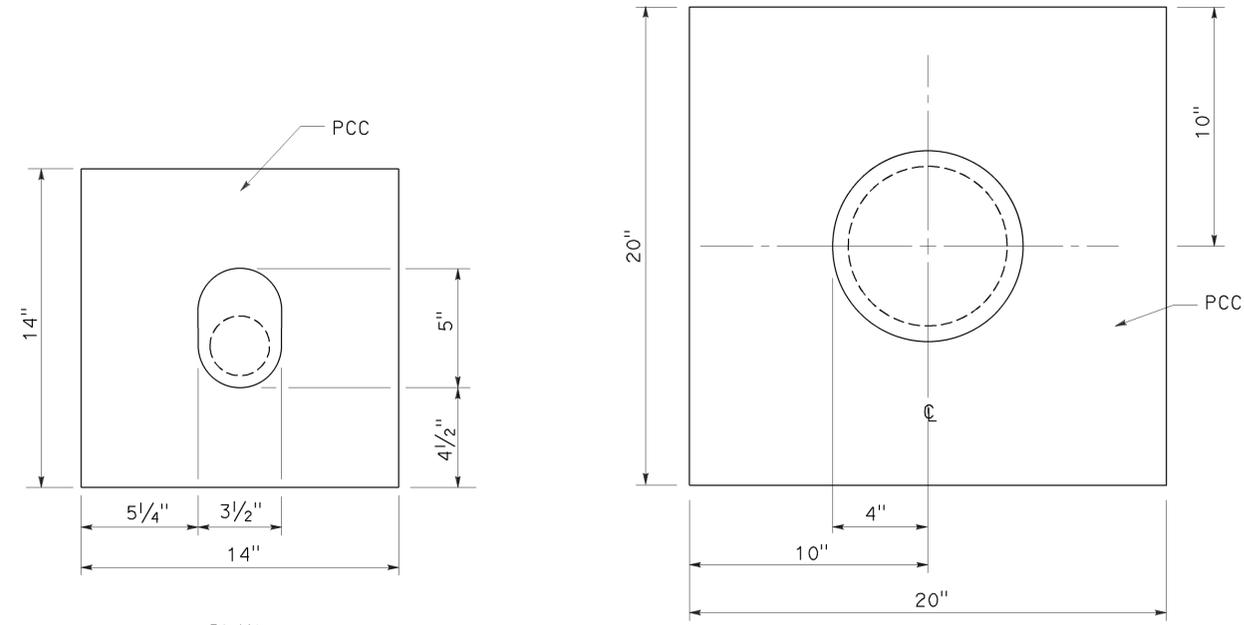


PLAN

PLAN

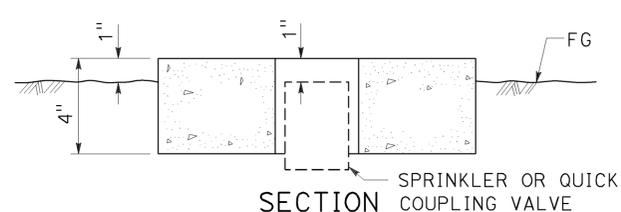


SECTION

SPRINKLER PROTECTOR TYPE I

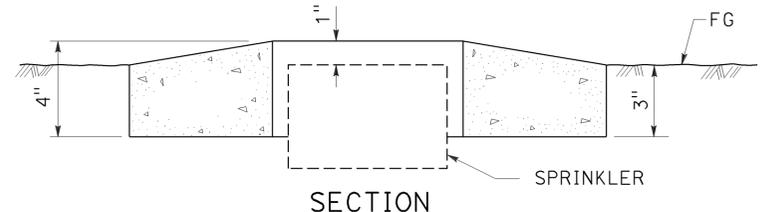


SECTION

SPRINKLER PROTECTOR TYPE II

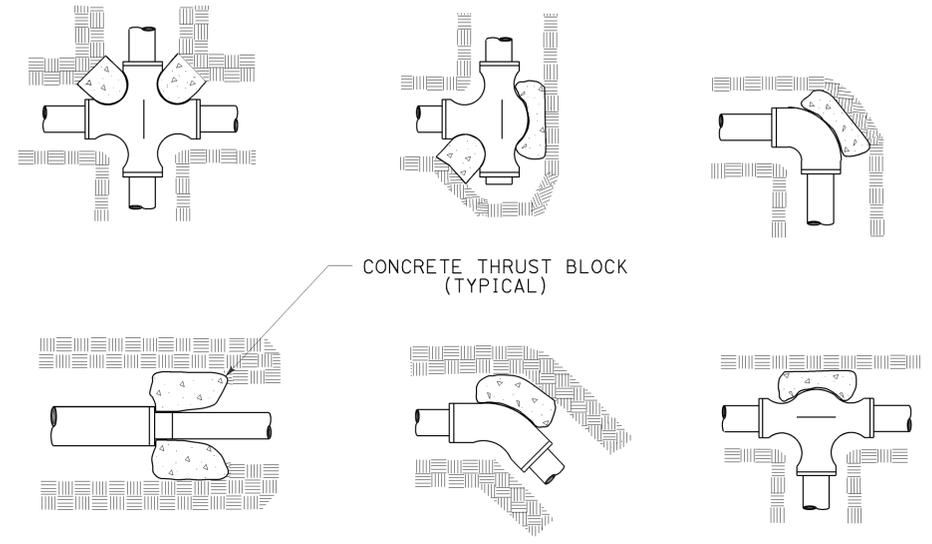


TYPICAL THRUST BLOCKS

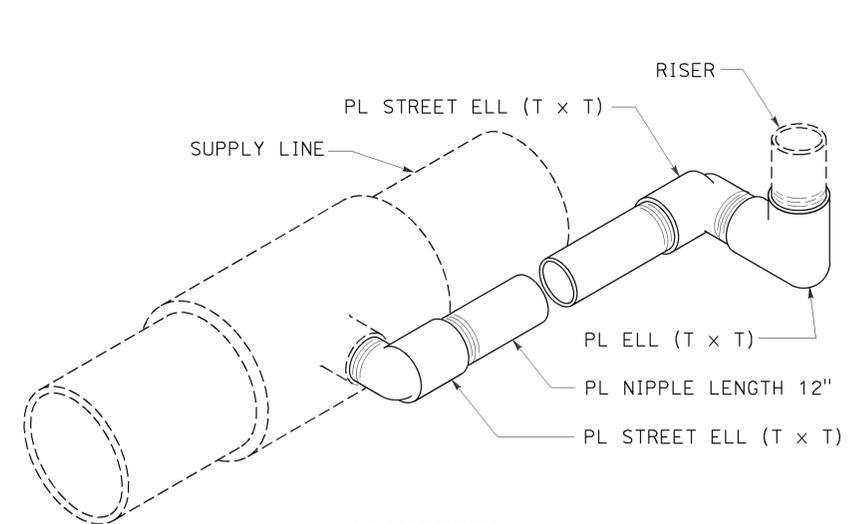


ISOMETRIC

POP-UP SPRINKLER ASSEMBLY TYPE I

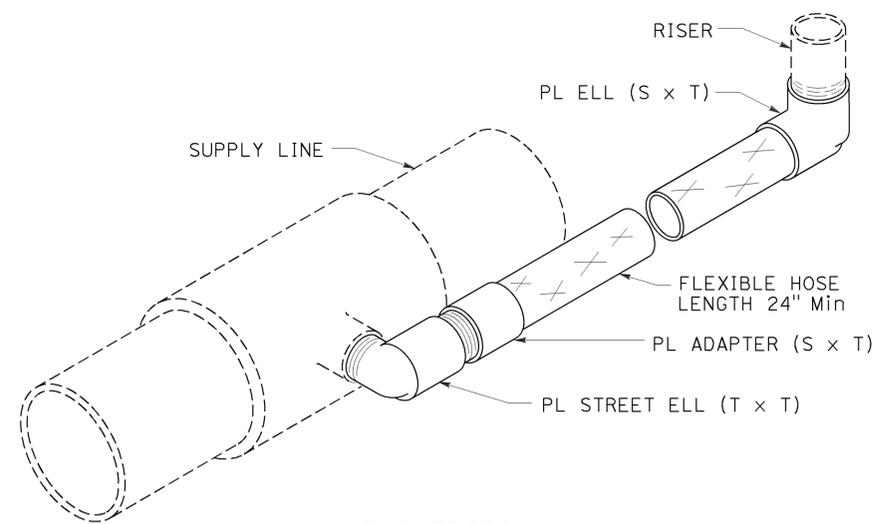

ISOMETRIC

POP-UP SPRINKLER ASSEMBLY TYPE II

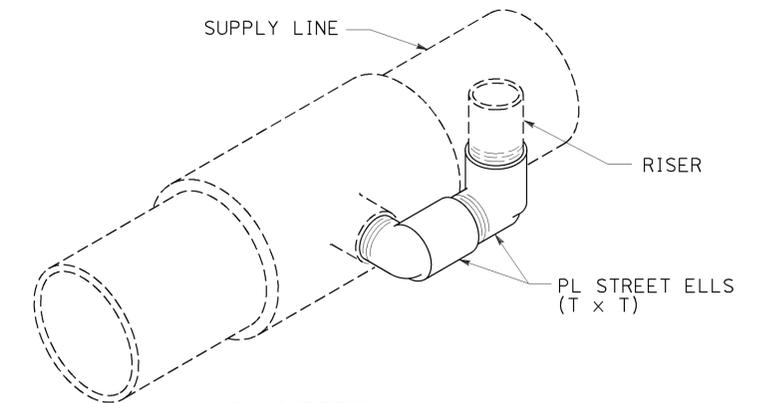

ISOMETRIC

POP-UP SPRINKLER ASSEMBLY TYPE III

STATE OF CALIFORNIA
 DEPARTMENT OF TRANSPORTATION
LANDSCAPE DETAILS


NO SCALE

RSP H6 DATED JULY 19, 2013 SUPERSEDES STANDARD PLAN H6 DATED MAY 20, 2011 - PAGE 223 OF THE STANDARD PLANS BOOK DATED 2010.


REVISED STANDARD PLAN RSP H6

Dist	COUNTY	ROUTE	POST MILES TOTAL PROJECT	SHEET No.	TOTAL SHEETS
11	SD	8,15,163	Var	113	131


Gregory A. Balzer
 LICENSED LANDSCAPE ARCHITECT
 July 19, 2013
 PLANS APPROVAL DATE
THE STATE OF CALIFORNIA OR ITS OFFICERS OR AGENTS SHALL NOT BE RESPONSIBLE FOR THE ACCURACY OR COMPLETENESS OF SCANNED COPIES OF THIS PLAN SHEET.

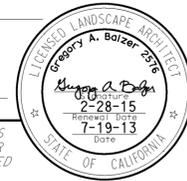


TO ACCOMPANY PLANS DATED 04-25-16

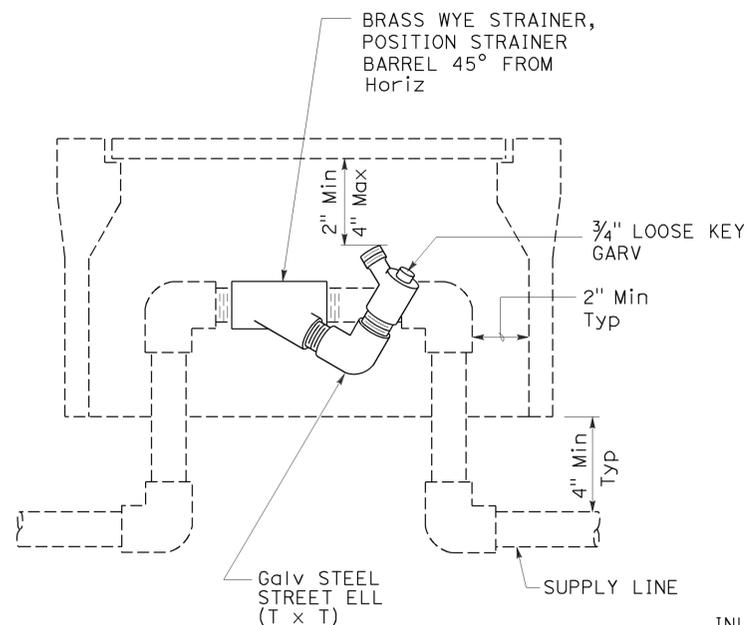


**ELEVATION
WYE STRAINER ASSEMBLY**

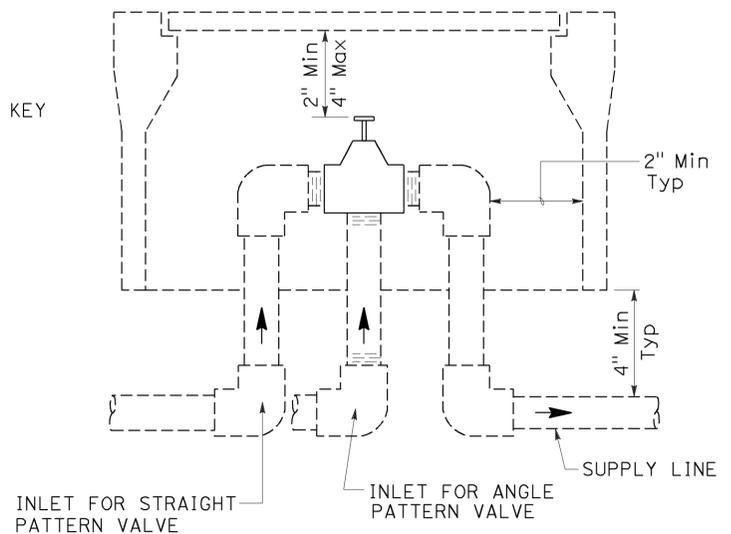


**ELEVATION
VALVE**

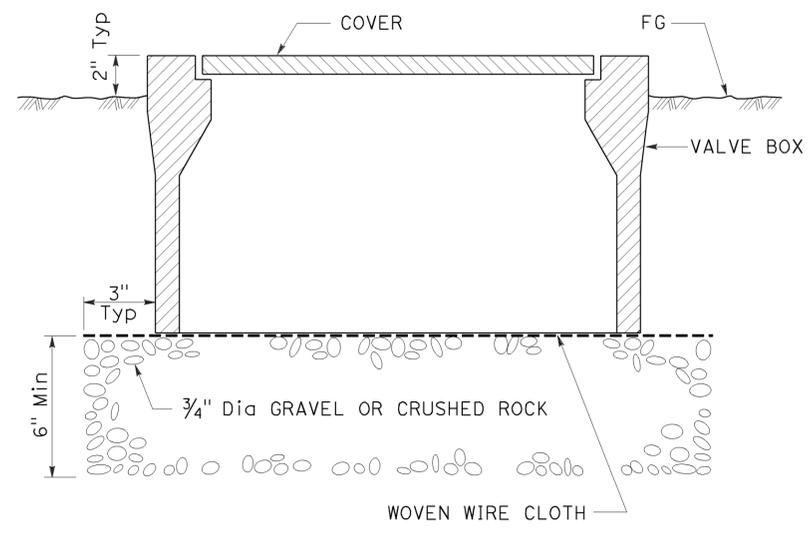

**SECTION
VALVE BOX**

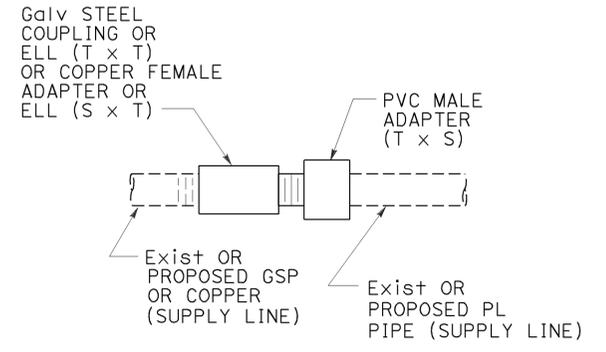

**GALVANIZED OR COPPER PIPE
CONNECTION TO PLASTIC PIPE**

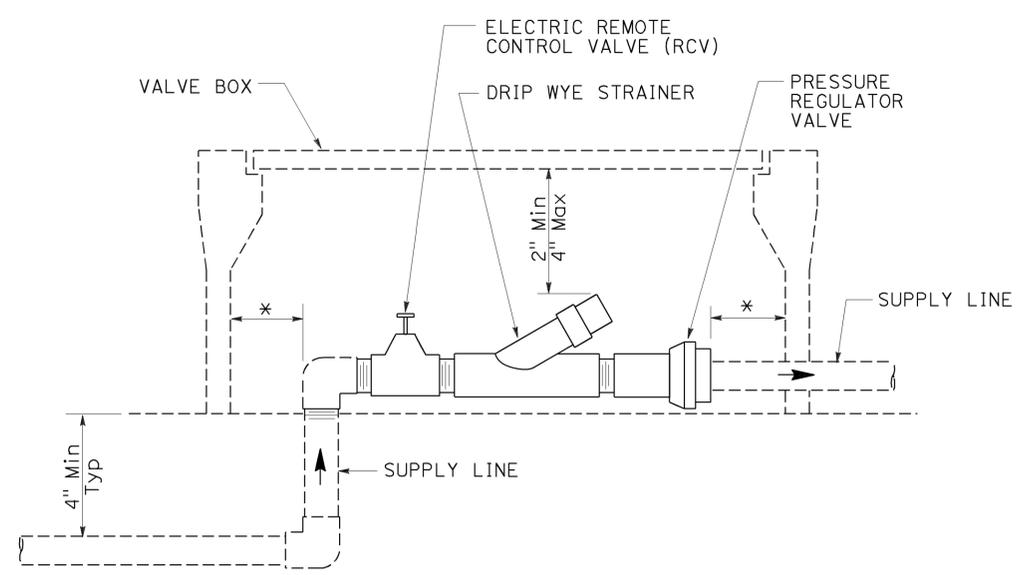


**ELEVATION
DRIP VALVE ASSEMBLY**


* 2" CLEARANCE ON ALL SIDES

IDENTIFICATION LABEL:
FOR ABBREVIATIONS SEE
REVISED STANDARD PLANS
RSP H1 AND RSP H2.
FOR CONTROLLER AND
STATION NUMBER
SEE PROJECT PLANS.


RECYCLED WATER WARNING
SIGN WHEN REQUIRED

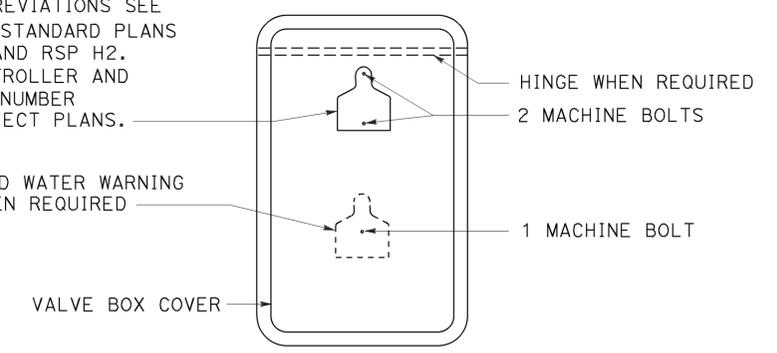


PLAN

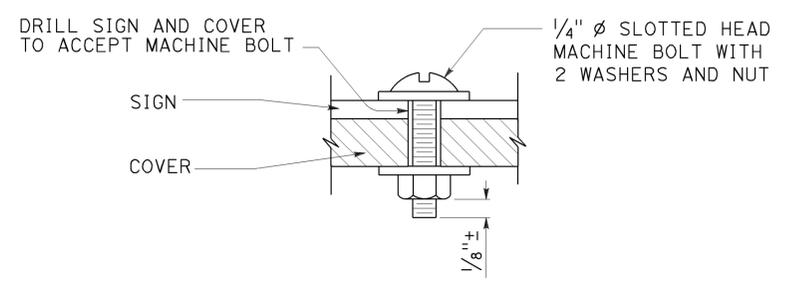

**SECTION
VALVE BOX IDENTIFICATION**

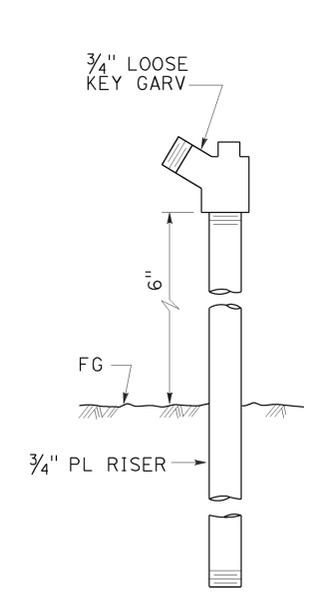

**ELEVATION
GARDEN VALVE ASSEMBLY**

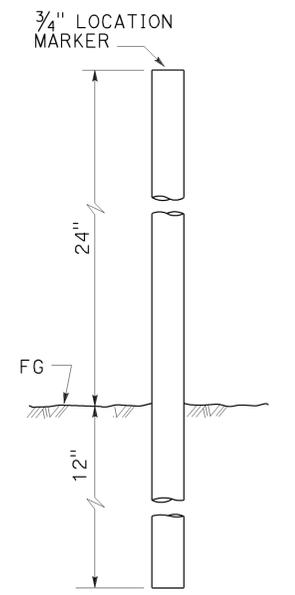

**ELEVATION
LOCATION MARKER**

GARDEN VALVE ASSEMBLY

LANDSCAPE DETAILS

STATE OF CALIFORNIA
DEPARTMENT OF TRANSPORTATION

NO SCALE


RSP H7 DATED JULY 19, 2013 SUPERSEDES STANDARD PLAN H7
DATED MAY 20, 2011 - PAGE 224 OF THE STANDARD PLANS BOOK DATED 2010.

REVISED STANDARD PLAN RSP H7


2010 REVISED STANDARD PLAN RSP H7

Dist	COUNTY	ROUTE	POST MILES TOTAL PROJECT	SHEET No.	TOTAL SHEETS
11	SD	8,15,163	Var	114	131


Gregory A. Balzer
 LICENSED LANDSCAPE ARCHITECT
 July 19, 2013
 PLANS APPROVAL DATE
THE STATE OF CALIFORNIA OR ITS OFFICERS OR AGENTS SHALL NOT BE RESPONSIBLE FOR THE ACCURACY OR COMPLETENESS OF SCANNED COPIES OF THIS PLAN SHEET.

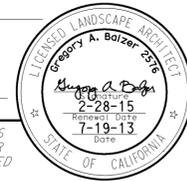


TO ACCOMPANY PLANS DATED 04-25-16

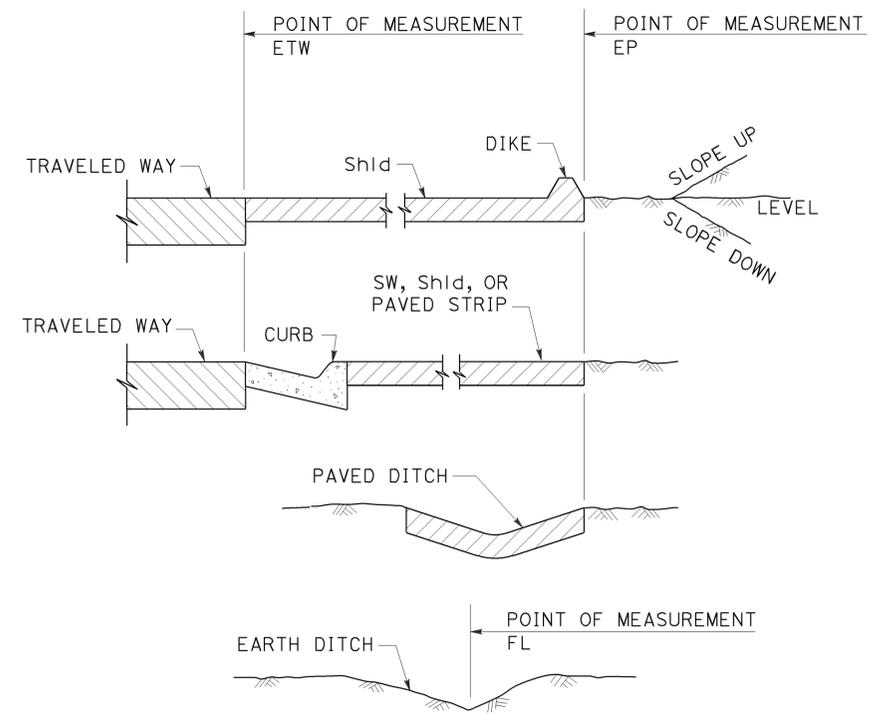


**SECTION
POINTS OF MEASUREMENT**

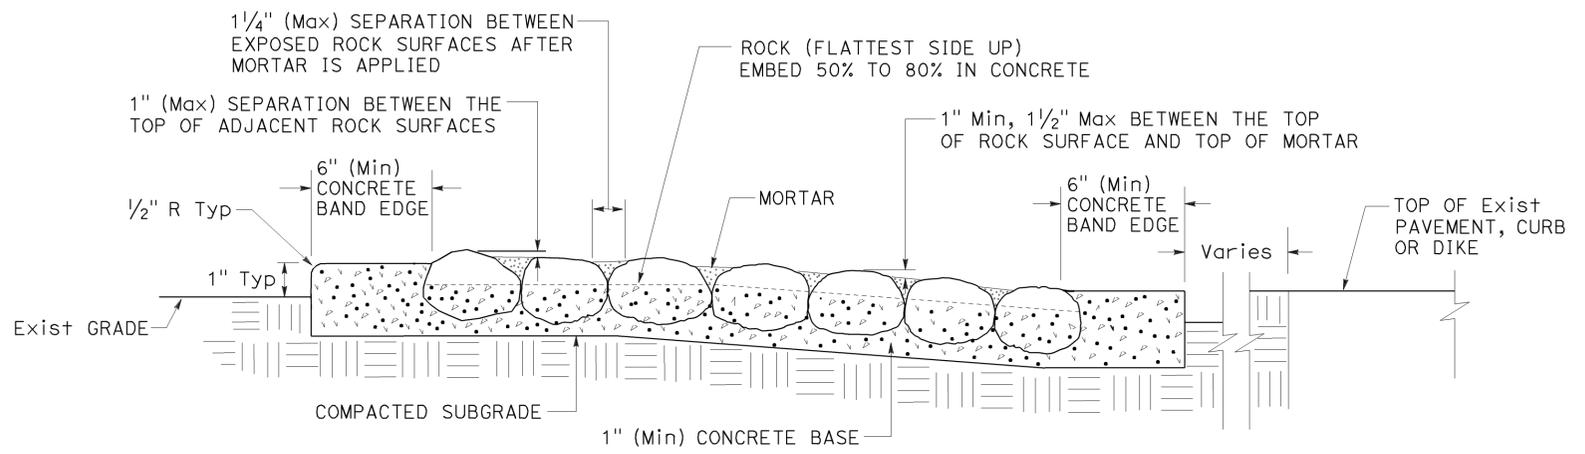

**SECTION
ROCK BLANKET**

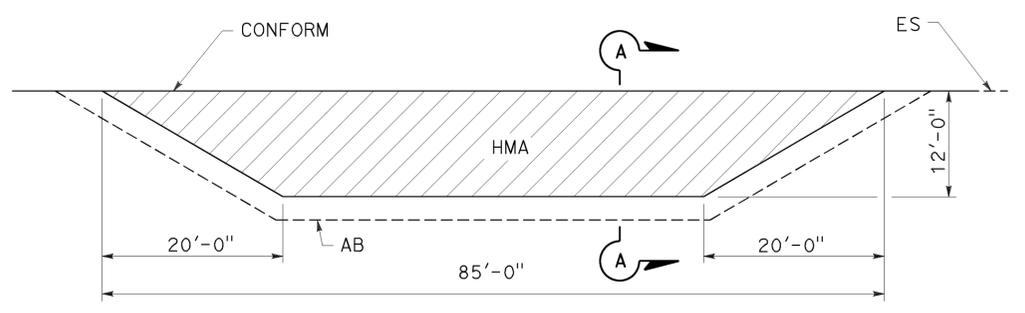

PLAN

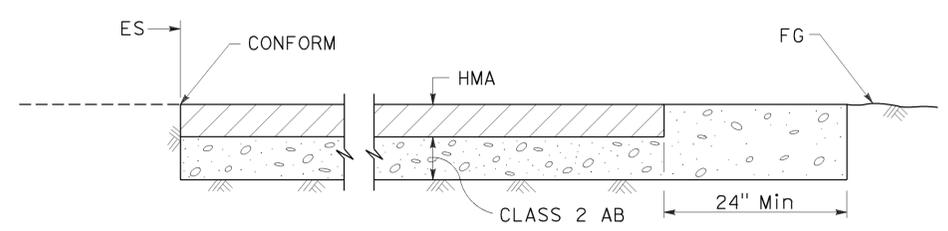

**SECTION A-A
MAINTENANCE VEHICLE PULLOUT**


STATE OF CALIFORNIA
 DEPARTMENT OF TRANSPORTATION
LANDSCAPE DETAILS
 NO SCALE

RSP H9A DATED JULY 19, 2013 SUPPLEMENTS THE STANDARD PLANS BOOK DATED 2010.

REVISED STANDARD PLAN RSP H9A

2010 REVISED STANDARD PLAN RSP H9A

Dist	COUNTY	ROUTE	POST MILES TOTAL PROJECT	SHEET No.	TOTAL SHEETS
11	SD	8,15,163	Var	115	131

 
 REGISTERED CIVIL ENGINEER
 July 19, 2013
 PLANS APPROVAL DATE



THE STATE OF CALIFORNIA OR ITS OFFICERS OR AGENTS SHALL NOT BE RESPONSIBLE FOR THE ACCURACY OR COMPLETENESS OF SCANNED COPIES OF THIS PLAN SHEET.

TO ACCOMPANY PLANS DATED 04-25-16

TABLE 1

TAPER LENGTH CRITERIA AND CHANNELIZING DEVICE SPACING							
SPEED (S)	MINIMUM TAPER LENGTH * FOR WIDTH OF OFFSET 12 FEET (W)				MAXIMUM CHANNELIZING DEVICE SPACING		
	TANGENT 2L	MERGING L	SHIFTING L/2	SHOULDER L/3	X	Y	Z **
					TAPER	TANGENT	CONFLICT
mph	ft	ft	ft	ft	ft	ft	ft
20	160	80	40	27	20	40	10
25	250	125	63	42	25	50	12
30	360	180	90	60	30	60	15
35	490	245	123	82	35	70	17
40	640	320	160	107	40	80	20
45	1080	540	270	180	45	90	22
50	1200	600	300	200	50	100	25
55	1320	660	330	220	55	110	27
60	1440	720	360	240	60	120	30
65	1560	780	390	260	65	130	32
70	1680	840	420	280	70	140	35

* - For other offsets, use the following merging taper length formula for L:
 For speed of 40 mph or less, $L = WS^2/60$
 For speed of 45 mph or more, $L = WS$

Where: L = Taper length in feet
 W = Width of offset in feet
 S = Posted speed limit, off-peak 85th-percentile speed prior to work starting, or the anticipated operating speed in mph

** - Use for taper and tangent sections where there are no pavement markings or where there is a conflict between existing pavement markings and channelizers (CA).

TABLE 2

LONGITUDINAL BUFFER SPACE AND FLAGGER STATION SPACING				
SPEED *	Min D **	DOWNGRADE Min D ***		
		-3%	-6%	-9%
		ft	ft	ft
mph	ft	ft	ft	ft
20	115	116	120	126
25	155	158	165	173
30	200	205	215	227
35	250	257	271	287
40	305	315	333	354
45	360	378	400	427
50	425	446	474	507
55	495	520	553	593
60	570	598	638	686
65	645	682	728	785
70	730	771	825	891

* - Speed is posted speed limit, off-peak 85th-percentile speed prior to work starting, or the anticipated operating speed in mph
 ** - Longitudinal buffer space or flagger station spacing
 *** - Use on sustained downgrade steeper than -3 percent and longer than 1 mile.

TABLE 3

ADVANCE WARNING SIGN SPACING			
ROAD TYPE	DISTANCE BETWEEN SIGNS *		
	A	B	C
	ft	ft	ft
URBAN - 25 mph OR LESS	100	100	100
URBAN - MORE THAN 25 mph TO 40 mph	250	250	250
URBAN - MORE THAN 40 mph	350	350	350
RURAL	500	500	500
EXPRESSWAY / FREEWAY	1000	1500	2640

* - The distances are approximate, are intended for guidance purposes only, and should be applied with engineering judgment. These distances should be adjusted by the Engineer for field conditions, if necessary, by increasing or decreasing the recommended distances.

STATE OF CALIFORNIA
 DEPARTMENT OF TRANSPORTATION

TRAFFIC CONTROL SYSTEM TABLES FOR LANE AND RAMP CLOSURES

NO SCALE

RSP T9 DATED JULY 19, 2013 SUPERSEDES RSP T9 DATED APRIL 19, 2013 THAT SUPPLEMENTS THE STANDARD PLANS BOOK DATED 2010.


2010 REVISED STANDARD PLAN RSP T9

DIST	COUNTY	ROUTE	POST MILES TOTAL PROJECT	SHEET No.	TOTAL SHEETS
11	SD	8,15,163	Var	116	131

REGISTERED CIVIL ENGINEER
 April 19, 2013
 PLANS APPROVAL DATE

THE STATE OF CALIFORNIA OR ITS OFFICERS OR AGENTS SHALL NOT BE RESPONSIBLE FOR THE ACCURACY OR COMPLETENESS OF SCANNED COPIES OF THIS PLAN SHEET.

2010 REVISED STANDARD PLAN RSP T10

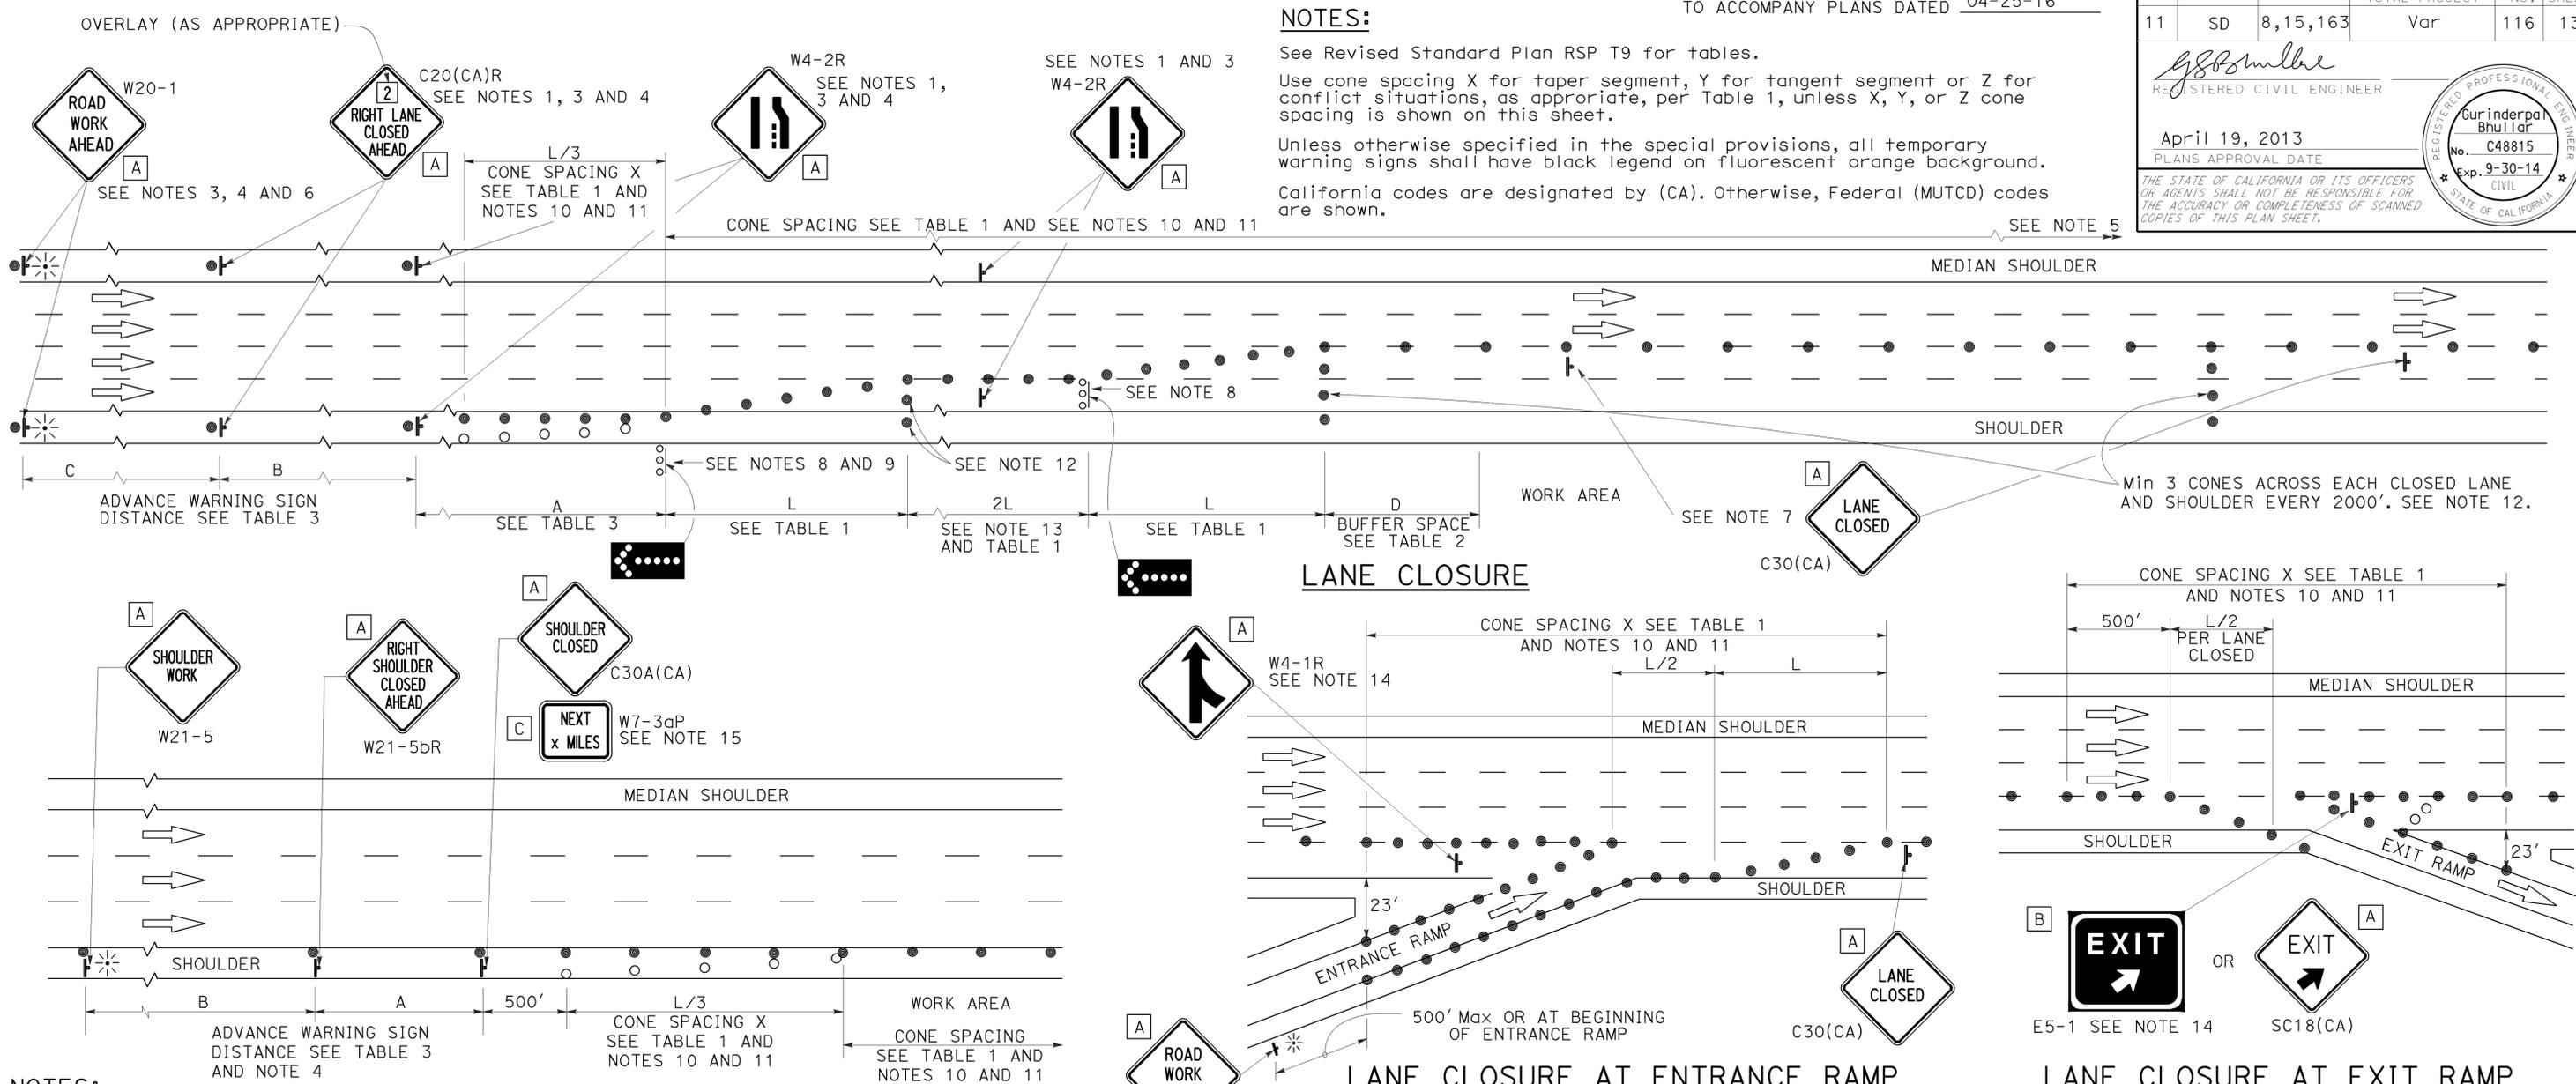

- NOTES:**
1. Median lane closures shall conform to the details as shown except that C20(CA)L and W4-2L signs shall be used.
 2. At least one person shall be assigned to provide full time maintenance of traffic control devices for lane closures.
 3. Duplicate sign installations are not required:
 - a) On opposite shoulder if at least one-half of the available lanes remain open to traffic.
 - b) In the median if the width of the median shoulder is less than 8' and the outside lanes are to be closed.
 4. Each advance warning sign on each side of the roadway shall be equipped with at least two flags for daytime closure. Each flag shall be at least 16" x 16" in size and shall be orange or fluorescent red-orange in color. Flashing beacons shall be placed at the locations indicated for lane closure during hours of darkness.
 5. A G20-2 "END ROAD WORK" sign, with minimum size of 48" x 24" as appropriate, shall be placed at the end of the lane closure unless the end of work area is obvious or ends within a larger project's limits.

- SHOULDER CLOSURE**
6. If the W20-1 sign would follow within 2000' of a stationary W20-1 or G20-1 "ROAD WORK NEXT _____ MILES", use a C20(CA)L and W4-2L signs shall be used.
 7. Place a C30(CA) sign every 2000' throughout length of lane closure.
 8. One flashing arrow sign for each lane closed. The flashing arrow signs shall be Type I.
 9. A minimum 1500' of sight distance shall be provided where possible for vehicles approaching the first flashing arrow sign. Lane closures shall not begin at top of crest vertical curve or on a horizontal curve.
 10. All cones used for lane closures during the hours of darkness shall be fitted with retroreflective bands (or sleeves) as specified in the specifications.
 11. Portable delineators, placed at one-half the spacing indicated for traffic cones may be used instead of cones for daytime closures only.

- LANE CLOSURE AT ENTRANCE RAMP**
12. Unless otherwise specified in the special provisions, a minimum of 3 cones shall be placed transversely across each closed lane and shoulder at each location where a taper across a traffic lane ends and every 2000' as shown on the "Lane Closure" detail. Two Type II barricades may be used instead of the 3 cones. The transverse alignment of the cones or barricades on the closed shoulder may be shifted from the transverse alignment to provide access to the work.
 13. Unless otherwise specified in the special provisions, the 2L tangent shown along lane lines shall be used between the L tapers required for each closed traffic lane.
 14. Unless otherwise specified in the special provisions, the E5-1 or SC18(CA) and W4-1 signs shall be used as shown.
 15. A W7-3aP "NEXT _____ MILES" plaque must be used if the shoulder closure extends beyond the distance that can be perceived by road users.

LEGEND

- TRAFFIC CONE
- TRAFFIC CONE (OPTIONAL TAPER)
- ⊥ TEMPORARY TRAFFIC CONTROL SIGN
- ⬢ FLASHING ARROW SIGN (FAS)
- ⊞ FAS SUPPORT OR TRAILER
- ⚡ PORTABLE FLASHING BEACON

SIGN PANEL SIZE (Min)

A	48" x 48"
B	72" x 60"
C	36" x 30"

STATE OF CALIFORNIA
 DEPARTMENT OF TRANSPORTATION

TRAFFIC CONTROL SYSTEM FOR LANE CLOSURE ON FREEWAYS AND EXPRESSWAYS

NO SCALE

RSP T10 DATED APRIL 19, 2013 SUPERSEDES STANDARD PLAN T10 DATED MAY 20, 2011 - PAGE 237 OF THE STANDARD PLANS BOOK DATED 2010.


REVISED STANDARD PLAN RSP T10

DIST	COUNTY	ROUTE	POST MILES TOTAL PROJECT	SHEET No.	TOTAL SHEETS
11	SD	8,15,163	Var	117	131

REGISTERED CIVIL ENGINEER
 April 19, 2013
 PLANS APPROVAL DATE
 THE STATE OF CALIFORNIA OR ITS OFFICERS OR AGENTS SHALL NOT BE RESPONSIBLE FOR THE ACCURACY OR COMPLETENESS OF SCANNED COPIES OF THIS PLAN SHEET.

REGISTERED PROFESSIONAL ENGINEER
 Gurinderpal Bhullar
 No. C48815
 Exp. 9-30-14
 CIVIL
 STATE OF CALIFORNIA

TO ACCOMPANY PLANS DATED 04-25-16

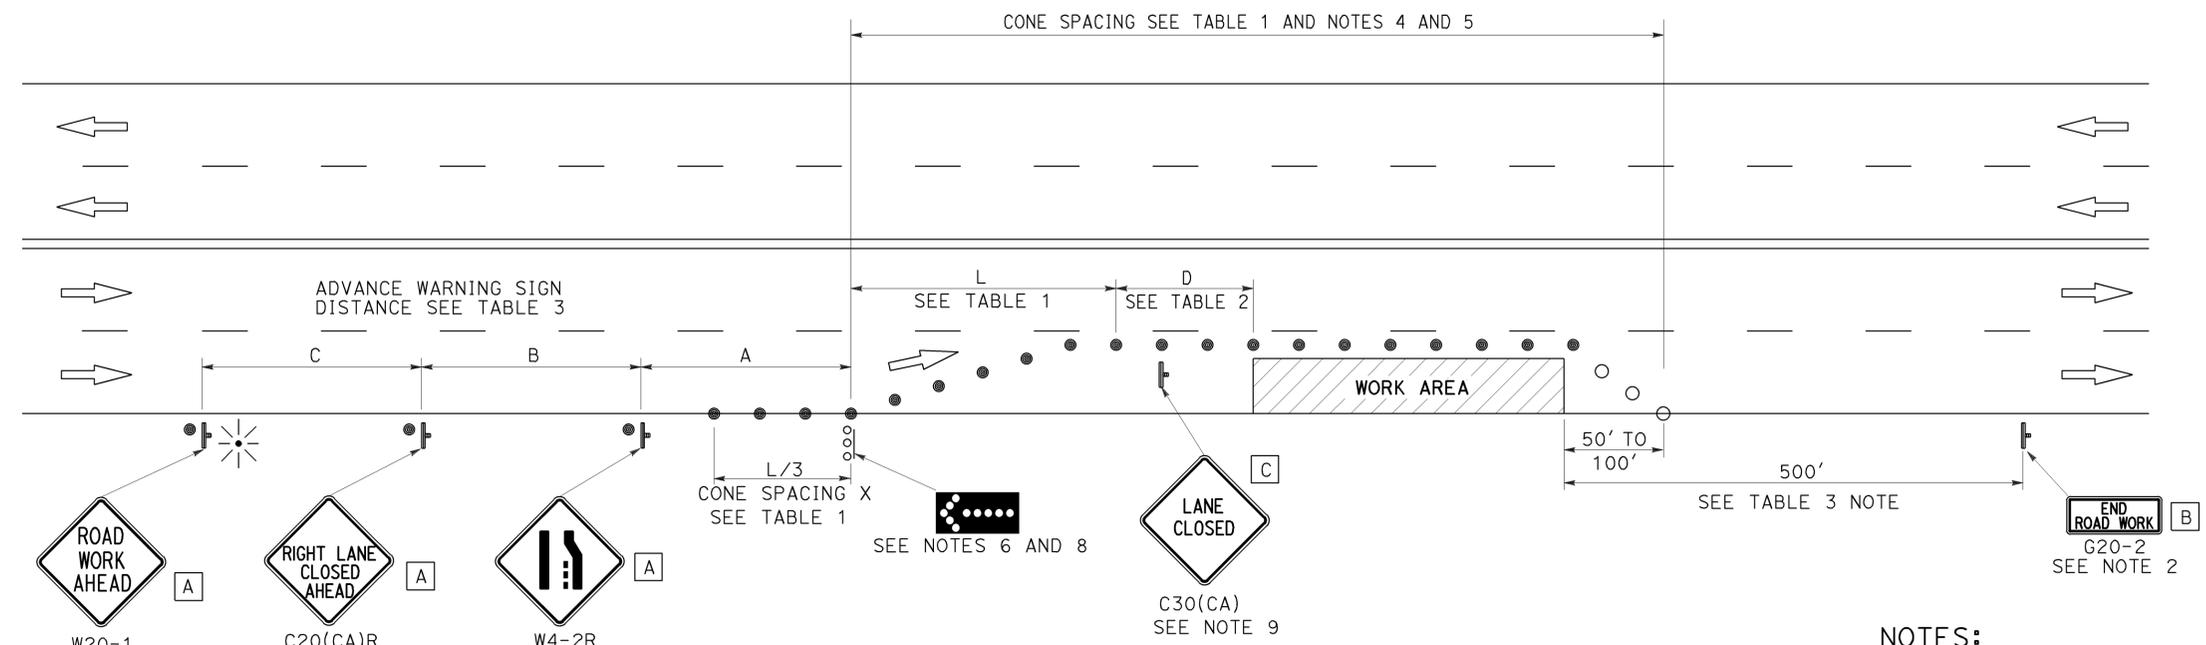

TYPICAL LANE CLOSURE

NOTES:

- See Revised Standard Plan RSP T9 for tables.
- Use cone spacing X for taper segment, Y for tangent segment or Z for conflict situations, as appropriate, per Table 1, unless X, Y, or Z cone spacing is shown on this sheet.
- Unless otherwise specified in the special provisions, all temporary warning signs shall have black legend on fluorescent orange background.
- California codes are designated by (CA). Otherwise, Federal (MUTCD) codes are shown.

NOTES:

1. Each advance warning sign shall be equipped with at least two flags for daytime closure. Each flag shall be at least 16" x 16" in size and shall be orange or fluorescent red-orange in color. Flashing beacons shall be placed at the locations indicated for lane closure during hours of darkness.
2. A G20-2 "END ROAD WORK" sign, as appropriate, shall be placed at the end of the lane closure unless the end of work area is obvious, or ends within a larger project's limits.
3. If the W20-1 sign would follow within 2000' of a stationary W20-1 or G20-1 "ROAD WORK NEXT _____ MILES", use a C20(CA) sign for the first advance warning sign.
4. All cones used for lane closures during the hours of darkness shall be fitted with retroreflective bands (or sleeves) as specified in the specifications.
5. Portable delineators, placed at one-half the spacing indicated for traffic cones, may be used instead of cones for daytime closures only.
6. Flashing arrow sign shall be either Type I or Type II.
7. For approach speeds over 50 mph, use the "Traffic Control System for Lane Closure On Freeways And Expressways" plan for lane closure details and requirements.
8. A minimum 1500' of sight distance shall be provided where possible for vehicles approaching the first flashing arrow sign. Lane closures shall not begin at the top of crest vertical curve or on a horizontal curve.
9. Place a C30(CA) sign every 2000' throughout length of lane closure.
10. Median lane closures shall conform to the details as shown except that C20(CA)L and W4-2L signs shall be used.
11. At least one person shall be assigned to provide full time maintenance of traffic control devices for lane closure unless, otherwise directed by the Engineer.

LEGEND

- TRAFFIC CONE
- TRAFFIC CONE (OPTIONAL TAPER)
- ⌋ TEMPORARY TRAFFIC CONTROL SIGN
- ⬢ FLASHING ARROW SIGN (FAS)
- σσσ FAS SUPPORT OR TRAILER
- ☀ PORTABLE FLASHING BEACON

SIGN PANEL SIZE (Min)

- A 48" x 48"
- B 36" x 18"
- C 30" x 30"

STATE OF CALIFORNIA
 DEPARTMENT OF TRANSPORTATION
**TRAFFIC CONTROL SYSTEM
 FOR LANE CLOSURE ON
 MULTILANE CONVENTIONAL
 HIGHWAYS**

NO SCALE

RSP T11 DATED APRIL 19, 2013 SUPERSEDES STANDARD PLAN T11
 DATED MAY 20, 2011 - PAGE 239 OF THE STANDARD PLANS BOOK DATED 2010.

REVISED STANDARD PLAN RSP T11

2010 REVISED STANDARD PLAN RSP T11

Dist	COUNTY	ROUTE	POST MILES TOTAL PROJECT	SHEET No.	TOTAL SHEETS
11	SD	8,15,163	Var	118	131

Devinder Singh
 REGISTERED CIVIL ENGINEER
 October 30, 2015
 PLANS APPROVAL DATE
 No. C50470
 Exp. 6-30-17
 CIVIL
 STATE OF CALIFORNIA
 THE STATE OF CALIFORNIA OR ITS OFFICERS OR AGENTS SHALL NOT BE RESPONSIBLE FOR THE ACCURACY OR COMPLETENESS OF SCANNED COPIES OF THIS PLAN SHEET.

NOTES:

See Revised Standard Plan RSP T9 for tables.



Use cone spacing X for taper segment, Y for tangent segment or Z for conflict situations, as appropriate, per Table 1, unless X, Y, or Z cone spacing is shown on this sheet.

Unless otherwise specified in the special provisions, all temporary warning signs shall have black legend on fluorescent orange background.

California codes are designated by (CA). Otherwise, Federal (MUTCD) codes are shown.

TYPICAL LANE CLOSURE WITH REVERSIBLE CONTROL

TO ACCOMPANY PLANS DATED 04-25-16

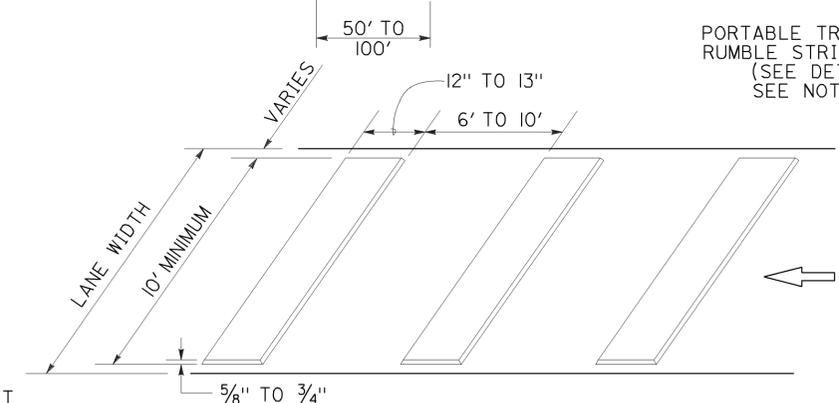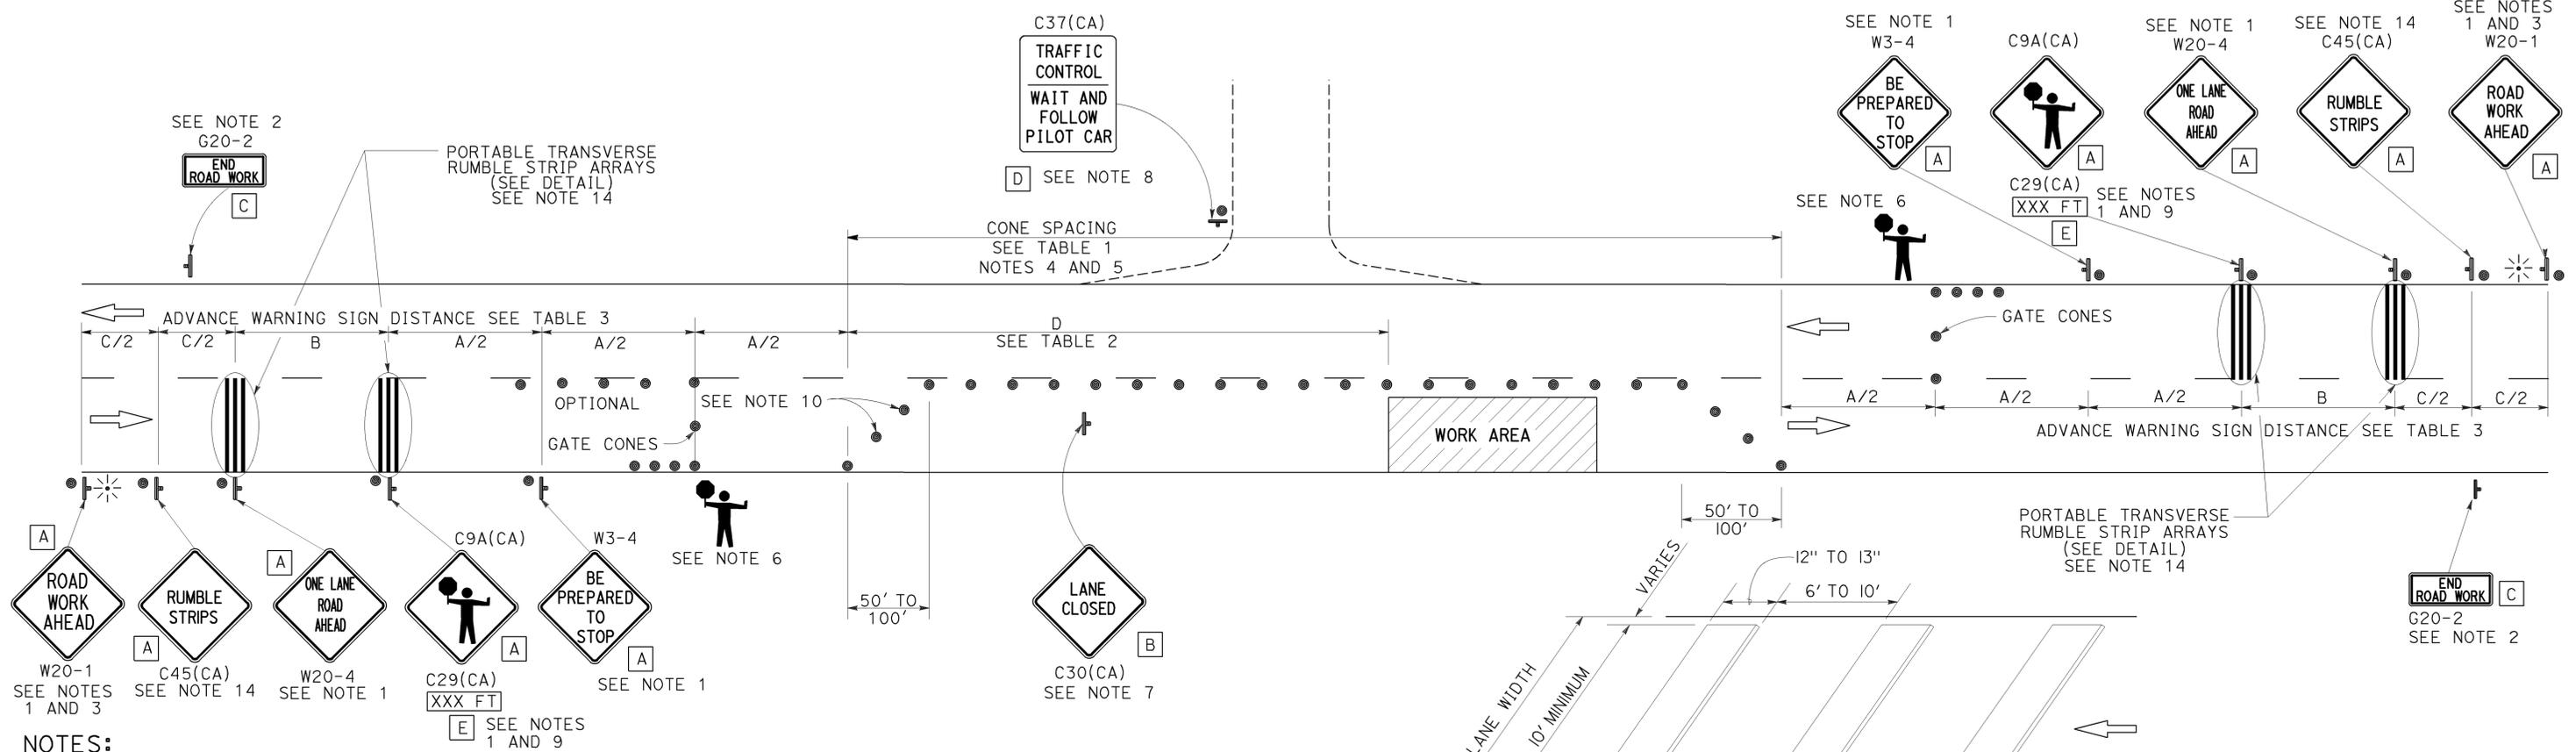

- NOTES:**
- Each advance warning sign in each direction of travel shall be equipped with at least two flags for daytime closure. Each flag shall be at least 16" x 16" in size and shall be orange or fluorescent red-orange in color. Flashing beacons shall be placed at the locations indicated for lane closure during hours of darkness.
 - A G20-2 "END ROAD WORK" sign, as appropriate, shall be placed at the end of the lane control unless the end of work area is obvious, or ends within a larger project's limits.
 - If the W20-1 sign would follow within 2000' of a stationary W20-1 or G20-1 "ROAD WORK NEXT _____ MILES", use a W20-4 sign for the first advance warning sign.
 - All cones used for lane closures during the hours of darkness shall be fitted with retroreflective bands (or sleeves) as specified in the specifications.
 - Portable delineators, placed at one-half the spacing indicated for traffic cones, may be used instead of cones for daytime closures only.
 - Additional advance flaggers may be required. Flagger should stand in a conspicuous place, be visible to approaching traffic as well as approaching vehicles after the first vehicle has stopped. During the hours of darkness, the flagging-station and flagger shall be illuminated and clearly visible to approaching traffic. The illumination footprint of the lighting on the ground shall be at least 20' in diameter. Place a minimum of four cones at 50' intervals in advance of flagger station as shown.

- Place C30(CA) "LANE CLOSED" sign at 500' to 1000' intervals throughout extended work areas. They are optional if the work area is visible from the flagger station.
- When a pilot car is used, place a C37(CA) "TRAFFIC CONTROL-WAIT AND FOLLOW PILOT CAR" sign with black legend on white background at all intersections, driveways and alleys without a flagger within traffic control area. Signs shall be clean and visible at all times. Where traffic can not be effectively self-regulated, at least one flagger shall be used at each intersection within traffic control area.
- An optional C29(CA) sign may be placed below the C9A(CA) sign.
- Either traffic cones or barricades shall be placed on the taper. Barricades shall be Type I, II, or III.
- The color of the portable transverse rumble strips shall be black or orange. Use 2 arrays, each array shall consist of 3 rumble strips.
- Portable transverse rumble strips shall not be placed on sharp horizontal or vertical curves nor shall they be placed through pedestrian crossings.
- If the portable transverse rumble strips become out of alignment (skewed) by more than 6 inches, measured from one end to the other, they shall be readjusted to bring the placement back to the original location.
- Portable transverse rumble strips are not required if any one of the following conditions is satisfied:
 - Work duration occupies a location for four hours or less
 - Posted speed limit is below 45 MPH
 - Work is of emergency nature
 - Work zone is in snow or icy weather conditions

SIGN PANEL SIZE (Min)

- A 48" x 48"
- B 30" x 30"
- C 36" x 18"
- D 36" x 42"
- E 20" x 7"

LEGEND

- TRAFFIC CONE
- ⊥ TEMPORARY TRAFFIC CONTROL SIGN
- ⚡ PORTABLE FLASHING BEACON
- 🚧 FLAGGER

STATE OF CALIFORNIA
DEPARTMENT OF TRANSPORTATION

**TRAFFIC CONTROL SYSTEM
FOR LANE CLOSURE ON
TWO LANE CONVENTIONAL
HIGHWAYS**

NO SCALE

RSP T13 DATED OCTOBER 30, 2015 SUPERSEDES
RSP T13 DATED OCTOBER 17, 2014, RSP T13 DATED JULY 18, 2014
AND RSP T13 DATED APRIL 19, 2013 AND STANDARD PLAN T13 DATED
MAY 20, 2011 - PAGE 241 OF THE STANDARD PLANS BOOK DATED 2010.

REVISED STANDARD PLAN RSP T13

2010 REVISED STANDARD PLAN RSP T13

TYPICAL RAMP CLOSURES

SIGN PANEL SIZE (Min)

- A 48" x 48"
- B 48" x 30"
- C 36" x 36"
- D 48" x 36"

LEGEND

- TRAFFIC CONE
- † TEMPORARY TRAFFIC CONTROL SIGN
- ‡ BARRICADES
- ⚡ PORTABLE FLASHING BEACON

Dist	COUNTY	ROUTE	POST MILES TOTAL PROJECT	SHEET No.	TOTAL SHEETS
11	SD	8,15,163	Var	119	131


Gurinderpal Bhullar
 REGISTERED CIVIL ENGINEER
 April 19, 2013
 PLANS APPROVAL DATE
THE STATE OF CALIFORNIA OR ITS OFFICERS OR AGENTS SHALL NOT BE RESPONSIBLE FOR THE ACCURACY OR COMPLETENESS OF SCANNED COPIES OF THIS PLAN SHEET.

REGISTERED PROFESSIONAL ENGINEER
Gurinderpal Bhullar
 No. C48815
 Exp. 9-30-14
 CIVIL
 STATE OF CALIFORNIA


TO ACCOMPANY PLANS DATED 04-25-16

NOTES:


- Barricades shall be Type I, II, or III for closures lasting one week or less and Type III for closures lasting longer than one week.
- In addition to placing the C19(CA) "RAMP CLOSED AHEAD" and C30(CA) "RAMP CLOSED" signs, black on orange overlay plates with the word "CLOSED" may be mounted, as directed by the Engineer, on all guide signs that refer to the closed ramp. The letter size on the overlay shall be the same as the guide sign.
- Each advance C19(CA) "RAMP CLOSED AHEAD" sign shall be equipped with at least two flags for daytime closure. Each flag shall be at least 16" x 16" in size and shall be orange or fluorescent red-orange in color. A flashing beacon shall be placed on top of the first C19(CA) sign during hours of darkness.
- All cones used for ramp closures during the hours of darkness shall be fitted with retroreflective bands (or sleeves) as specified in the specifications.
- Portable delineators, placed at one-half the spacing indicated for traffic cones, may be used instead of cones for daytime ramp closures only.
- At least one person shall be assigned to provide full time maintenance of traffic control devices, unless otherwise directed by the Engineer.
- The existing "EXIT" signs shall be covered during ramp closures.
- A minimum of 3 cones shall be placed transversely across each closed lane and shoulder.

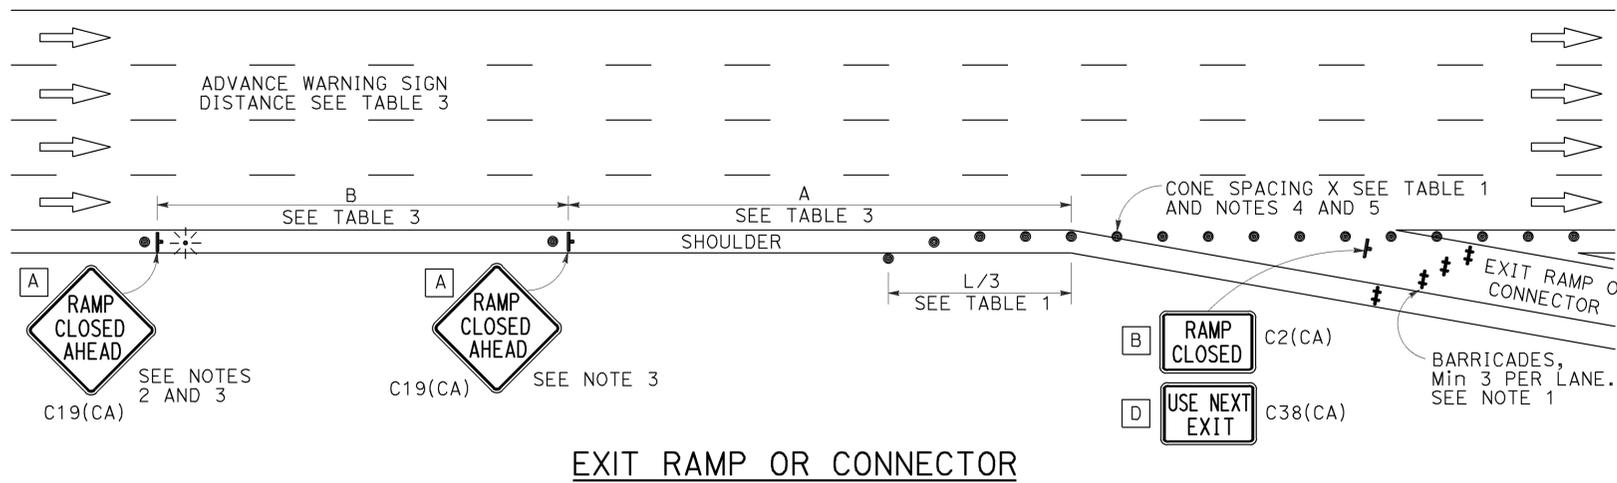


EXIT RAMP OR CONNECTOR

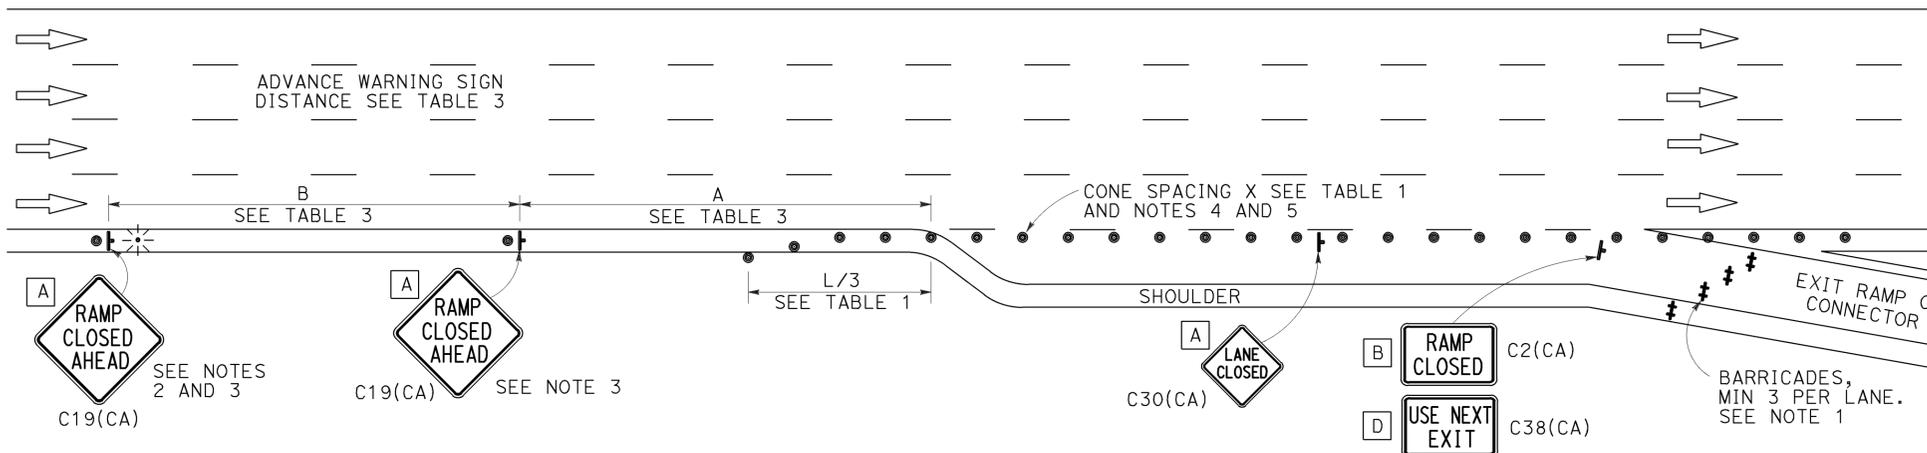

EXIT RAMP OR CONNECTOR WITH ADDITIONAL LANE

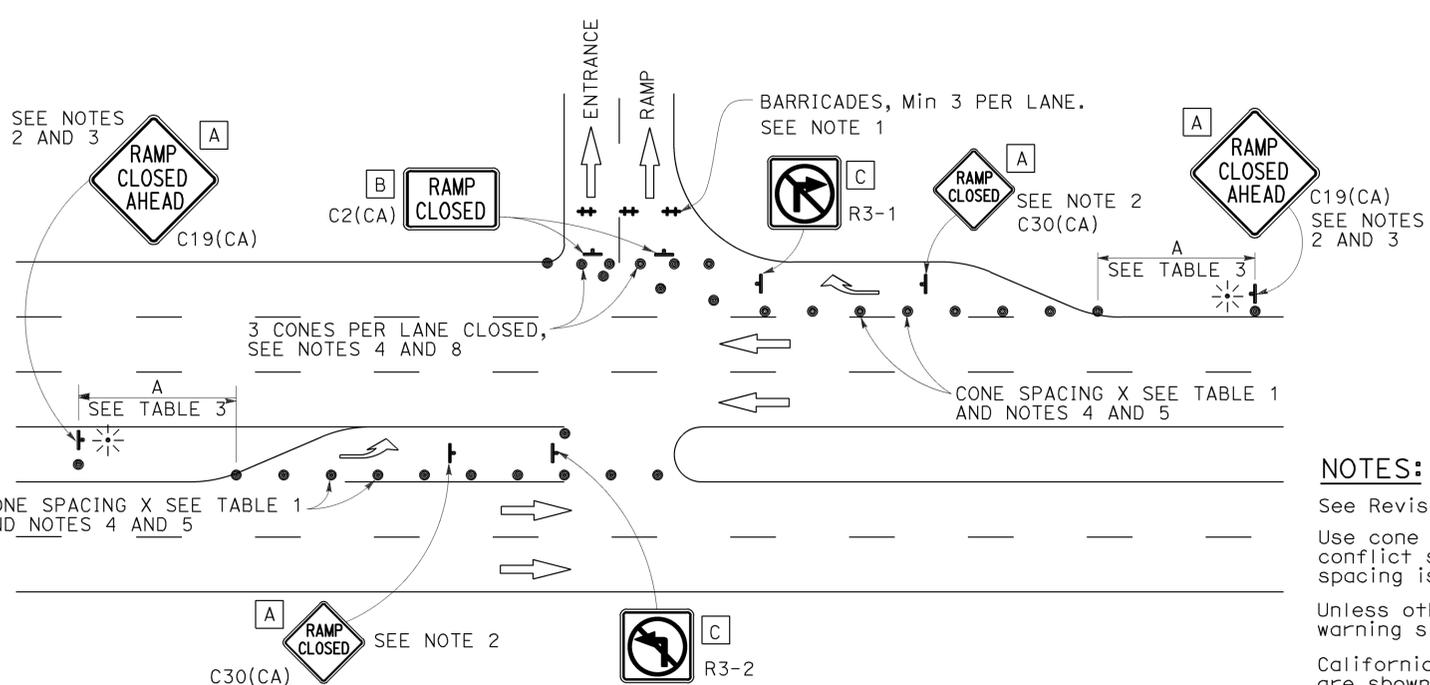

ENTRANCE RAMP WITH TURNING POCKETS

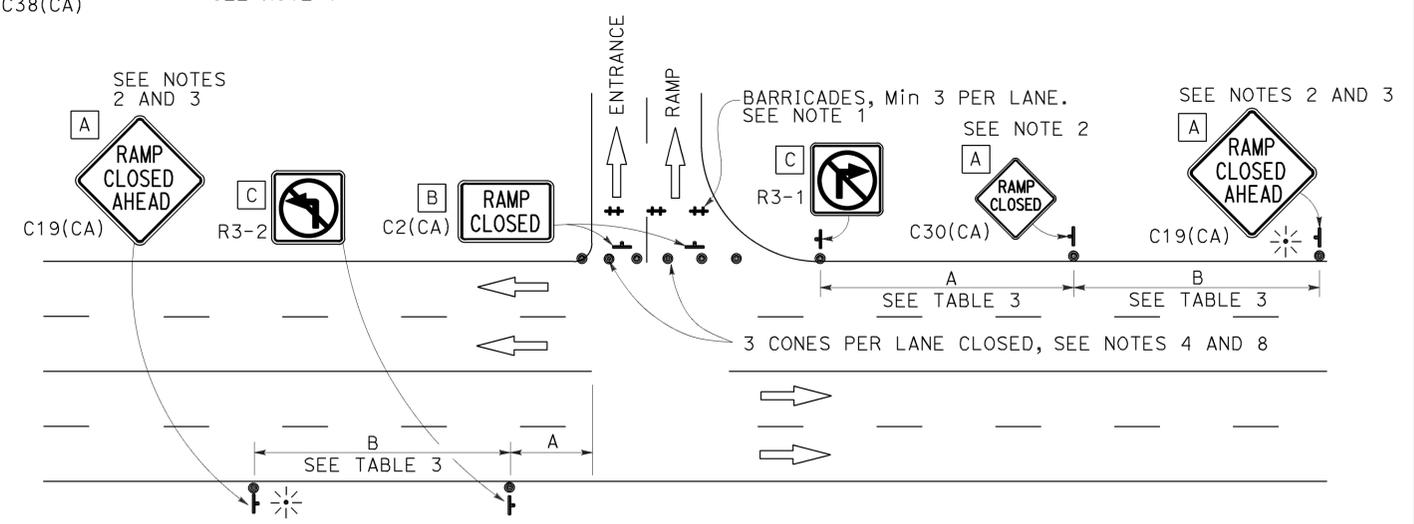

ENTRANCE RAMP WITHOUT TURNING POCKETS

NOTES:

- See Revised Standard Plan RSP T9 for tables.
- Use cone spacing X for taper segment, Y for tangent segment or Z for conflict situations, as appropriate, per Table 1, unless X, Y, or Z cone spacing is shown on this sheet.
- Unless otherwise specified in the special provisions, all temporary warning signs shall have black legend on fluorescent orange background.
- California codes are designated by (CA). Otherwise, Federal (MUTCD) codes are shown.

STATE OF CALIFORNIA
 DEPARTMENT OF TRANSPORTATION
**TRAFFIC CONTROL SYSTEM
 FOR RAMP CLOSURE**
 NO SCALE

RSP T14 DATED APRIL 19, 2013 SUPERSEDES STANDARD PLAN T14
 DATED MAY 20, 2011 - PAGE 242 OF THE STANDARD PLANS BOOK DATED 2010.
REVISED STANDARD PLAN RSP T14

2010 REVISED STANDARD PLAN RSP T14

LEGEND:

AB	ABANDON. IF APPLIED TO CONDUIT, REMOVE CONDUCTORS
BC	INSTALL PULL BOX IN EXISTING CONDUIT RUN
BP	PEDESTRIAN BARRICADE, TYPE AS INDICATED ON PLAN
CB	INSTALL CONDUIT INTO EXISTING PULL BOX
CC	CONNECT NEW AND EXISTING CONDUIT. REMOVE EXISTING CONDUCTORS AND INSTALL CONDUCTORS AS INDICATED
CF	CONDUIT TO REMAIN FOR FUTURE USE. REMOVE CONDUCTORS. INSTALL PULL TAPE
DH	DETECTOR HANDHOLE
FA	FOUNDATION TO BE ABANDONED
IS	INSTALL SIGN ON SIGNAL MAST ARM
NS	NO SLIP BASE ON STANDARD
PEC	PHOTOELECTRIC CONTROL
PEU	PHOTOELECTRIC UNIT
RC	EQUIPMENT OR MATERIAL TO BE REMOVED AND BECOME THE PROPERTY OF THE CONTRACTOR
RE	REMOVE ELECTROLIER, FUSES AND BALLAST. TAPE ENDS OF CONDUCTORS
RL	RELOCATE EQUIPMENT
RR	REMOVE AND REUSE EQUIPMENT
RS	REMOVE AND SALVAGE EQUIPMENT
SC	SPLICE NEW TO EXISTING CONDUCTORS
SD	SERVICE DISCONNECT
TSP	TELEPHONE SERVICE POINT

ABBREVIATIONS

AC+	UNDERGROUNDED CONDUCTOR	MAT	MAST ARM MOUNTING TOP ATTACHMENT
APS	ACCESSIBLE PEDESTRIAN SIGNAL	MAS	MAST ARM MOUNTING SIDE ATTACHMENT
Batt	BATTERY	MBPS	MANUAL BYPASS SWITCH
BBS	BATTERY BACKUP SYSTEM	M/M	MULTIPLE TO MULTIPLE TRANSFORMER
BC	BOLT CIRCLE	Mtg	MOUNTING
BIK	BLACK	MV	MERCURY VAPOR LIGHTING FIXTURE
BP	BYPASS	MVDS	MICROWAVE VEHICLE DETECTION SYSTEM
BPB	BICYCLE PUSH BUTTON	N	NEUTRAL (GROUNDED CONDUCTOR)
C	CONDUIT	NB	NEUTRAL BUS
CB	CIRCUIT BREAKER	NC	NORMALLY CLOSE
CCTV	CLOSED CIRCUIT TELEVISION	NO	NORMALLY OPEN
Ckt	CIRCUIT	P	CIRCUIT BREAKER'S POLE
CMS	CHANGEABLE MESSAGE SIGN	PB	PULL BOX
Ctid	CALTRANS IDENTIFICATION	PBA	PUSH BUTTON ASSEMBLY
Comm	COMMUNICATION	PEC	PHOTOELECTRIC CONTROL
Cn+l	CONTROL	Ped	PEDESTRIAN
DF	DEPARTMENT-FURNISHED	PEU	PHOTOELECTRIC UNIT
DLC	LOOP DETECTOR LEAD-IN CABLE	PT	CONDUIT WITH PULL TAPE
EMS	EXTINGUISHABLE MESSAGE SIGN	PTR	POWER TRANSFER RELAY
EVUC	EMERGENCY VEHICLE UNIT CABLE	RE	RELOCATED EQUIPMENT
EVUD	EMERGENCY VEHICLE UNIT DETECTOR	RM	RAMP METERING
FB	FLASHING BEACON	RWIS	ROADSIDE WEATHER INFORMATION SYSTEM
FBCA	FLASHING BEACON CONTROL ASSEMBLY	SB	SLIP BASE
FBS	FLASHING BEACON WITH SLIP BASE	SIC	SIGNAL INTERCONNECT CABLE
FO	FIBER OPTIC	Sig	SIGNAL
G	EQUIPMENT GROUNDING CONDUCTOR	SMA	SIGNAL MAST ARM
GB	GROUND BUS	SNS	STREET NAME SIGN
GFCI	GROUND FAULT CIRCUIT INTERRUPTER	SP	SERVICE POINT
Grn	GREEN	TB	TERMINAL BOARD
HAR	HIGHWAY ADVISORY RADIO	TDC	TELEPHONE DEMARCATION CABINET
Hex	HEXAGONAL	Temp	TEMPERATURE
HPS	HIGH PRESSURE SODIUM	TMS	TRAFFIC MONITORING STATION
IISNS	INTERNALLY ILLUMINATED STREET NAME SIGN	TOS	TRAFFIC OPERATIONS SYSTEM
ISL	INDUCTION SIGN LIGHTING	UPS	UNINTERRUPTABLE POWER SUPPLY
LED	LIGHT EMITTING DIODE	UPSC	UNINTERRUPTABLE POWER SUPPLY CONTROLLER
LMA	LUMINAIRE MAST ARM	Veh	VEHICLE
LPS	LOW PRESSURE SODIUM	VIVDS	VIDEO IMAGE VEHICLE DETECTION SYSTEM
Ltg	LIGHTING	Wht	WHITE
Lum	LUMINAIRE	WIM	WEIGH-IN-MOTION
M	METERED	Xfmr	TRANSFORMER

Dist	COUNTY	ROUTE	POST MILES TOTAL PROJECT	SHEET No.	TOTAL SHEETS
11	SD	8,15,163	Var	120	131

Theresa Gabriel
REGISTERED ELECTRICAL ENGINEER

October 30, 2015
PLANS APPROVAL DATE

Theresa
Aziz Gabriel
No. E15129
Exp. 6-30-16
ELECTRICAL
STATE OF CALIFORNIA

THE STATE OF CALIFORNIA OR ITS OFFICERS OR AGENTS SHALL NOT BE RESPONSIBLE FOR THE ACCURACY OR COMPLETENESS OF SCANNED COPIES OF THIS PLAN SHEET.

TO ACCOMPANY PLANS DATED 04-25-16

SOFFIT AND WALL-MOUNTED LUMINAIRES

- PENDANT SOFFIT LUMINAIRE, 70 W HPS UNLESS OTHERWISE SPECIFIED
- FLUSH-MOUNTED SOFFIT LUMINAIRE, 70 W HPS UNLESS OTHERWISE SPECIFIED
- WALL-MOUNTED LUMINAIRE, 70 W HPS UNLESS OTHERWISE SPECIFIED
- EXISTING SOFFIT OR WALL-MOUNTED LUMINAIRE TO REMAIN UNMODIFIED
- EXISTING SOFFIT OR WALL-MOUNTED LUMINAIRE TO BE MODIFIED AS SPECIFIED

NOTE:
Arrow indicates "street side" of luminaire.

COMMONLY USED SYMBOLS FOR UNITED STATES CUSTOMARY UNITS OF MEASUREMENT:

SYMBOL	DEFINITIONS
Ω	OHMS
min	MINUTE
s	SECOND
bps	BITS PER SECOND
Bps	BYTES PER SECOND
A	AMPERE
V	VOLT
V(dc)	VOLT (DIRECT CURRENT)
V(ac)	VOLT (ALTERNATING CURRENT)
FC	FOOT - CANDLE
W	WATTS
VA	VOLT-AMPERE
M	MEGA
k	KILO
m	MILLI
μ	MICRO
P	PICO
Hz	HERTZ

MISCELLANEOUS ELECTROLIERS

NEW	EXISTING	
		LUMINAIRE ON WOOD POLE
		NON-STANDARD ELECTROLIER (SEE PROJECT LEGEND)
		CITY ELECTROLIER
		ELECTROLIER FOUNDATION (FUTURE INSTALLATION)

- NOTES:**
- LED luminaires shall be 235 W when installed on Type 21, 21D, 30, 31 and 32 Standards, unless otherwise specified. LED luminaires shall be 165 W when installed on other type standards or poles, unless otherwise specified.
 - Luminaires shall be the cutoff type, ANSI Type III medium cutoff lighting distribution, unless otherwise specified.

STANDARD ELECTROLIER

NEW	EXISTING	STANDARD TYPE
		15
		15D
		15 STRUCTURE
		15D STRUCTURE
		21
		21D
		21 STRUCTURE
		21D STRUCTURE
		30
		31
		32

STATE OF CALIFORNIA
DEPARTMENT OF TRANSPORTATION

ELECTRICAL SYSTEMS (LEGEND AND ABBREVIATIONS)

NO SCALE

RSP ES-1A DATED OCTOBER 30, 2015 SUPERSEDES RSP ES-1A DATED JULY 19, 2013 AND STANDARD PLAN ES-1A DATED MAY 20, 2011 - PAGE 425 OF THE STANDARD PLANS BOOK DATED 2010.

REVISED STANDARD PLAN RSP ES-1A

2010 REVISED STANDARD PLAN RSP ES-1A

Dist	COUNTY	ROUTE	POST MILES TOTAL PROJECT	SHEET No.	TOTAL SHEETS
11	SD	8,15,163	Var	121	131

Theresa Gabriel
 REGISTERED ELECTRICAL ENGINEER
 October 30, 2015
 PLANS APPROVAL DATE
THE STATE OF CALIFORNIA OR ITS OFFICERS OR AGENTS SHALL NOT BE RESPONSIBLE FOR THE ACCURACY OR COMPLETENESS OF SCANNED COPIES OF THIS PLAN SHEET.

TO ACCOMPANY PLANS DATED 04-25-16

CONDUIT

SIGNAL EQUIPMENT

NEW	EXISTING	
---	---	LIGHTING CONDUIT, UNLESS OTHERWISE INDICATED OR NOTED
---	---	TRAFFIC SIGNAL CONDUIT
---C---	---c---	COMMUNICATION CONDUIT
---T---	---t---	TELEPHONE CONDUIT
---F---	---f---	FIRE ALARM CONDUIT
---FO---	---fo---	FIBER OPTIC CONDUIT
---	---	CONDUIT TERMINATION
		CONDUIT RISER ATTACHED TO THE STRUCTURE OR SERVICE POLE

NEW	EXISTING	
		PEDESTRIAN SIGNAL HEAD
		PUSH BUTTON ASSEMBLY POST
		PEDESTRIAN BARRICADE
		VEHICLE SIGNAL HEAD (WITH BACKPLATE AND 3-SECTIONS: RED, YELLOW AND GREEN)
		VEHICLE SIGNAL HEAD WITH ANGLE VISOR
		MODIFICATIONS OF BASIC SYMBOL: "L" INDICATES ALL NON-ARROW SECTIONS LOUVERED "LG" INDICATES LOUVERED GREEN SECTION ONLY "PV" INDICATES ALL 12" SECTIONS PROGRAMMED VISIBILITY "8" INDICATES ALL 8" SECTIONS (ONLY WHEN SPECIFIED)

SIGNAL EQUIPMENT Cont

NEW	EXISTING	
		GUARD POST
		TYPE 1 STANDARD WITH RAMP METERING SIGN
		OPTICAL DETECTOR FOR THE EMERGENCY VEHICLE DETECTION

SERVICE EQUIPMENT


NEW	EXISTING	
---OH---	---oh---	OVERHEAD LINES
		WOOD POLE, "U" INDICATES UTILITY OWNED
		POLE GUY WITH ANCHOR
		UTILITY TRANSFORMER - GROUND MOUNTED
		SERVICE EQUIPMENT ENCLOSURE TYPE. DOOR INDICATES FRONT OF ENCLOSURE
		TELEPHONE DEMARCATION CABINET

		VEHICLE SIGNAL HEAD CONSISTING OF RED, YELLOW AND GREEN LEFT ARROW SECTIONS
		VEHICLE SIGNAL HEAD CONSISTING OF RED AND YELLOW SECTIONS WITH AN UP GREEN ARROW SECTION
		VEHICLE SIGNAL HEAD (5 SECTION) CONSISTING OF RED, YELLOW AND GREEN SECTIONS WITH YELLOW AND GREEN RIGHT ARROW SECTIONS
		TYPE 15TS STANDARD WITH VEHICLE SIGNAL HEAD AND LUMINAIRE
		TYPE 21TS STANDARD WITH VEHICLE SIGNAL HEAD AND LUMINAIRE
		STANDARD WITH LUMINAIRE AND SIGNAL MAST ARMS AND ATTACHED VEHICLE SIGNAL HEADS
		TYPE 1 STANDARD WITH ATTACHED VEHICLE SIGNAL HEADS
		STANDARD WITH A SIGNAL MAST ARM, ATTACHED VEHICLE SIGNAL HEADS AND INTERNALLY ILLUMINATED STREET NAME SIGN
		CONTROLLER ASSEMBLY. DOOR INDICATES FRONT OF CABINET

NOTES:

- All signal sections shall be 12" unless shown otherwise.
- Signal heads shall be provided with backplates unless shown otherwise.

 POLE-MOUNTED SERVICE DESIGNATION



FLASHING BEACON

NEW	EXISTING	
		FLASHING BEACON (ONE VEHICLE SIGNAL HEAD WITH BACKPLATE AND VISOR) "R" INDICATES RED INDICATION, "Y" INDICATES YELLOW INDICATION
		FLASHING BEACON WITH TYPE 15-FBS STANDARD AND A SIGN.
		FLASHING BEACON WITH TYPES 9, 9A OR 9B SIGN UNLESS OTHERWISE SPECIFIED OR INDICATED

ILLUMINATED OVERHEAD SIGN

NEW	EXISTING	
		SINGLE POST, SINGLE ILLUMINATED SIGN, BALANCED BUTTERFLY
		SINGLE POST, DOUBLE ILLUMINATED SIGN, BALANCED BUTTERFLY
		SINGLE POST, SINGLE ILLUMINATED SIGN, FULL CANTILEVER
		DOUBLE POST, SINGLE ILLUMINATED SIGN
		SINGLE ILLUMINATED SIGN MOUNTED ON STRUCTURE
		DOUBLE POST, SINGLE ILLUMINATED SIGN WITH ELECTROLIER

STATE OF CALIFORNIA
 DEPARTMENT OF TRANSPORTATION
**ELECTRICAL SYSTEMS
 (LEGEND AND ABBREVIATIONS)**

NO SCALE

RSP ES-1B DATED OCTOBER 30, 2015 SUPERSEDES RSP ES-1B DATED JULY 19, 2013 AND STANDARD PLAN ES-1B DATED MAY 20, 2011 - PAGE 426 OF THE STANDARD PLANS BOOK DATED 2010.

REVISED STANDARD PLAN RSP ES-1B


2010 REVISED STANDARD PLAN RSP ES-1B




TO ACCOMPANY PLANS DATED 04-25-16

EQUIPMENT IDENTIFICATION


ILLUMINATED SIGN IDENTIFICATION NUMBER:

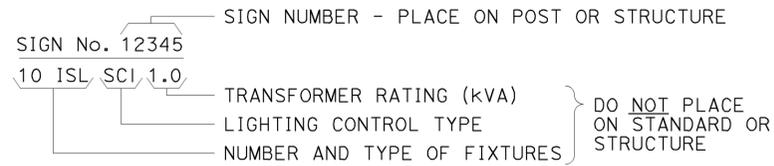


ELECTROLIER OR EQUIPMENT IDENTIFICATION NUMBER:

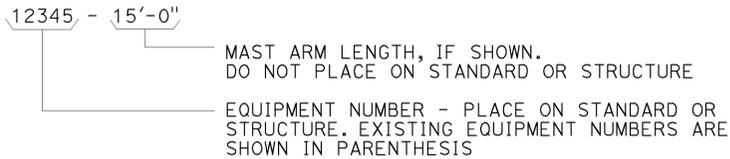


CONDUIT AND CONDUCTOR IDENTIFICATION:

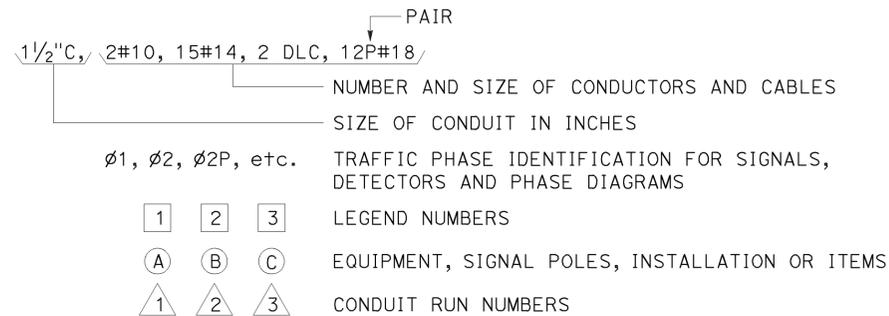


SIGNAL AND LIGHTING STANDARD (TYPICAL DESIGNATION):

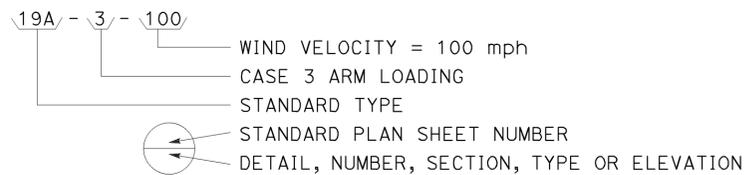


MISCELLANEOUS EQUIPMENT

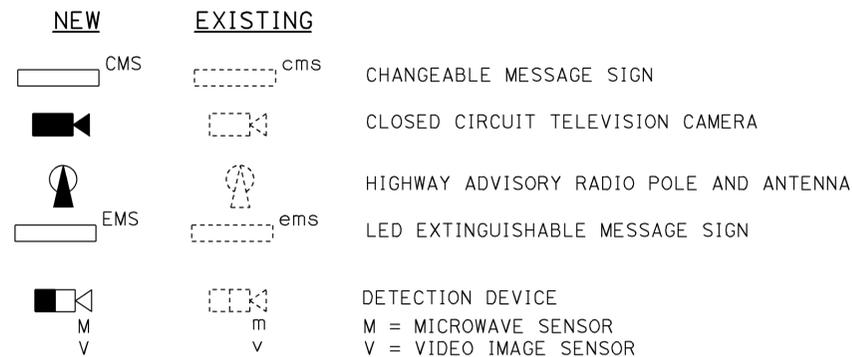



WIRING DIAGRAM LEGEND

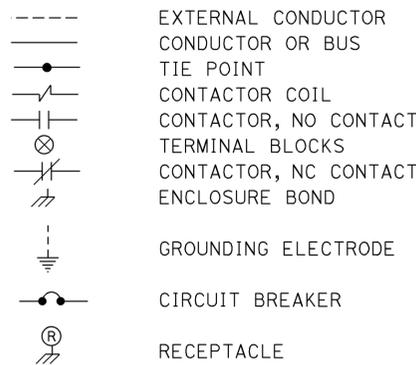

PULL BOXES

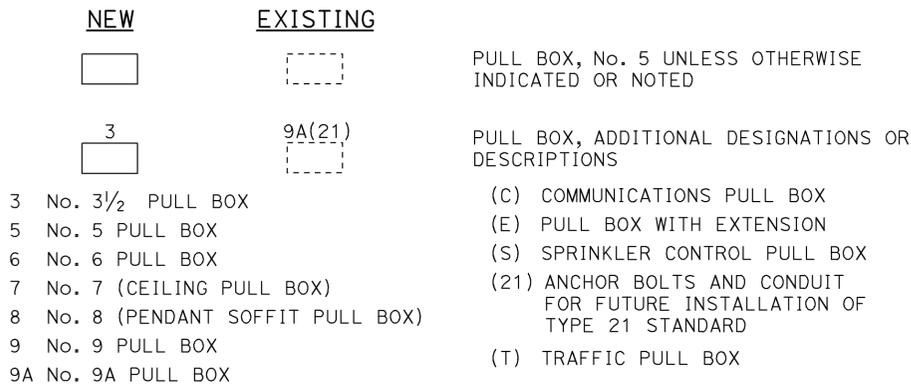

VEHICLE DETECTORS

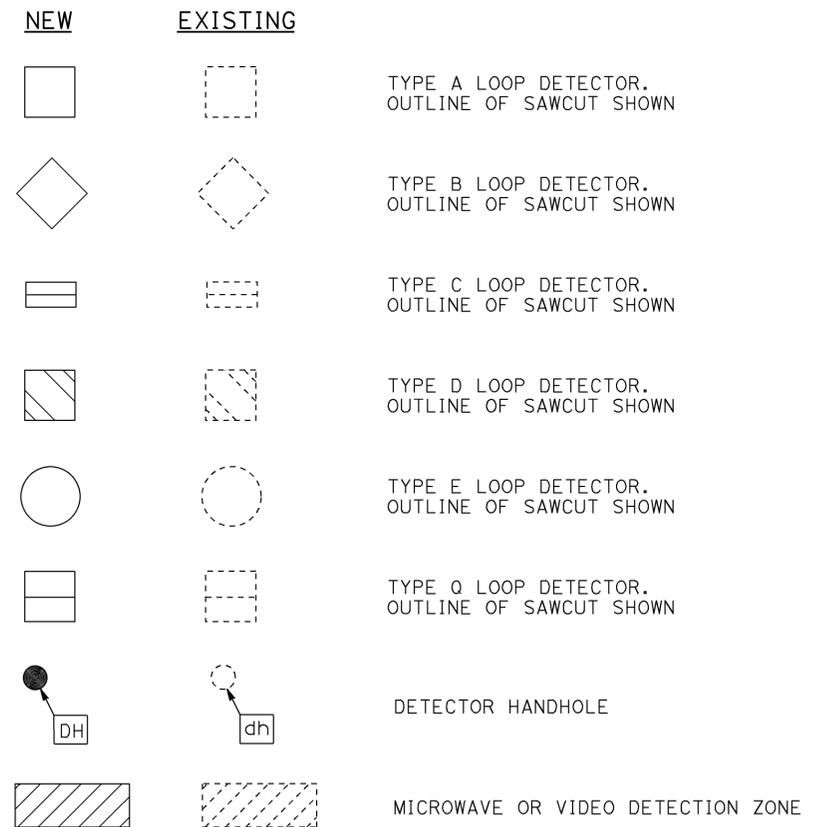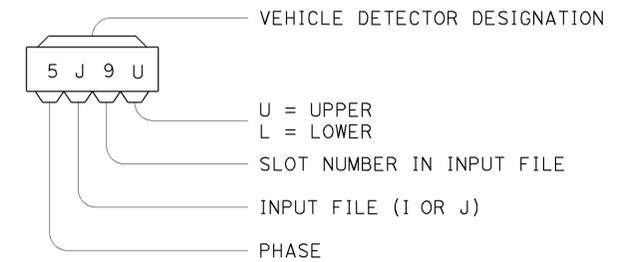

STATE OF CALIFORNIA
 DEPARTMENT OF TRANSPORTATION

ELECTRICAL SYSTEMS (LEGEND AND ABBREVIATIONS)

NO SCALE

RSP ES-1C DATED OCTOBER 30, 2015 SUPERSEDES RSP ES-1C DATED JULY 19, 2013 AND STANDARD PLAN ES-1C DATED MAY 20, 2011 - PAGE 427 OF THE STANDARD PLANS BOOK DATED 2010.

REVISED STANDARD PLAN RSP ES-1C

2010 REVISED STANDARD PLAN RSP ES-1C

NOTES:

1. Foundation shall be located to provide 2'-0" minimum clearance between face of curb and any portion of cabinet.
2. Controller units, plug-mounted equipment, shelf-mounted equipment and wall-mounted equipment shall be located to permit safe and easy removal or replacement without removing any other piece of equipment.
3. Cabinet fan may be installed at an alternate location near the top of the cabinet when approved by the Engineer.
4. Where telephone interconnect is required, a minimum of 5" clear vertical space shall be provided inside the cabinet for the equipment.
5. Telephone interconnect conductors shall be enclosed in a 3/4" or larger conduit through the foundation. Type 4 conduit shall be used to separate telephone and power conductors in cabinets.

Dist	COUNTY	ROUTE	POST MILES TOTAL PROJECT	SHEET No.	TOTAL SHEETS
11	SD	8,15,163	Var	123	131

Theresa Gabriel
REGISTERED ELECTRICAL ENGINEER

October 30, 2015
PLANS APPROVAL DATE

THE STATE OF CALIFORNIA OR ITS OFFICERS OR AGENTS SHALL NOT BE RESPONSIBLE FOR THE ACCURACY OR COMPLETENESS OF SCANNED COPIES OF THIS PLAN SHEET.

TO ACCOMPANY PLANS DATED 04-25-16

REGISTERED PROFESSIONAL ENGINEER


Theresa Aziz Gabriel

No. E15129


Exp. 6-30-16

ELECTRICAL


STATE OF CALIFORNIA

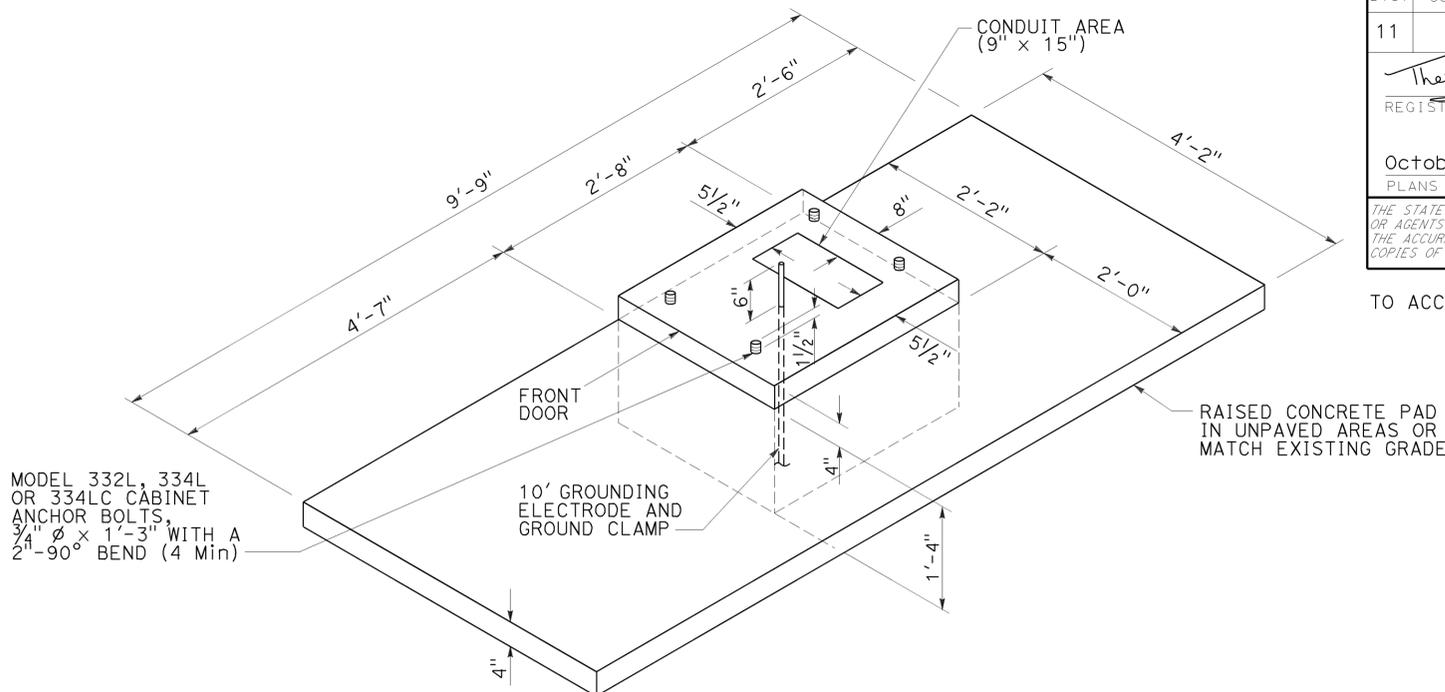

FOUNDATION AND PAD DETAIL
Model 332L, 334L and 334LC

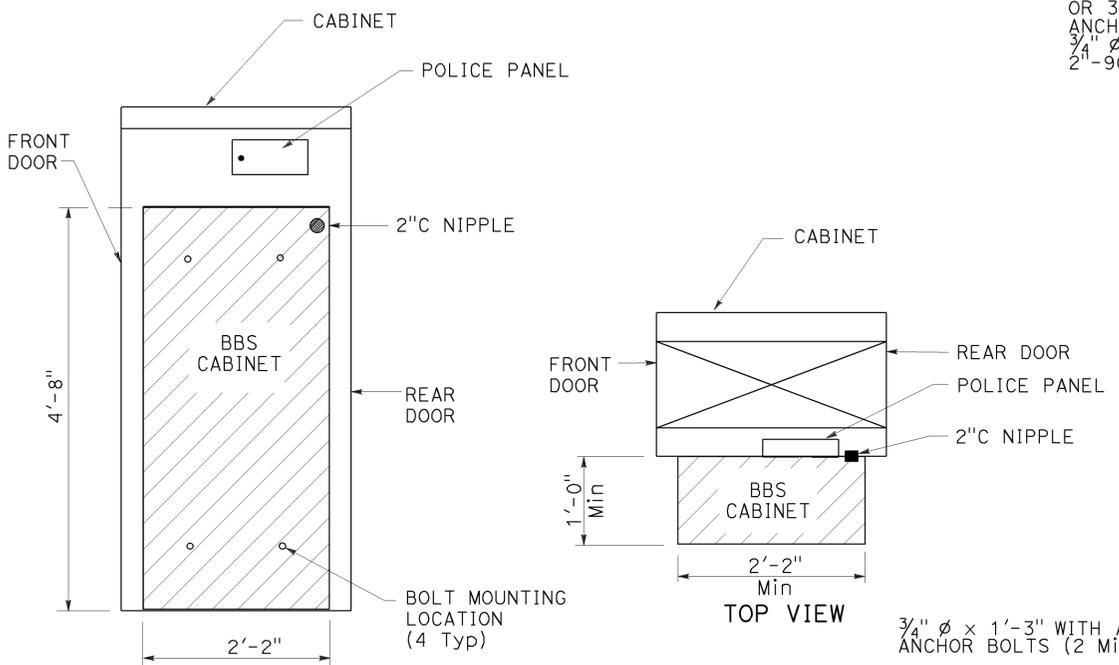


BBS CABINET MOUNTED TO THE MODEL 332L CABINET

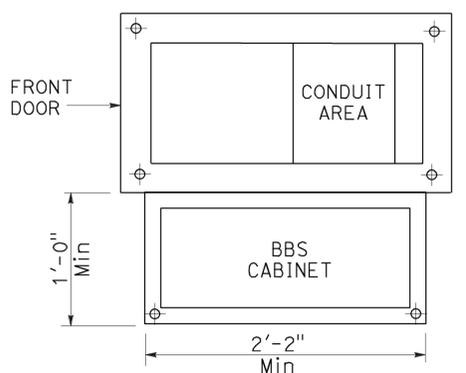


BASE PLAN FOR BBS MOUNTED TO THE MODEL 332L CABINET

(FOR DIMENSIONS AND DETAILS NOT SHOWN, SEE CABINET HOUSING DETAILS OF THE TRANSPORTATION ELECTRICAL EQUIPMENT SPECIFICATION (TEES))

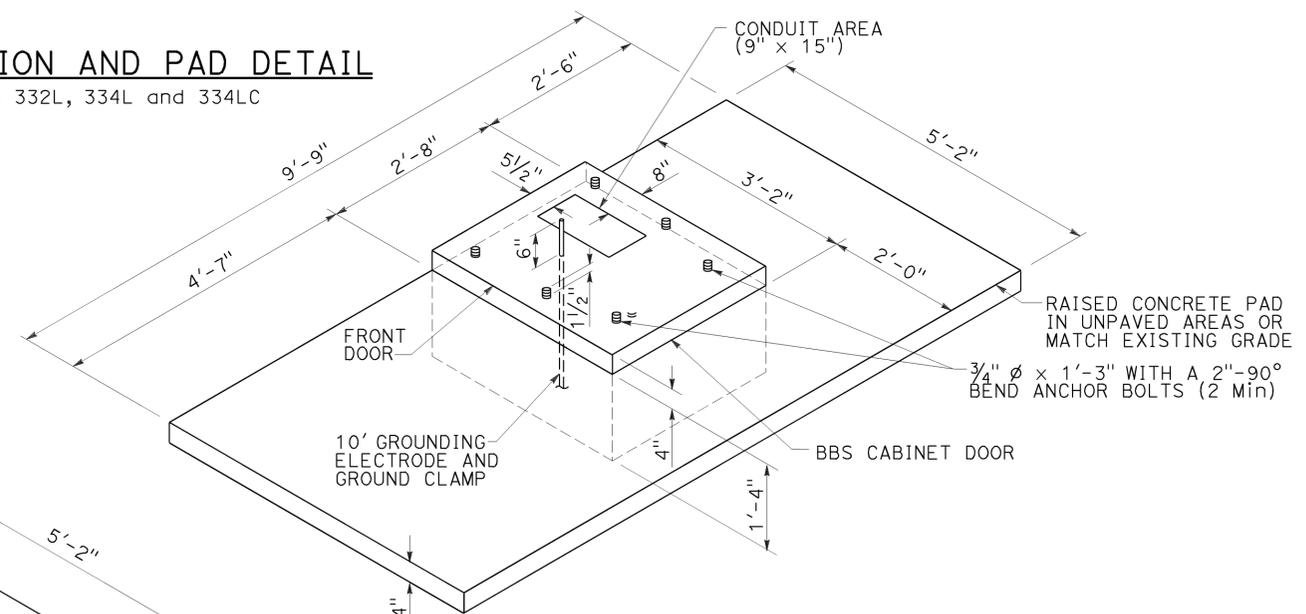

RIGHT SIDE INSTALLATION
DETAIL B

MODIFIED MODEL 332L CABINET
FOUNDATION DETAIL FOR BATTERY BACKUP SYSTEM

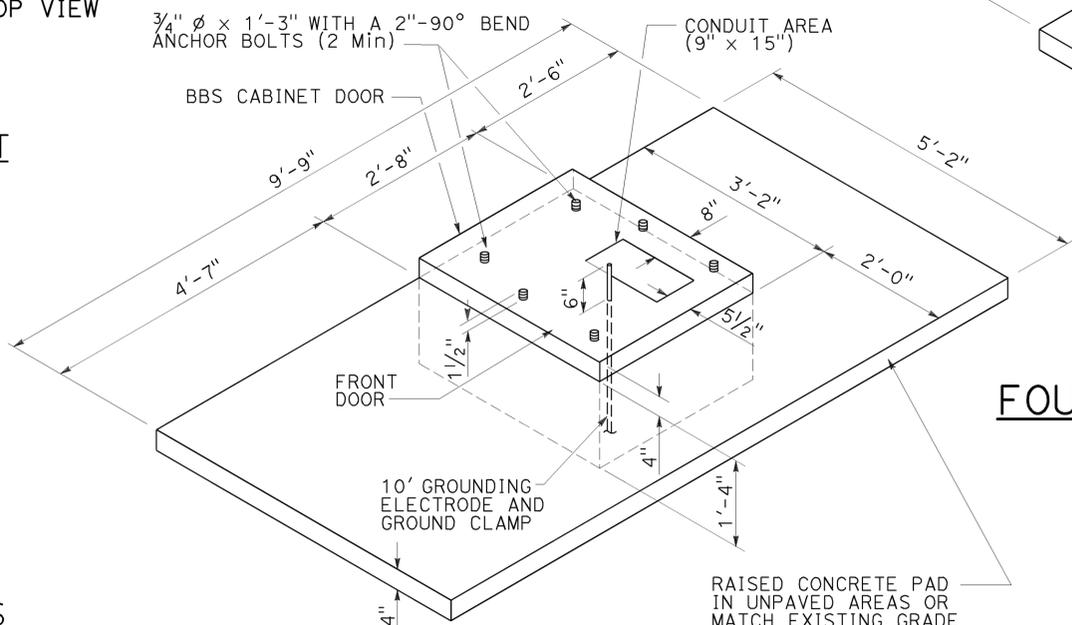

LEFT SIDE INSTALLATION
DETAIL A

STATE OF CALIFORNIA
DEPARTMENT OF TRANSPORTATION

ELECTRICAL SYSTEMS
(CONTROLLER CABINET
FOUNDATION AND PAD DETAILS)

NO SCALE


RSP ES-3C DATED OCTOBER 30, 2015 SUPERSEDES STANDARD PLAN ES-3C DATED MAY 20, 2011 - PAGE 437 OF THE STANDARD PLANS BOOK DATED 2010.

REVISED STANDARD PLAN RSP ES-3C


2010 REVISED STANDARD PLAN RSP ES-3C

Dist	COUNTY	ROUTE	POST MILES TOTAL PROJECT	SHEET No.	TOTAL SHEETS
11	SD	8,15,163	Var	124	131

Theresa Gabriel
 REGISTERED ELECTRICAL ENGINEER
 October 30, 2015
 PLANS APPROVAL DATE
 THE STATE OF CALIFORNIA OR ITS OFFICERS OR AGENTS SHALL NOT BE RESPONSIBLE FOR THE ACCURACY OR COMPLETENESS OF SCANNED COPIES OF THIS PLAN SHEET.

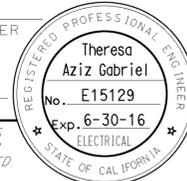


TO ACCOMPANY PLANS DATED 04-25-16

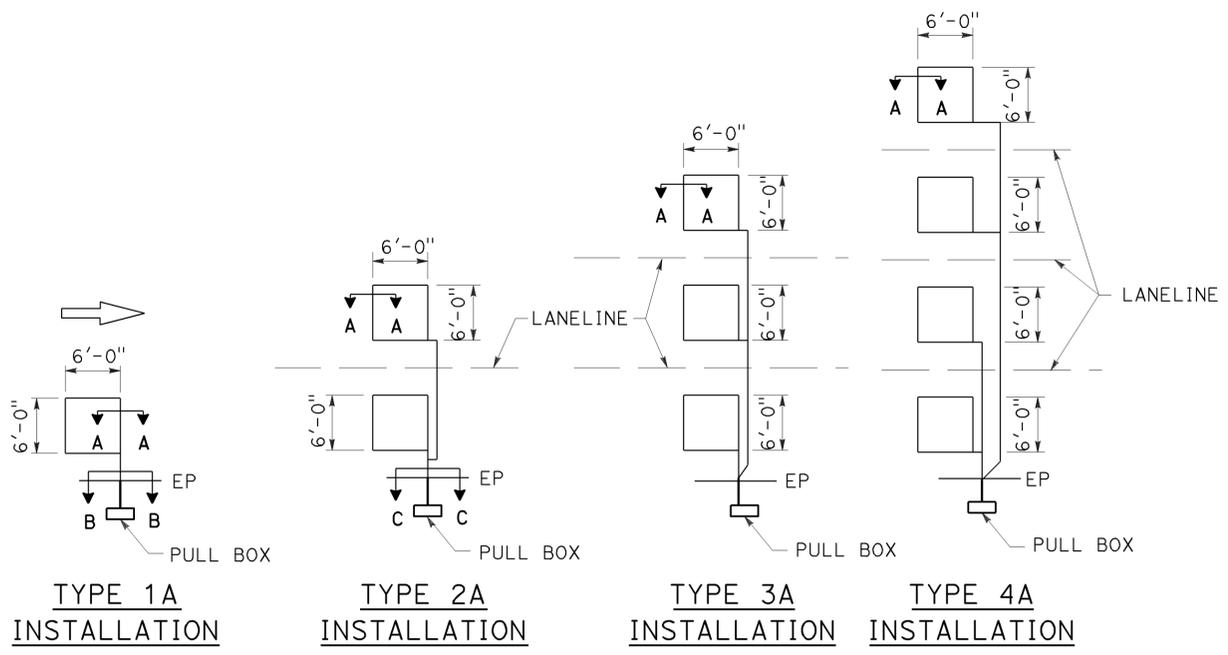


SAWCUT DETAILS

- Type A loop detector configurations illustrated
- 1A thru 4A = 1 Type A loop configuration in each lane.
 - 1B thru 4B = 1 Type B loop configuration in each lane.
 - 1C = 1 Type C loop configuration entering lanes as required.
 - 1D thru 4D = 1 Type D loop configuration in each lane.
 - 1E thru 4E = 1 Type E loop configuration in each lane.
 - 1Q thru 4Q = 1 Type Q loop configuration in each lane.
- Use Type A, B, C, D, E or Q loop detector configurations only when specified or shown on plans.

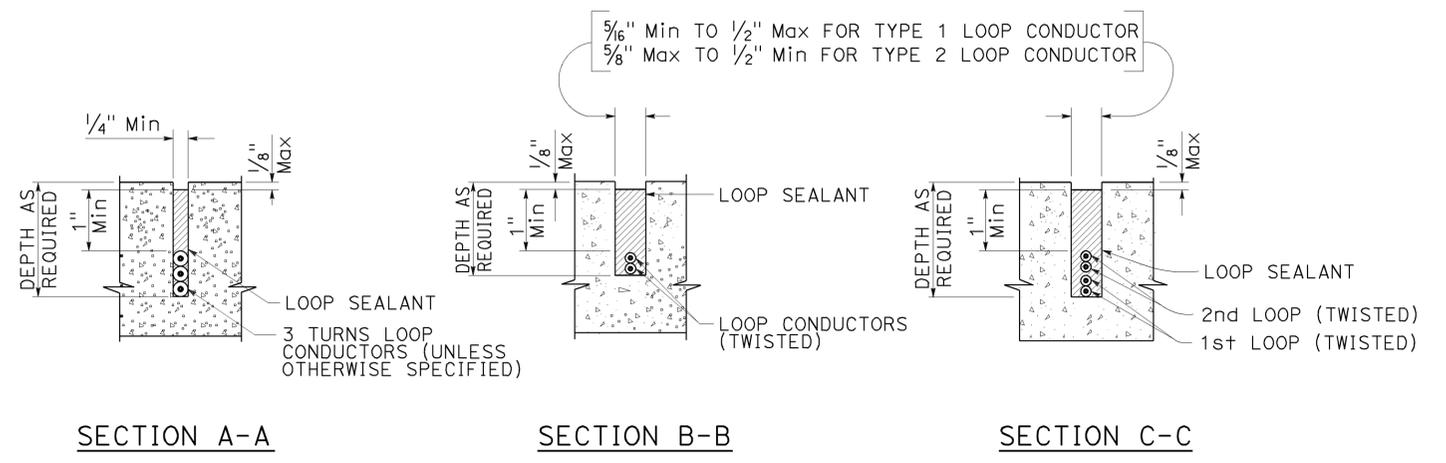


SLOT DETAILS - TYPE 1 AND TYPE 2 LOOP CONDUCTOR

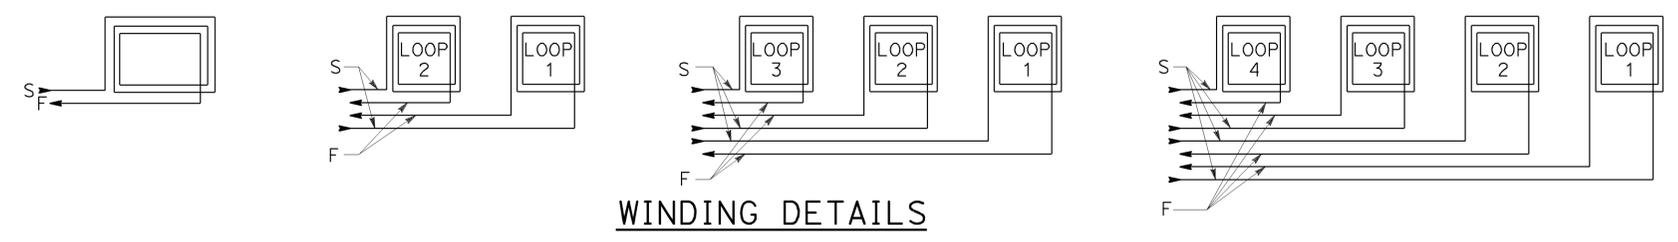

WINDING DETAILS

ABBREVIATIONS:
 S - START
 F - FINISH

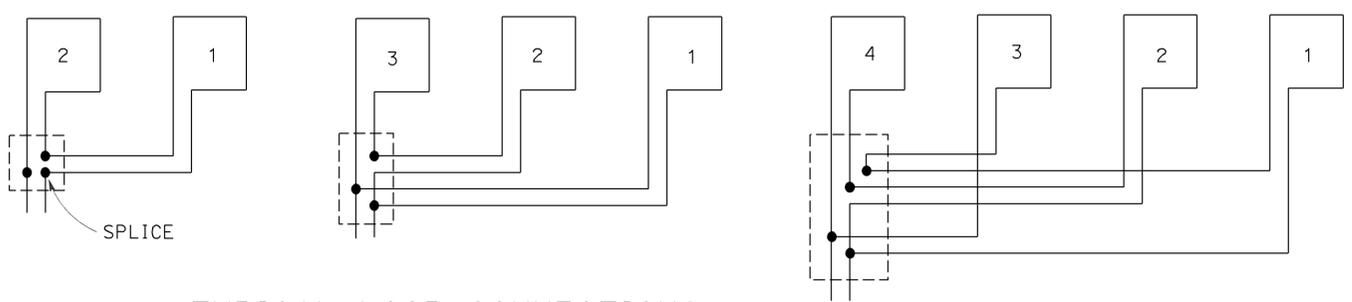

TYPICAL LOOP CONNECTIONS
 Dashed lines represent the pull box

STATE OF CALIFORNIA
 DEPARTMENT OF TRANSPORTATION
**ELECTRICAL SYSTEMS
 (LOOP DETECTORS)**
 NO SCALE

RSP ES-5A DATED OCTOBER 30, 2015 SUPERSEDES STANDARD PLAN ES-5A DATED MAY 20, 2011 - PAGE 448 OF THE STANDARD PLANS BOOK DATED 2010.

REVISED STANDARD PLAN RSP ES-5A


2010 REVISED STANDARD PLAN RSP ES-5A

Dist	COUNTY	ROUTE	POST MILES TOTAL PROJECT	SHEET No.	TOTAL SHEETS
11	SD	8,15,163	Var	125	131


Theresa Gabriel
 REGISTERED ELECTRICAL ENGINEER
 Theresa Aziz Gabriel
 No. E15129
 Exp. 6-30-16
 ELECTRICAL
 STATE OF CALIFORNIA

October 30, 2015
 PLANS APPROVAL DATE
THE STATE OF CALIFORNIA OR ITS OFFICERS OR AGENTS SHALL NOT BE RESPONSIBLE FOR THE ACCURACY OR COMPLETENESS OF SCANNED COPIES OF THIS PLAN SHEET.


TO ACCOMPANY PLANS DATED 04-25-16

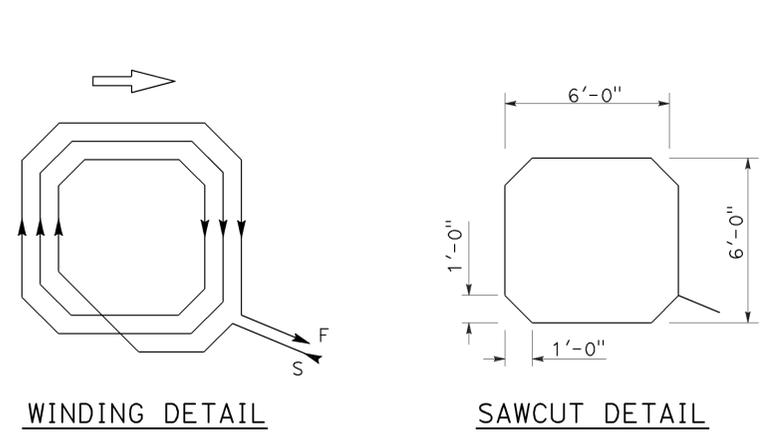


WINDING DETAIL
SAWCUT DETAIL
TYPE A LOOP DETECTOR CONFIGURATION

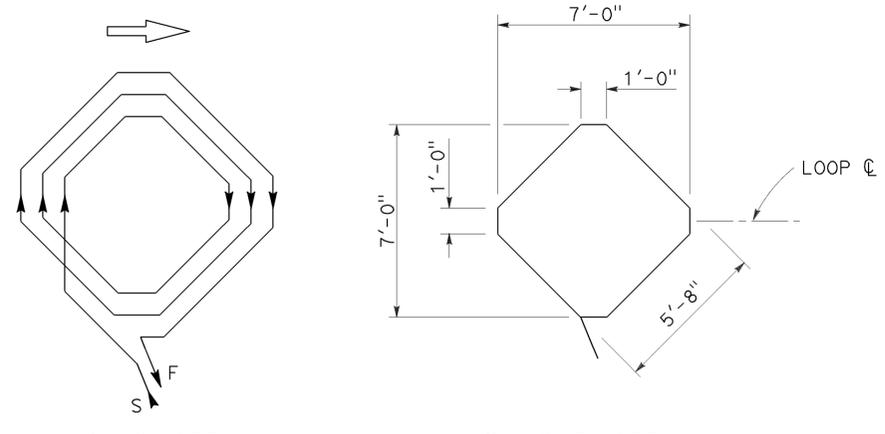


WINDING DETAIL
SAWCUT DETAIL
TYPE B LOOP DETECTOR CONFIGURATION

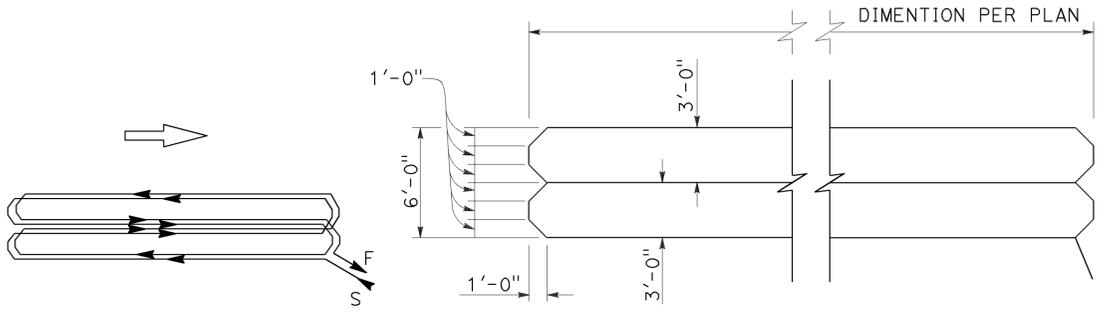


WINDING DETAIL
SAWCUT DETAIL
TYPE C LOOP DETECTOR CONFIGURATION

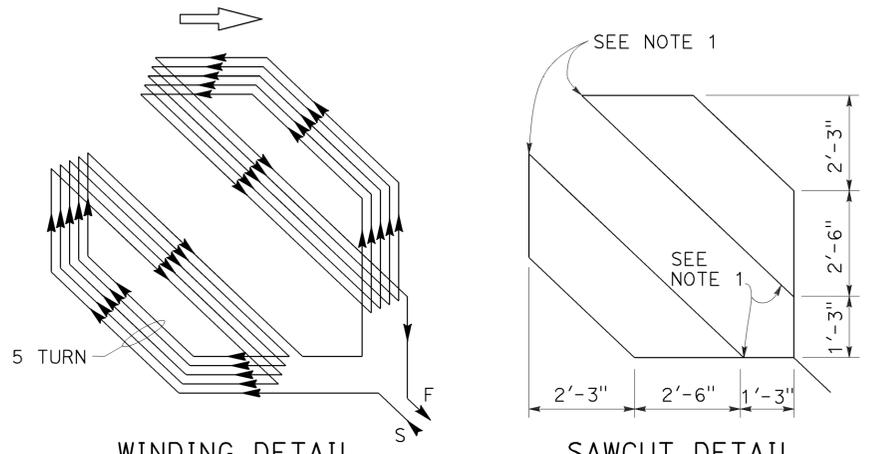


WINDING DETAIL
SAWCUT DETAIL
TYPE D LOOP DETECTOR CONFIGURATION

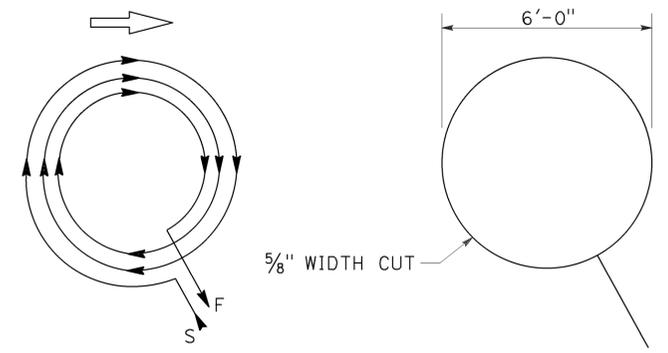

WINDING DETAIL
SAWCUT DETAIL
TYPE E LOOP DETECTOR CONFIGURATION

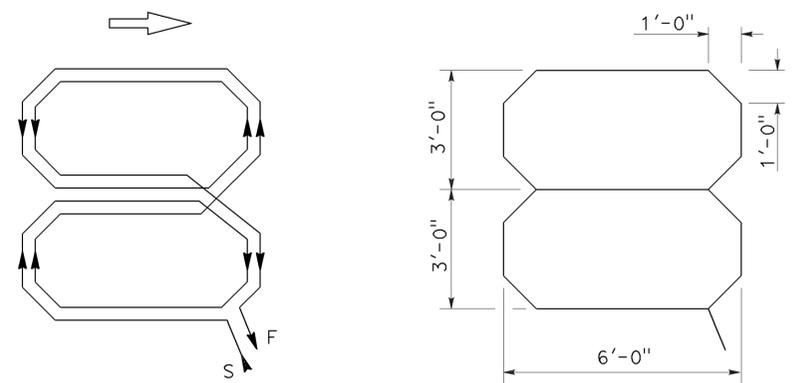

WINDING DETAIL
SAWCUT DETAIL
TYPE Q LOOP DETECTOR CONFIGURATION

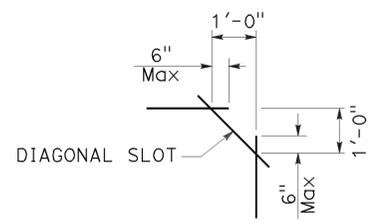

PLAN VIEW OF DIAGONAL SLOT AT CORNERS

- NOTES:**
1. Round corners of acute angle sawcuts to prevent damage to conductors.
 2. Typical distance separating loops from edge to edge is 10' for Type A, B, D and E installation in single lane.
 3. Use Type D loops for limit line detector installations in left turn and bicycle lanes.

STATE OF CALIFORNIA
DEPARTMENT OF TRANSPORTATION
ELECTRICAL SYSTEMS (DETECTORS)
NO SCALE

RSP ES-5B DATED OCTOBER 30, 2015 SUPERSEDES RSP ES-5B DATED JULY 19, 2013 AND STANDARD PLAN ES-5B DATED MAY 20, 2011 - PAGE 449 OF THE STANDARD PLANS BOOK DATED 2010.

REVISED STANDARD PLAN RSP ES-5B


2010 REVISED STANDARD PLAN RSP ES-5B

DIST	COUNTY	ROUTE	POST MILES TOTAL PROJECT	SHEET No.	TOTAL SHEETS
11	SD	8,15,163	Var	126	131


Theresa Gabriel
 REGISTERED ELECTRICAL ENGINEER
 October 30, 2015
 PLANS APPROVAL DATE
THE STATE OF CALIFORNIA OR ITS OFFICERS OR AGENTS SHALL NOT BE RESPONSIBLE FOR THE ACCURACY OR COMPLETENESS OF SCANNED COPIES OF THIS PLAN SHEET.

Theresa
 Aziz Gabriel
 No. E15129
 Exp. 6-30-16
 ELECTRICAL
 STATE OF CALIFORNIA


TO ACCOMPANY PLANS DATED 04-25-16

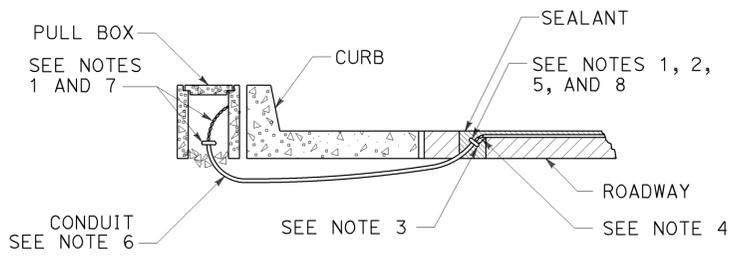


**TYPE A
CURB TERMINATION DETAIL**

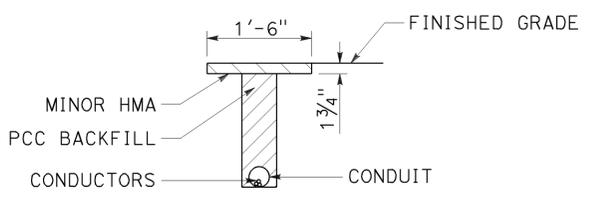


**"T" TRENCH
DETAIL I**

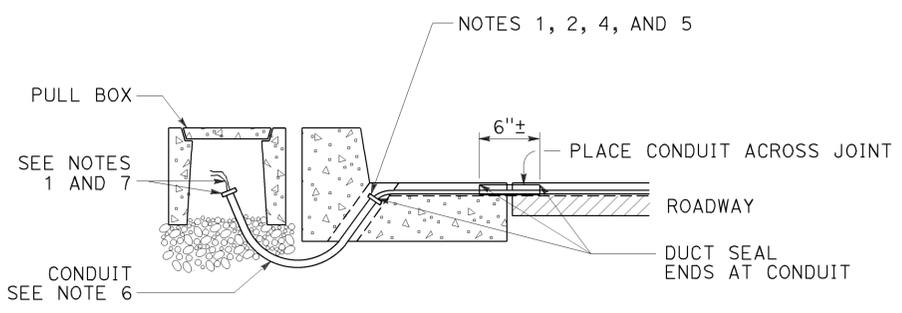

CROSS SECTION

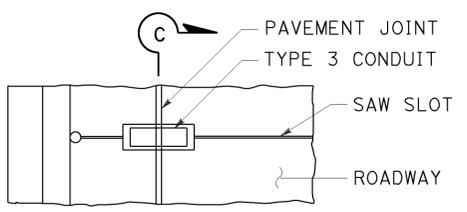


PLAN VIEW

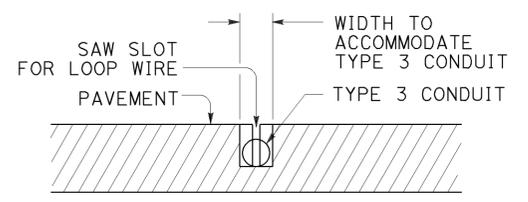


SECTION C-C


**TYPE B
CURB TERMINATION DETAIL**

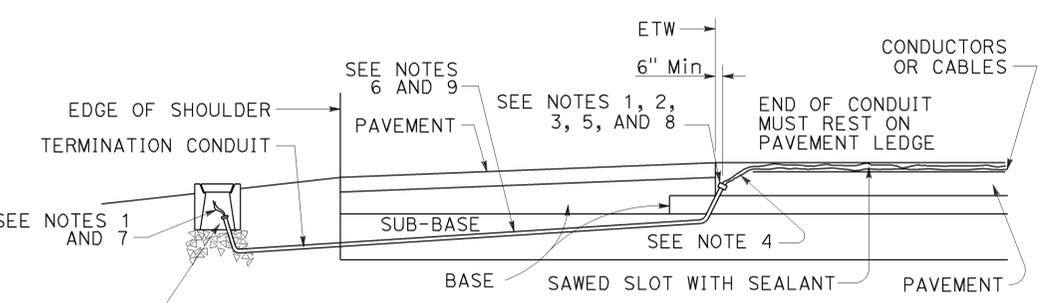


CROSS SECTION

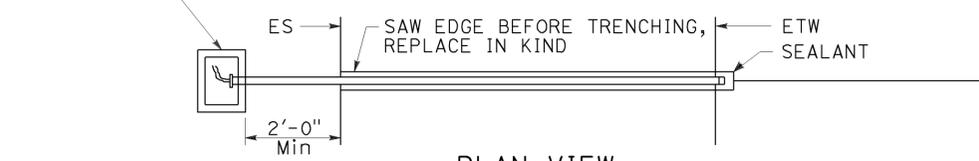


**PLAN VIEW
SHOULDER TERMINATION DETAILS**

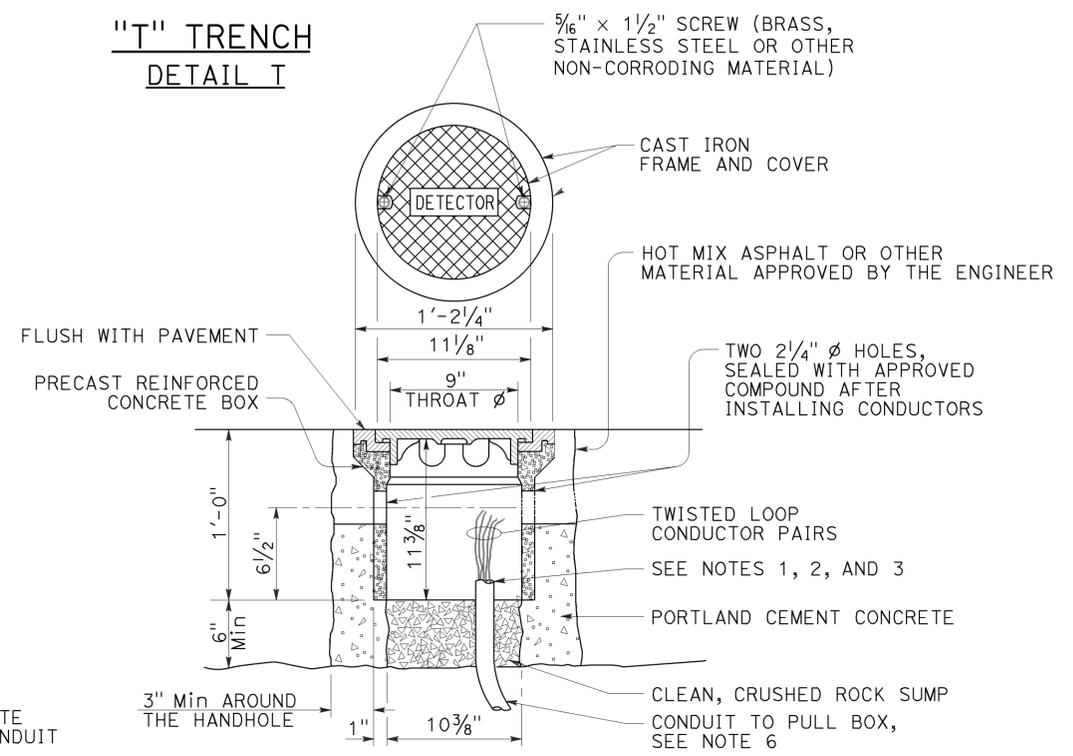


DETECTOR HANDHOLE DETAIL

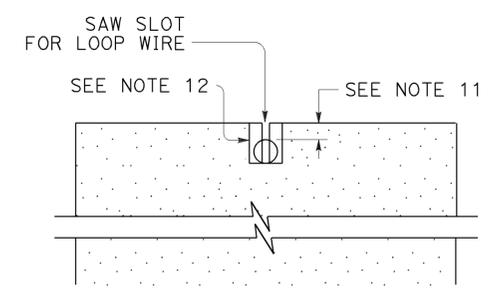

SECTION A-A

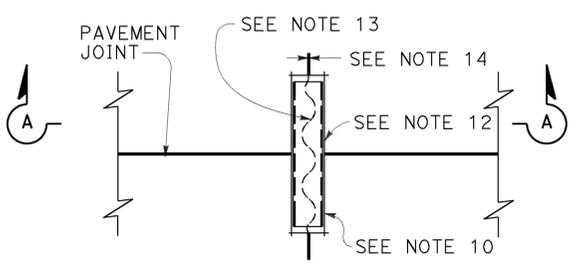

**PLAN VIEW
TYPICAL LOOP LEAD-IN DETAIL
AT PAVEMENT JOINT**

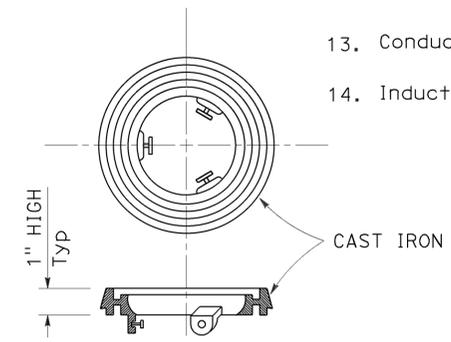

LOCKING GRADE RING

STATE OF CALIFORNIA
DEPARTMENT OF TRANSPORTATION

**ELECTRICAL SYSTEMS
(CURB AND SHOULDER TERMINATION,
TRENCH, AND HANDHOLE DETAILS)**

NO SCALE


RSP ES-5D DATED OCTOBER 30, 2015 SUPERSEDES RSP ES-5D DATED JULY 19, 2013 AND STANDARD PLAN ES-5D DATED MAY 20, 2011 - PAGE 451 OF THE STANDARD PLANS BOOK DATED 2010.

REVISED STANDARD PLAN RSP ES-5D


2010 REVISED STANDARD PLAN RSP ES-5D

TO ACCOMPANY PLANS DATED 04-25-16



- NOTES:**
- Standards shall be 10'-0" ± 2" for vehicle signals and 7'-0" ± 2" for pedestrian signals unless shorter pole is noted on project plans.
 - Top of standards shall be 4 1/2" OD.
 - Conduits shall extend 2" maximum above finished surface of foundation and for Types 1-A, 1-C and 1-D shall be sloped toward handhole.
 - Anchor bolts shall be bonded to conduit or grounding conductor.
 - For additional notes and details, see Revised Standard Plans RSP ES-7M and RSP ES-7N.
 - Pour foundation concrete against undisturbed soil.
 - For standards with handhole, locate in the downstream side of traffic.
 - Coupling nuts to be used only when shown or specified on project plans.

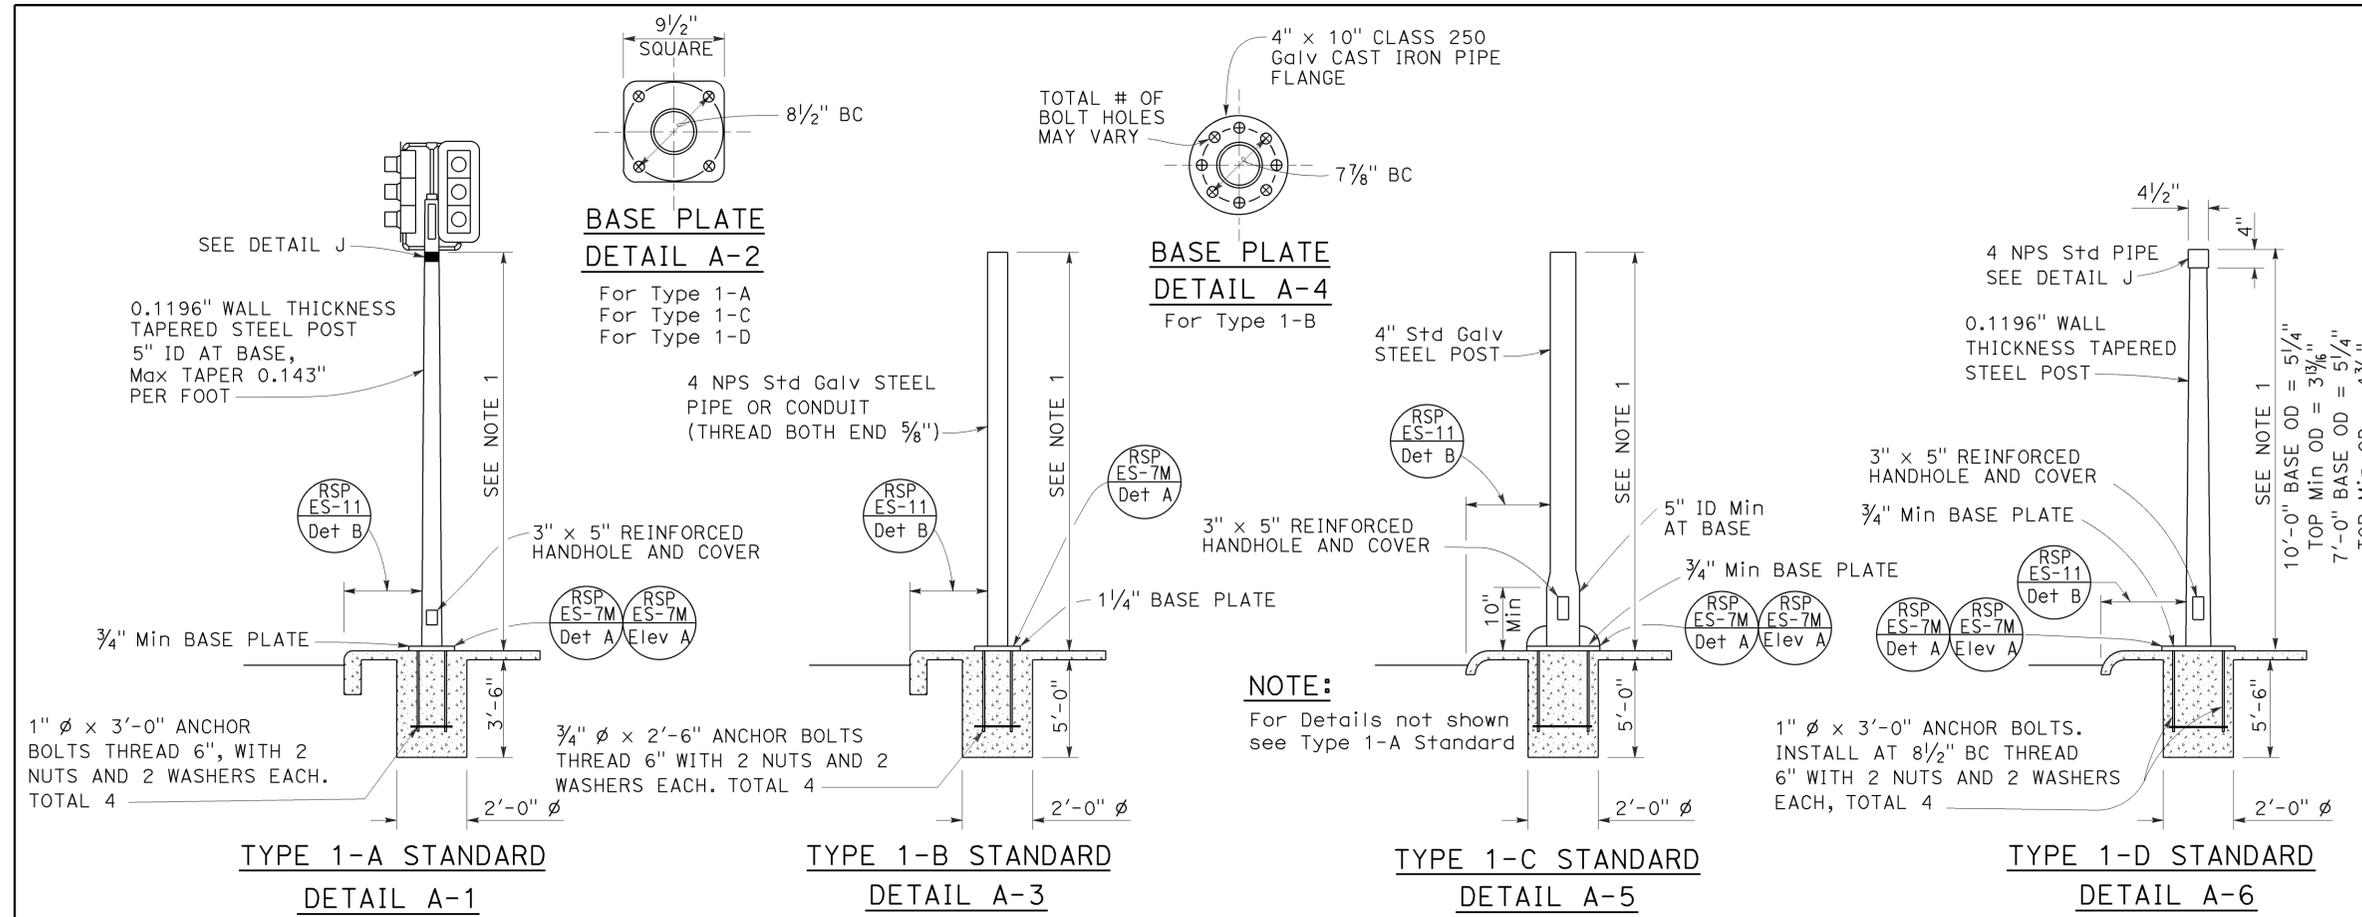

**TYPE 1 SIGNAL STANDARDS
DETAIL A**

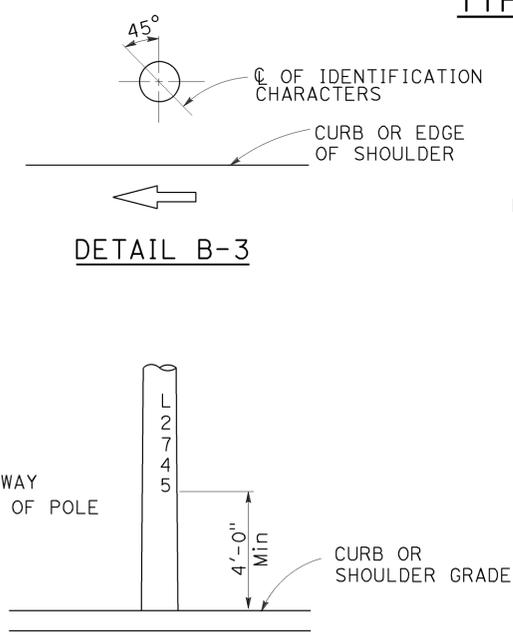

**LOCATION OF EQUIPMENT IDENTIFICATION CHARACTERS ON STANDARDS AND POSTS
DETAIL B**

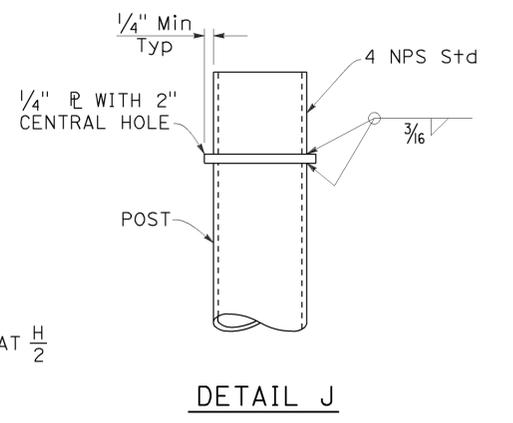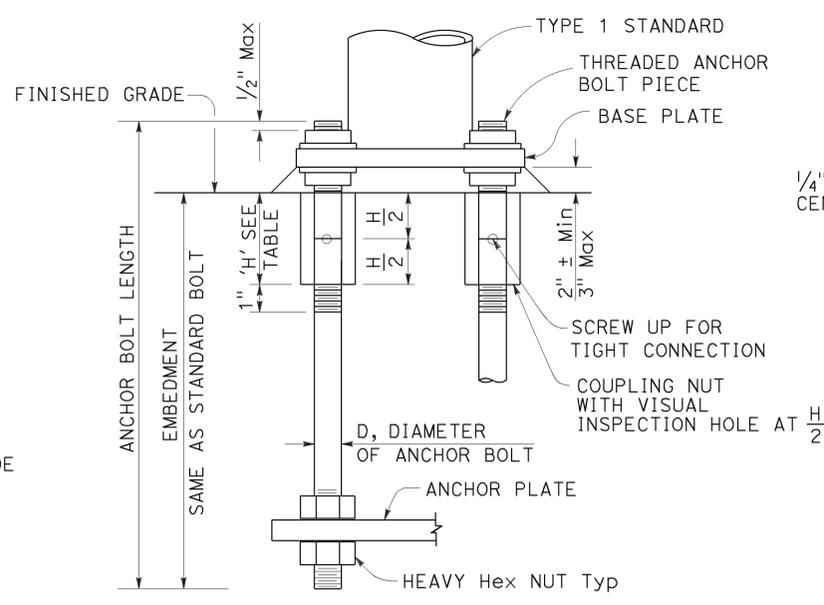

BOLT DIAMETER	NUT TABLE THICKNESS 'H'
3/4"	2 1/4"
1"	3"

STATE OF CALIFORNIA
DEPARTMENT OF TRANSPORTATION


**ELECTRICAL SYSTEMS
(SIGNAL AND LIGHTING STANDARD, TYPE 1
AND EQUIPMENT IDENTIFICATION CHARACTERS)**

2010 REVISED STANDARD PLAN RSP ES-7B


Dist	COUNTY	ROUTE	POST MILES TOTAL PROJECT	SHEET No.	TOTAL SHEETS
11	SD	8,15,163	Var	128	131

Stanley P. Johnson
 REGISTERED CIVIL ENGINEER
 October 30, 2015
 PLANS APPROVAL DATE
THE STATE OF CALIFORNIA OR ITS OFFICERS OR AGENTS SHALL NOT BE RESPONSIBLE FOR THE ACCURACY OR COMPLETENESS OF SCANNED COPIES OF THIS PLAN SHEET.


TO ACCOMPANY PLANS DATED 04-25-16

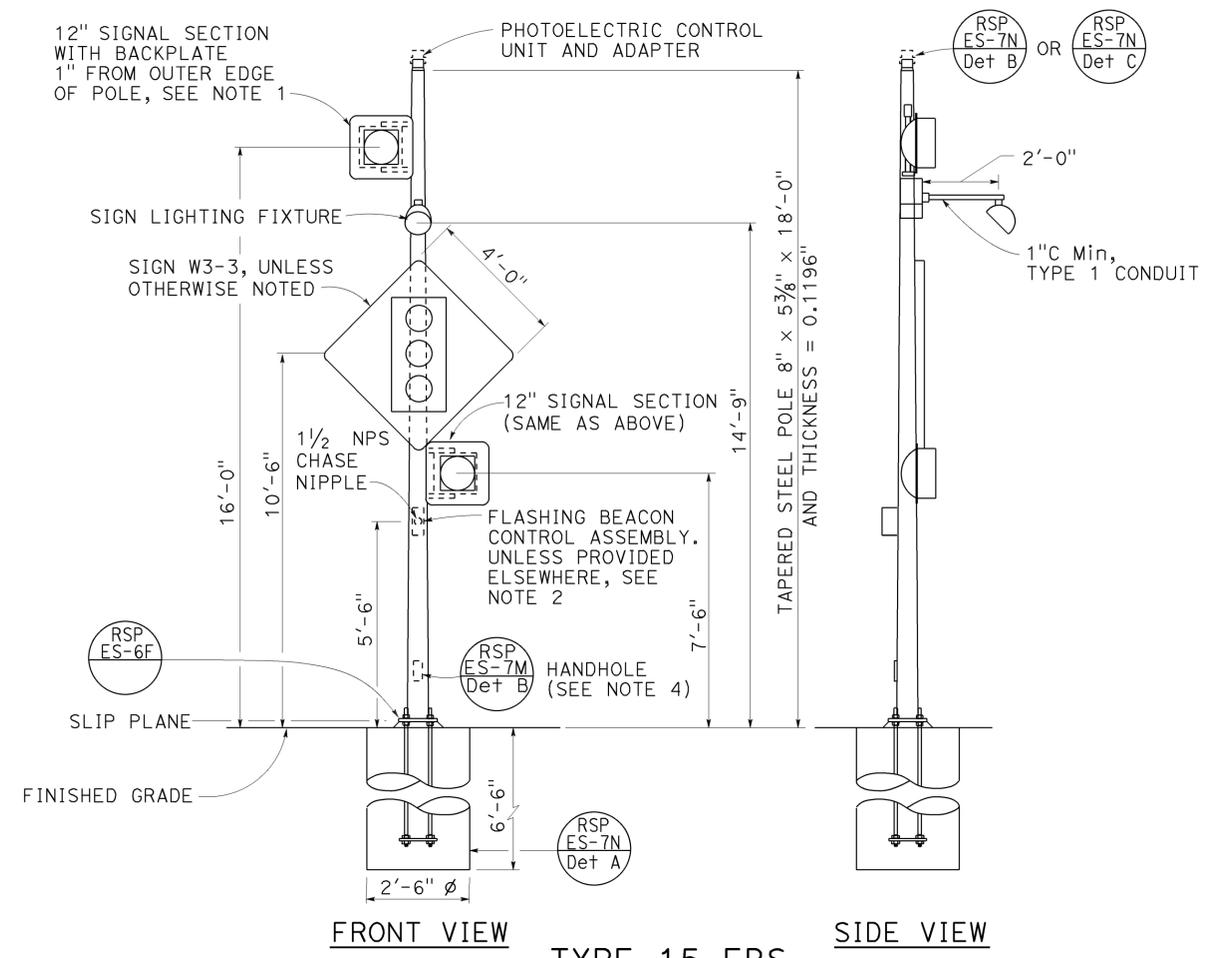

TYPE 15-FBS
ADVANCE FLASHING BEACON WITH SLIP BASE INSTALLATION
DETAIL A

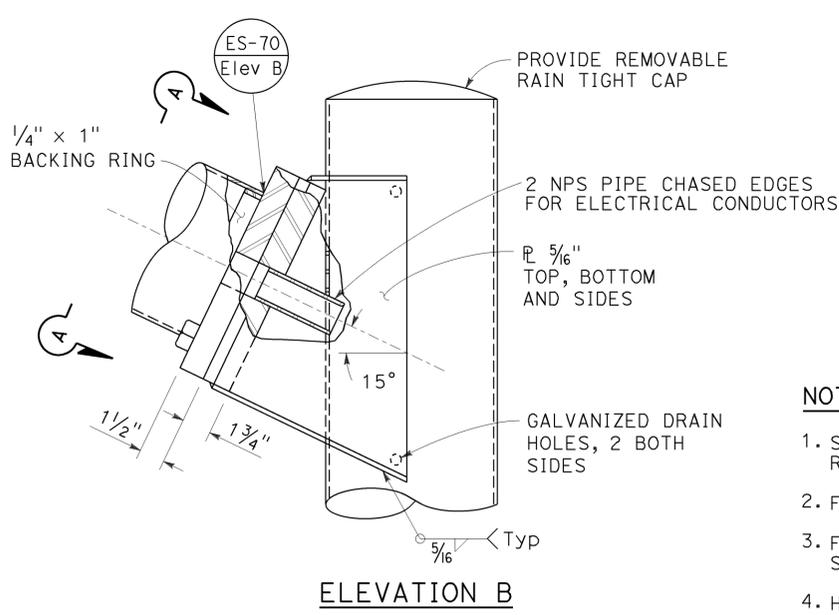


ELEVATION B

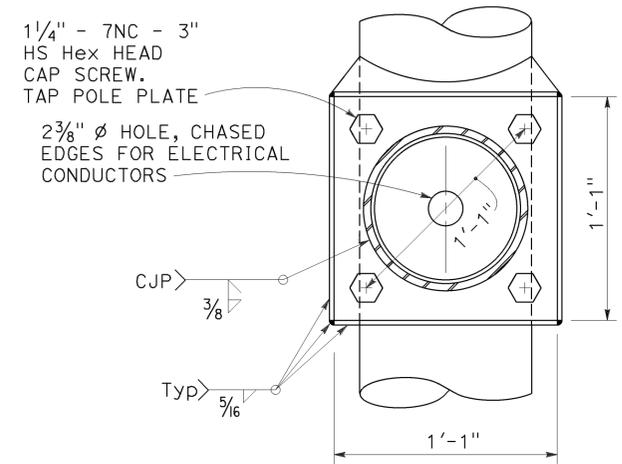


VIEW A-A
FLASHING BEACON MAST ARM
CONNECTION DETAIL
DETAIL B

NOTES:


1. See Revised Standard Plans RSP ES-4A and RSP ES-4D for attachment fitting details.
2. For wiring diagram, see Standard Plan ES-14B.
3. For additional notes and details, see Revised Standard Plans RSP ES-7M and RSP ES-7N.
4. Handhole shall be located on the downstream side of traffic.
5. See project plans for type of standard to be installed.

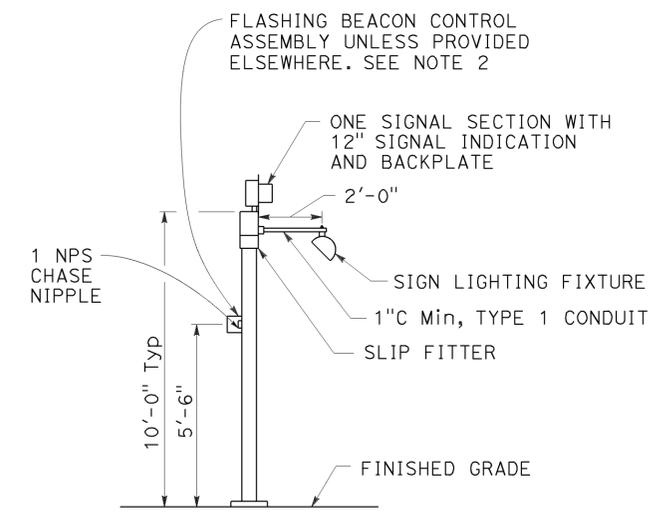

TYPE 1-A, 1-B, 1-C, AND 1-D
ADVANCE FLASHING
BEACON INSTALLATION
DETAIL D
 See Note 5

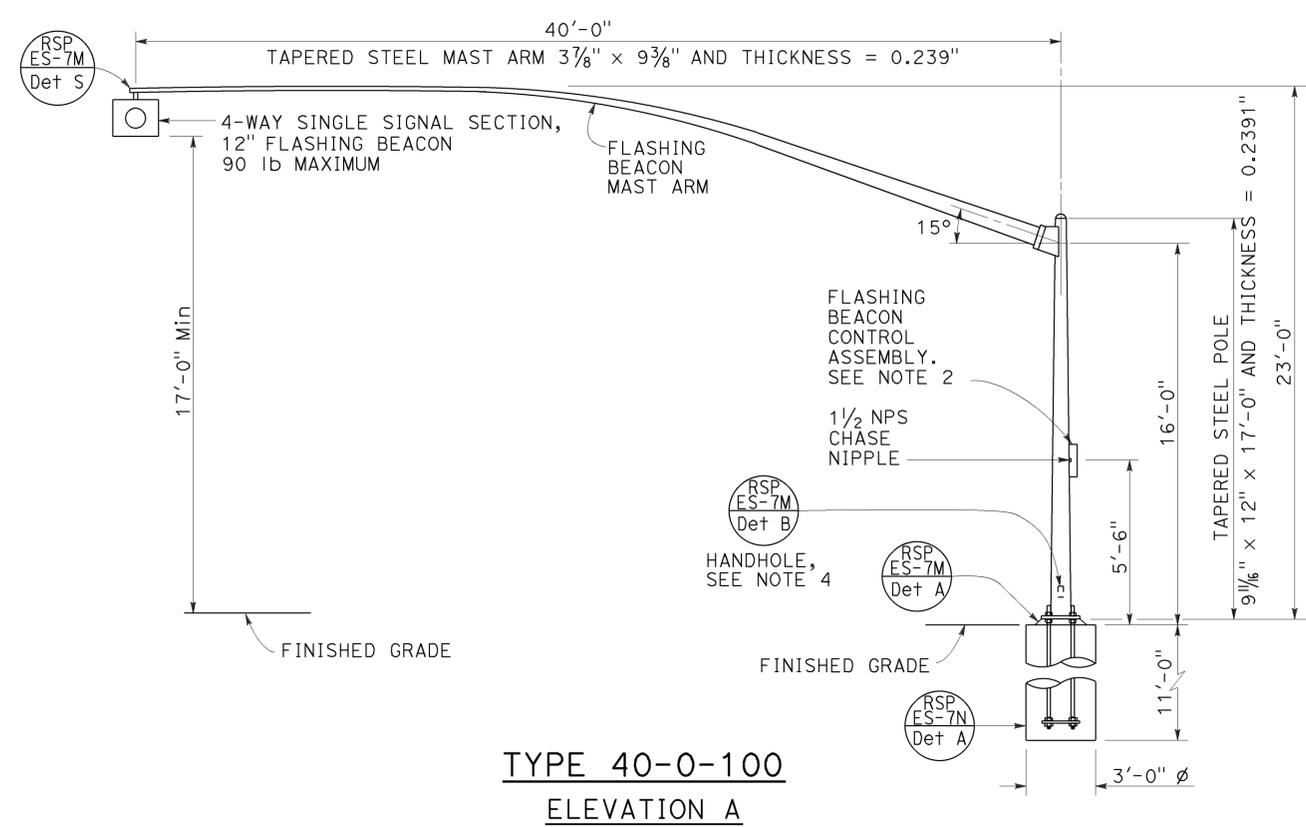

TYPE 40-0-100
ELEVATION A

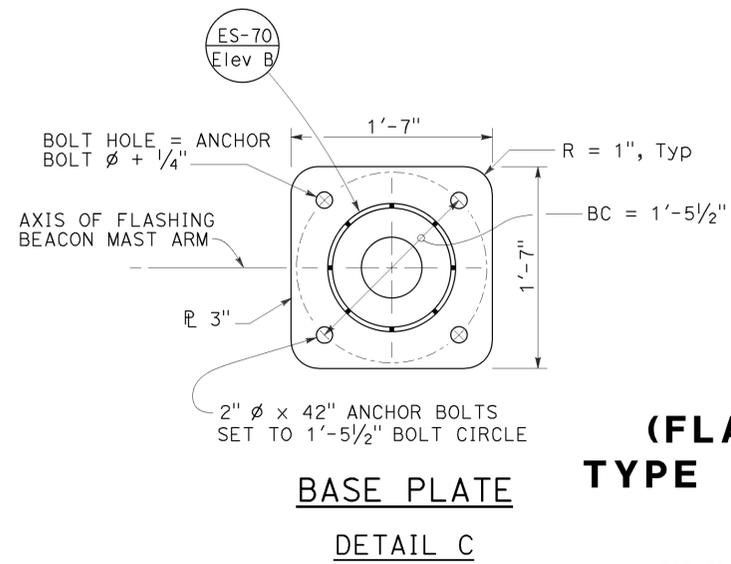

BASE PLATE
DETAIL C

ELECTRICAL SYSTEMS
(FLASHING BEACON ON A TYPE 1, TYPE 15-FBS, AND TYPE 40 STANDARD)
 NO SCALE


RSP ES-7J DATED OCTOBER 30, 2015 SUPERSEDES RSP ES-7J DATED JULY 19, 2013 AND STANDARD PLAN ES-7J DATED MAY 20, 2011 - PAGE 471 OF THE STANDARD PLANS BOOK DATED 2010.

2010 REVISED STANDARD PLAN RSP ES-7J


DIST	COUNTY	ROUTE	POST MILES TOTAL PROJECT	SHEET NO.	TOTAL SHEETS
11	SD	8,15,163	Var	129	131

Theresa Gabriel
 REGISTERED ELECTRICAL ENGINEER
 October 30, 2015
 PLANS APPROVAL DATE
THE STATE OF CALIFORNIA OR ITS OFFICERS OR AGENTS SHALL NOT BE RESPONSIBLE FOR THE ACCURACY OR COMPLETENESS OF SCANNED COPIES OF THIS PLAN SHEET.


TO ACCOMPANY PLANS DATED 04-25-16

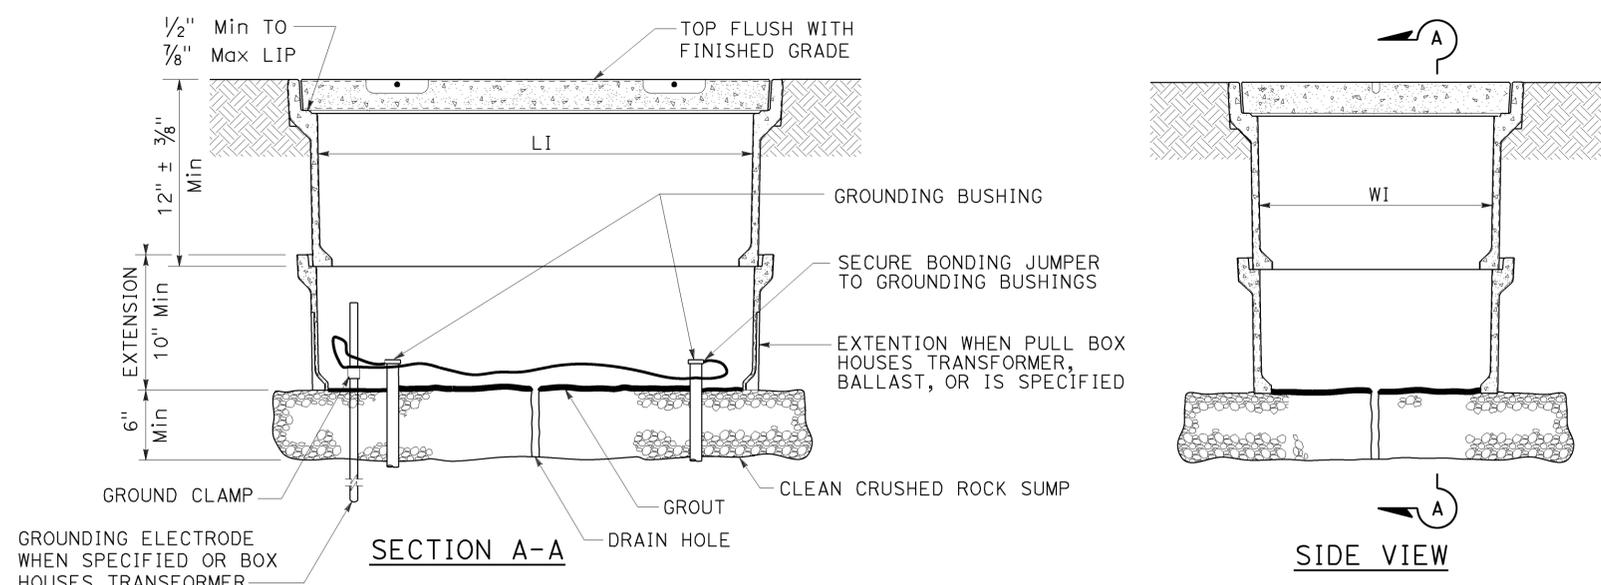


INSTALLATION DETAILS
DETAIL A

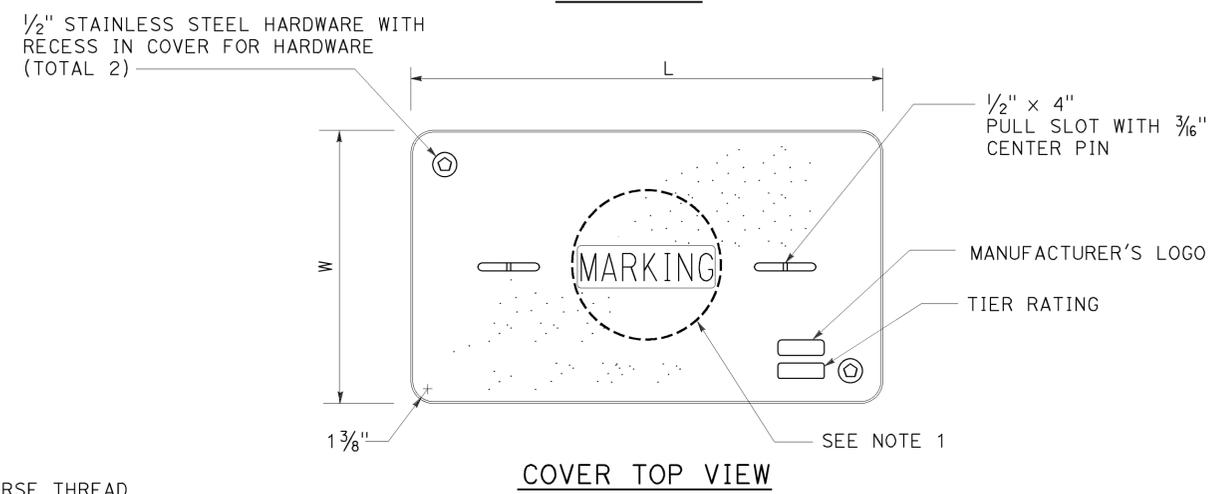

COVER TOP VIEW

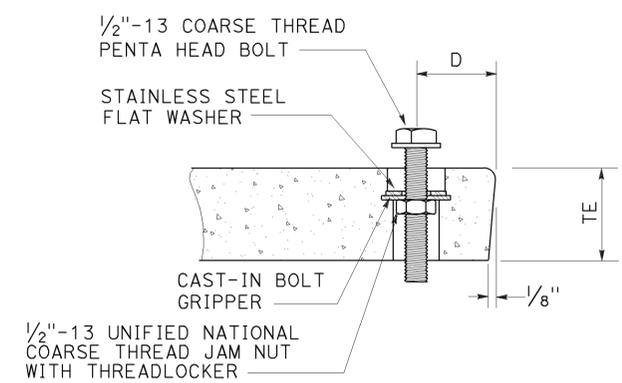

TYPICAL COVER CAPTIVE BOLT
OR SIMILAR

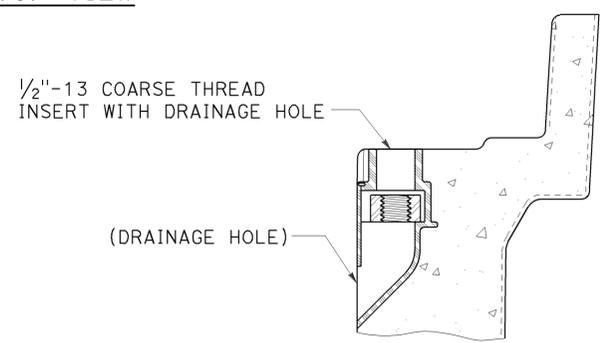

TYPICAL THREADED INSERT
OR SIMILAR

NOTES:

- Pull box covers shall be marked as follows: "SERVICE" Service circuits between service point and service disconnect; "SPRINKLER-CONTROL" sprinkler control circuits, 50 V or less; "CALTRANS" on all pull boxes, except pull boxes marked "SPRINKLER-CONTROL"; and "TELEPHONE" Telephone service;
 - No. 3 1/2 pull box.
 - "SIGNAL" - Traffic signal circuits with or without lighting or sign lighting circuits.
 - "LIGHTING" - Lighting or sign lighting circuits where voltage is under 600 V.
 - No. 5, 6, 9 or 9A pull box.
 - "TRAFFIC SIGNAL" - Traffic signal circuits with or without lighting or sign lighting circuits.
 - "LIGHTING" - Lighting or sign lighting circuits where voltage is under 600 V.
 - "LIGHTING-HIGH VOLTAGE" - Lighting or sign lighting circuits where voltage is above 600 V.
 - "IRRIGATION" - Circuits to irrigation controller 120 V or more.
 - "RAMP METER" - Ramp meter circuits.
 - "COUNT STATION" - Count or speed monitor circuits.
 - "COMMUNICATIONS" - Communication circuits.
 - "TOS COMMUNICATIONS" - TOS communication line.
 - "TOS POWER" - TOS power.
 - "TDC POWER" - Telephone demarcation cabinet power.
 - "CCTV" - Closed circuit television circuits.
 - "TMS" - Traffic monitoring station circuits.
 - "CMS" - Changeable message sign circuits.
 - "HAR" - Highway advisory radio circuits.
 - "BOOSTER PUMP" - Booster pump circuit.
- The nominal dimensions of the opening in which the cover sets shall be the same as the cover dimensions except the length and width dimensions shall be 1/8" greater.
- Covers and boxes shall be interchangeable with California standard male and female gages. When interchanged with a standard male or female gage, the top surfaces shall be flush within 1/8". Top outside radius of covers and pull boxes shall have a 1/8" radius.
- Pull box extension may be another pull box as long as the bottom edge of the pull box can fit into the cover opening.
- Dimensions for the cover for non-traffic pull box are nominal values.


DIMENSION TABLE										
PULL BOX	PULL BOX				COVER					
	MINIMUM DEPTH BOX	MINIMUM DEPTH EXTENSION	MINIMUM WEIGHT	LI Min	WI Min	TE	D	L	W	MINIMUM WEIGHT
No. 3 1/2	12"	N/A	40 lb	1' - 3"	9"	1 3/4"	1 3/4"	1'-3 1/4" - 1'-3 3/8"	10" - 10 1/8"	30 lb
No. 5	12"	10"	55 lb	1' - 8"	11"	2"	1 3/4"	1'-11 1/4"	1'-1 3/4"	60 lb
No. 6	12"	10"	70 lb	2' - 4 1/4"	1' - 3 1/4"	2"	2"	2'-6 1/2"	1'-5 1/2"	85 lb

STATE OF CALIFORNIA
DEPARTMENT OF TRANSPORTATION
ELECTRICAL SYSTEMS
(NON-TRAFFIC PULL BOX)
NO SCALE

RSP ES-8A DATED OCTOBER 30, 2015 SUPERSEDES RSP ES-8A DATED JULY 19, 2013 AND RSP ES-8A DATED JANUARY 20, 2012 THAT SUPPLEMENTS THE STANDARD PLANS BOOK DATED 2010.


REVISED STANDARD PLAN RSP ES-8A

2010 REVISED STANDARD PLAN RSP ES-8A

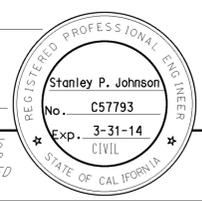


TO ACCOMPANY PLANS DATED 04-25-16


STANDARD TYPE	SETBACK (DIMENSION A)
32	30'-0" (Min)
31	20'-0" (Min)
15, 15D, 15-SB, 21, 21D, 30	ARM LENGTH (Min)

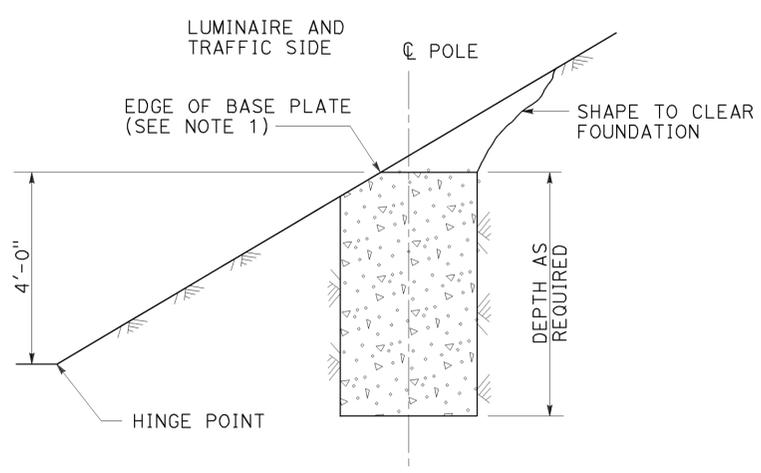

CUT SLOPES
STEEPER THAN 4:1,
LESS THAN 2:1
DETAIL A-1
 See Note 2 and 3

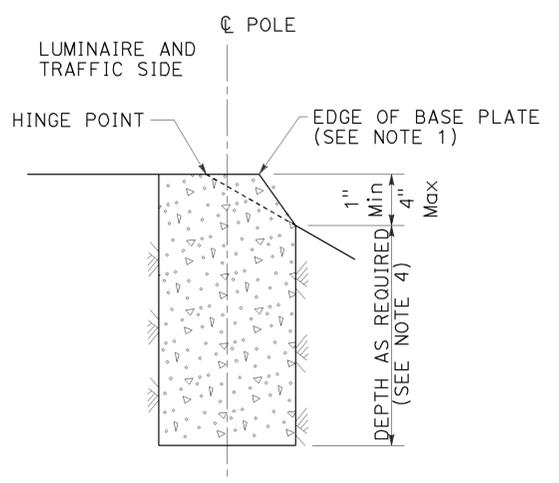

FILL SLOPES
STEEPER THAN 4:1,
LESS THAN 2:1
DETAIL A-2
 See Note 2 and 3

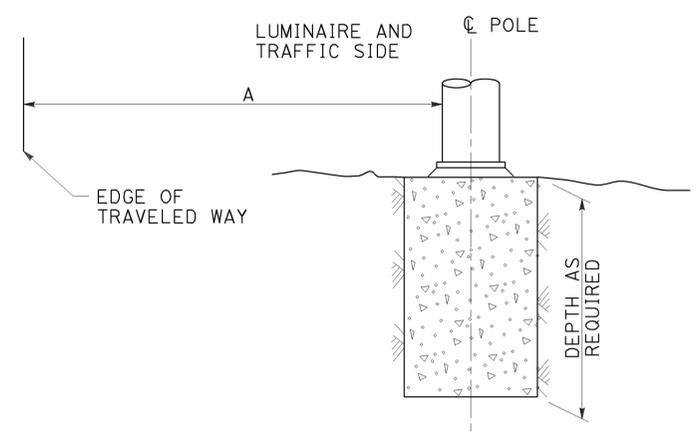


FLAT SECTIONS, CUT OR FILL SLOPES
4:1 OR FLATTER
DETAIL A-3
 See Note 2


FOUNDATIONS ADJACENT TO ALL ROADWAYS EXCEPT
IN SIDEWALK, MEDIAN AND ISLAND AREAS
DETAIL A

NOTES:

1. Where a portion of the foundation is above grade, the top edges shall have a 1" chamfer.
2. Slopes shall be horizontal to vertical ratio (Horizontal : Vertical).
3. Horizontal setbacks on cut and fill slopes steeper than 4:1 shall not exceed the distance shown for flat sections.
4. CIDH embedment depth shall be increased beyond standard depths by the diameter of the CIDH.

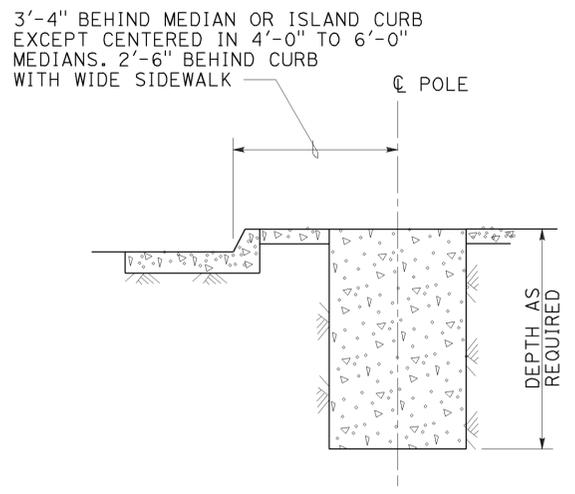

MEDIAN, ISLAND
OR WIDE SIDEWALK
DETAIL B-1
 7' Wide and wider

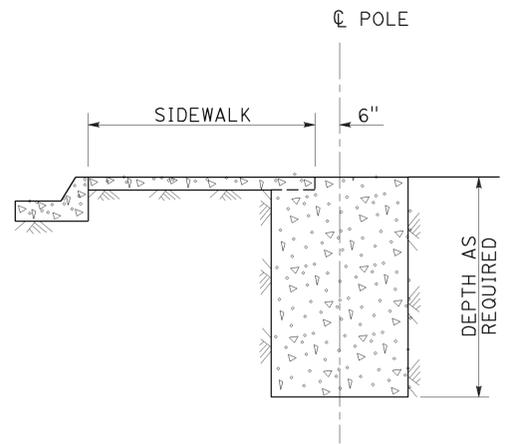

NARROW SIDEWALK
DETAIL B-2
 Less than 7' wide

FOUNDATIONS IN SIDEWALK, MEDIAN AND ISLAND AREAS
DETAIL B

STATE OF CALIFORNIA
 DEPARTMENT OF TRANSPORTATION
ELECTRICAL SYSTEMS
(FOUNDATION INSTALLATIONS)
 NO SCALE

RSP ES-11 DATED JULY 19, 2013 SUPERSEDES STANDARD PLAN ES-11
 DATED MAY 20, 2011 - PAGE 488 OF THE STANDARD PLANS BOOK DATED 2010.


Dist	COUNTY	ROUTE	POST MILES TOTAL PROJECT	SHEET No.	TOTAL SHEETS
11	SD	8,15,163	Var	131	131

Theresa Gabriel
 REGISTERED ELECTRICAL ENGINEER
 Theresa Aziz Gabriel
 No. E15129
 Exp. 6-30-16
 ELECTRICAL
 STATE OF CALIFORNIA

October 30, 2015
 PLANS APPROVAL DATE


THE STATE OF CALIFORNIA OR ITS OFFICERS OR AGENTS SHALL NOT BE RESPONSIBLE FOR THE ACCURACY OR COMPLETENESS OF SCANNED COPIES OF THIS PLAN SHEET.

TO ACCOMPANY PLANS DATED 04-25-16

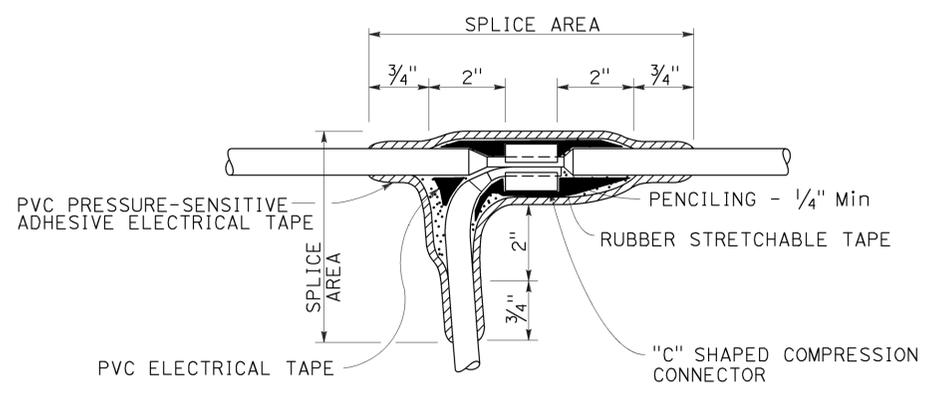

TYPE C SPLICE

See Note 3

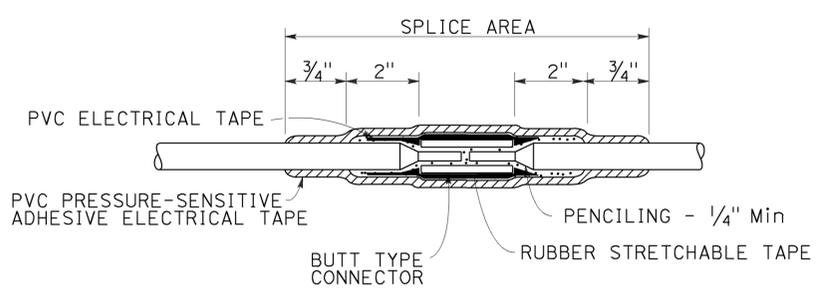


TYPE S SPLICE

See Note 4


NOTES:

1. Dimensions are minimum.
2. Rubber tapes shall be rolled after application.
3. Between 1 free-end and 1 through conductor.
4. Between 2 free-end conductors.
5. Between 3 free-end conductors.

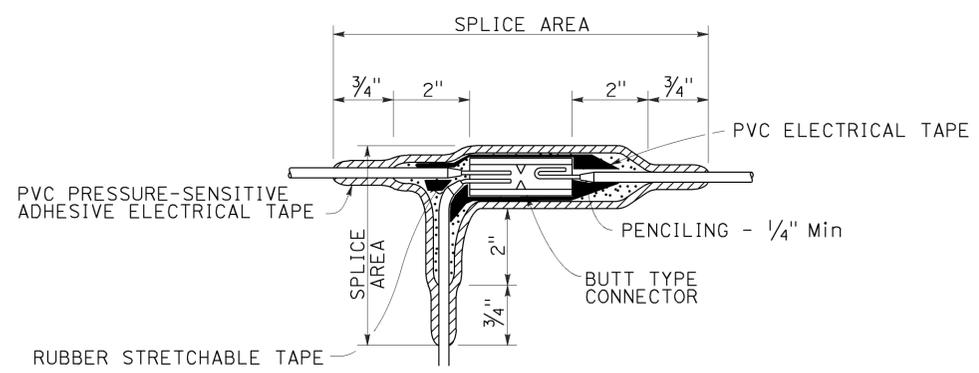

TYPE ST SPLICE

See Note 5

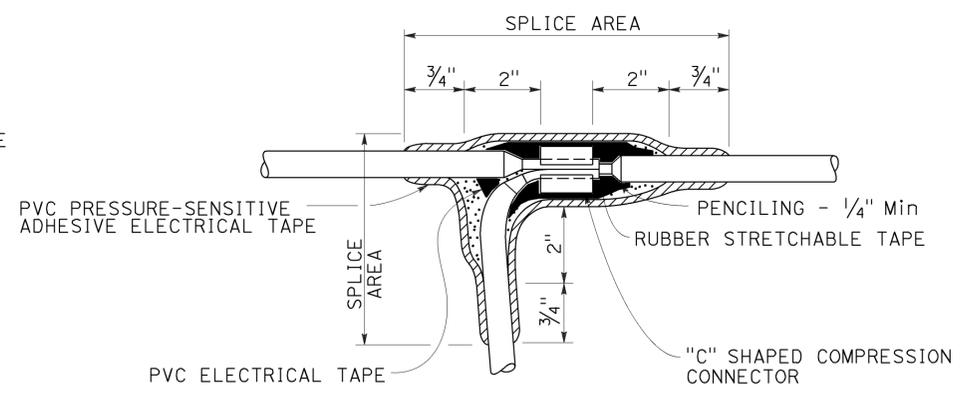

TYPE T SPLICE

See Note 5

STATE OF CALIFORNIA
 DEPARTMENT OF TRANSPORTATION
**ELECTRICAL SYSTEMS
 (SPlicing DETAILS)**
 NO SCALE

RSP ES-13A DATED OCTOBER 30, 2015 SUPERSEDES STANDARD PLAN ES-13A DATED MAY 20, 2011 - PAGE 491 OF THE STANDARD PLANS BOOK DATED 2010.

REVISED STANDARD PLAN RSP ES-13A

2010 REVISED STANDARD PLAN RSP ES-13A